

PRELIMINARY SURVEY COORDINATE AND CURVE DATA - WILLISTON - US 2											STATE	PROJECT NO.		SECTION NO.	SHEET NO.
										ND	NH-NHU-7-002(156)022		81	1	
HORIZONTAL ALIGNMENT				CURVE DATA		US PUBLIC LAND SURVEY DATA				SURVEY CONTROL POINTS					
PNT	STATION	NORTHING	EASTING	ARC DEFINITION		DESC.	SEC-TWP-RGE	NORTHING	EASTING	PNT	NORTHING	EASTING	ELEV	STATION	OFFSET
WILLISTON - US 2 - (Chain: EX2)						W 1/4 Cor 1	T-155-N R-101-W	481426.78	1207761.23	CONTROL POINT DESCRIPTION					
Begin	1130+09.41	447131.91	1206345.33	C2	C3	NW Cor Sec 12	T-155-N R-101-W	478787.94	1207656.36	PRIMARY CONTROL - US 2					
PC	1170+85.83	451204.81	1206514.75	PI STA= 1178+71.63	PI STA= 1217+86.20	W 1/4 Cor 12	T-155-N R-101-W	476149.36	1207555.59						
PI C2	1178+71.63	451989.93	1206547.41	Delta = 10° 58' 03" LT	Delta = 27° 13' 40" RT	SW Cor Sec 12	T-155-N R-101-W	473510.90	1207454.58						
PT	1186+52.63	452766.93	1206430.10	D _a = 0° 42' 00"	D _a = 1° 00' 00"	W 1/4 Cor 13	T-155-N R-101-W	470869.75	1207352.45	5/8" Rebar w/ 2" Alum CAP Stamped GPS 2-1					
PC	1203+98.59	454493.32	1206169.45	R = 8,185.16'	R = 5,729.65'	SW Cor Sec 13	T-155-N R-101-W	468234.03	1207253.14	GPS 2-2	458307.37	1206934.80	2050.49	1243+47.64	- 156' RT
PI C3	1217+86.20	455865.39	1205962.30	T = 785.80'	T = 1,387.62'	W 1/4 Cor 24	T-155-N R-101-W	465595.75	1207147.07	5/8" Rebar w/ 2" Alum CAP Stamped GPS 2-2					
PT	1231+21.39	457180.20	1206405.86	L = 1,566.80'	L = 2,722.81'	SW Cor Sec 24	T-155-N R-101-W	462957.53	1207041.03	GPS 2-3	469637.62	1207013.89	1976.98	1356+49.36	- 292' LT
PC	1239+35.41	457951.50	1206666.07	C4		W 1/4 Cor 25	T-155-N R-101-W	460325.37	1206930.21	5/8" Rebar w/ 2" Alum CAP Stamped GPS 2-3					
PI C4	1248+08.36	458778.66	1206945.11	PI STA= 1248+08.36		SW Cor Sec 25	T-155-N R-101-W	457693.28	1206819.39	GPS 2-4	481385.96	1207913.32	2022.10	1474+23.56	-154' RT
PT	1256+67.99	459651.38	1206965.17	Delta = 17° 19' 32" LT		S 1/4 Cor 11	T-156-N R-101-W	505336.03	1206084.99	5/8" Rebar w/ 2" Alum CAP Stamped GPS 2-4					
End	1275+68.35	461551.23	1207008.83	D _a = 1° 00' 00"		S 1/4 Cor 12	T-156-N R-101-W	505104.88	1211368.88	GPS 2-5	492046.30	1208343.34	2041.96	1580+92.63	- 150' RT
Rec Sec Cor	1289+75.01	462957.53	1207041.03	R = 5,729.65'		NW Cor Sec 13	T-156-N R-101-W	505217.90	1208726.63	5/8" Rebar w/ 2" Alum CAP Stamped GPS 2-5					
Rec Qtr Cor	1316+15.36	465595.75	1207147.07	T = 872.95'		SW Cor Sec 13	T-156-N R-101-W	499926.40	1208516.54	GPS 2-6	505303.50	1209198.22	1941.03	1712+69.01	- 468' RT
Rec Sec Cor	1342+55.77	468234.03	1207253.14	L = 1,732.58'		W 1/4 Cor 13	T-156-N R-101-W	502572.32	1208621.69	5/8" Rebar w/ 2" Alum CAP Stamped GPS 2-6					
Rec Qtr Cor	1368+93.37	470869.75	1207352.45			SW Cor Sec 14	T-156-N R-101-W	500167.27	1203221.81	REFERENCE MARKERS					
Rec Sec Cor	1395+36.45	473510.90	1207454.58			W 1/4 Cor 24	T-156-N R-101-W	497292.81	1208407.47	R Mkr#	NORTHING	EASTING	STATION	OFFSET	
Rec Qtr Cor	1421+76.88	476149.36	1207555.59			SW Cor Sec 24	T-156-N R-101-W	494642.05	1208297.82	US 2					
Rec Sec Cor	1448+17.39	478787.94	1207656.36			W 1/4 Cor 25	T-156-N R-101-W	492012.12	1208192.33	22	450249.47	1206546.48	1161+33	-	71' RT
Rec Qtr Cor	1474+58.30	481426.78	1207761.23			SW Cor Sec 25	T-156-N R-101-W	489357.99	1208085.97	23	455505.04	1206198.03	1214+16	-	91' RT
Rec Sec Cor	1501+21.81	484088.19	1207866.80			W 1/4 Cor 36	T-156-N R-101-W	486722.82	1207976.48	24	460715.00	1207081.10	1267+34	-	91' RT
Rec Qtr Cor	1527+58.72	486722.82	1207976.48			SW Cor Sec 36	T-156-N R-101-W	484088.19	1207866.80	25	465975.06	1207252.19	1319+99	-	90' RT
Rec Sec Cor	1553+96.16	489357.99	1208085.97							26	471232.26	1207455.80	1372+60	-	89' RT
Rec Qtr Cor	1580+52.42	492012.12	1208192.33							27	476498.40	1207656.83	1425+30	-	88' RT
Rec Sec Cor	1606+84.47	494642.05	1208297.82							28	481740.40	1207863.60	1477+76	-	90' RT
Rec Qtr Cor	1633+37.50	497292.81	1208407.47							29	487036.27	1208078.01	1530+76	-	88' RT
Rec Sec Cor	1659+73.35	499926.40	1208516.54							30	492320.72	1208295.94	1583+65	-	91' RT
Rec Qtr Cor	1686+21.35	502572.32	1208621.69							31	497601.01	1208509.79	1636+50	-	89' RT
										32	502893.83	1208718.63	1689+46	-	84' RT
										All coordinates and measurements on this document derived from the International Foot definition.		This document was originally issued and sealed by Derek Anderson, Registration Number LS- 7107 , on 08/02/17 and the original document is stored at the North Dakota Department of Transportation			
										INITIALIZING BENCH MARK NDGPS Stations (OPUS)					
										☒ NAVD-88 ☐ NGVD-29 ☐ GEOID 09 ☐ _____ ☒ GEOID 12A					
NOTES: Sheet 1 of 1				Date Survey Completed 09/01/16		☐ Assumed Coordinates ☒ All coordinates on this sheet are Williams County ground coordinates. They are derived from the NAD83(2011) Reference frame; North Dakota North Zone Combination Factor (cf) = 0.9998445									

PRELIMINARY SURVEY COORDINATE AND CURVE DATA -									STATE	PROJECT NO.		SECTION NO.	SHEET NO.		
								ND		NH-NHU-7-002(156)022		81	2		
HORIZONTAL ALIGNMENT				HORIZONTAL ALIGNMENT				CURVE DATA		SURVEY CONTROL POINTS					
PNT	STATION	NORTHING	EASTING	PNT	STATION	NORTHING	EASTING	ARC DEFINITION		PNT	NORTHING	EASTING	ELEV	STATION	OFFSET
WILLISTON - US 2 - (Chain: PR_US2)								Curve PR_US2_3		PRIMARY CONTROL - US 2					
POB	10+00.00	447,130.47	1,206,380.05	TS	567+72.02	502,734.05	1,208,680.05	PI = 57+96.96		GPS 2-1	450034.29	1206588.69	1899.54	39+09.98 - 88' RT	
PC	50+63.70	451,190.66	1,206,548.94	PC	569+72.02	502,933.74	1,208,690.89	Delta = 10° 13' 12" (Lt)		5/8" Rebar w/ 2" Alum CAP Stamped GPS 2-1					
PI (PR_US2_3)	57+96.96	451,923.29	1,206,579.42	PI (PR_US2_37)	590+78.57	505,032.98	1,208,866.20	D _a = 0° 41' 55"		GPS 2-2	458307.37	1206934.80	2050.49	123+22.96 - 103' RT	
PT	65+26.34	452,649.70	1,206,479.42	PT	603+79.05	505,034.84	1,210,972.75	R = 8,200.00		5/8" Rebar w/ 2" Alum CAP Stamped GPS 2-2					
Point 2	74+89.46	453,603.83	1,206,348.08	ST	605+79.03	505,029.20	1,211,172.63	T = 733.26		GPS 2-3	469637.62	1207013.89	1976.98	236+36.18 - 346' LT	
Point 3	78+92.35	454,002.87	1,206,292.57	Point 14	608+41.16	505,018.00	1,211,434.52	L = 1,462.64		5/8" Rebar w/ 2" Alum CAP Stamped GPS 2-3					
PC	84+53.58	454,558.68	1,206,214.73							GPS 2-4	481385.96	1207913.32	2022.10	354+10.26 - 93' RT	
PI (PR_US2_10)	98+11.38	455,903.36	1,206,026.41					Curve PR_US2_10		5/8" Rebar w/ 2" Alum CAP Stamped GPS 2-4					
PT	111+19.50	457,188.52	1,206,464.54					PI = 98+11.38		GPS 2-5	492046.30	1208343.34	2041.96	460+79.41 - 97' RT	
PC	119+18.63	457,945.59	1,206,720.43					Delta = 26° 47' 51" (Rt)		5/8" Rebar w/ 2" Alum CAP Stamped GPS 2-5					
PI (PR_US2_13)	127+79.90	458,762.23	1,206,994.07					D _a = 1° 00' 19"		GPS 2-6	505303.50	1209198.22	1941.03	589+90.89 - 825' LT	
PT	136+28.68	459,623.15	1,207,018.61					R = 5,700.00		5/8" Rebar w/ 2" Alum CAP Stamped GPS 2-6					
PI	143+26.62	460,320.91	1,207,034.27					T = 1,357.80		REFERENCE MARKERS					
PI	155+55.90	461,549.88	1,207,062.23					L = 2,665.91							
PI	169+61.71	462,955.27	1,207,096.65							R Mkr#	NORTHING	EASTING	STATION	OFFSET	
PI	196+01.95	465,593.43	1,207,201.27					Curve PR_US2_13		22	450249.47	1206546.48	41+23.23	-	36.65' RT
PI	222+42.70	468,232.08	1,207,306.79					PI = 127+79.90		23	455505.04	1206198.03	94+03.51	-	36.25' RT
PI	248+79.95	470,867.45	1,207,406.38					Delta = 16° 53' 34" (Lt)		24	460715.00	1207081.10	147+21.67	-	37.85' RT
PI	275+23.07	473,508.59	1,207,508.60					D _a = 0° 59' 16"		25	465975.06	1207252.19	199+85.31	-	35.64' RT
PI	301+63.45	476,147.06	1,207,609.08					R = 5,800.00		26	471232.26	1207455.80	252+46.43	-	35.05' RT
PI	328+04.21	478,785.88	1,207,710.23					T = 861.27		27	476498.40	1207656.83	305+16.39	-	29.08' RT
PI	354+44.89	481,424.51	1,207,814.17					L = 1,710.04		28	481740.40	1207863.60	357+62.47	-	29.79' RT
PI	381+08.51	484,085.98	1,207,921.32					Curve PR_US2_37		29	487036.27	1208078.01	410+62.73	-	35.56' RT
PI	407+45.31	486,720.55	1,208,029.56					PI = 590+78.55		30	492320.72	1208295.94	463+51.67	-	38.28' RT
PI	433+82.75	489,359.54	1,208,141.34					Delta = 85° 10' 33" (Rt)		31	497601.01	1208509.79	516+36.28	-	37.66' RT
PI	460+39.01	492,009.72	1,208,248.50					D _a = 2° 30' 00"		32	502893.83	1208718.63	569+34.08	-	30.67' RT
PI	476+60.63	493,584.86	1,208,287.04					R = 2,291.83							
PI	486+71.18	494,639.85	1,208,352.07					L = 3,407.03							
PI	513+24.21	497,289.11	1,208,460.20					L _c in = 200.00		All coordinates and measurements on this document derived from the International Foot definition.		This document was originally issued and sealed by Derek Anderson, Registration Number PE- 7107 , on 08/02/17 and the original document is stored at the North Dakota Department of Transportation			
PI	539+59.92	499,924.10	1,208,569.89					S _c in = 2° 30' 00"							
PI	566+08.06	502,570.22	1,208,673.55					T _c in = 2,399.58							
POT	567+22.02	502,684.09	1,208,678.07					☐ Assumed Coordinates		INITIALIZING BENCH MARK					
								☒ All coordinates on this sheet are Williams County ground coordinates. They are derived from the NAD83(2011) Reference frame; North Dakota North Zone Combination Factor (cf) = 0.9998445		☒ NAVD-88 ☐ NGVD-29					
NOTES:										☐ GEOID 09 ☐ _____ ☒ GEOID 12A					

PRELIMINARY SURVEY COORDINATE AND CURVE DATA -											STATE	PROJECT NO.			SECTION NO.	SHEET NO.
											ND	NH-NHU-7-002(156)022			81	3
HORIZONTAL ALIGNMENT				CURVE DATA		HORIZONTAL ALIGNMENT				SURVEY CONTROL POINTS						
PNT	STATION	NORTHING	EASTING	ARC DEFINITION		PNT	STATION	NORTHING	EASTING	PNT	NORTHING	EASTING	ELEV	STATION	OFFSET	
WILLISTON - FRONTAGE - (Chain: PR_FRONTAGE)				Curve PR_FRONTAGE_3		Gaurdrail (Chain : GRDRL)				CONTROL POINT DESCRIPTION						
										PRIMARY CONTROL - US 2						
POB	2000+00.00	451,973.70	1,206,581.77	PI = 2006+69.50		POB	415+00.00	487,474.650	1,208,059.50	GPS 2-1	450034.29	1206588.69	1899.54	39+09.98 - 88' RT		
PC	2005+89.53	451,997.89	1,205,992.73	Delta = 89° 58' 38" (Rt)		POT	426+00.00	488,573.69	1,208,105.42	5/8" Rebar w/ 2" Alum CAP Stamped GPS 2-1						
PI	2006+69.50	452,001.17	1,205,912.83	D _a = 71° 37' 11"						GPS 2-2	458307.37	1206934.80	2050.49	123+22.96 - 103' RT		
PT	2007+15.16	452,448.52	1,205,931.03	R = 80.00						5/8" Rebar w/ 2" Alum CAP Stamped GPS 2-2						
POT	2010+82.91	452,448.52	1,205,931.03	T = 79.97						GPS 2-3	469637.62	1207013.89	1976.98	236+36.18 - 346' LT		
				L = 125.63						5/8" Rebar w/ 2" Alum CAP Stamped GPS 2-3						
										GPS 2-4	481385.96	1207913.32	2022.10	354+10.26 - 93' RT		
OILFIELD REROUTE - (Chain: PR_OILFIELD)				Curve PR_OILFIELD_3						5/8" Rebar w/ 2" Alum CAP Stamped GPS 2-4						
POB	10000+00.00	468,427.58	1,208,137.27	PI = 10014+37.46						GPS 2-5	492046.30	1208343.34	2041.96	460+79.41 - 97' RT		
PC	10005+16.78	468,447.87	1,207,620.89	Delta = 195° 37' 48" (Rt)						5/8" Rebar w/ 2" Alum CAP Stamped GPS 2-5						
PI	10014+37.46	468,411.71	1,208,540.86	D _a = 45° 50' 12"						GPS 2-6	505303.50	1209198.22	1941.03	589+90.89 - 825' LT		
PT	10009+43.22	468,691.85	1,207,663.83	R = 125.00						5/8" Rebar w/ 2" Alum CAP Stamped GPS 2-6						
POT	10010+29.91	468,665.47	1,207,746.41	T = 920.68						REFERENCE MARKERS						
				L = 426.44												
WILLISTON - US 2 WB - (Chain: PR_US2_WB)				Curve PR_US2_WB_3	Curve PR_US2_WB_11					R Mkr#	NORTHING	EASTING	STATION	OFFSET		
Point 763	2010+00.00	447,133.12	1,206,316.37	PI = 2058+33.61	PI = 2128+05.56					22	450249.47	1206546.48	41+23.23	-	36.65' RT	
PC	2050+59.05	451,188.69	1,206,484.39	Delta = 10° 43' 37" (Lt)	Delta = 17° 12' 21" (Lt)					23	455505.04	1206198.03	94+03.51	-	36.25' RT	
PI	2058+33.61	451,962.58	1,206,516.45	D _a = 0° 41' 40"	D _a = 1° 06' 58"					24	460715.00	1207081.10	147+21.67	-	37.85' RT	
PT	2066+03.63	452,728.91	1,206,403.91	R = 8,250.00	R = 5,134.00					25	465975.06	1207252.19	199+85.31	-	35.64' RT	
Point 764	2072+62.33	453,380.62	1,206,308.20	T = 774.55	T = 776.72					26	471232.26	1207455.80	252+46.43	-	35.05' RT	
PC	2083+53.81	454,459.93	1,206,145.64	L = 1,544.58	L = 1,541.74					27	476498.40	1207656.83	305+16.39	-	29.08' RT	
PI	2097+73.78	455,864.06	1,205,934.15							28	481740.40	1207863.60	357+62.47	-	29.79' RT	
PT	2111+40.52	457,210.21	1,206,386.04	Curve PR_US2_WB_8						29	487036.27	1208078.01	410+62.73	-	35.56' RT	
PC	2020+28.84	458,052.34	1,206,668.74	PI = 2097+73.78						30	492320.72	1208295.94	463+51.67	-	38.28' RT	
PI	2128+05.56	458,788.68	1,206,915.92	Delta = 27° 07' 19" (Rt)						31	497601.01	1208509.79	516+36.28	-	37.66' RT	
PT	2135+70.58	459,565.18	1,206,934.23	D _a = 0° 58' 24"						32	502893.83	1208718.63	569+34.08	-	30.67' RT	
Point 765	2143+30.04	460,324.43	1,206,952.13	R = 5,887.00												
Point 766	2169+64.95	462,958.60	1,207,014.46	T = 1,419.97												
Point 767	2176+64.95	463,658.07	1,207,041.55	L = 2,786.71						All coordinates and measurements on this document derived from the International Foot definition. This document was originally issued and sealed by Derek Anderson, Registration Number PE- 7107 , on 08/02/17 and the original document is stored at the North Dakota Department of Transportation						
Point 768	2182+85.18	464,277.80	1,207,066.62													
Point 769	2196+05.42	465,596.96	1,207,119.86													
Point 770	2222+45.83	468,235.26	1,207,225.53													
Point 771	2248+83.43	470,871.00	1,207,324.50													
NOTES:				Date Survey Completed / /		☐ Assumed Coordinates ☒ All coordinates on this sheet are Williams County ground coordinates. They are derived from the NAD83(2011) Reference frame; North Dakota North Zone Combination Factor (cf) = 0.9998445				INITIALIZING BENCH MARK			☒ NAVD-88 ☐ NGVD-29 ☐ GEOID 09 ☐ _____ ☒ GEOID 12A			

ALIGNMENT MONUMENTS					ALIGNMENT MONUMENTS					STATE	PROJECT NO.		SECTION NO.	SHEET NO.	
WILLISTON - US 2 - (Chain: PR_US2)					WILLISTON - FRONTAGE - (Chain: PR_FRONTAGE)						ND	NH-NHU-7-002(156)022		81	4
STATION	OFFSET	DESCRIPTION	MONUMENT PER STANDARD D-720-1	POINT NUMBER	STATION	OFFSET	DESCRIPTION	MONUMENT PER STANDARD D-720-1	POINT NUMBER	SPEC CODE 720 125		BID ITEM ALIGNEMNT MONUMENTS		QTY	UNIT
10+00.00	0	POB	X	866	2000+00.00	0	POB	X	1391			See tables		37	EA
50+63.70	0	PC	X	987	2005+89.53	0	PC	X	9863						
		PI (PR_US2_3)	X	893	2006+52.35	-33.11	PI	X	9864						
65+26.34	0	PT	X	988	2007+15.16	0	PT	X	9865						
74+89.46	0	PI	X	867	2010+82.91	0	POT	X	1392						
78+92.35	0	PI	X	868											
84+53.58	0	PC	X	989											
		PI (PR_US2_10)	X	894											
111+19.50	0	PT	X	990											
119+18.63	0	PC	X	991											
		PI (PR_US2_13)	X	895											
136+28.68	0	PT	X	992											
143+26.62	0	PI	X	869											
155+55.90	0	PI	X	870											
169+61.71	0	PI	X	871											
196+01.95	0	PI	X	872											
222+42.70	0	PI	X	873											
248+79.95	0	PI	X	874											
275+23.07	0	PI	X	881											
301+63.45	0	PI	X	882											
328+04.21	0	PI	X	883											
354+44.89	0	PI	X	884											
381+08.51	0	PI	X	885											
407+45.31	0	PI	X	875											
433+82.75	0	PI	X	887											
460+39.01	0	PI	X	888											
476+60.63	0	PI	X	889											
486+71.18	0	PI	X	876											
513+24.21	0	PI	X	891											
539+59.92	0	PI	X	892											
566+08.06	0	PI	X	877											
567+22.02	0	POT	X	878											

NOTES:

1.

The Contractor shall provide a licensed Professional Surveyor (PLS) to oversee the placement of monuments. The PLS shall record all section corners and quarter corner monuments placed on the project in accordance with the North Dakota Century Code. The Contractor shall submit a copy of the recordation to the Engineer.

2.


Station and offsets given are perpendicular to the alignment.


This document was originally issued and sealed by
Derek Anderson,
Registration Number
PE- 7107,
on 08/02/17 and the original document is stored at the
North Dakota Department
of Transportation


Survey Coordinate Data


US 2


R/W & Alignment Monumentation

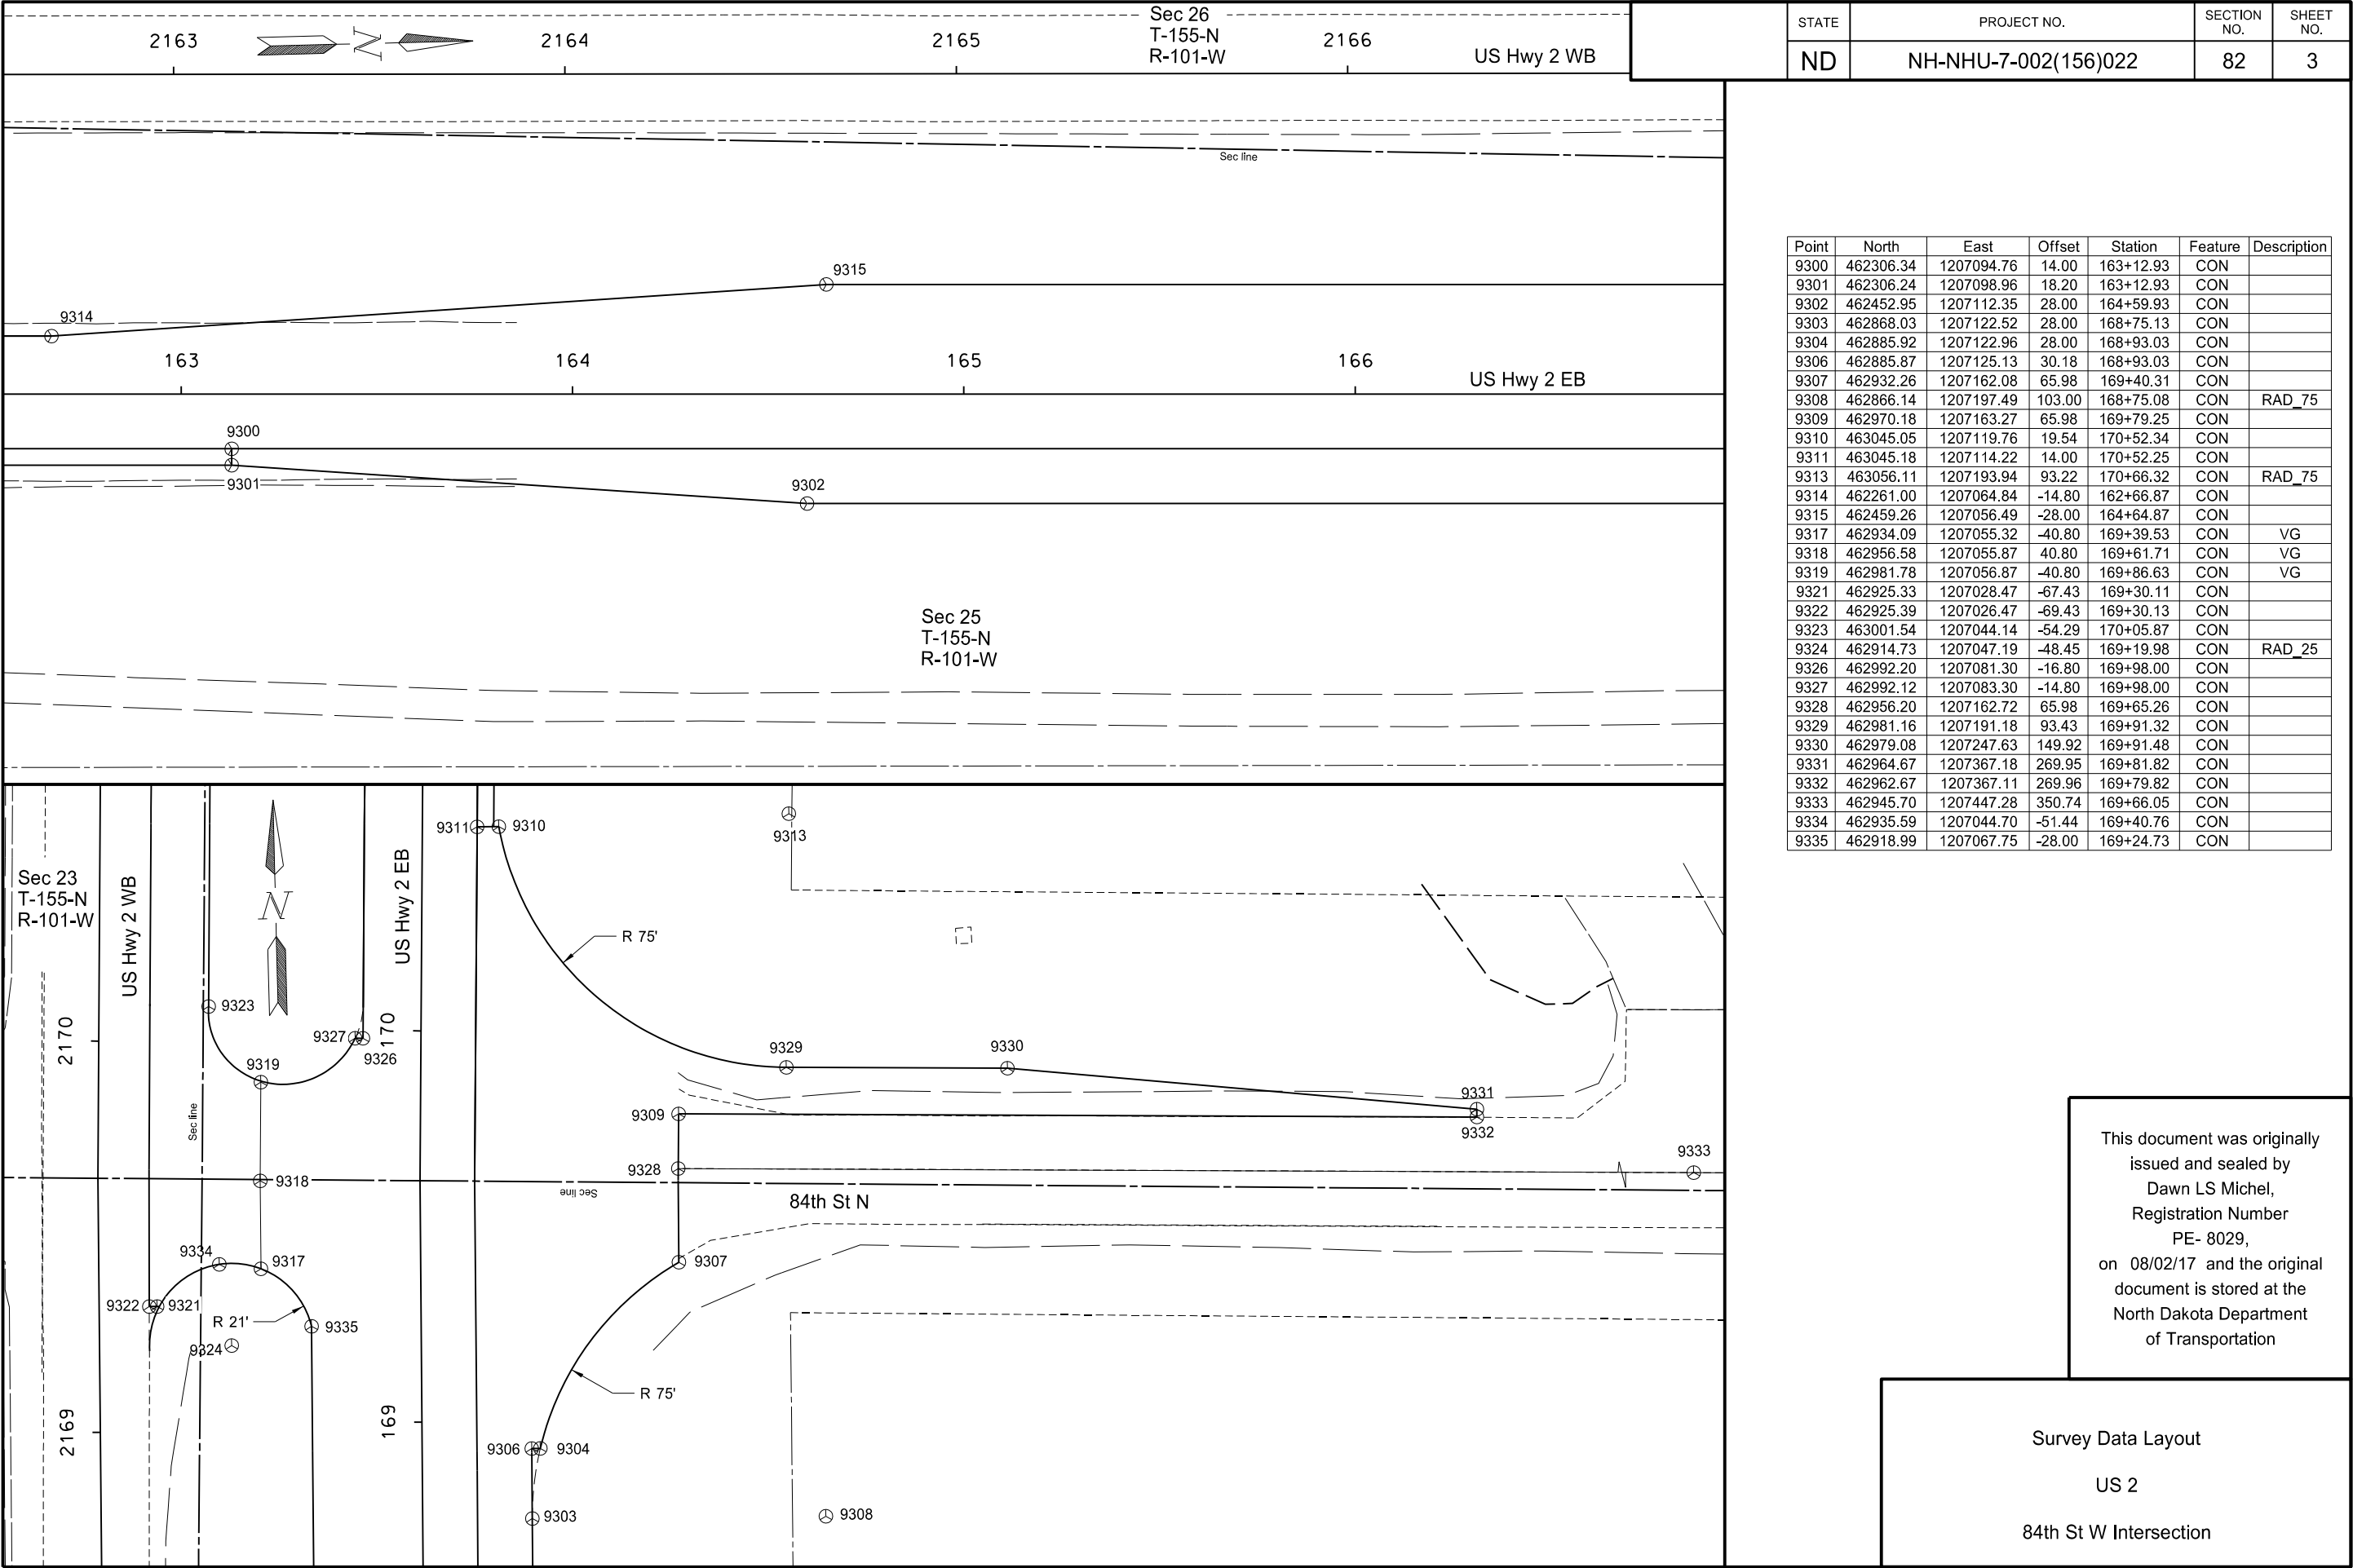


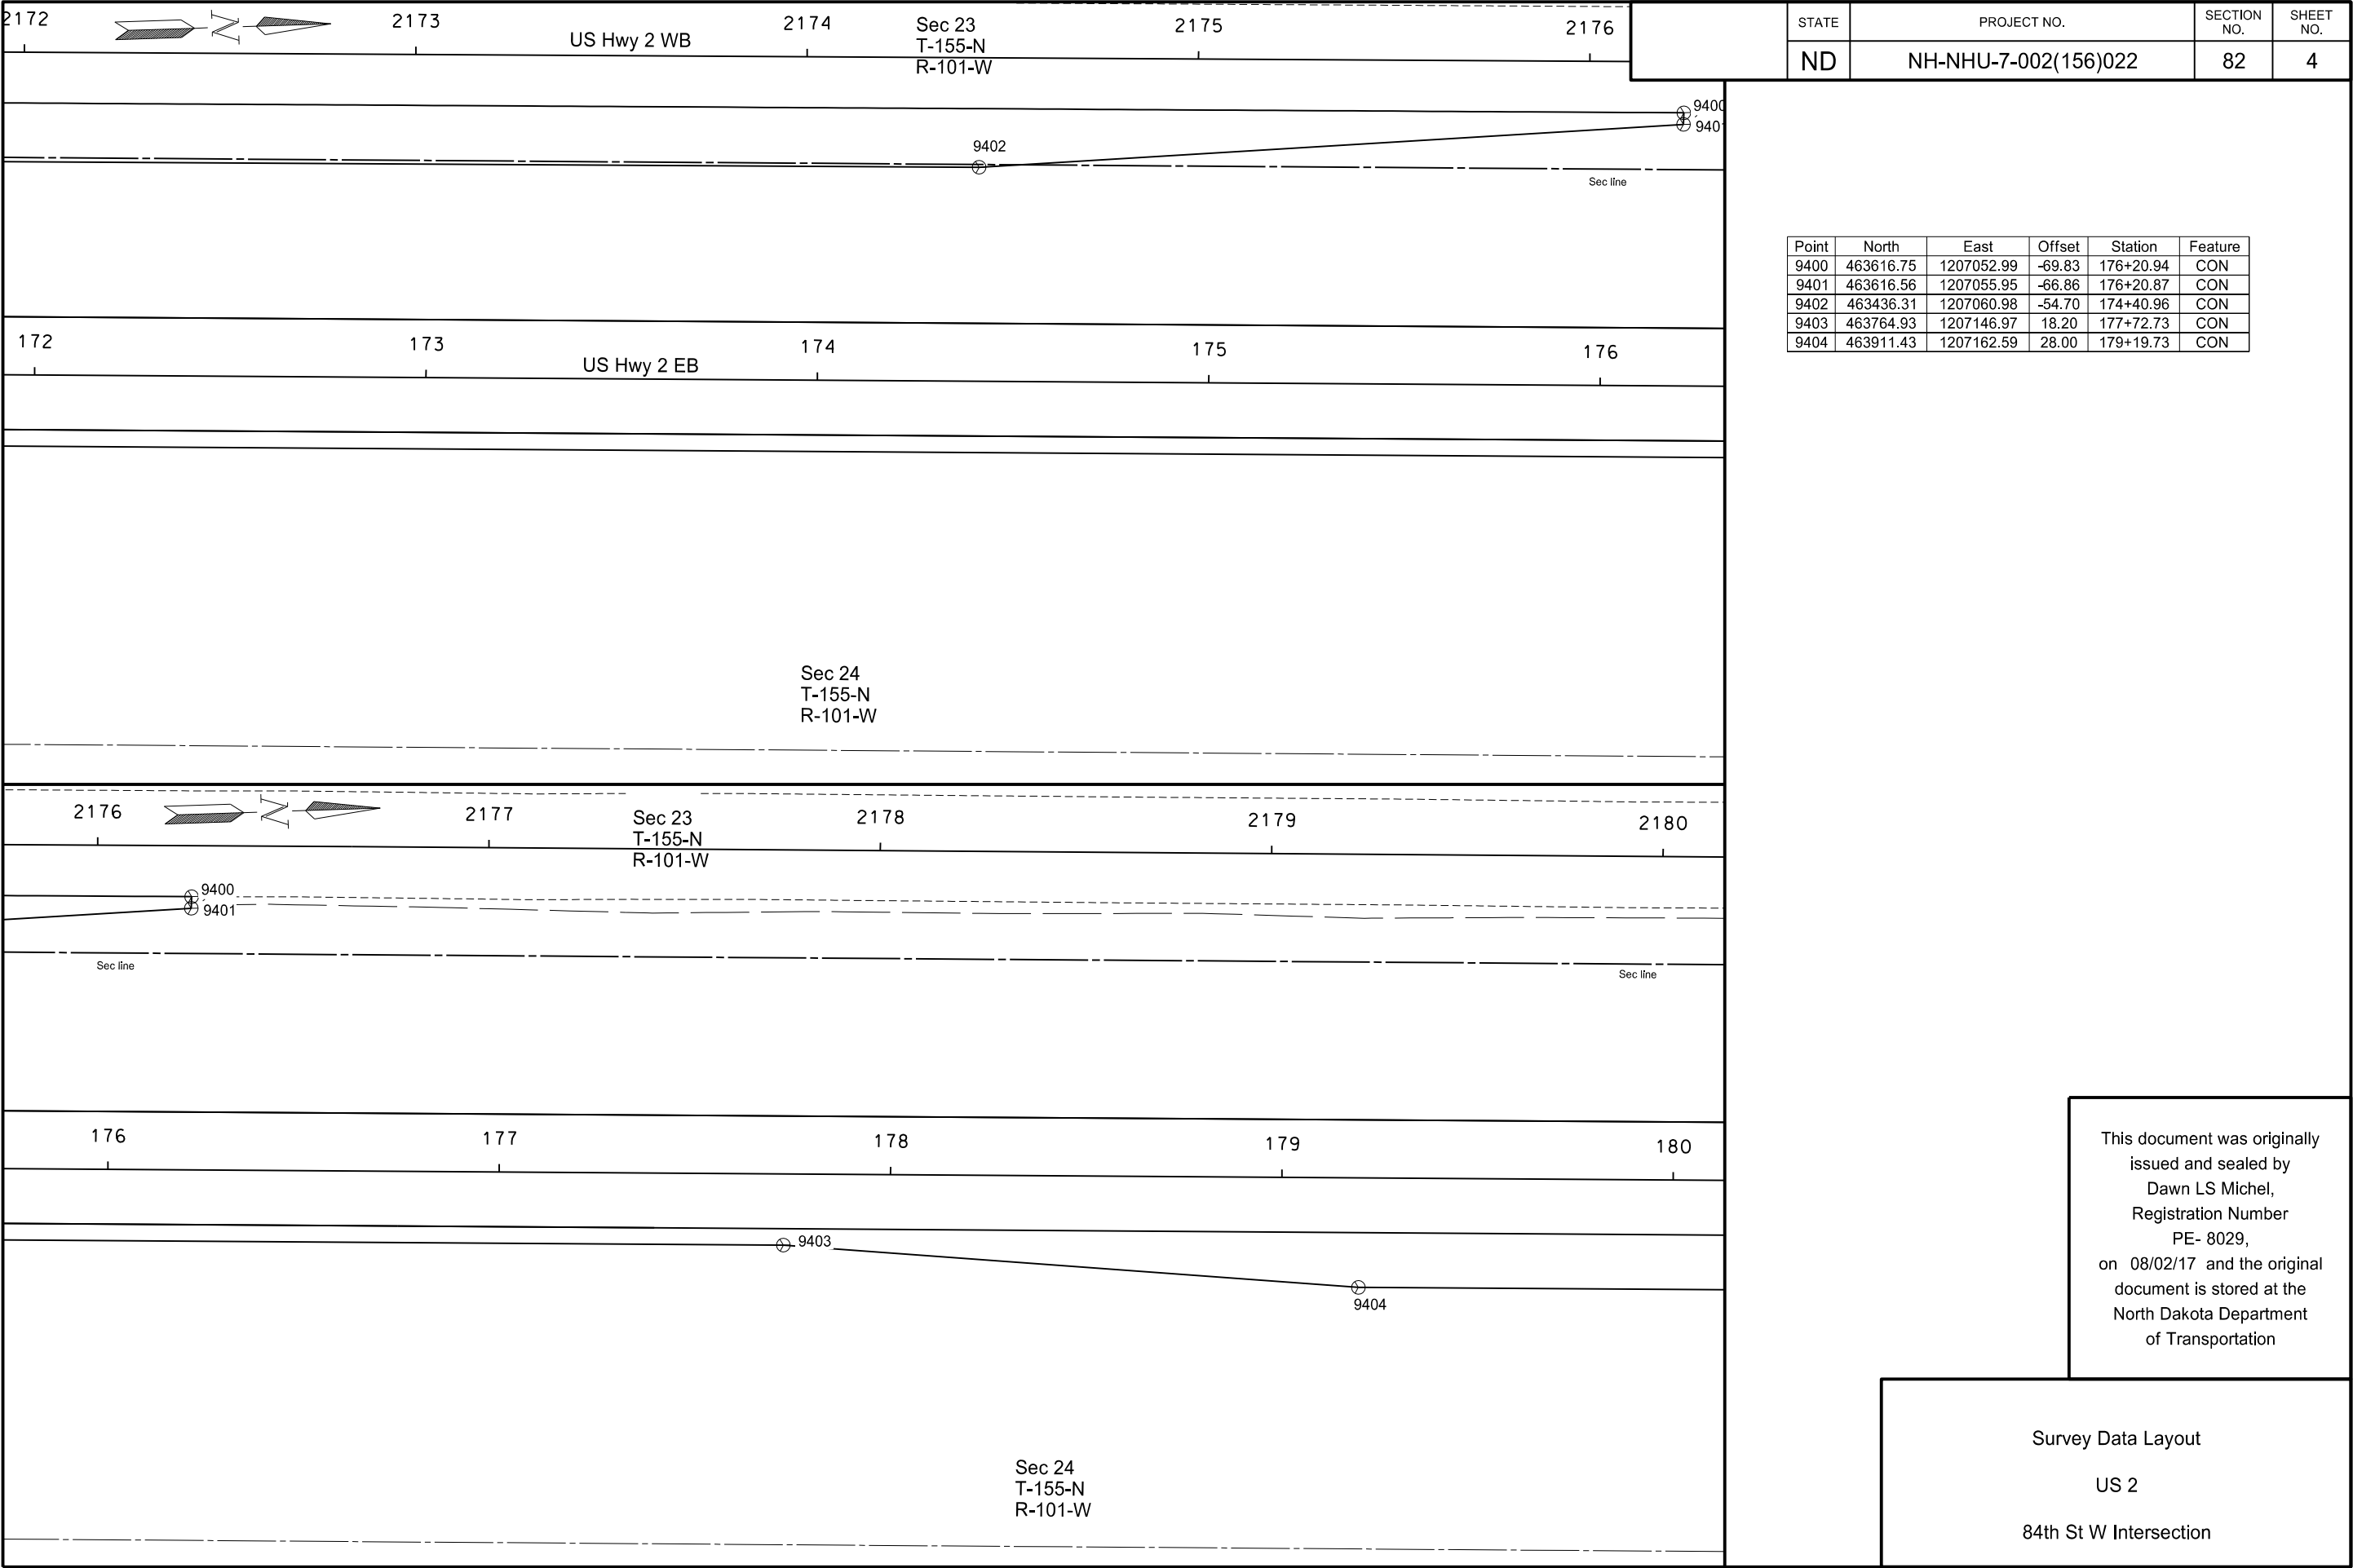

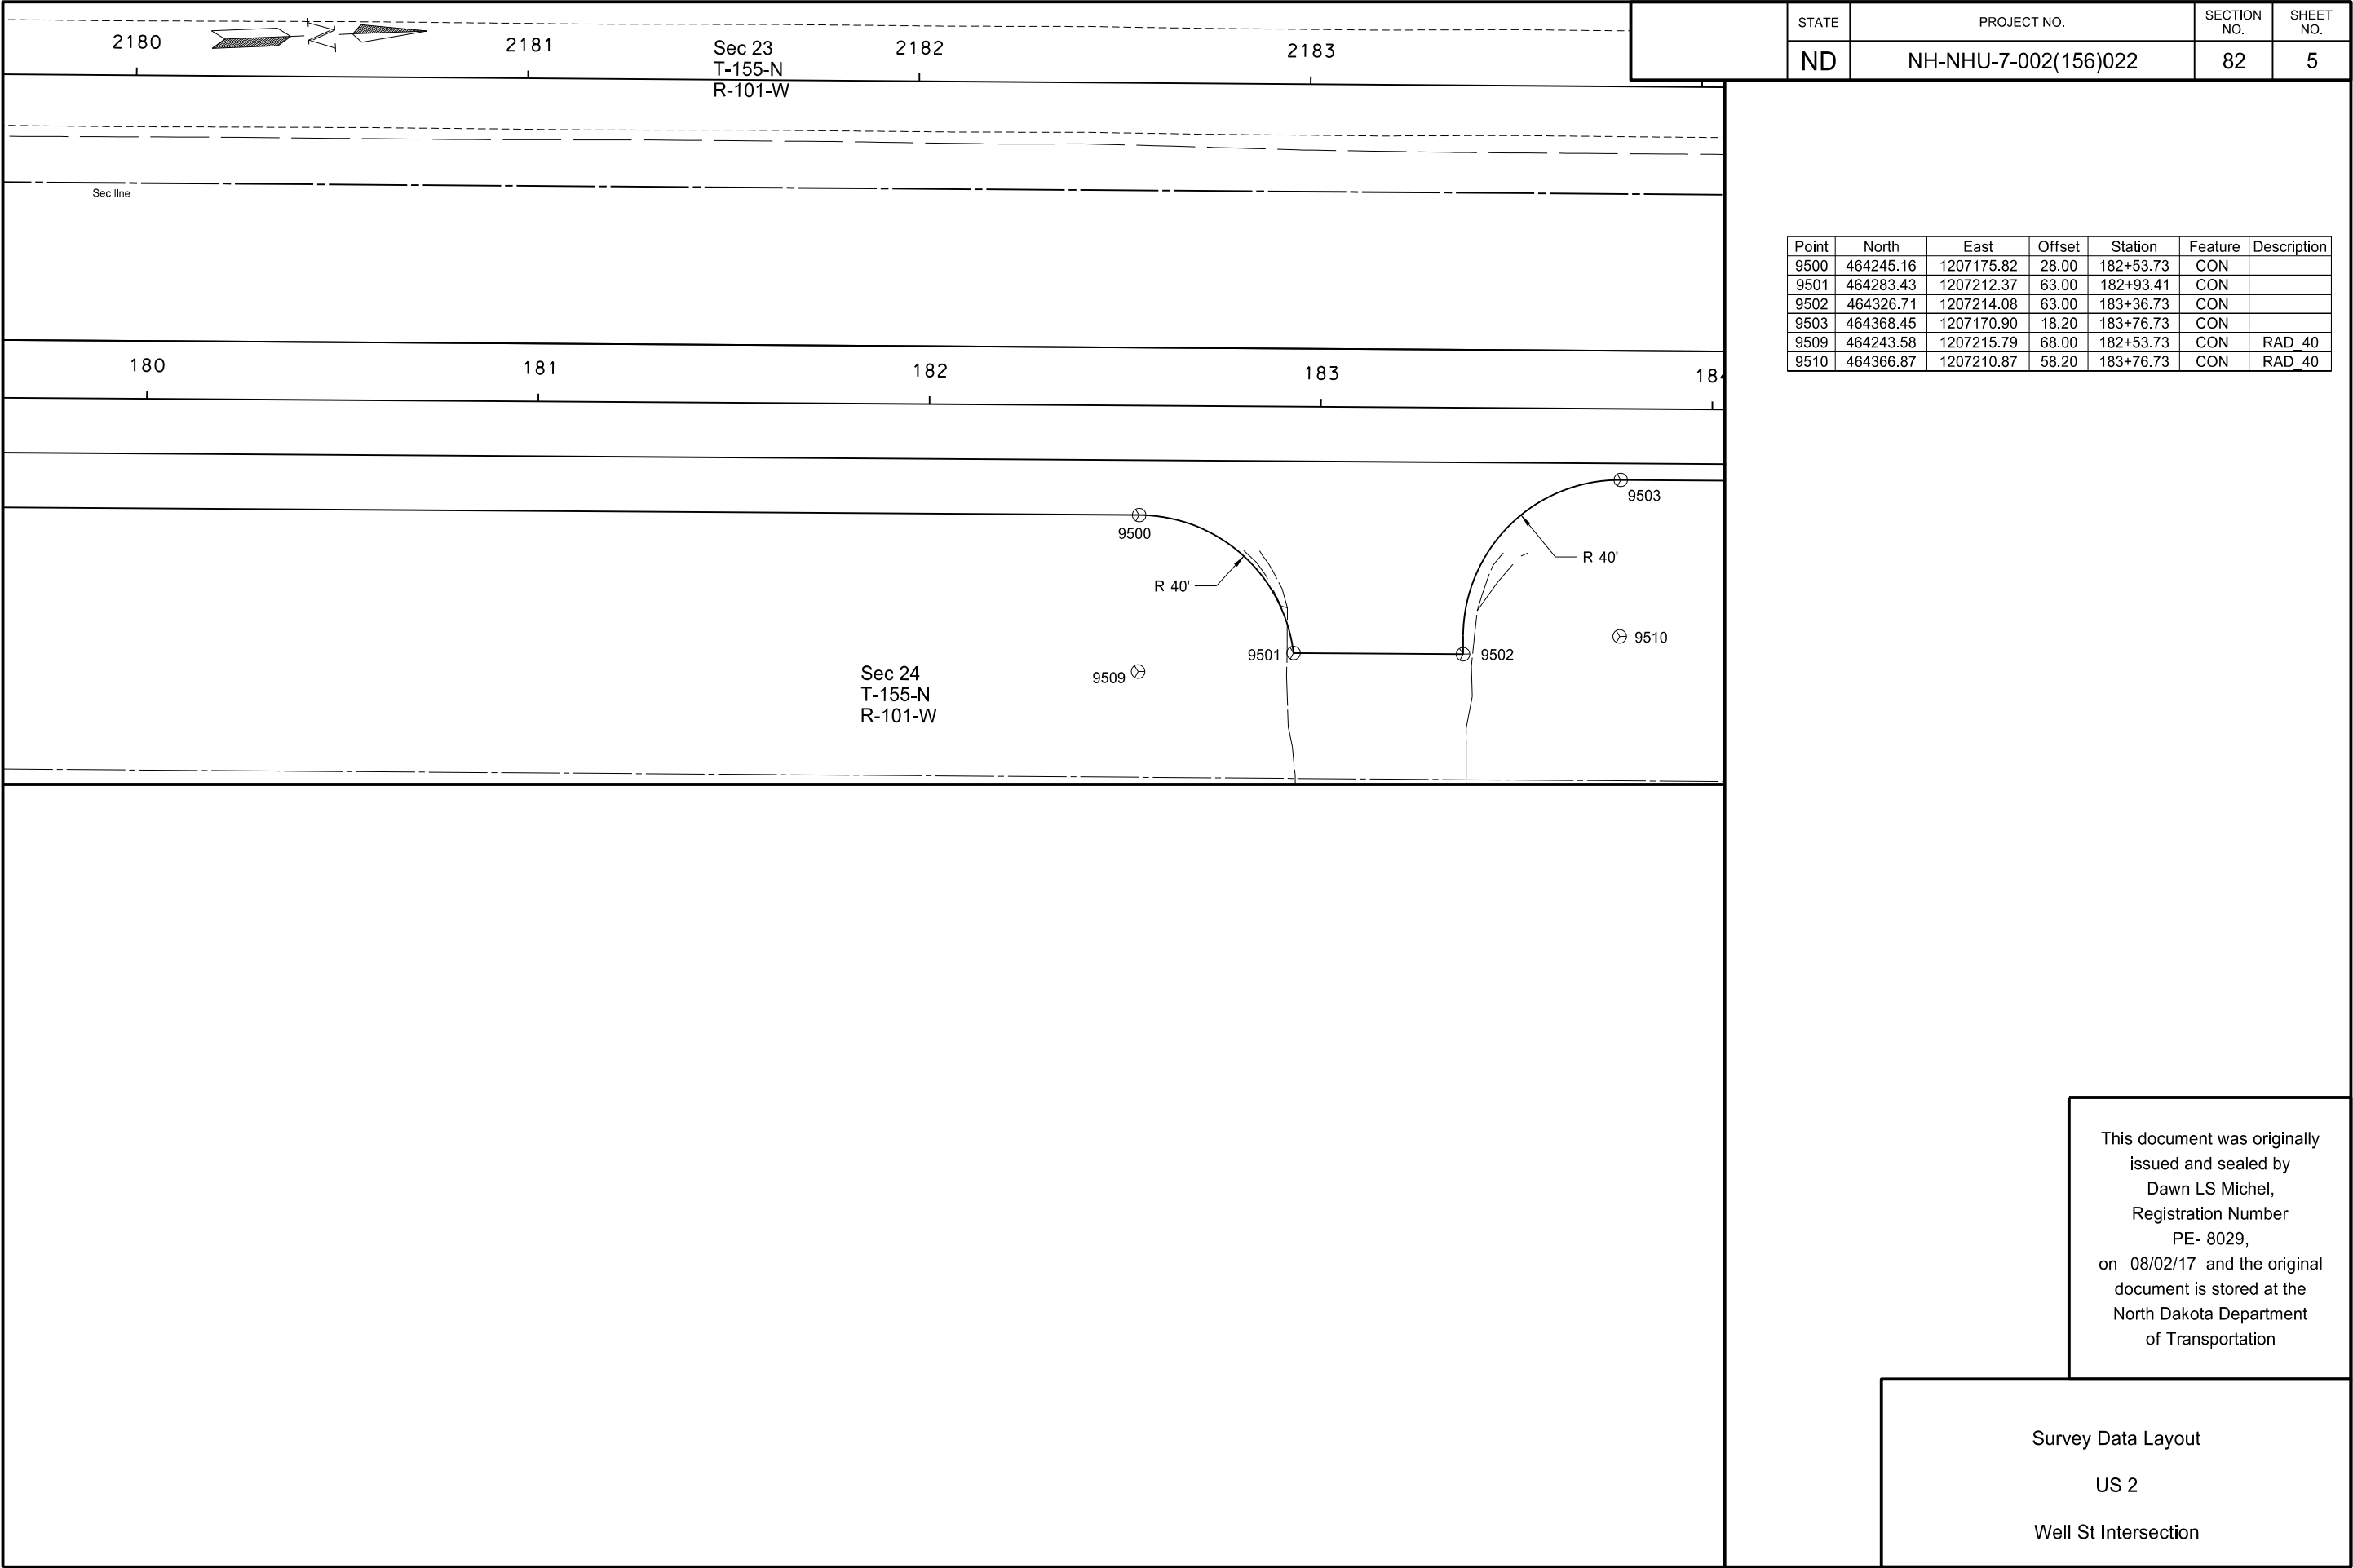

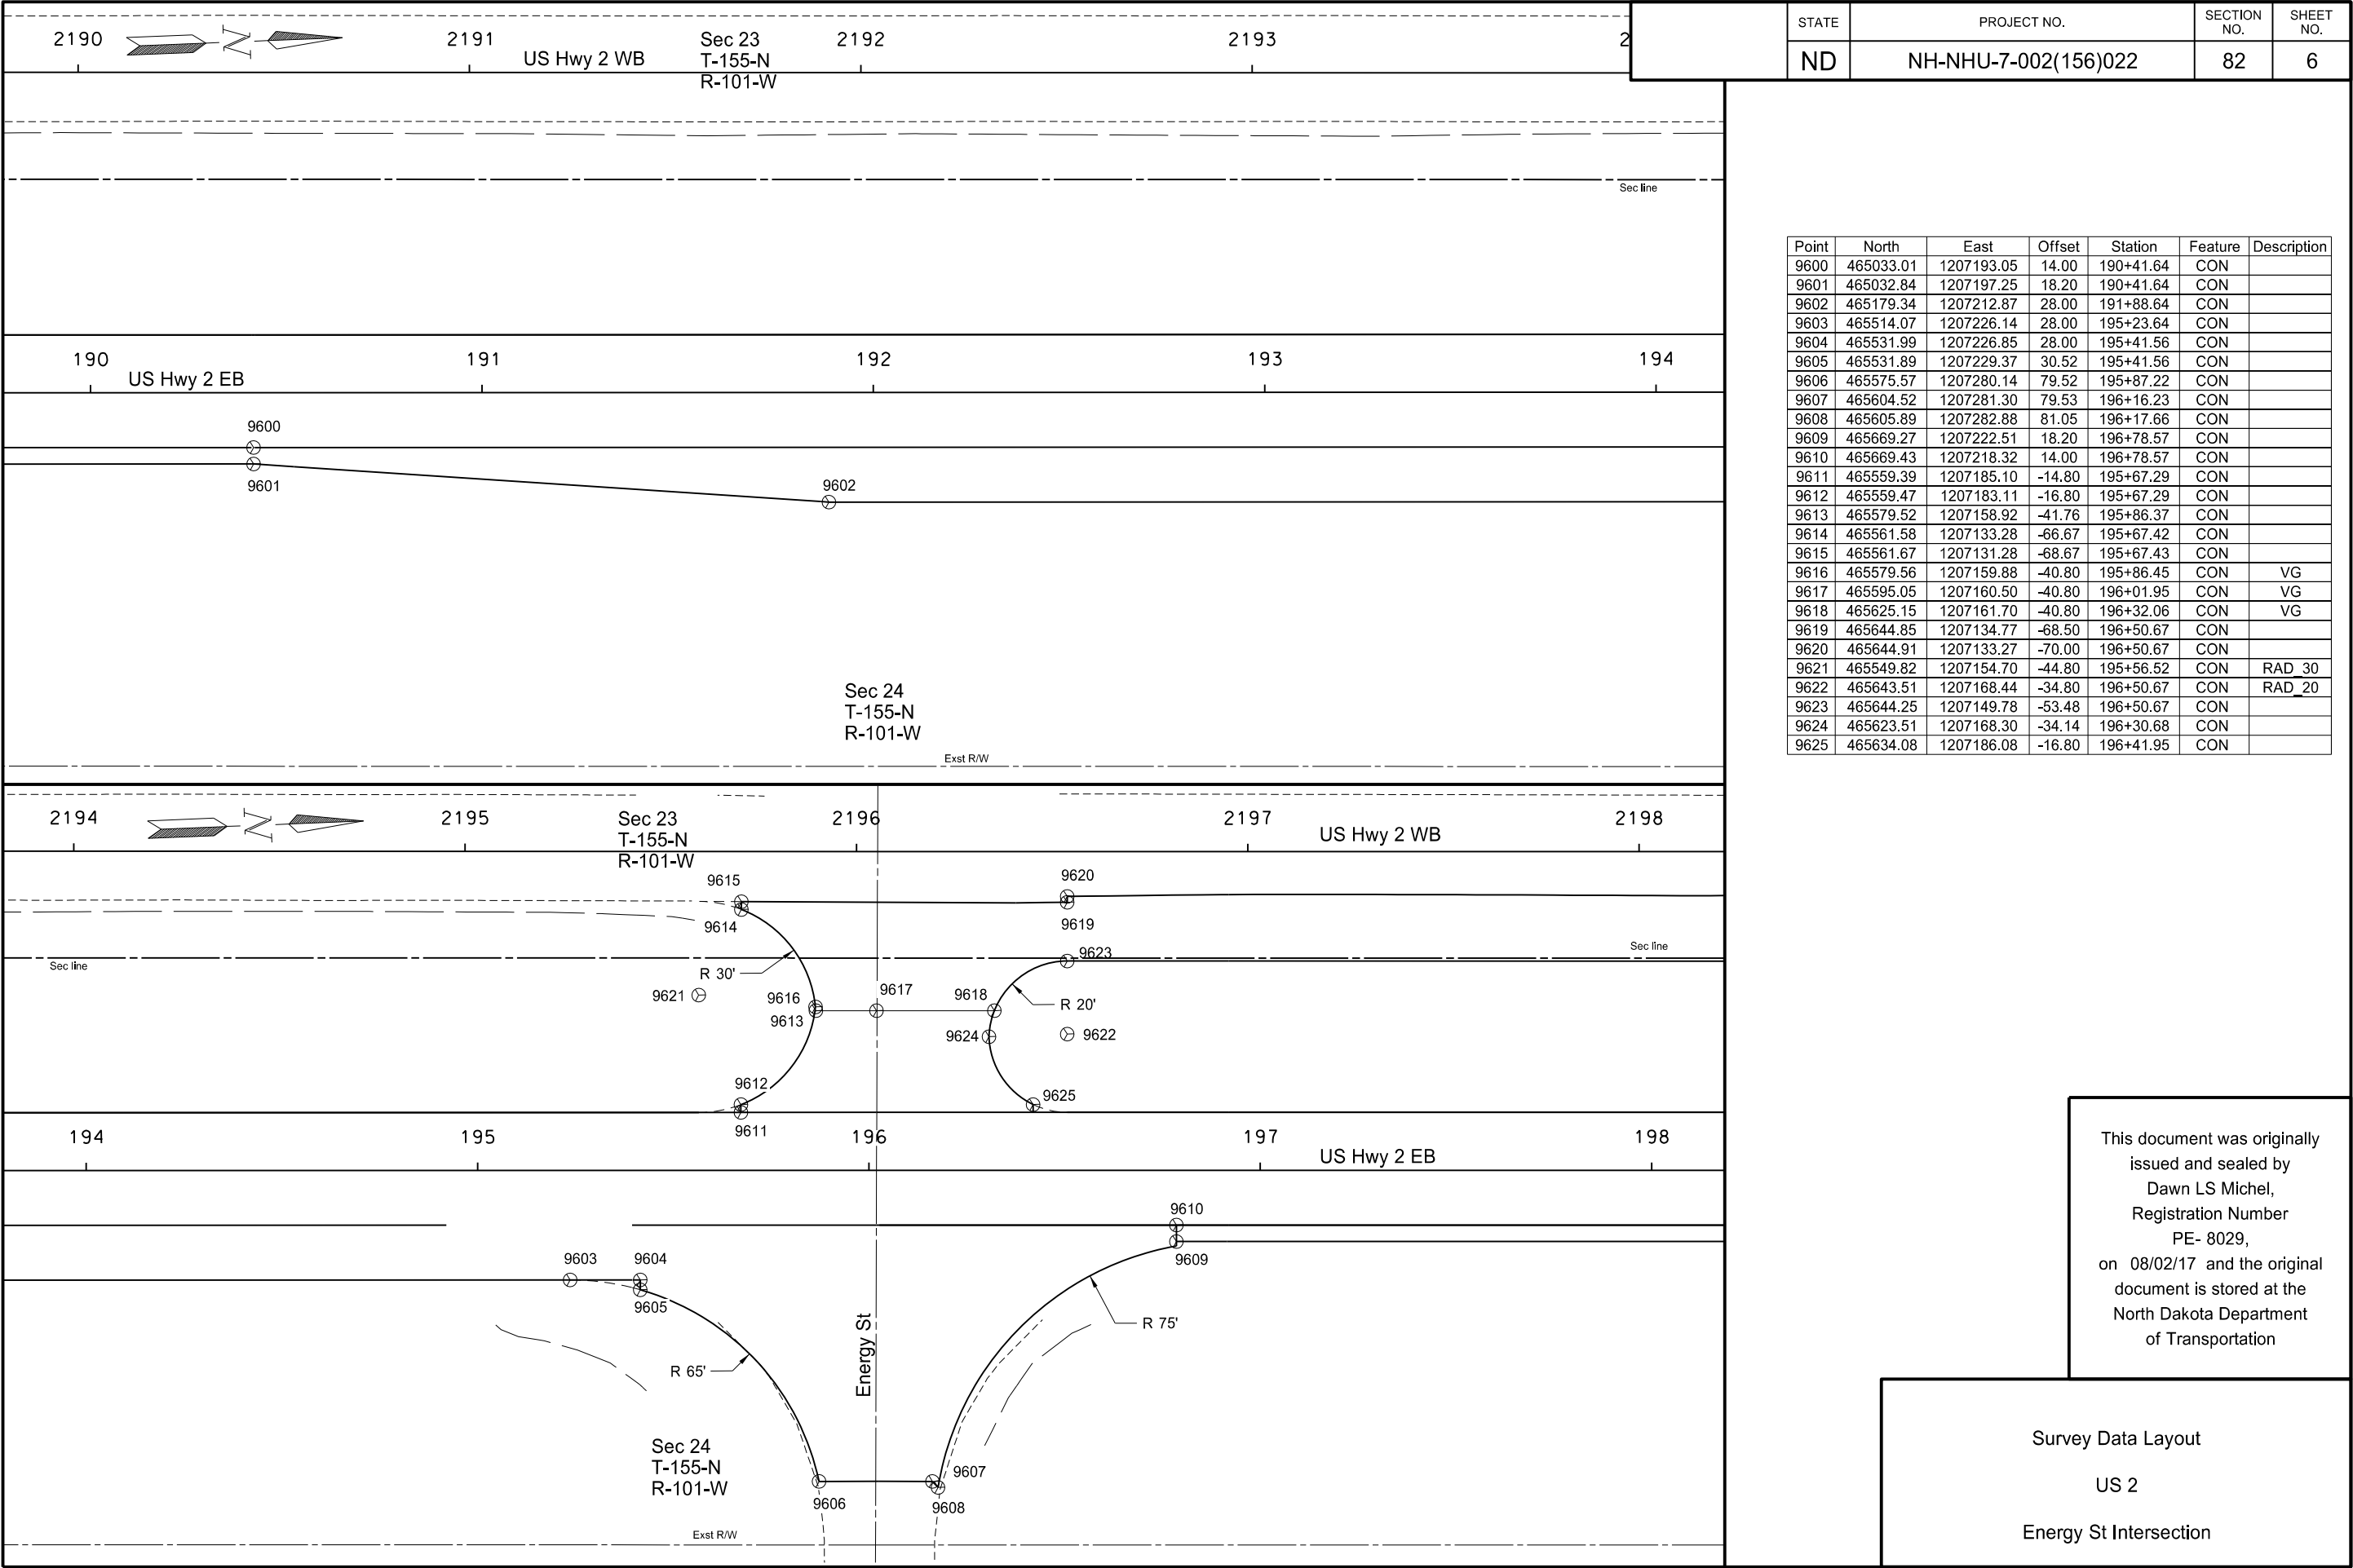

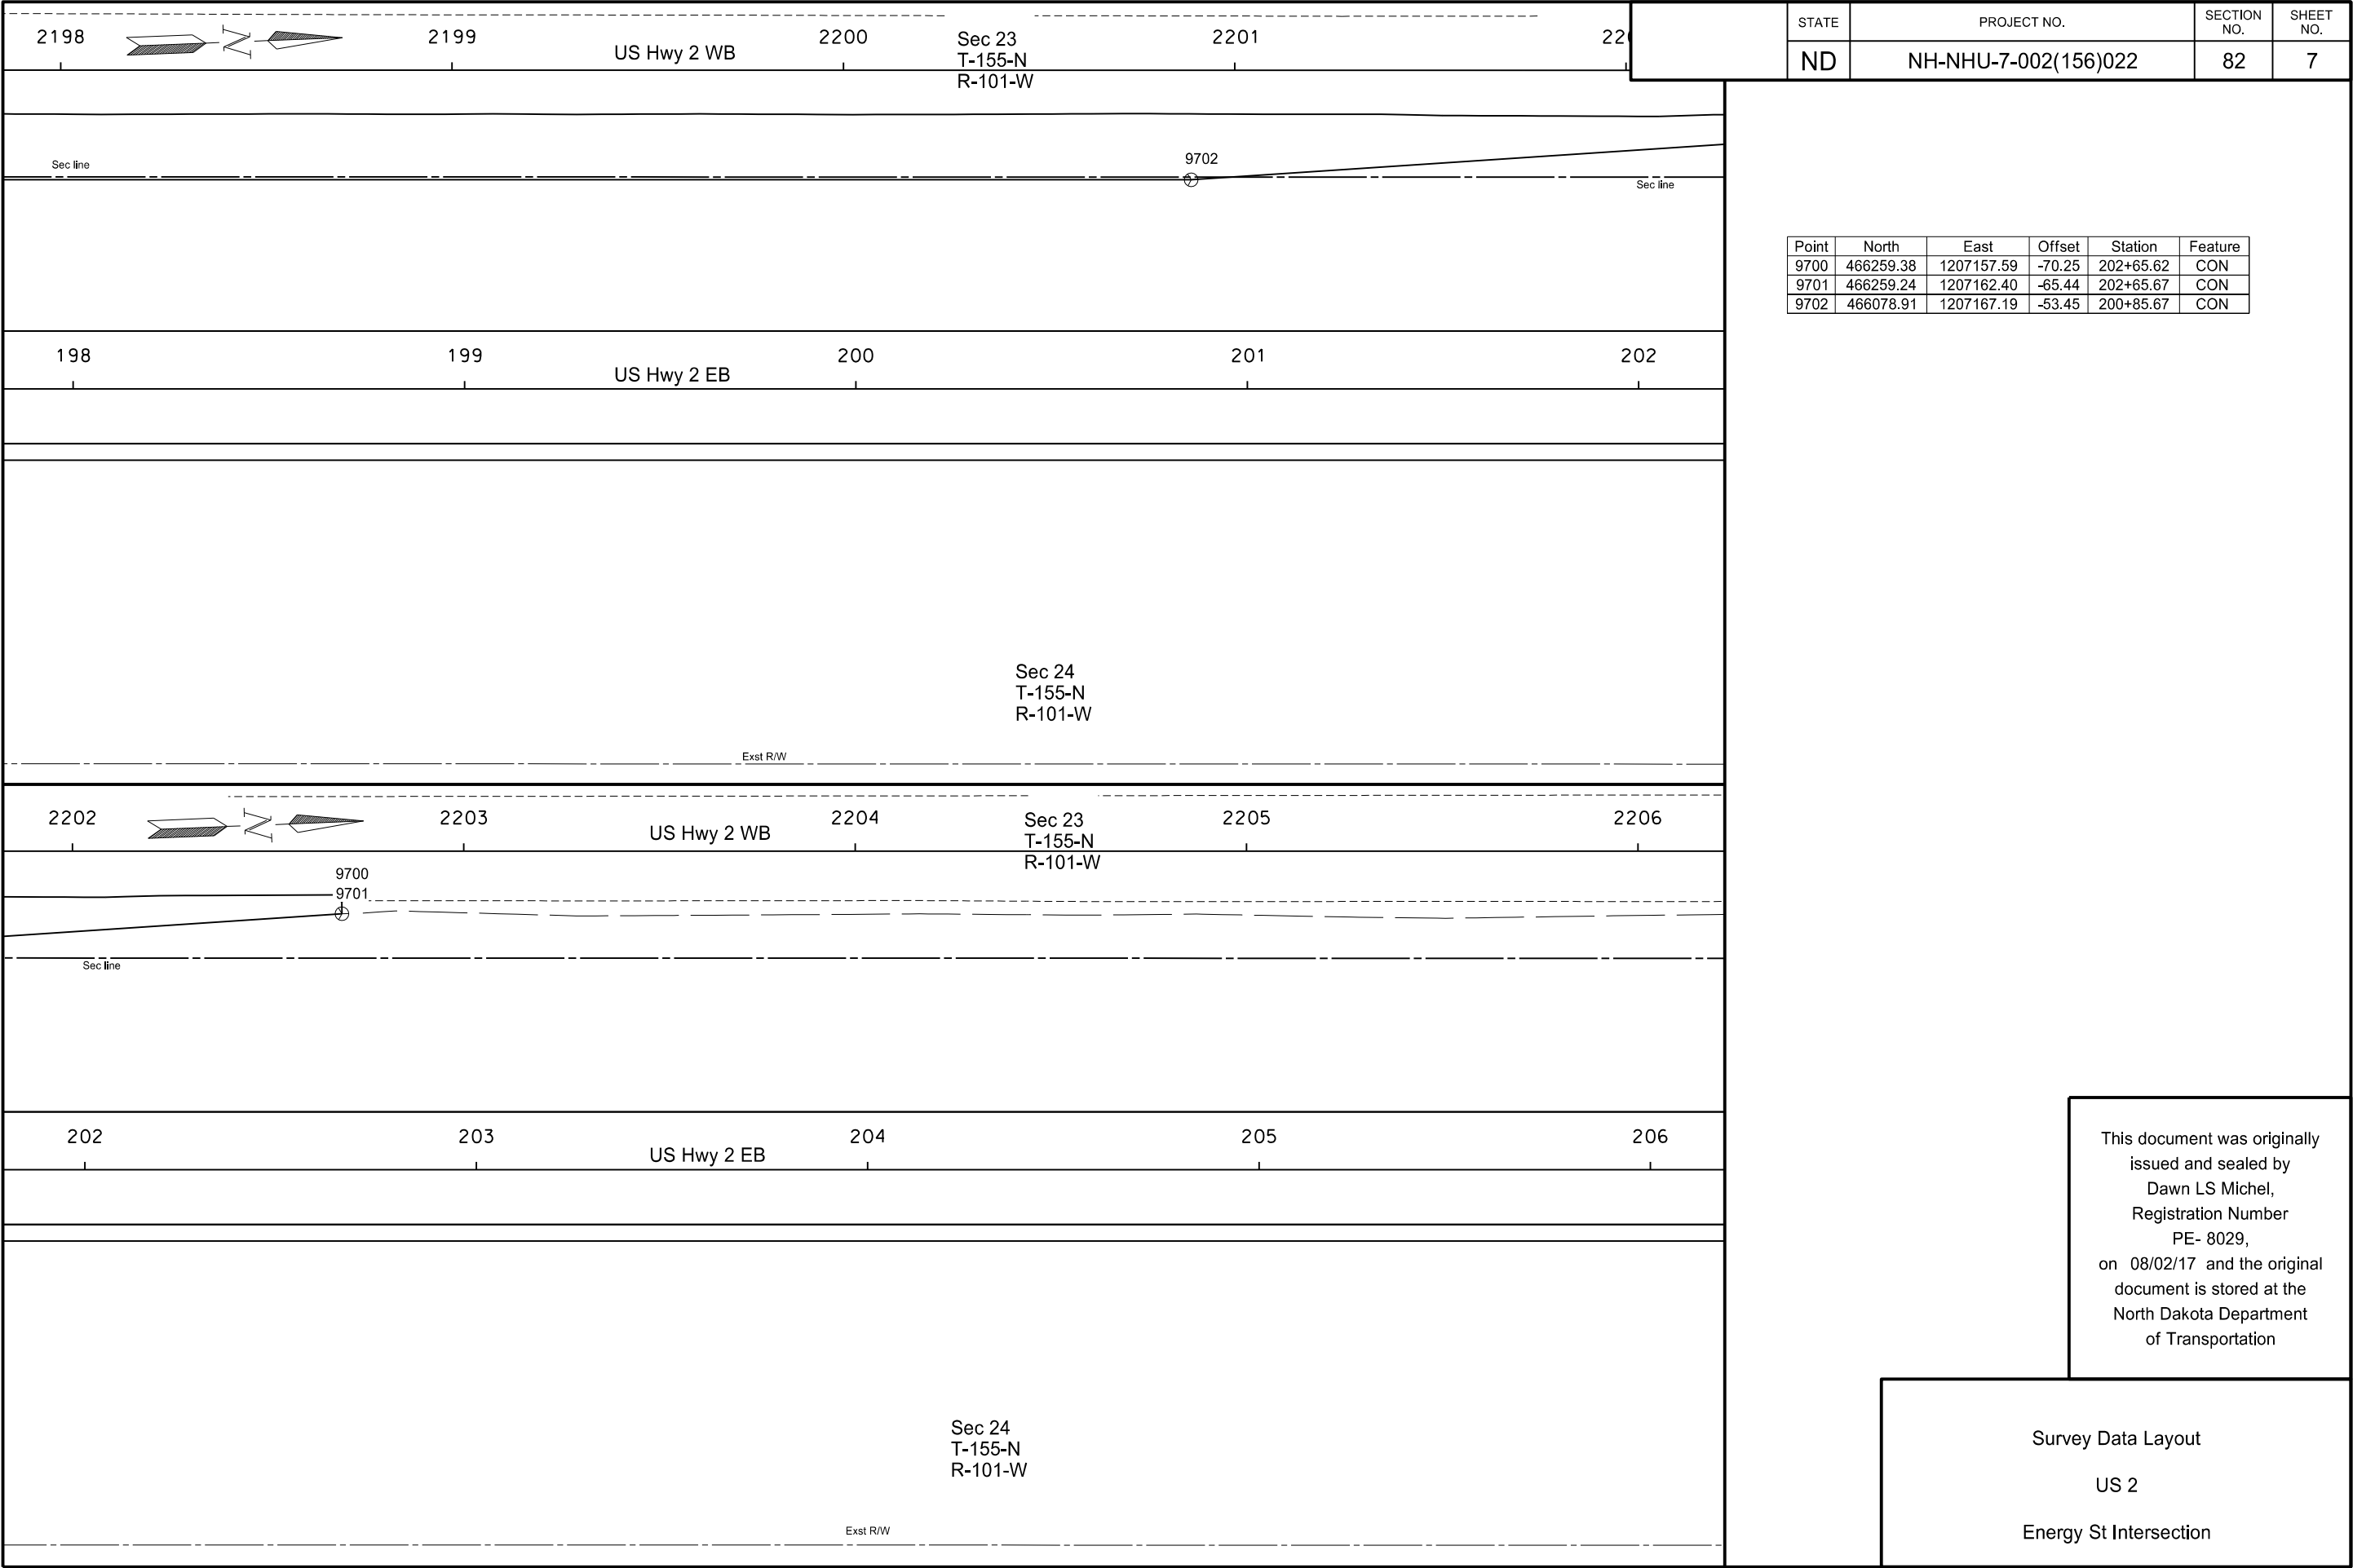

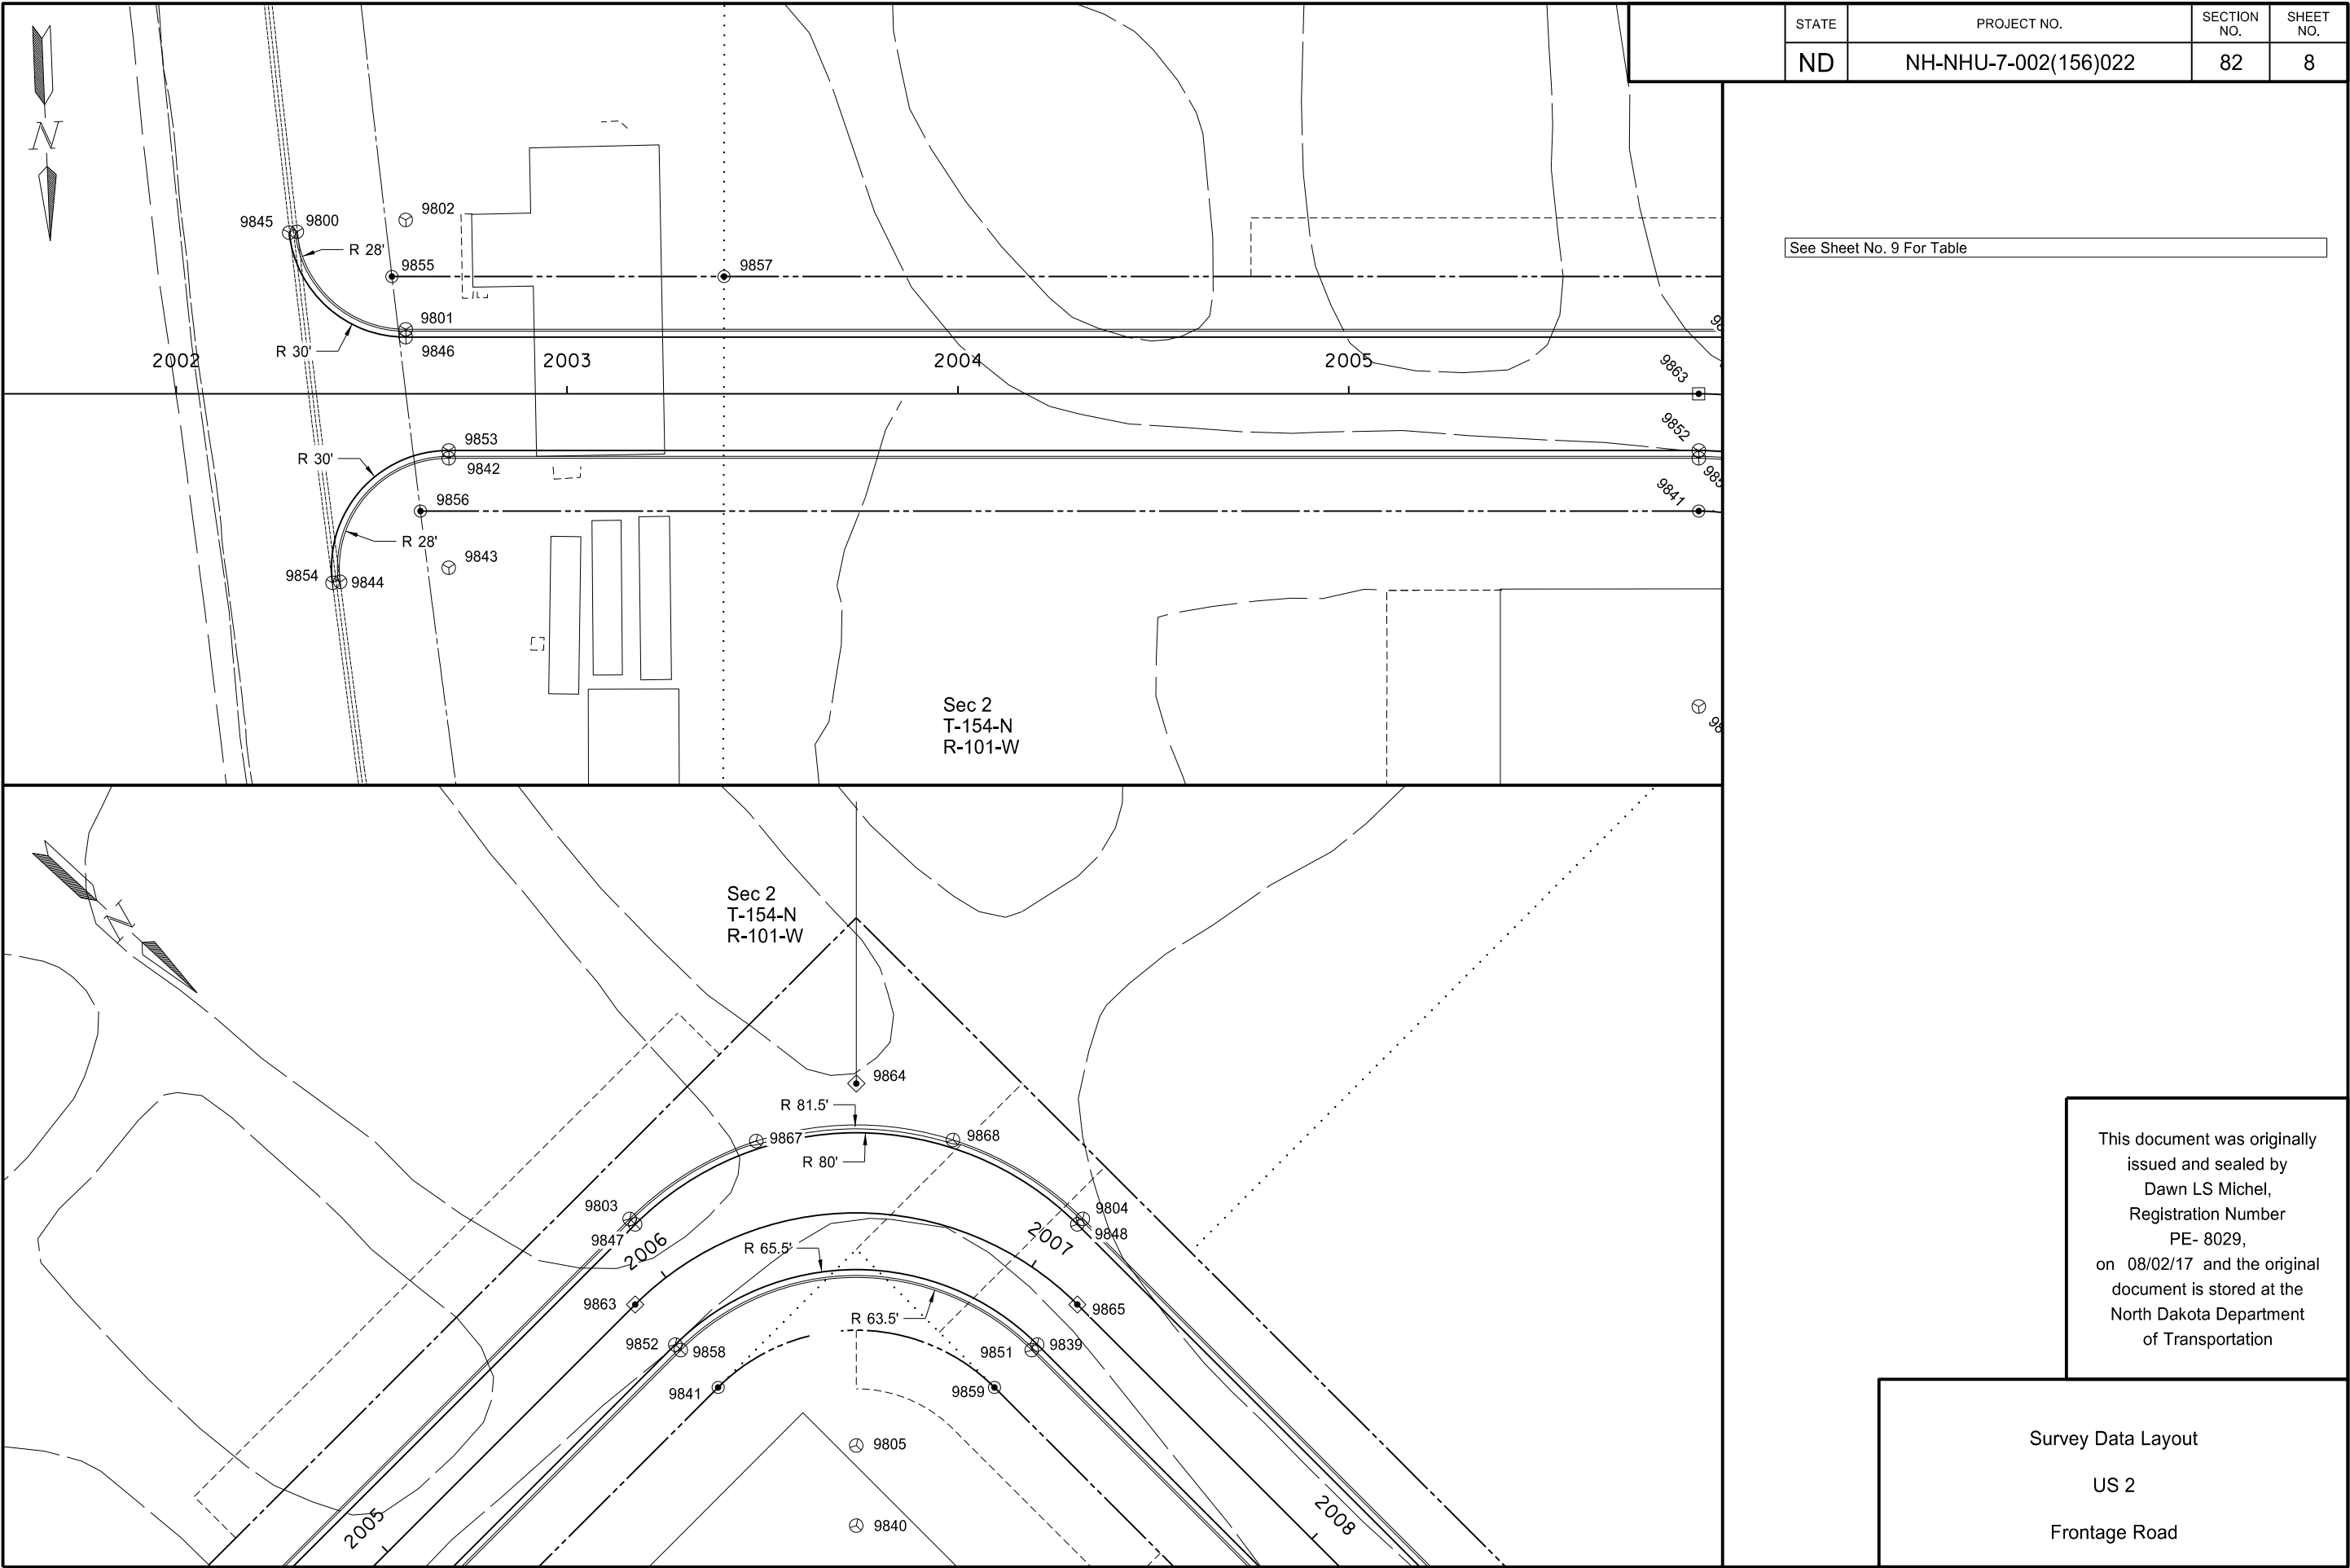



STATE	PROJECT NO.	SECTION NO.	SHEET NO.
ND	NH-NHU-7-002(156)022	82	8


See Sheet No. 9 For Table

This document was originally issued and sealed by
Dawn LS Michel,
Registration Number
PE- 8029,
on 08/02/17 and the original document is stored at the
North Dakota Department
of Transportation

Survey Data Layout
US 2
Frontage Road

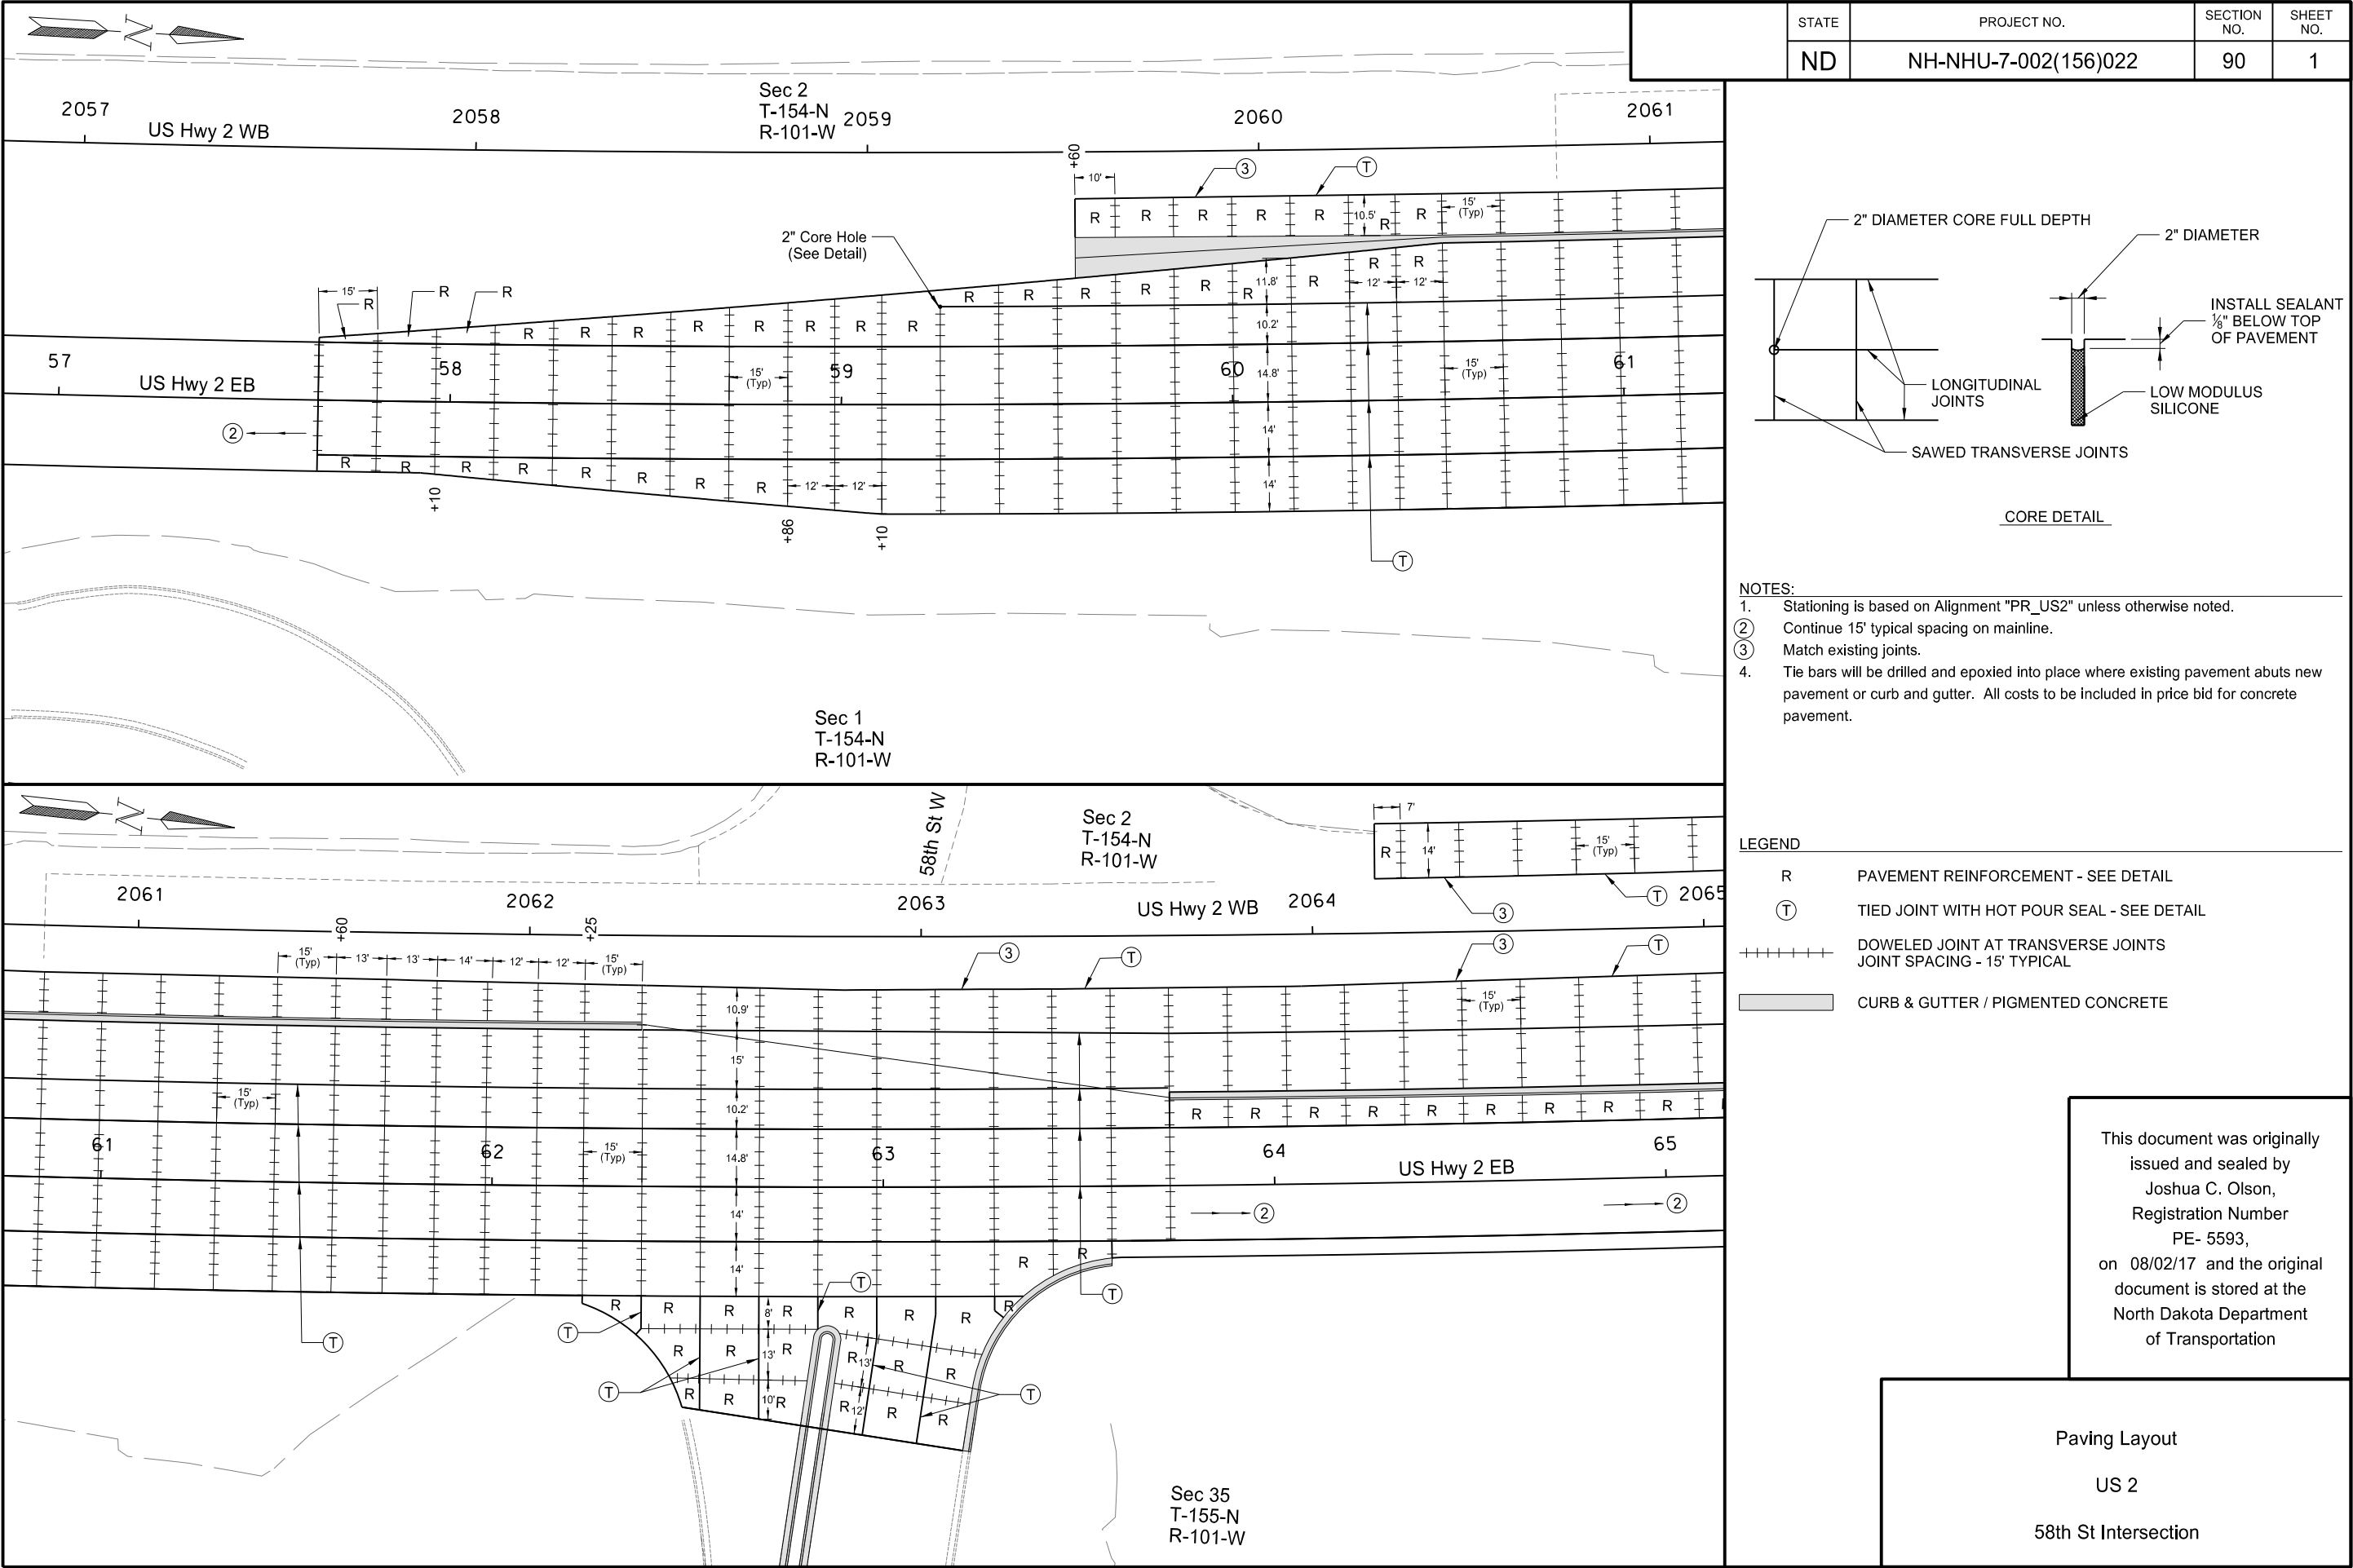

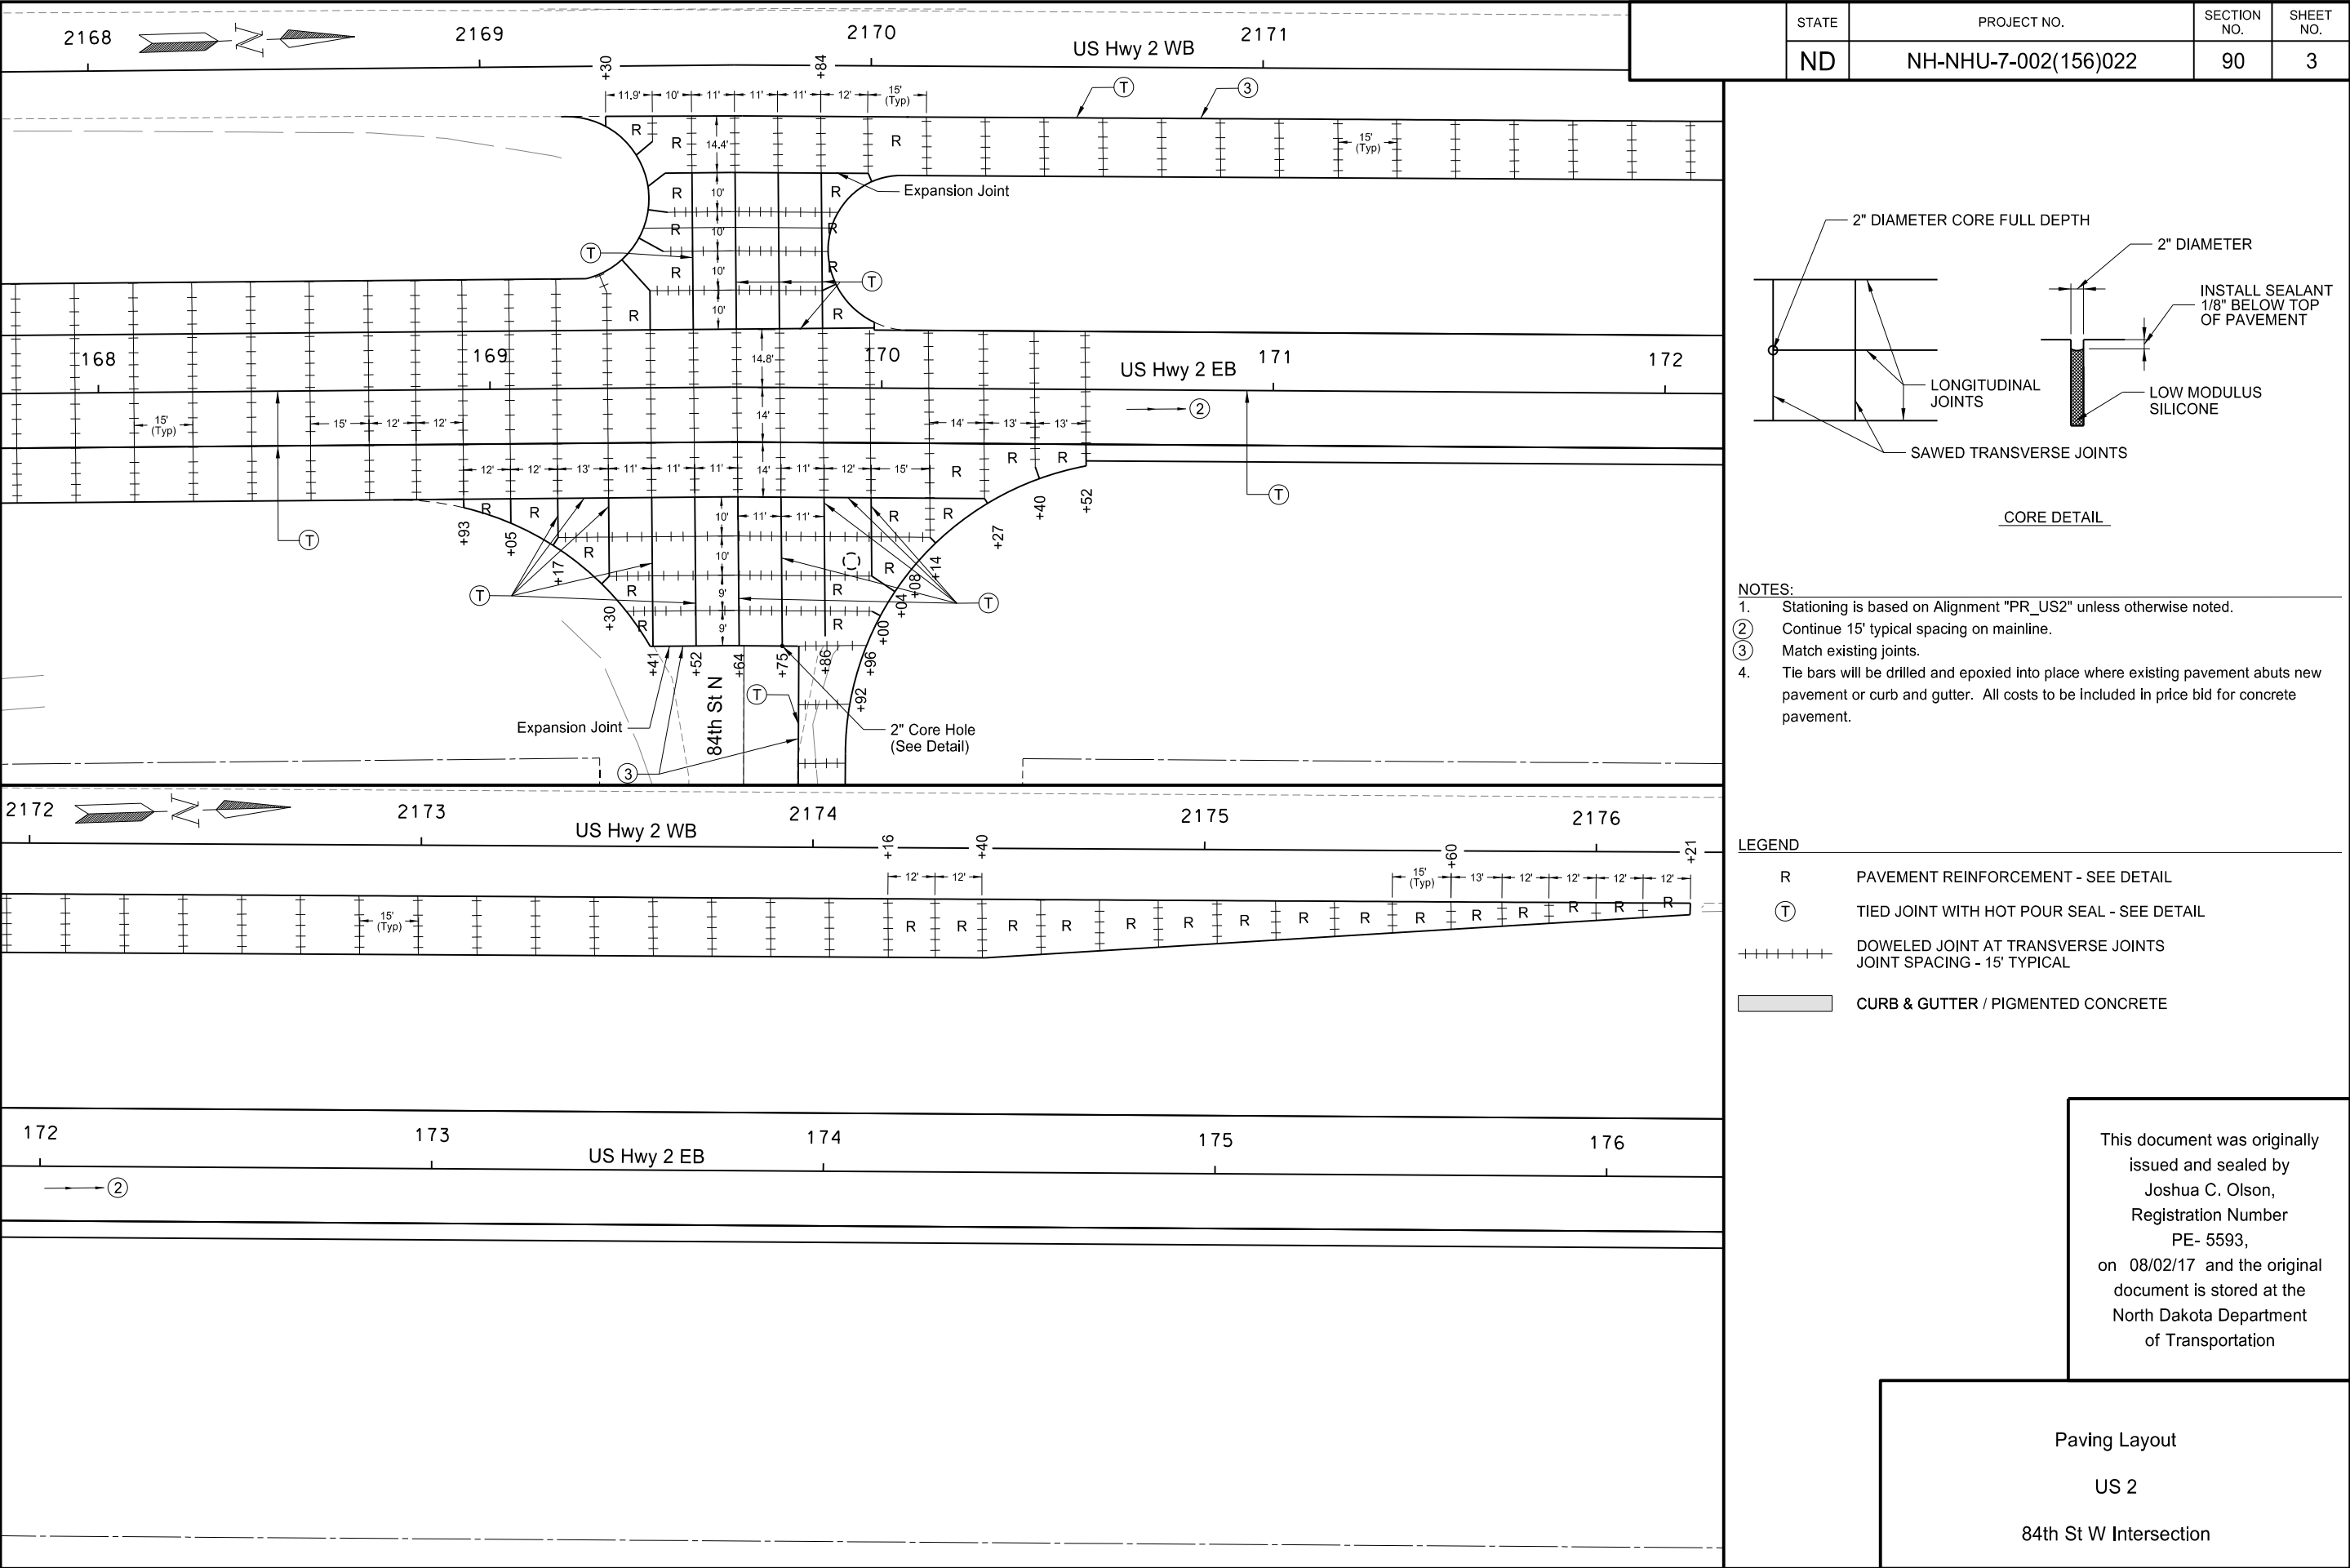

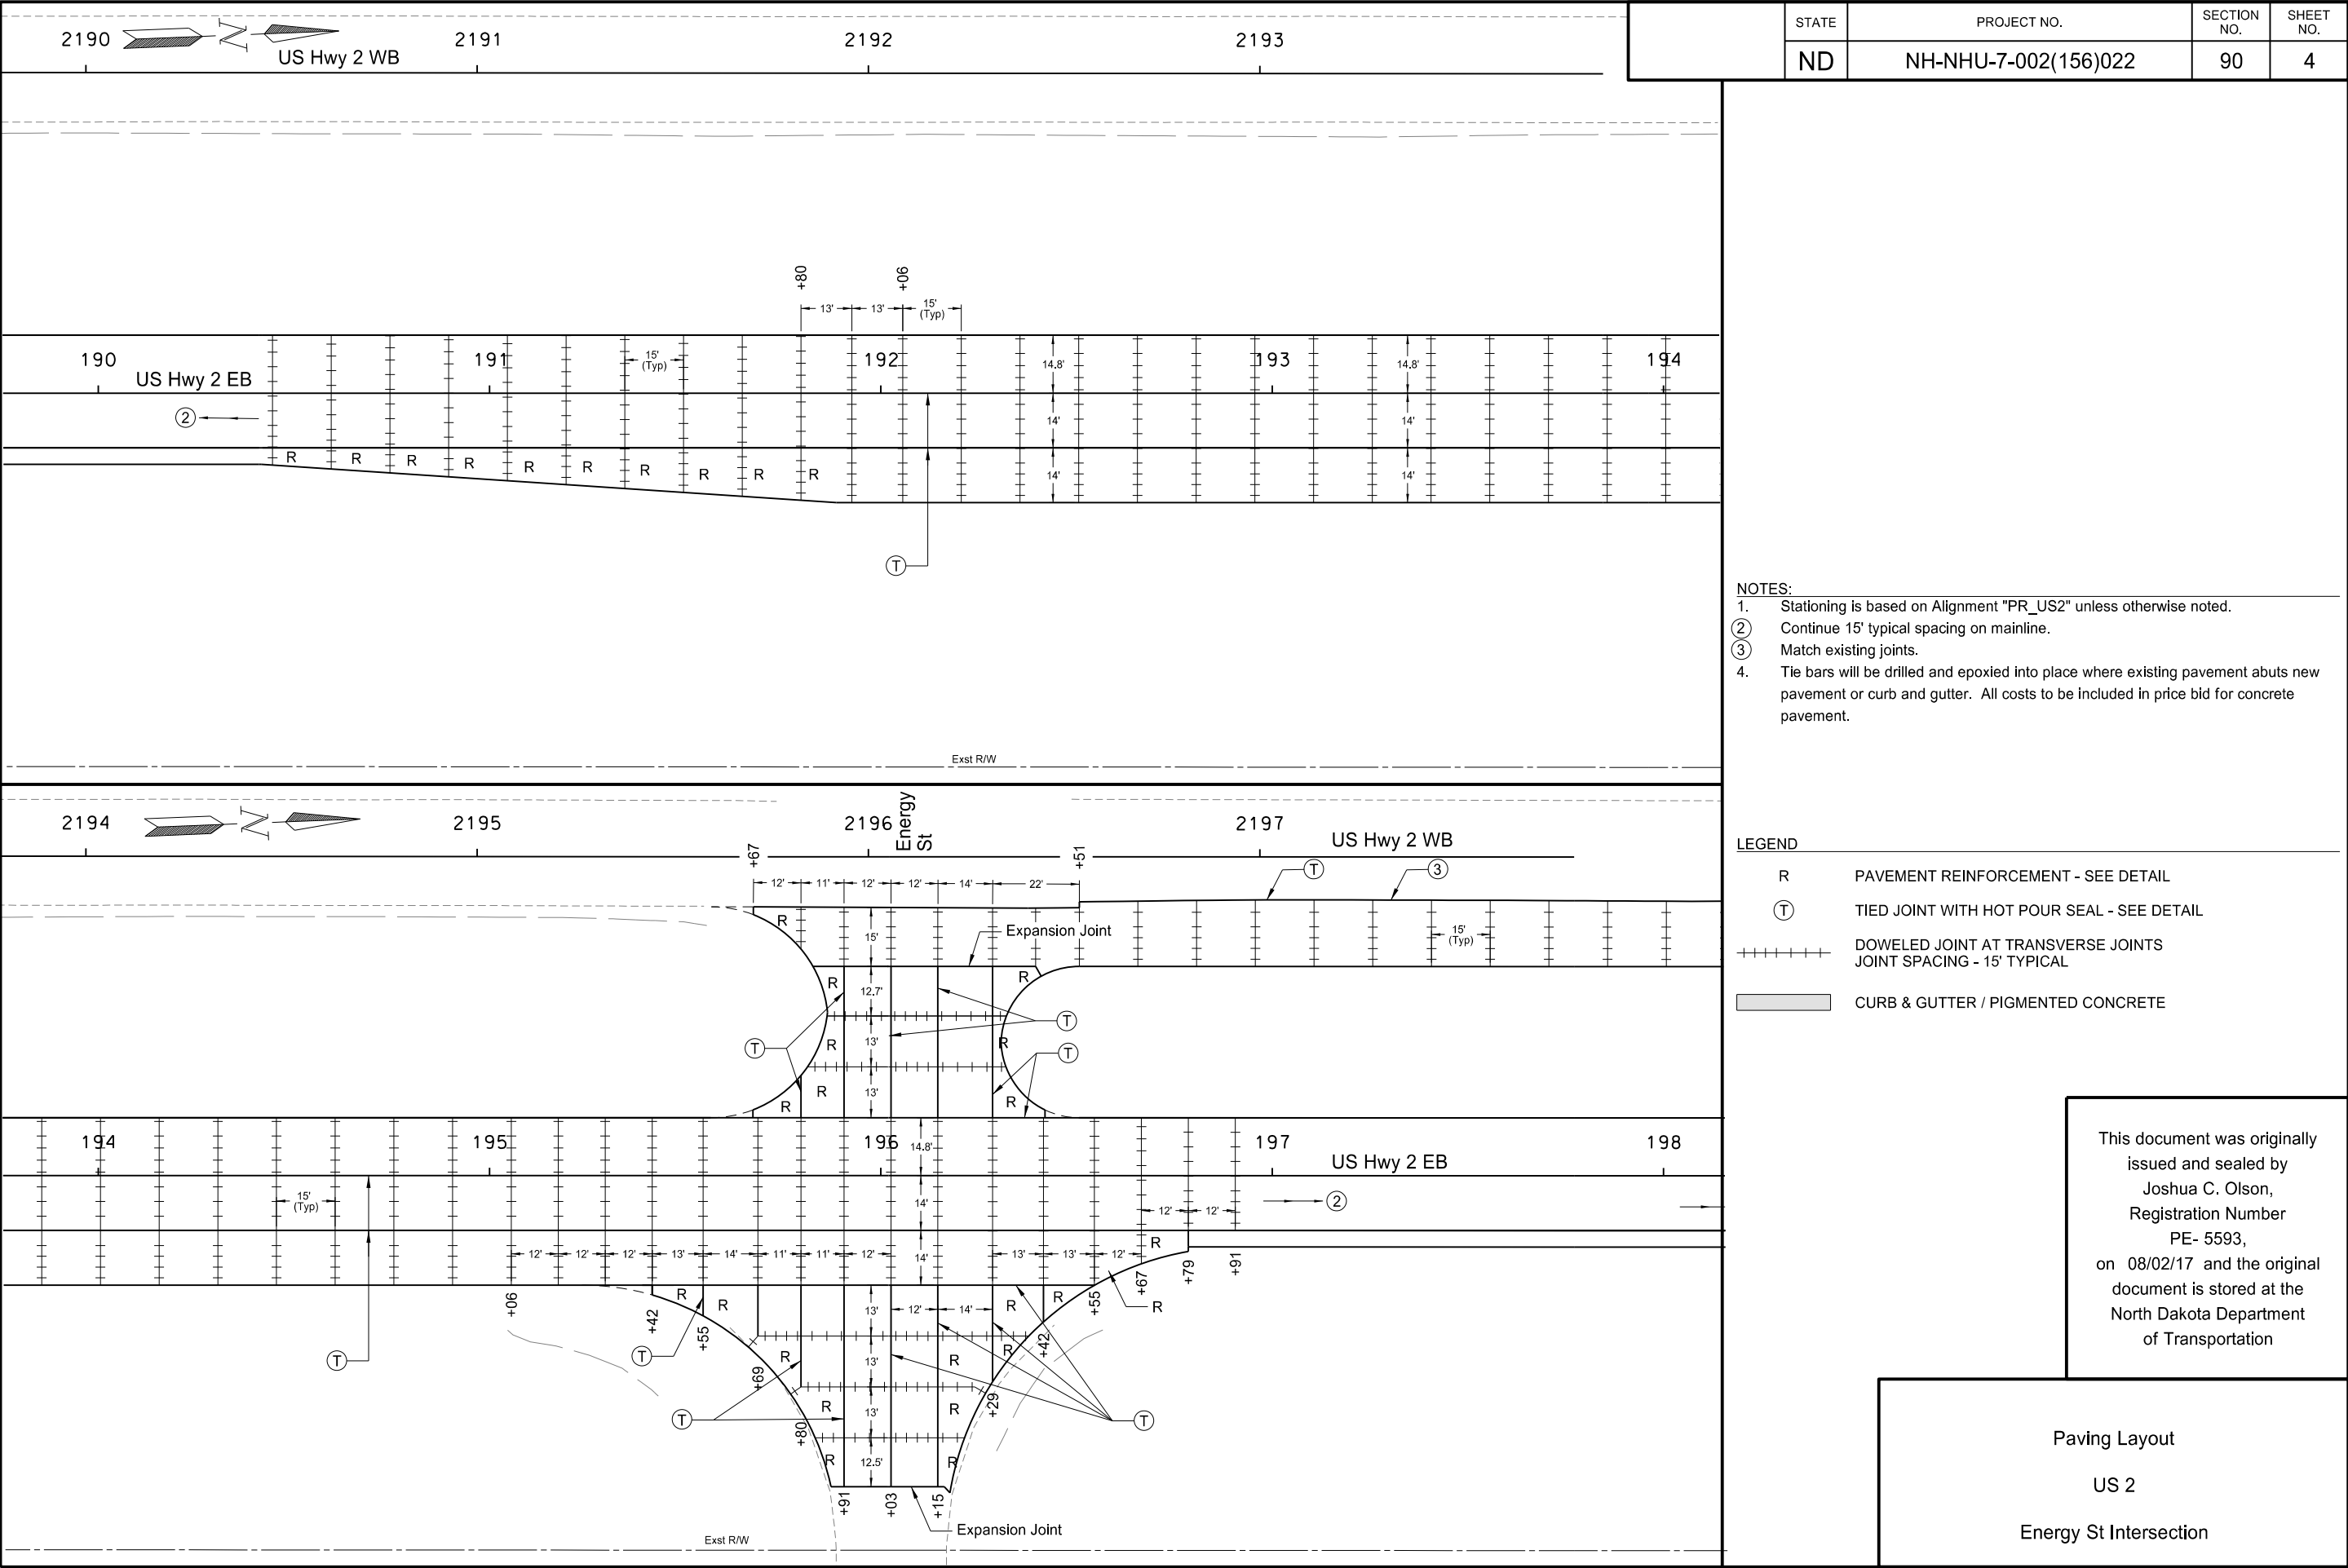

STATE	PROJECT NO.	SECTION NO.	SHEET NO.
ND	NH-NHU-7-002(156)022	100	1

SIGN NUMBER	SIGN SIZE	DESCRIPTION	AMOUNT REQUIRED				TOTAL AMOUNT REQUIRED	UNITS PER AMOUNT	UNITS SUB TOTAL
			BY PHASE NO.						
			1	2	3	4			
D3-36	36"x6"	STREET NAME SIGN (Sign and installation only)						6	
G20-1-60	60"x24"	ROAD WORK NEXT ____ MILES						34	
G20-1b-60	60"x24"	WORK IN PROGRESS/ NO WORK IN PROGRESS (Sign and installation only)						26	
G20-2-48	48"x24"	END ROAD WORK	16	2	11		16	19	304
G20-4-36	36"x18"	PILOT CAR FOLLOW ME (Mounted to back of pilot car)						18	
G20-10-108	108"x48"	CONTRACTOR SIGN	2		2		2	64	128
G20-50a-72	72"x36"	ROAD WORK NEXT ____ MILES RT & LT ARROWS		17			17	37	629
G20-52a-72	72"x24"	ROAD WORK NEXT ____ MILES RT or LT ARROW						30	
G20-55-96	96"x48"	SPEED LIMIT ENFORCED - MINIMUM FEE \$80 WHEN WORKERS PRESENT	16	4	12		16	59	944
M1-1-36	36"x36"	INTERSTATE ROUTE MARKER (Post and installation only)						10	
M1-4-24	24"x24"	U.S. ROUTE MARKER (Post and installation only)						10	
M1-5-24	24"x24"	STATE ROUTE MARKER (Post and installation only)						10	
M3-1-24	24"x12"	NORTH (Mounted on route marker post)						7	
M3-2-24	24"x12"	EAST (Mounted on route marker post)						7	
M3-3-24	24"x12"	SOUTH (Mounted on route marker post)						7	
M3-4-24	24"x12"	WEST (Mounted on route marker post)						7	
M4-8-24	24"x12"	DETOUR (Mounted on route marker post)						7	
M4-9-30	30"x24"	DETOUR ARROW RIGHT or LEFT/AHD AND RT or LT						15	
M4-10-48	48"x18"	DETOUR ARROW RIGHT or LEFT						23	
M5-1-21	21"x15"	ARROW AHD AND RT or LT (Mounted on route marker post)						7	
M5-2-21	21"x15"	ARROW AHD UP & RT or LT (Mounted on route marker post)						7	
M6-1-21	21"x15"	ARROW RT or LT (Mounted on route marker post)						7	
M6-2-21	21"x15"	ARROW UP & RT or LT (Mounted on route marker post)						7	
M6-3-21	21"x15"	ARROW AHD (Mounted on route marker post)						7	
R1-1-48	48"x48"	STOP						32	
R1-1a-18	18"x18"	STOP and SLOW PADDLE Back to Back	8		5		8	5	40
R1-2-60	60"x60"	YIELD		1			1	29	29
R2-1-48	48"x60"	SPEED LIMIT ____	56	11	40		56	39	2184
R2-1a-24	24"x18"	MINIMUM FEE \$80 (Mounted on Speed Limit post)			10		10	10	100
R2-1aP-24	24"x18"	MINIMUM FEE \$80 (Mounted on Speed Limit post)	16		2		16	10	160
R3-2-24	24"x24"	LEFT TURN PROHIBITION						10	
R3-6L-36	30"x36"	MANDATORY MOVEMENT LANE CONTROL		1			1	16	16
R3-7-48	48"x48"	LEFT or RIGHT LANE MUST TURN LEFT or RIGHT		1			1	35	35
R4-1-48	48"x60"	DO NOT PASS	16	18	10		18	39	702
R4-7-48	48"x60"	KEEP RIGHT SYMBOL		2			2	39	78
R5-1-48	48"x48"	DO NOT ENTER						35	
R6-1-36	36"x12"	ONE WAY RIGHT or LEFT						13	
R7-1-12	12"x18"	NO PARKING						11	
R10-6-24	24"x36"	STOP HERE ON RED						16	
R11-2-48	48"x30"	ROAD CLOSED		5		7	7	28	196
R11-2a-48	48"x30"	STREET CLOSED						28	
R11-3a-60	60"x30"	ROAD CLOSED ____ MILES AHEAD LOCAL TRAFFIC ONLY						31	
R11-3c-60	60"x30"	STREET CLOSED ____ MILES AHEAD LOCAL TRAFFIC ONLY						31	
R11-4a-60	60"x30"	STREET CLOSED TO THRU TRAFFIC						31	
W1-3-48	48"x48"	RIGHT or LEFT SHARP REVERSE CURVE ARROW						35	
W1-4-48	48"x48"	RIGHT or LEFT REVERSE CURVE ARROW		3			3	35	105
W1-4b-48	48"x48"	DOUBLE RIGHT or LEFT REVERSE CURVE ARROW						35	
W1-6-48	48"x24"	LARGE ARROW		2			2	26	52
W3-1-48	48"x48"	STOP AHEAD SYMBOL						35	
W3-3-48	48"x48"	SIGNAL AHEAD SYMBOL						35	
W3-4-48	48"x48"	BE PREPARED TO STOP						35	
W3-5-48	48"x48"	SPEED REDUCTION AHEAD	16	2	12		16	35	560
W4-1L-48	48"x48"	MERGING TRAFFIC		1			1	35	35
W4-2-48	48"x48"	RIGHT or LEFT LANE TRANSITION SYMBOL	16	4	12		16	35	560
W5-1-48	48"x48"	ROAD NARROWS						35	
W5-8-48	48"x48"	THRU TRAFFIC RIGHT LANE						35	
W5-9-48	48"x48"	ROAD WORK TRAFFIC ONLY DOWN & LT or RT ARROW						35	
W6-3-48	48"x48"	TWO WAY TRAFFIC SYMBOL		19			19	35	665
W8-1-48	48"x48"	BUMP						35	
W8-3-48	48"x48"	PAVEMENT ENDS						35	
W8-7-48	48"x48"	LOOSE GRAVEL						35	
W8-9a-48	48"x48"	SHOULDER DROP-OFF						35	
W8-11-48	48"x48"	UNEVEN LANES						35	
W8-12-48	48"x48"	NO CENTER STRIPE						35	
W8-53-48	48"x48"	TRUCKS ENTERING HIGHWAY						35	
W8-54-48	48"x48"	TRUCKS ENTERING AHEAD or ____ FT.						35	
W8-55-48	48"x48"	TRUCKS CROSSING AHEAD or ____ FT.						35	
W8-56-48	48"x48"	TRUCKS EXITING HIGHWAY						35	
W9-3a-48	48"x48"	CENTER LANE CLOSED SYMBOL						35	
W12-2-48	48"x48"	LOW CLEARANCE SYMBOL						35	
W13-1-24	24"x24"	____ MPH ADVISORY SPEED PLATE (Mounted on warning sign post)		2			2	11	22
W13-4-48	48"x60"	RAMP ARROW						39	
W14-3-48	48"x36"	NO PASSING ZONE						23	
W20-1-48	48"x48"	ROAD WORK AHEAD or ____ FT or ____ MILE	16	28	12		28	35	980
W20-2-48	48"x48"	DETOUR AHEAD or ____ FT						35	
W20-3-48	48"x48"	ROAD or STREET CLOSED AHEAD or ____ FT.				3	3	35	105
W20-4-48	48"x48"	ONE LANE ROAD AHEAD or ____ FT.						35	
W20-5-48	48"x48"	RIGHT or LEFT LANE CLOSED AHEAD or ____ FT.	16	6	12		16	35	560
W20-7a-48	48"x48"	FLAGGING SYMBOL	8		5		8	35	280
W20-7k-24	24"x18"	____ FEET (Mounted on warning sign post)						10	
W20-8-48	48"x48"	STREET CLOSED						35	
W20-51-48	48"x48"	EQUIPMENT WORKING						35	

[illegible][illegible]

SPEC & CODE			
704-1000	TRAFFIC CONTROL SIGNS	TOTAL UNITS	9860

[illegible]


NOTE:
If additional signs are required, units will be calculated using the formula from Section III-19.06 of the Design Manual.
<http://www.dot.nd.gov/>

This document was
originally issued
and sealed by
Levi J Heller,
Registration Number
PE-10394,
on 8/28/17 and the
original document
is stored at the North Dakota
Department of Transportation.

Traffic Control Devices List

US 2

	STATE	PROJECT NO.	SECTION NO.	SHEET NO.
	ND	NH-NHU-7-002(156)022	100	2


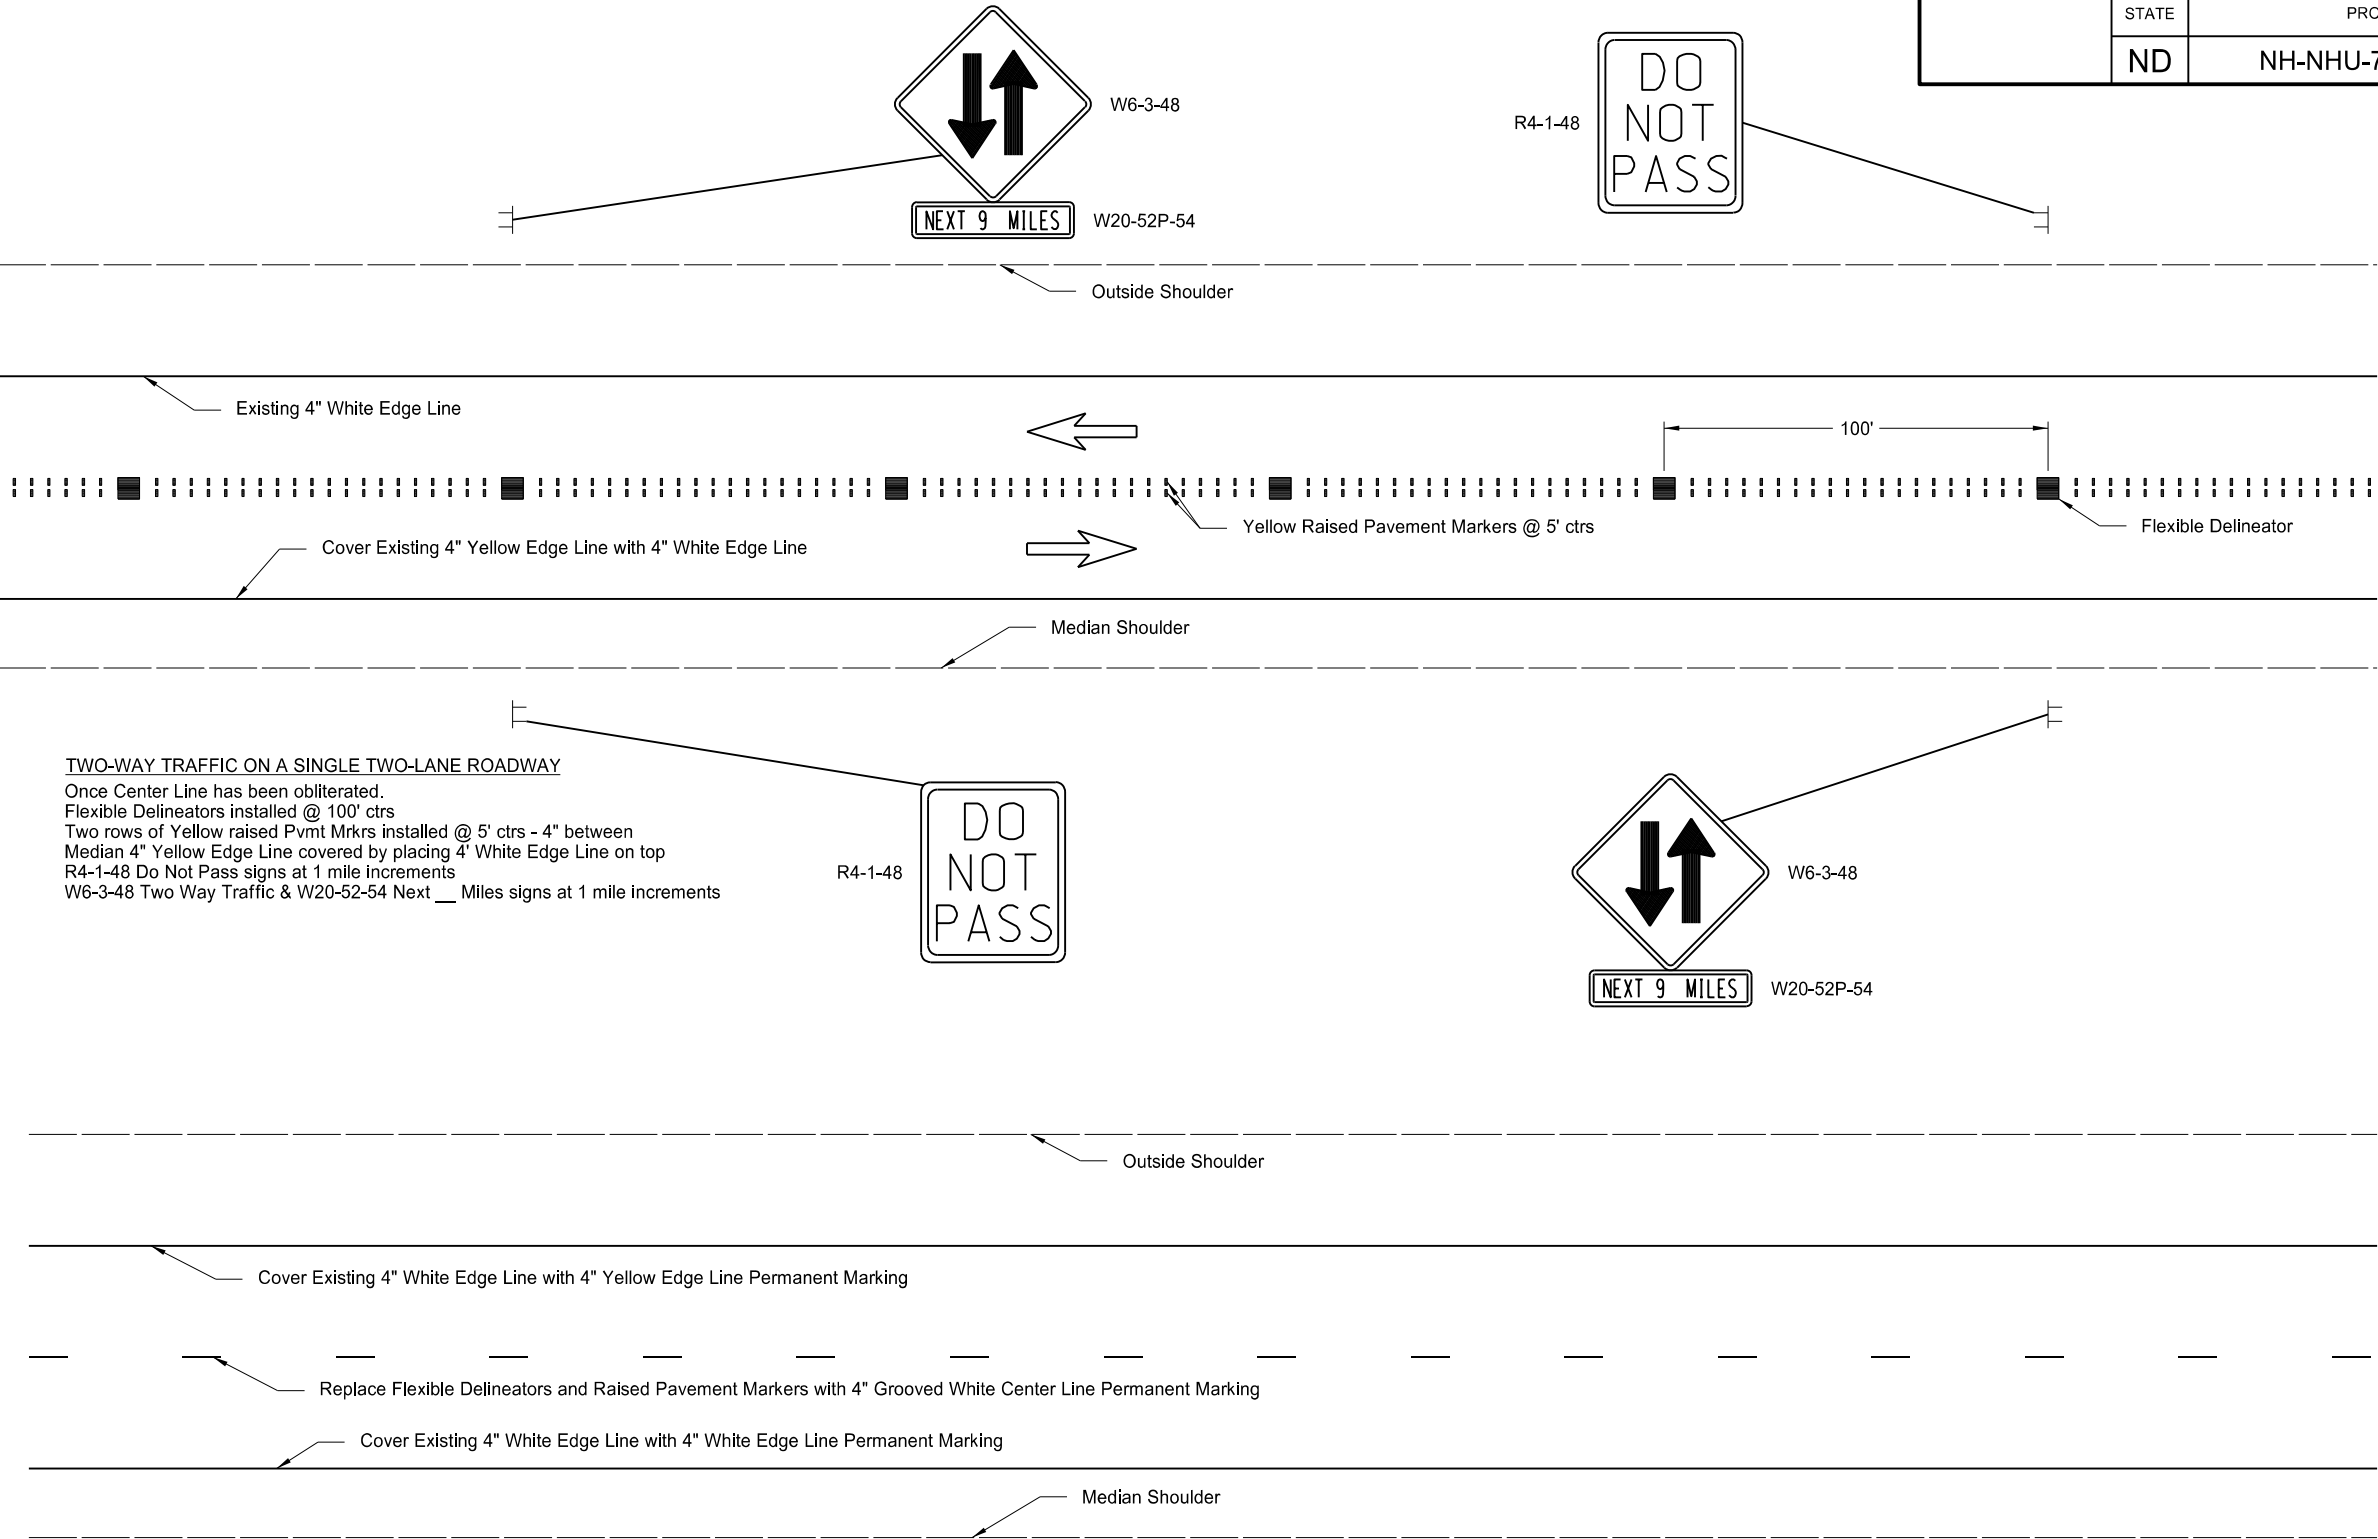


This document was originally issued and sealed by
Levi J Heller,
Registration Number
PE-10394
on 08/28/17 and the original document is stored at the
North Dakota Department
of Transportation


Two Way Traffic Control
US 2

*Note: Drawing not to scale.


	STATE	PROJECT NO.	SECTION NO.	SHEET NO.
	ND	NH-NHU-7-002(156)022	100	3

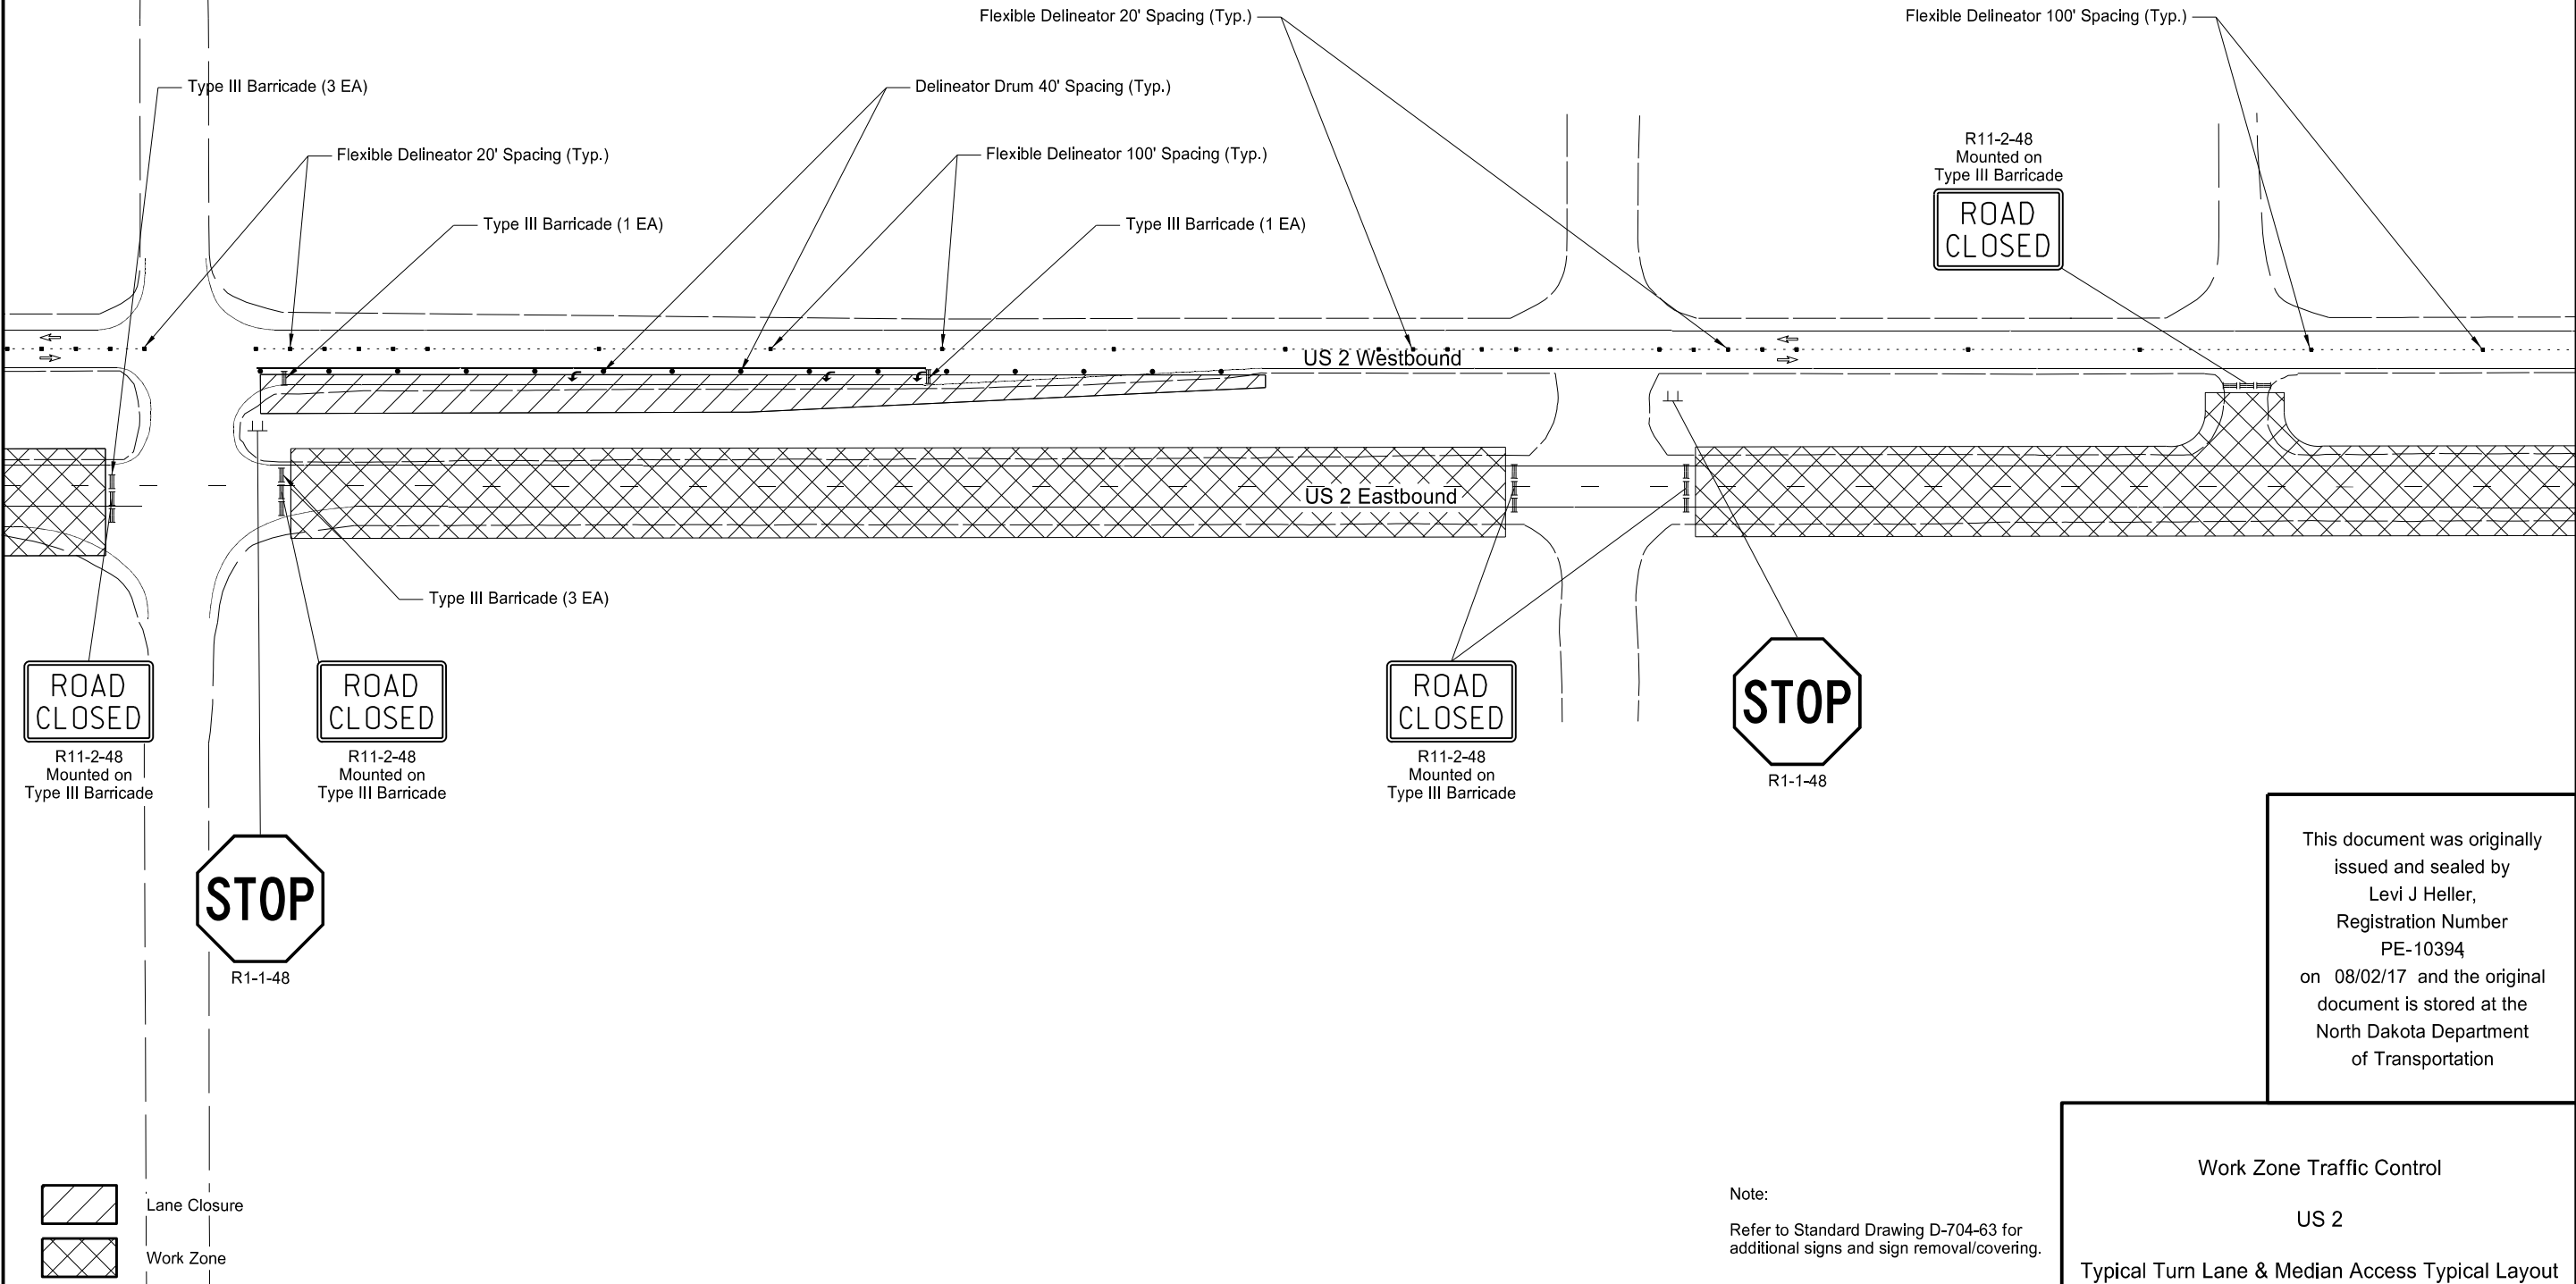 


	STATE	PROJECT NO.	SECTION NO.	SHEET NO.
	ND	NH-NHU-7-002(156)022	100	5

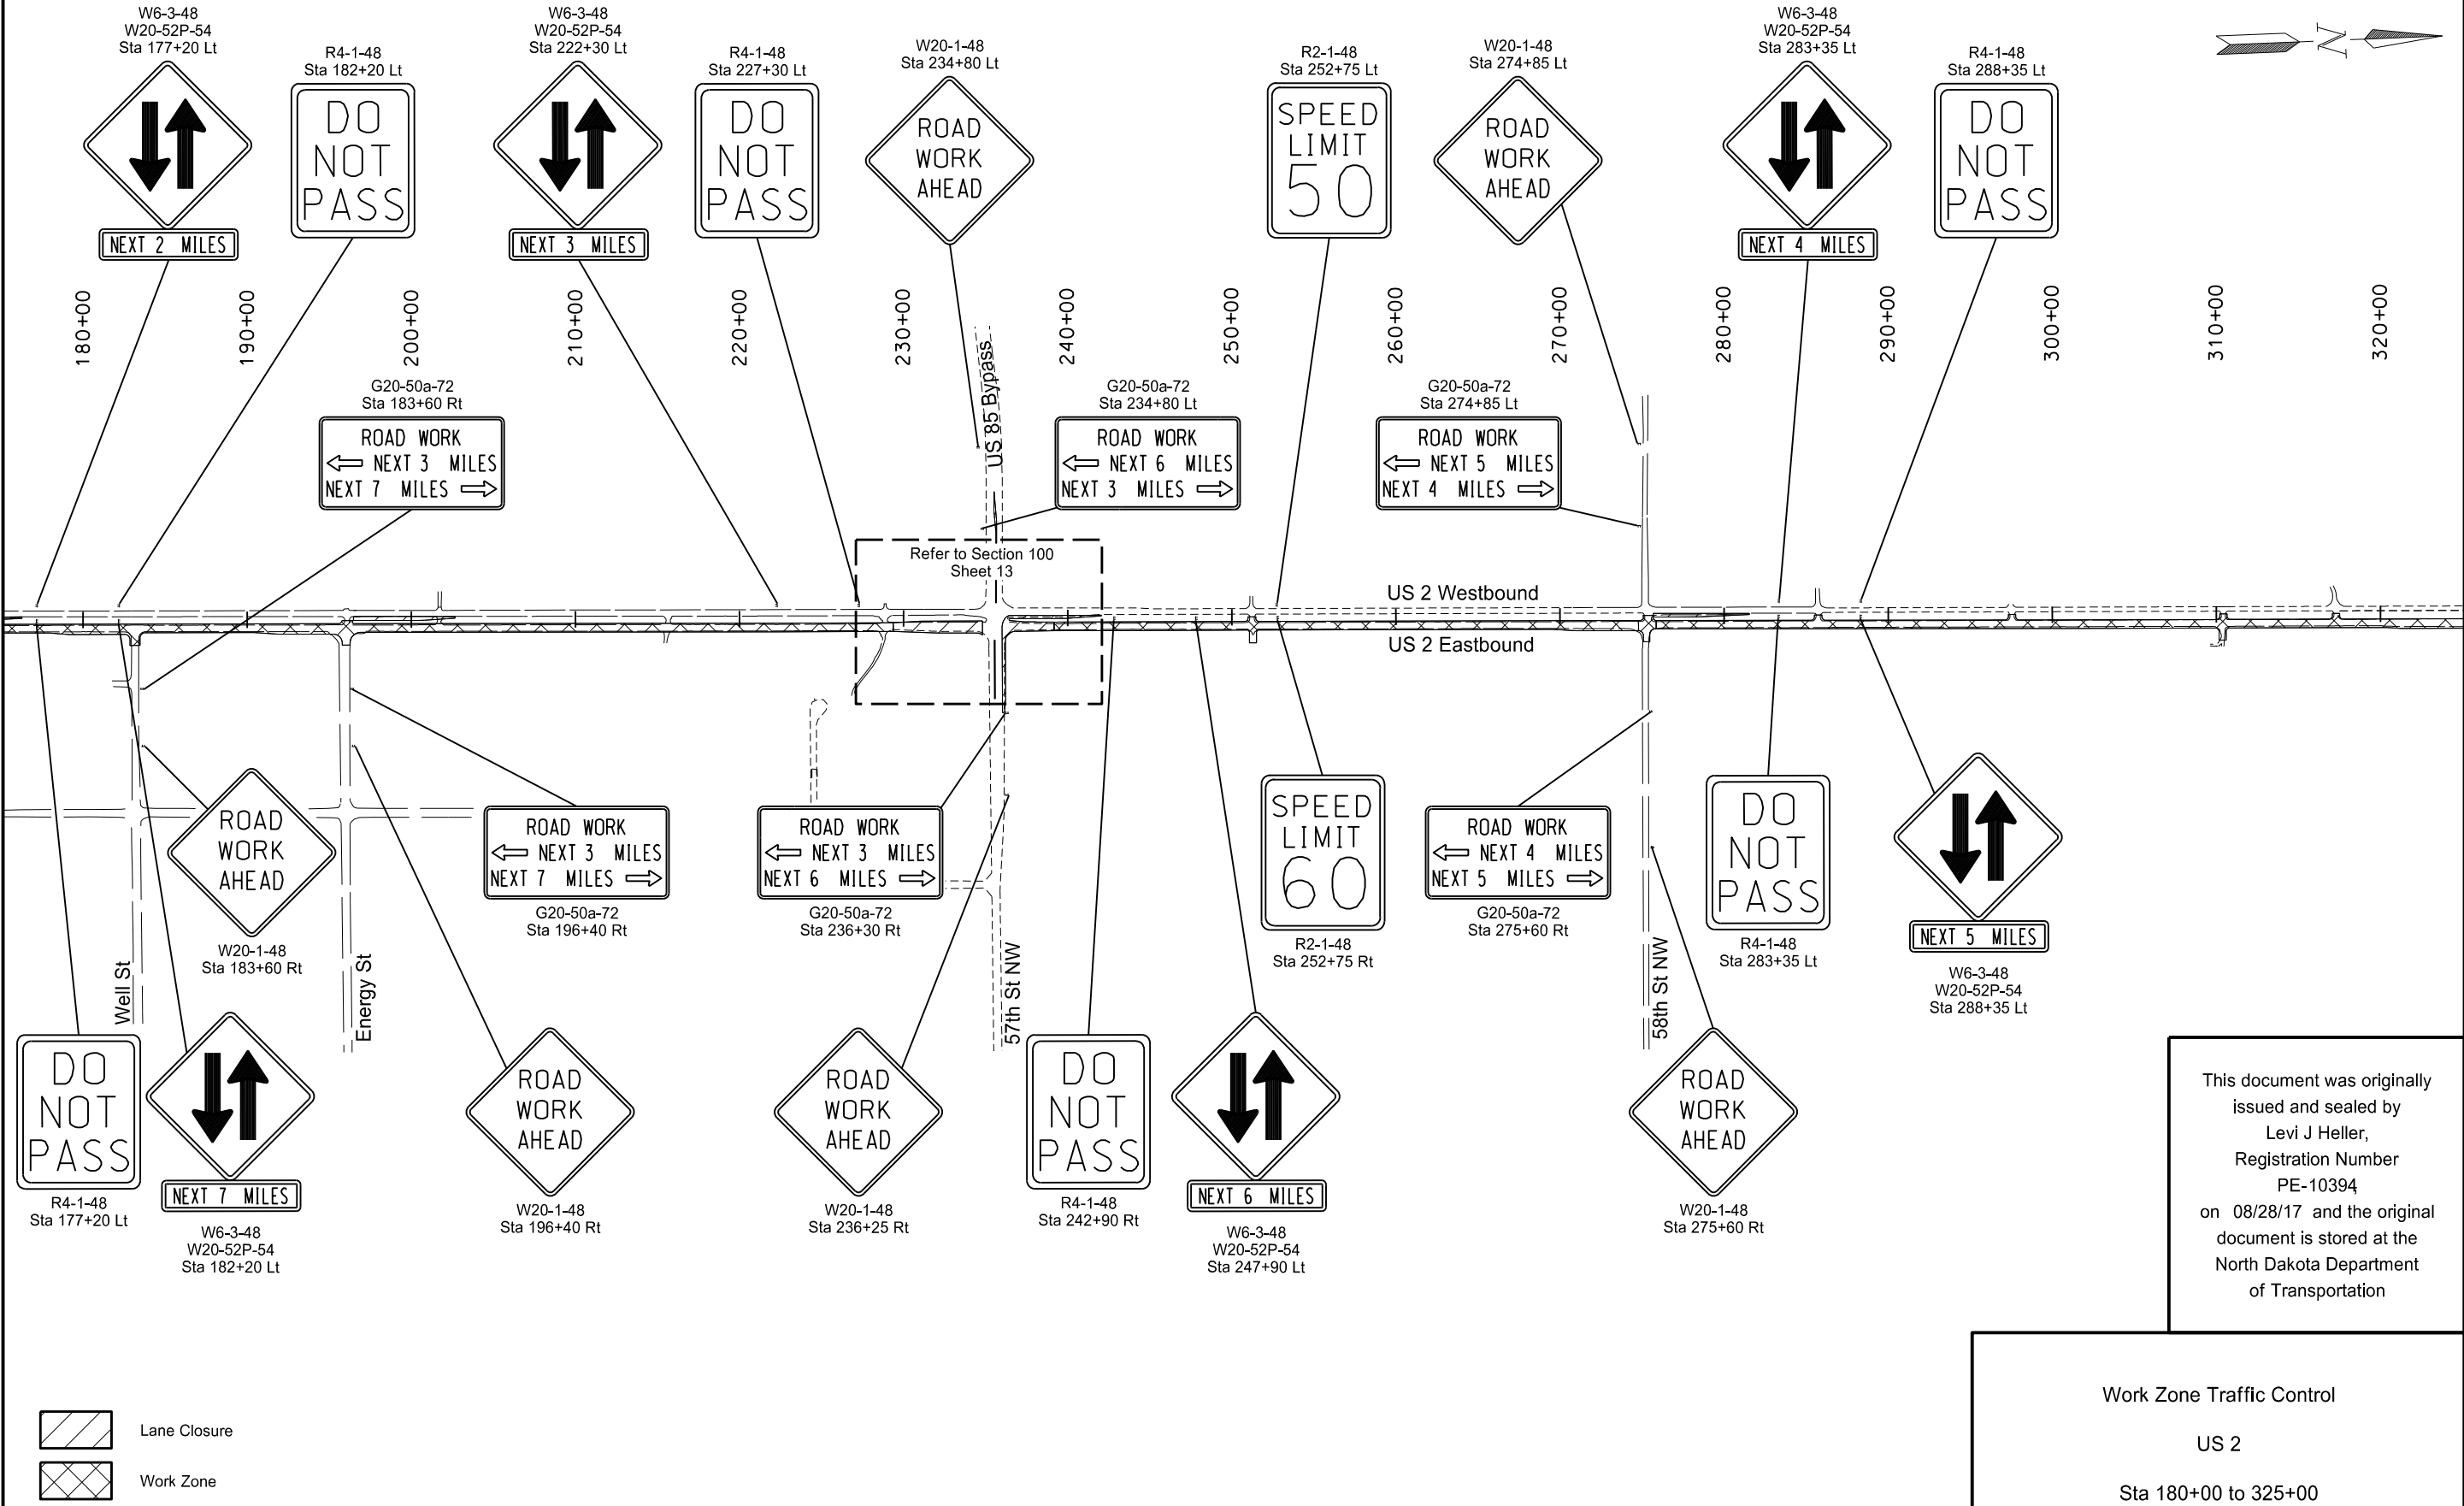

	STATE	PROJECT NO.	SECTION NO.	SHEET NO.
	ND	NH-NHU-7-002(156)022	100	7

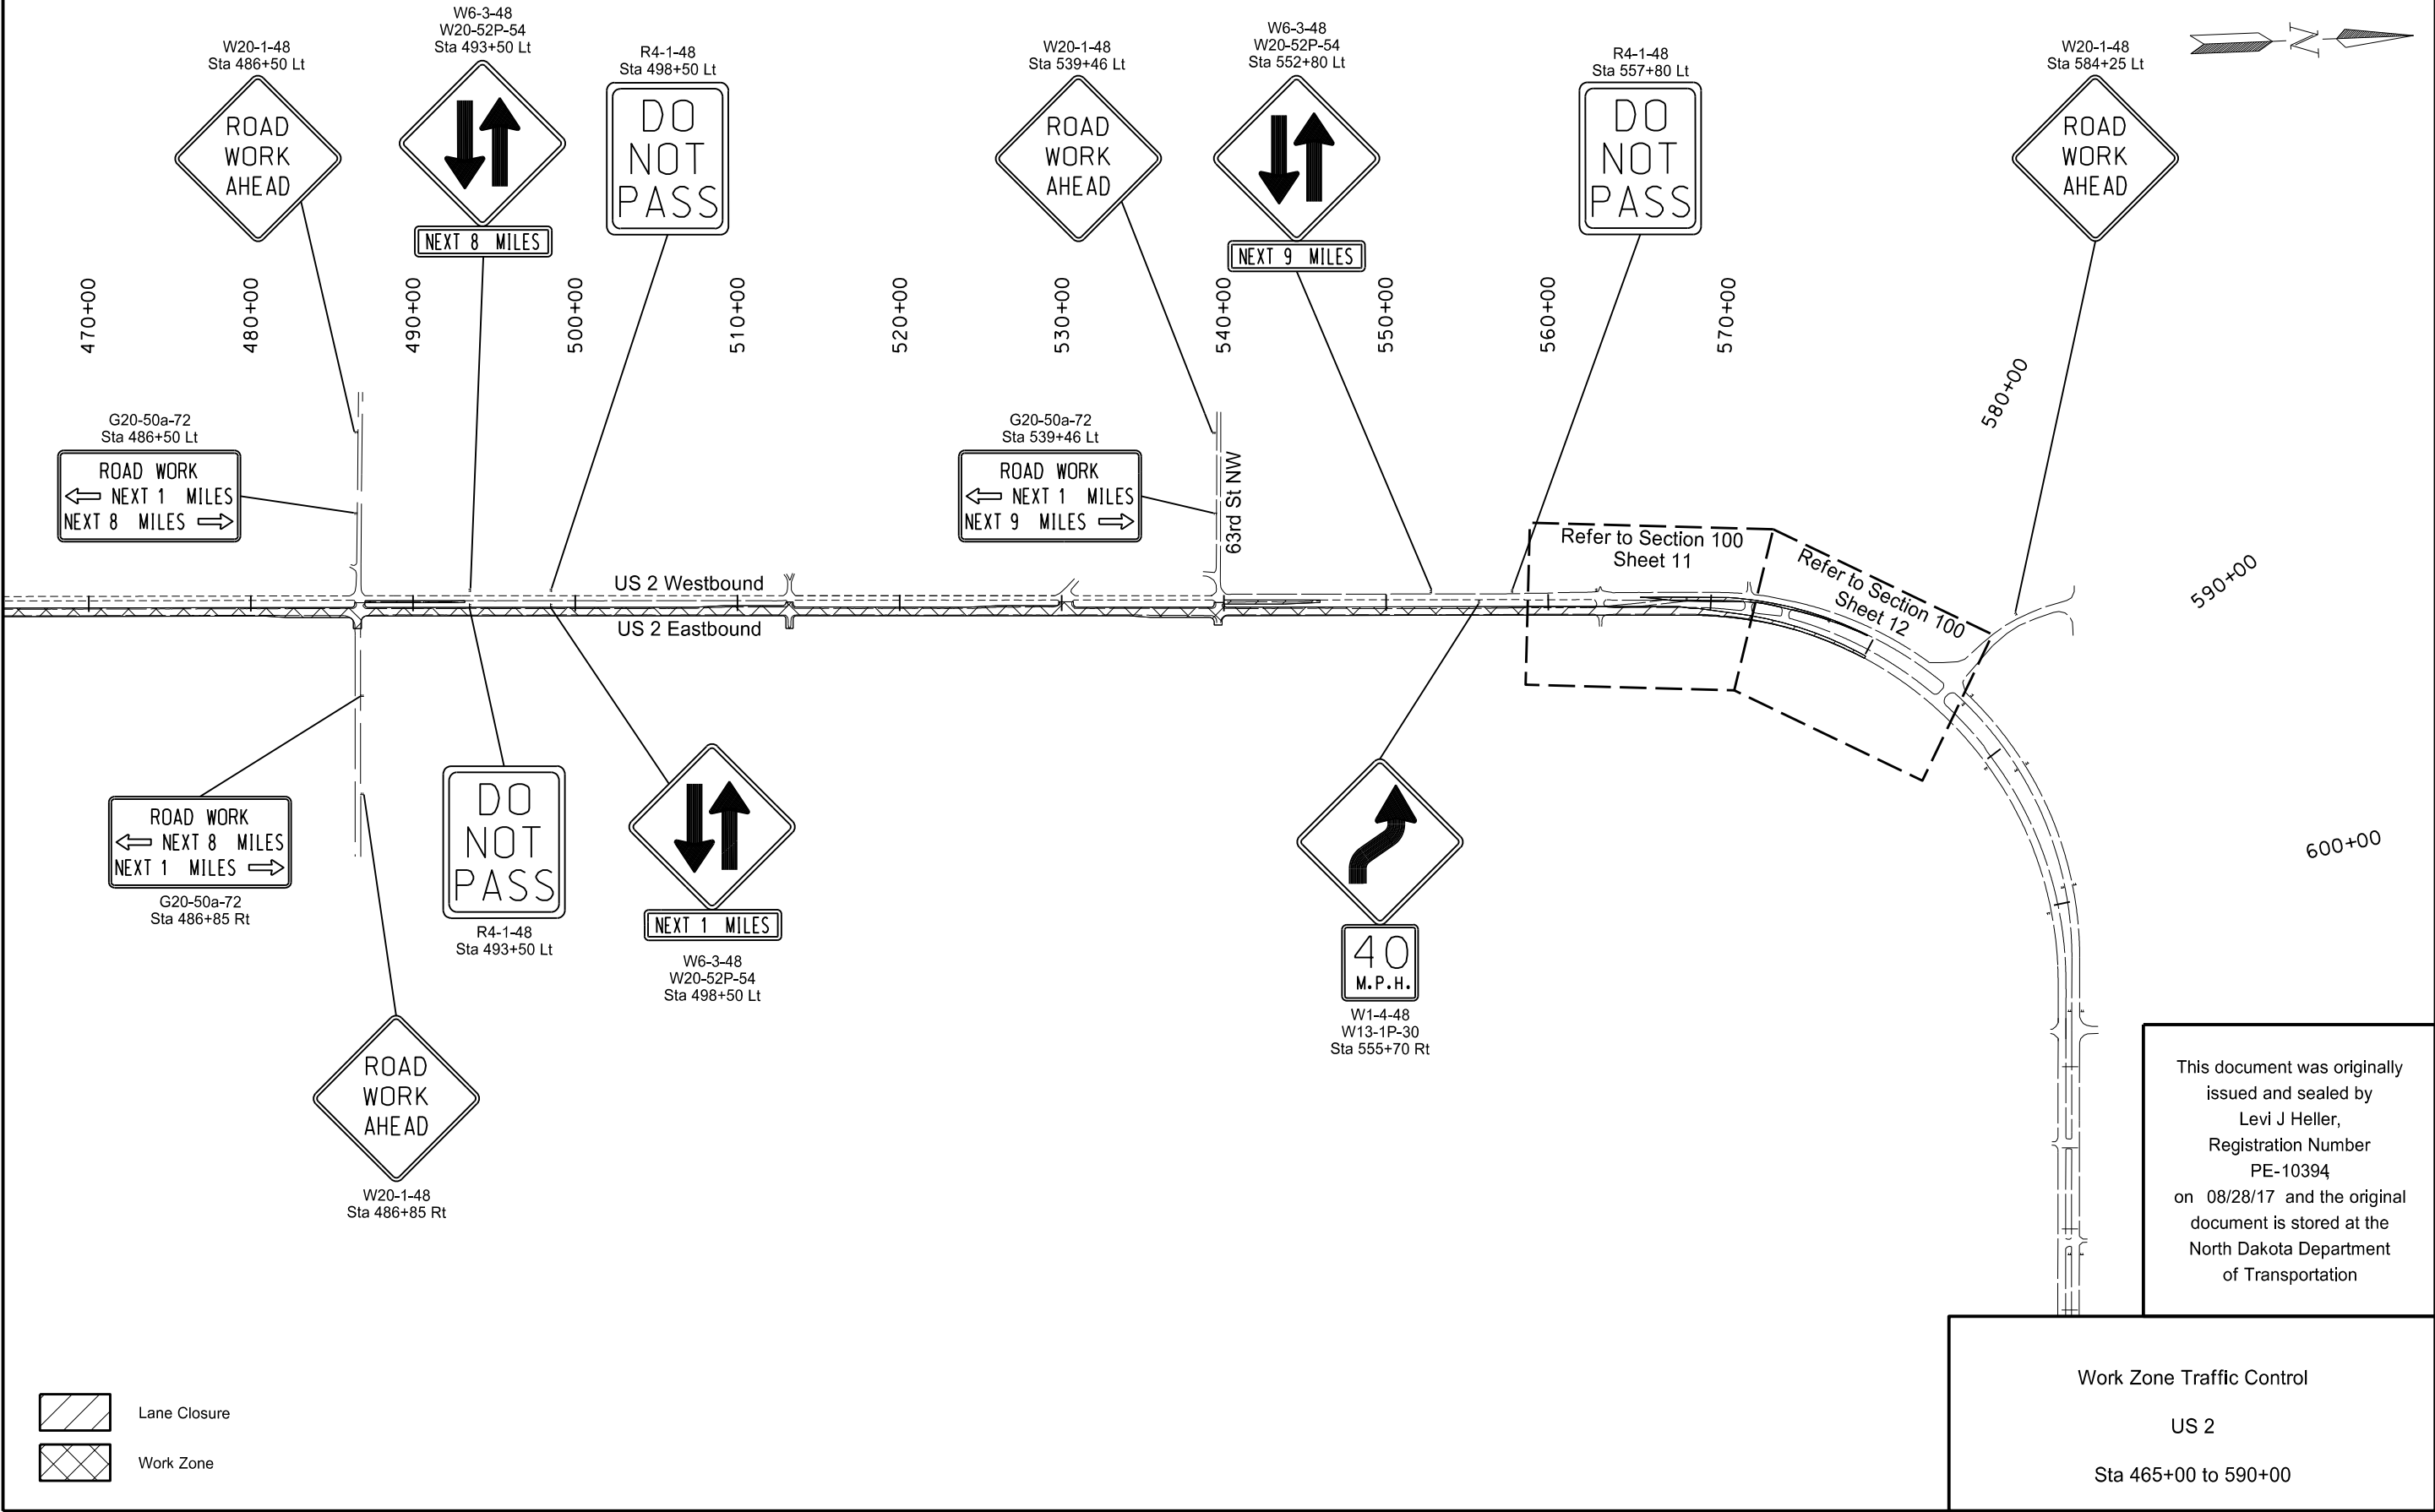


	STATE	PROJECT NO.	SECTION NO.	SHEET NO.
	ND	NH-NHU-7-002(156)022	100	8

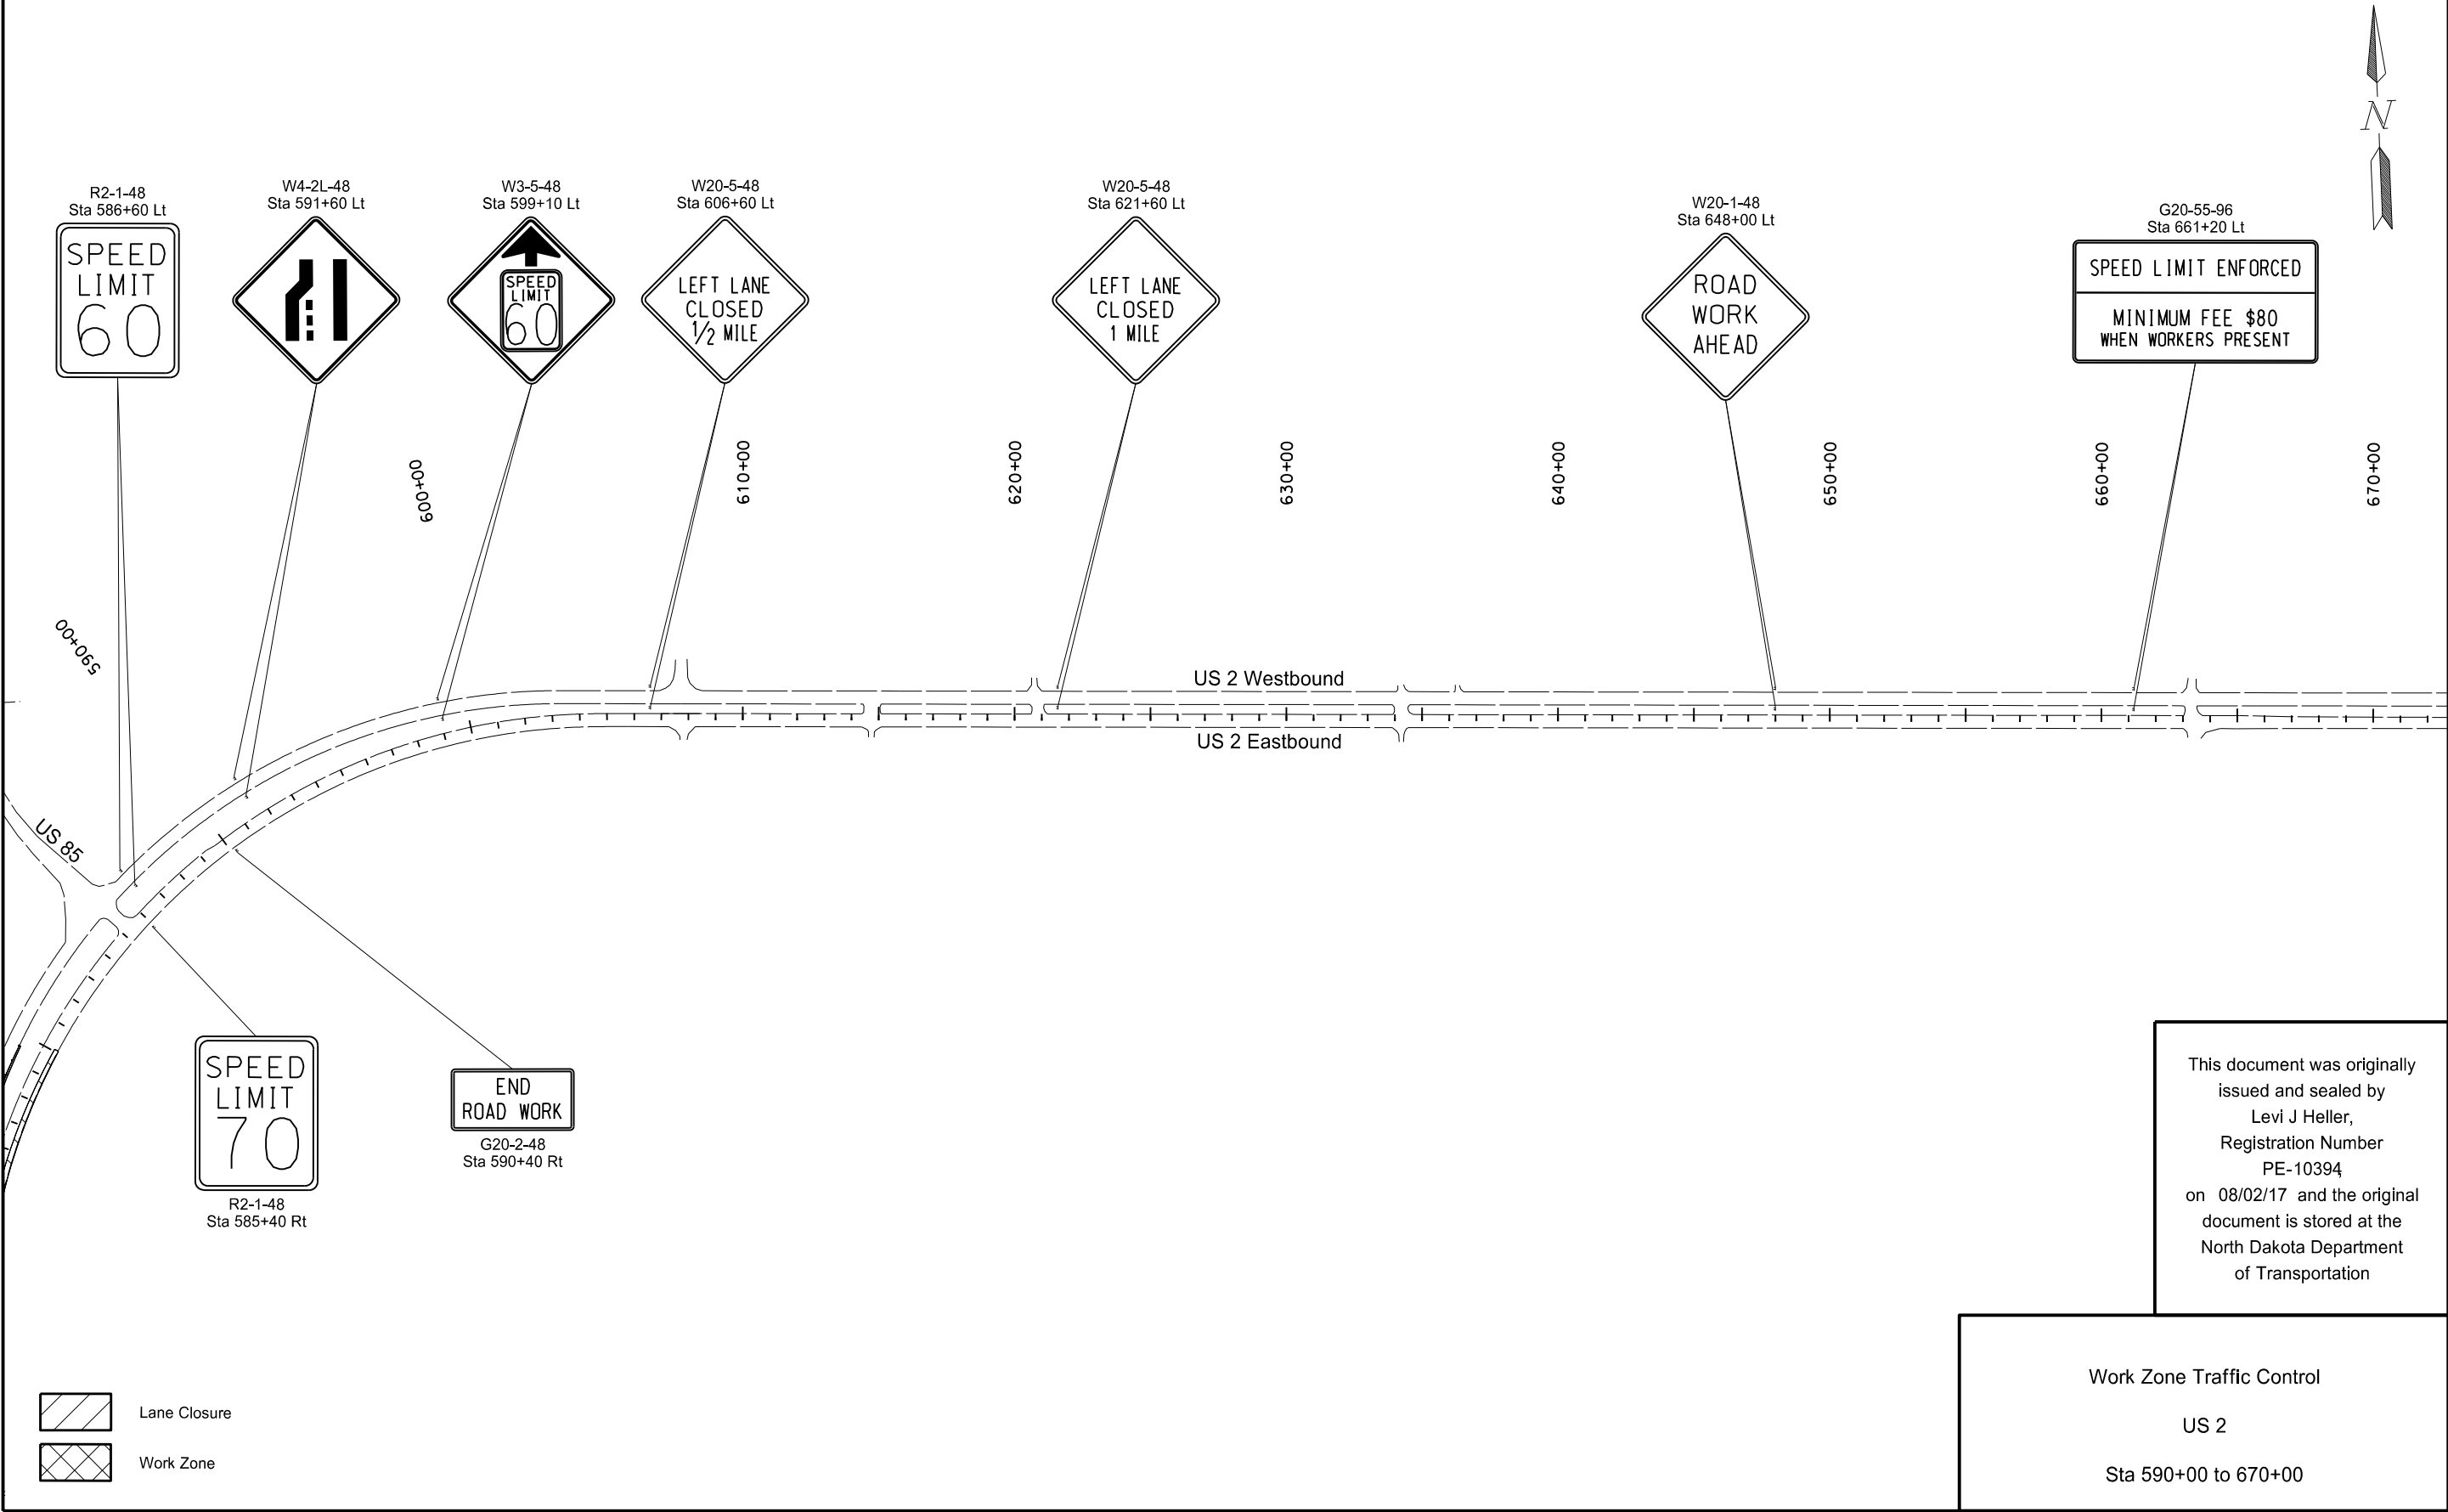

This document was originally issued and sealed by
Levi J Heller,
Registration Number
PE-10394
on 08/02/17 and the original document is stored at the
North Dakota Department
of Transportation

Work Zone Traffic Control
US 2
Sta 590+00 to 670+00

STATE	PROJECT NO.	SECTION NO.	SHEET NO.
ND	NH-NHU-7-002(156)022	100	9

 

R2-1-48
Sta 41+85 Lt & Rt



W20-1-48
Sta 42+00 Lt



Sequencing Arrow
Panel Type C
Sta 43+25 Rt



30+00

Frontage Rd W

35+00

US 2 Westbound

US 2 Eastbound

40+00

Frontage Rd E

Delineator Drum 13' Spacing (Typ.)

Delineator Drum 5' Spacing (Typ.)

Delineator Drum 40' Spacing (Typ.)

SPEED LIMIT ENFORCED

MINIMUM FEE \$80
WHEN WORKERS PRESENT

G20-55-96
Sta 30+00 Lt & Rt

ROAD
WORK
AHEAD

W20-1-48
Sta 34+50 Lt & Rt

RIGHT LANE
CLOSED
AHEAD

W20-5-48
Sta 38+00 Lt & Rt

W4-2R-48
Sta 40+45 Lt & Rt

Note:

Refer to Section 100 Sheet 2 and
Standard Drawing D-704-39 for temporary
pavement marking and obliteration details

This document was originally
issued and sealed by
Levi J Heller,
Registration Number
PE-10394
on 08/02/17 and the original
document is stored at the
North Dakota Department
of Transportation

Work Zone Traffic Control

US 2

Sta 30+00 to 44+00




Lane Closure



Work Zone

STATE	PROJECT NO.	SECTION NO.	SHEET NO.
ND	NH-NHU-7-002(156)022	100	10

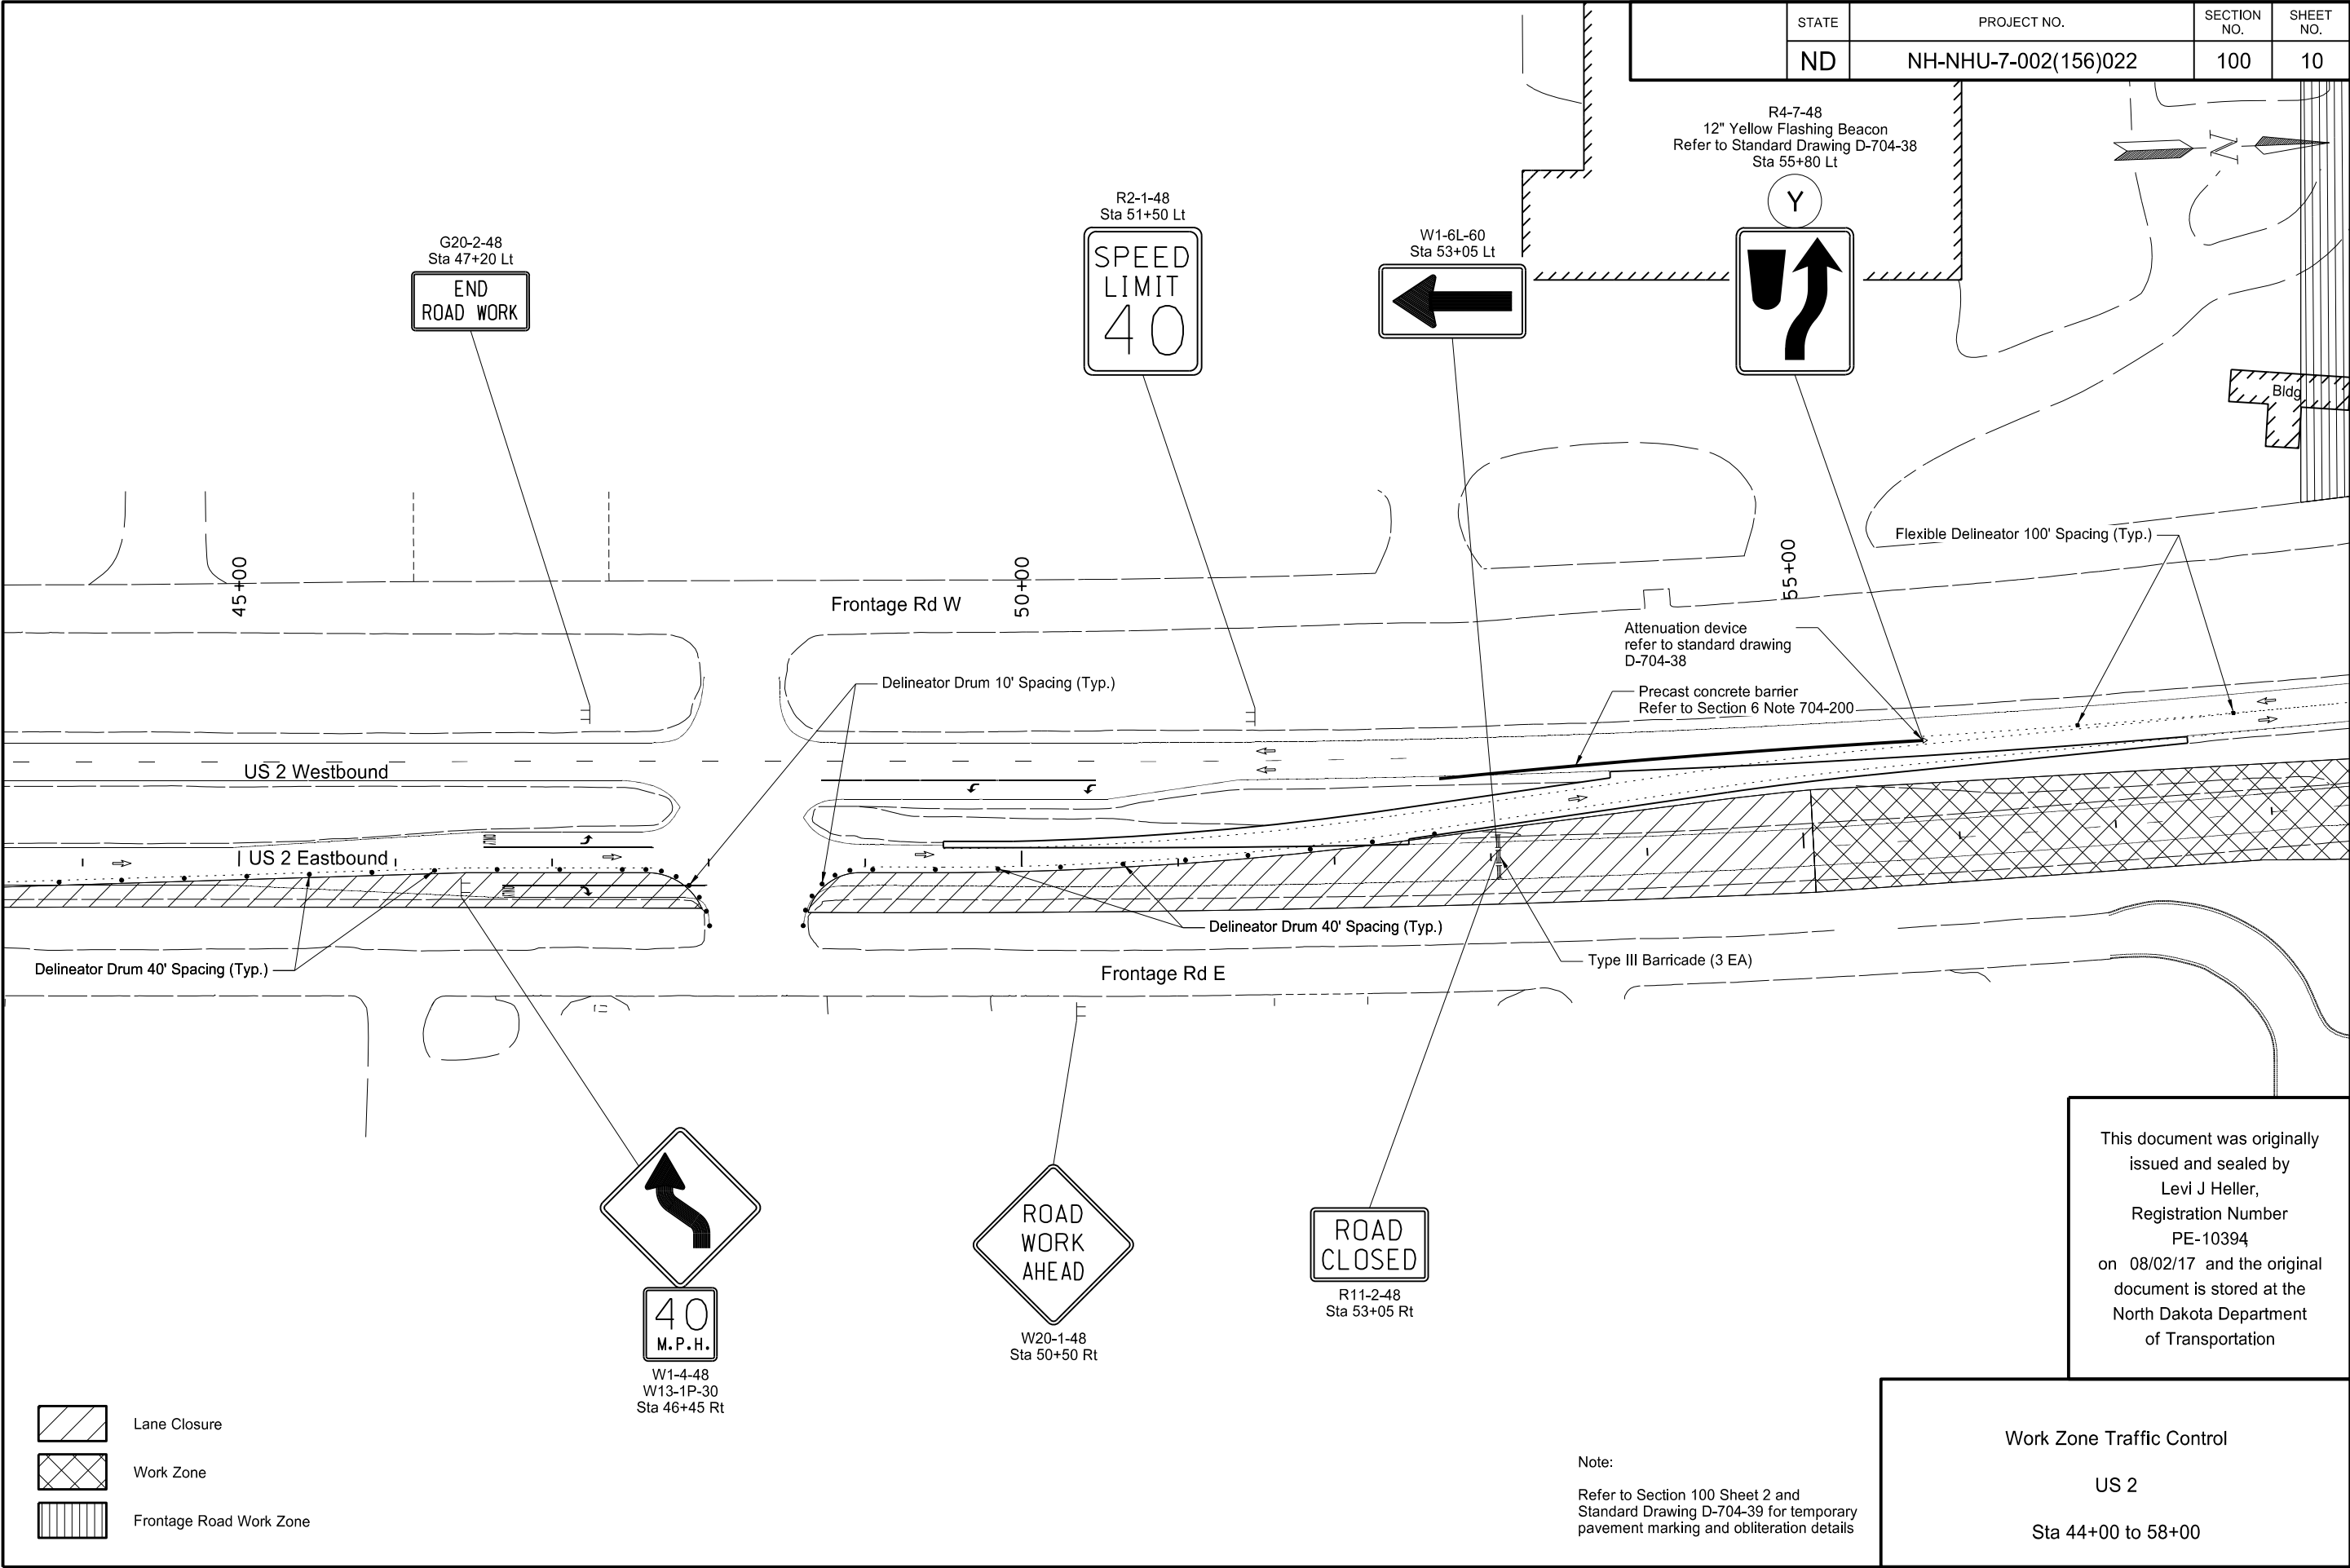

This document was originally issued and sealed by
Levi J Heller,
Registration Number
PE-10394
on 08/02/17 and the original document is stored at the
North Dakota Department
of Transportation


Work Zone Traffic Control

US 2


Sta 44+00 to 58+00

Note:
Refer to Section 100 Sheet 2 and
Standard Drawing D-704-39 for temporary
pavement marking and obliteration details

STATE	PROJECT NO.	SECTION NO.	SHEET NO.
ND	NH-NHU-7002(156)022	100	11

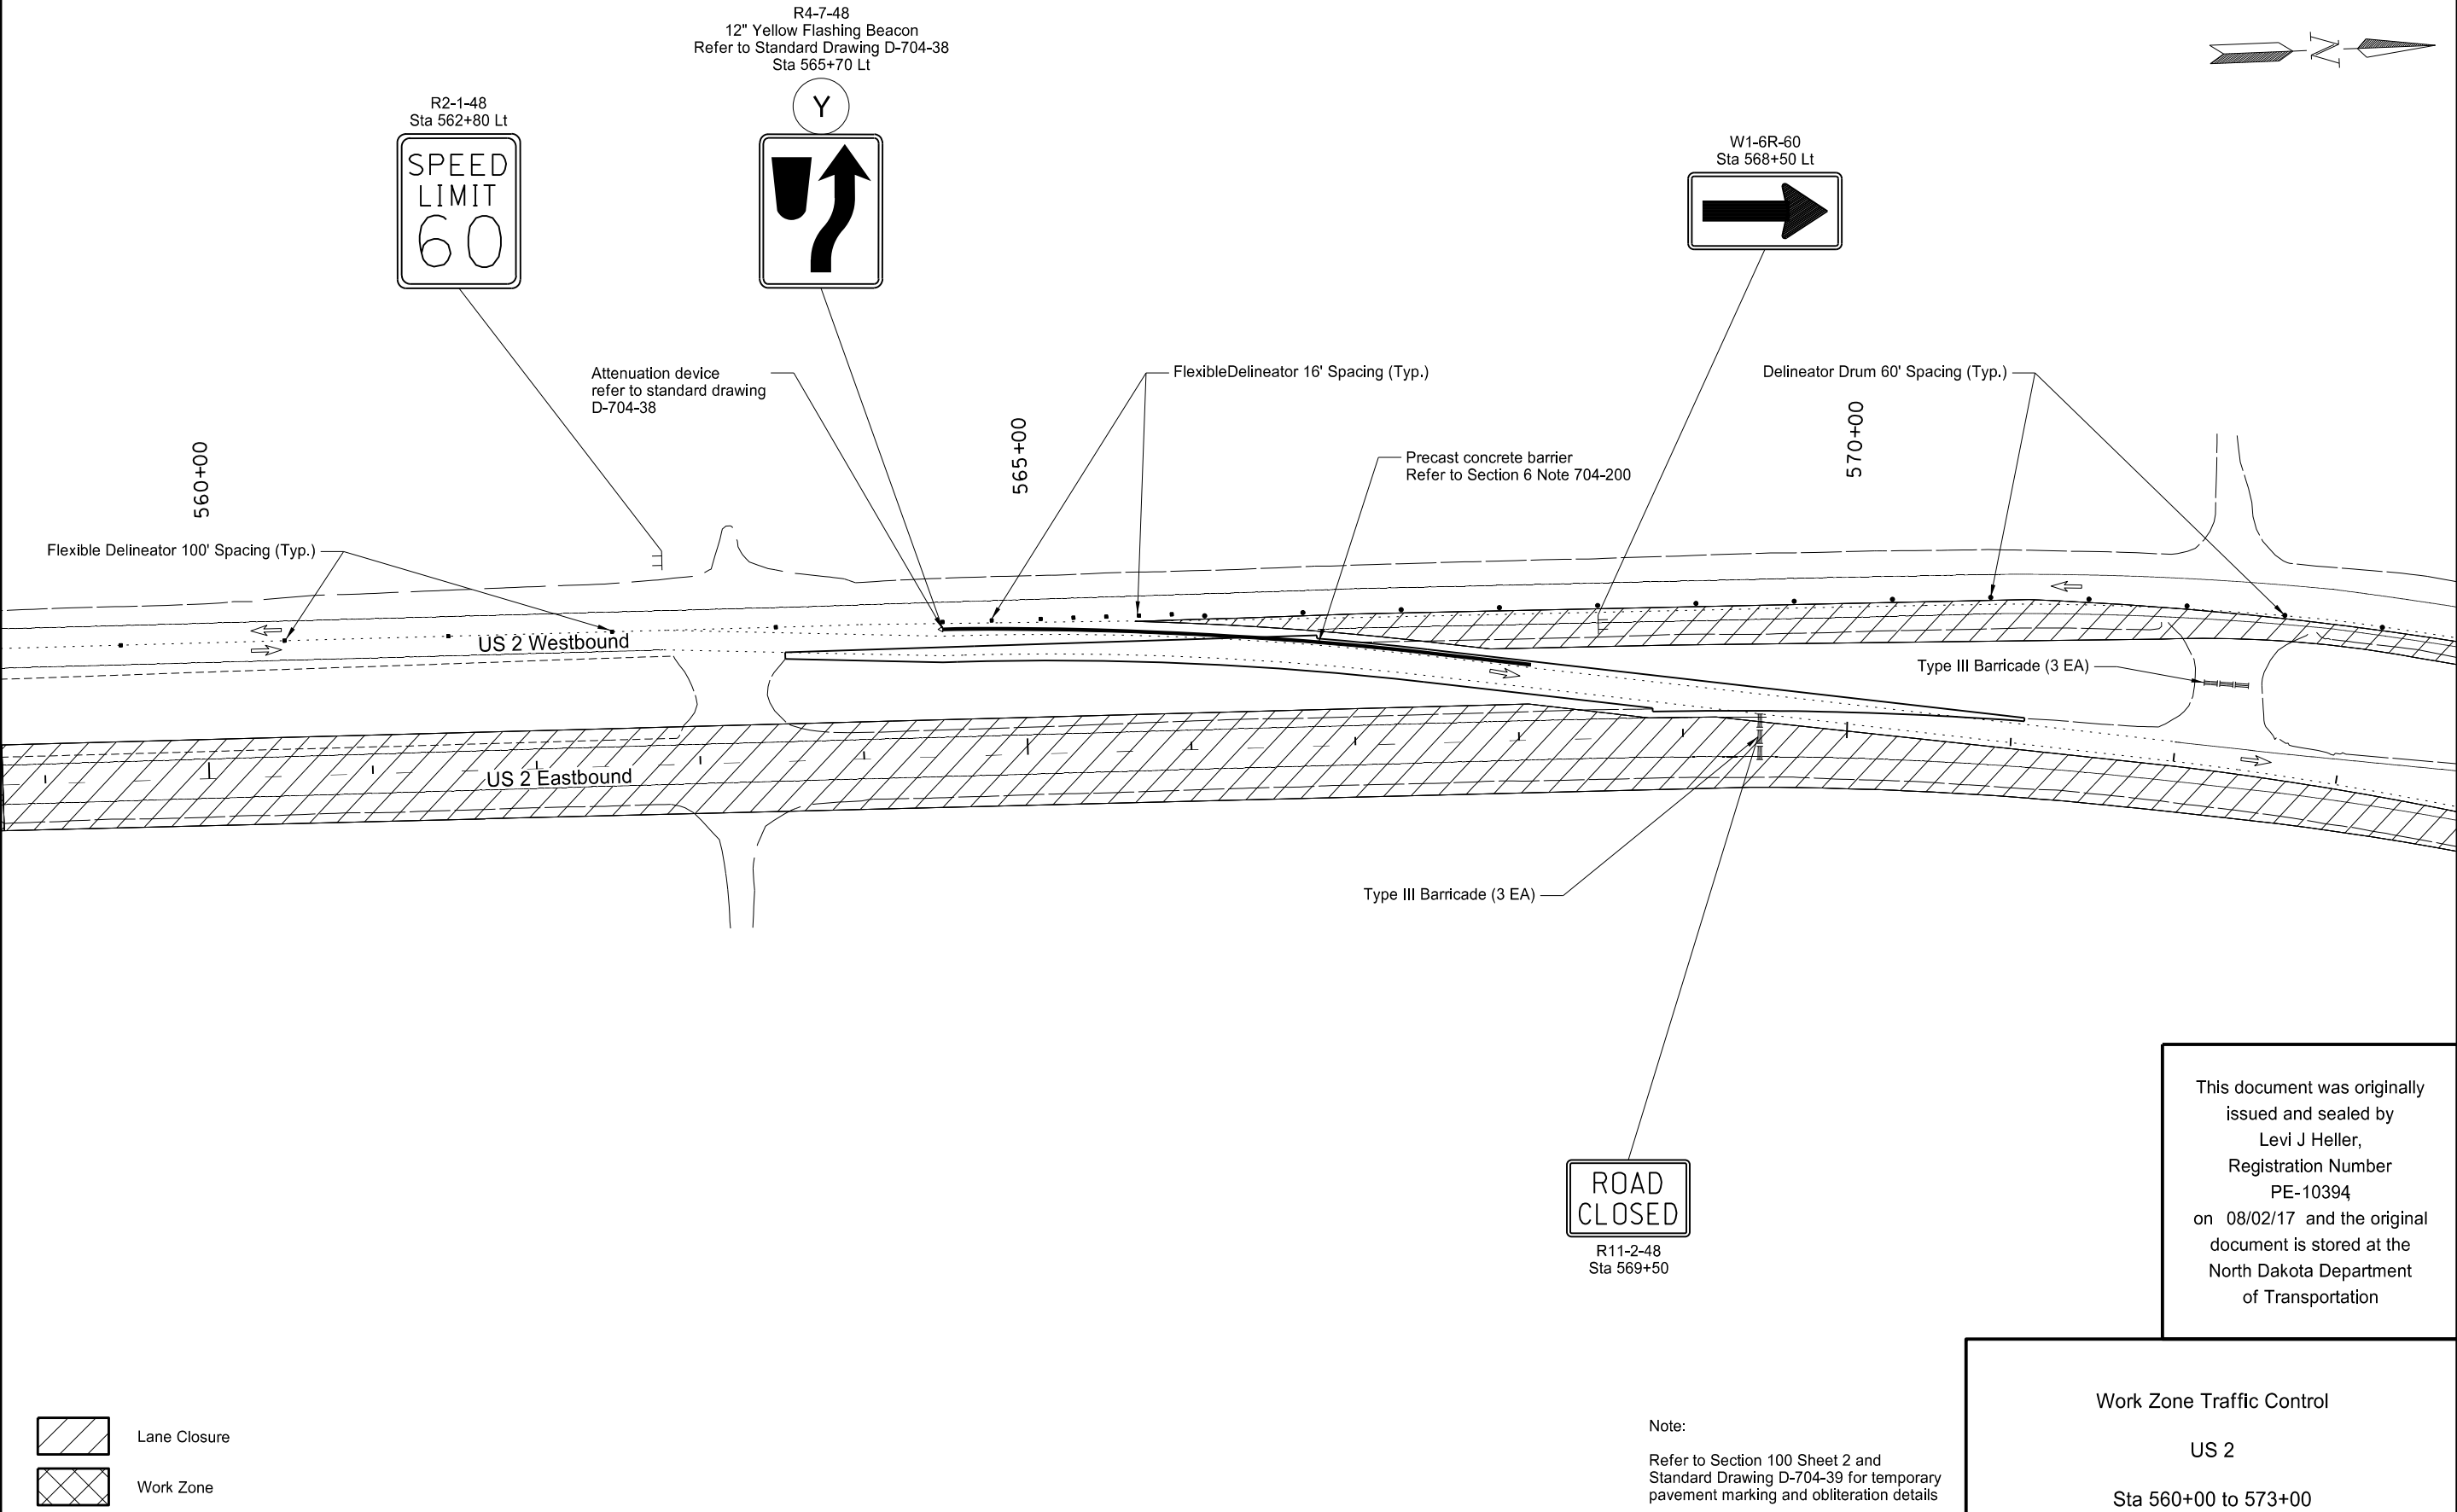

STATE	PROJECT NO.	SECTION NO.	SHEET NO.
ND	NH-NHU-7-002(156)022	100	12

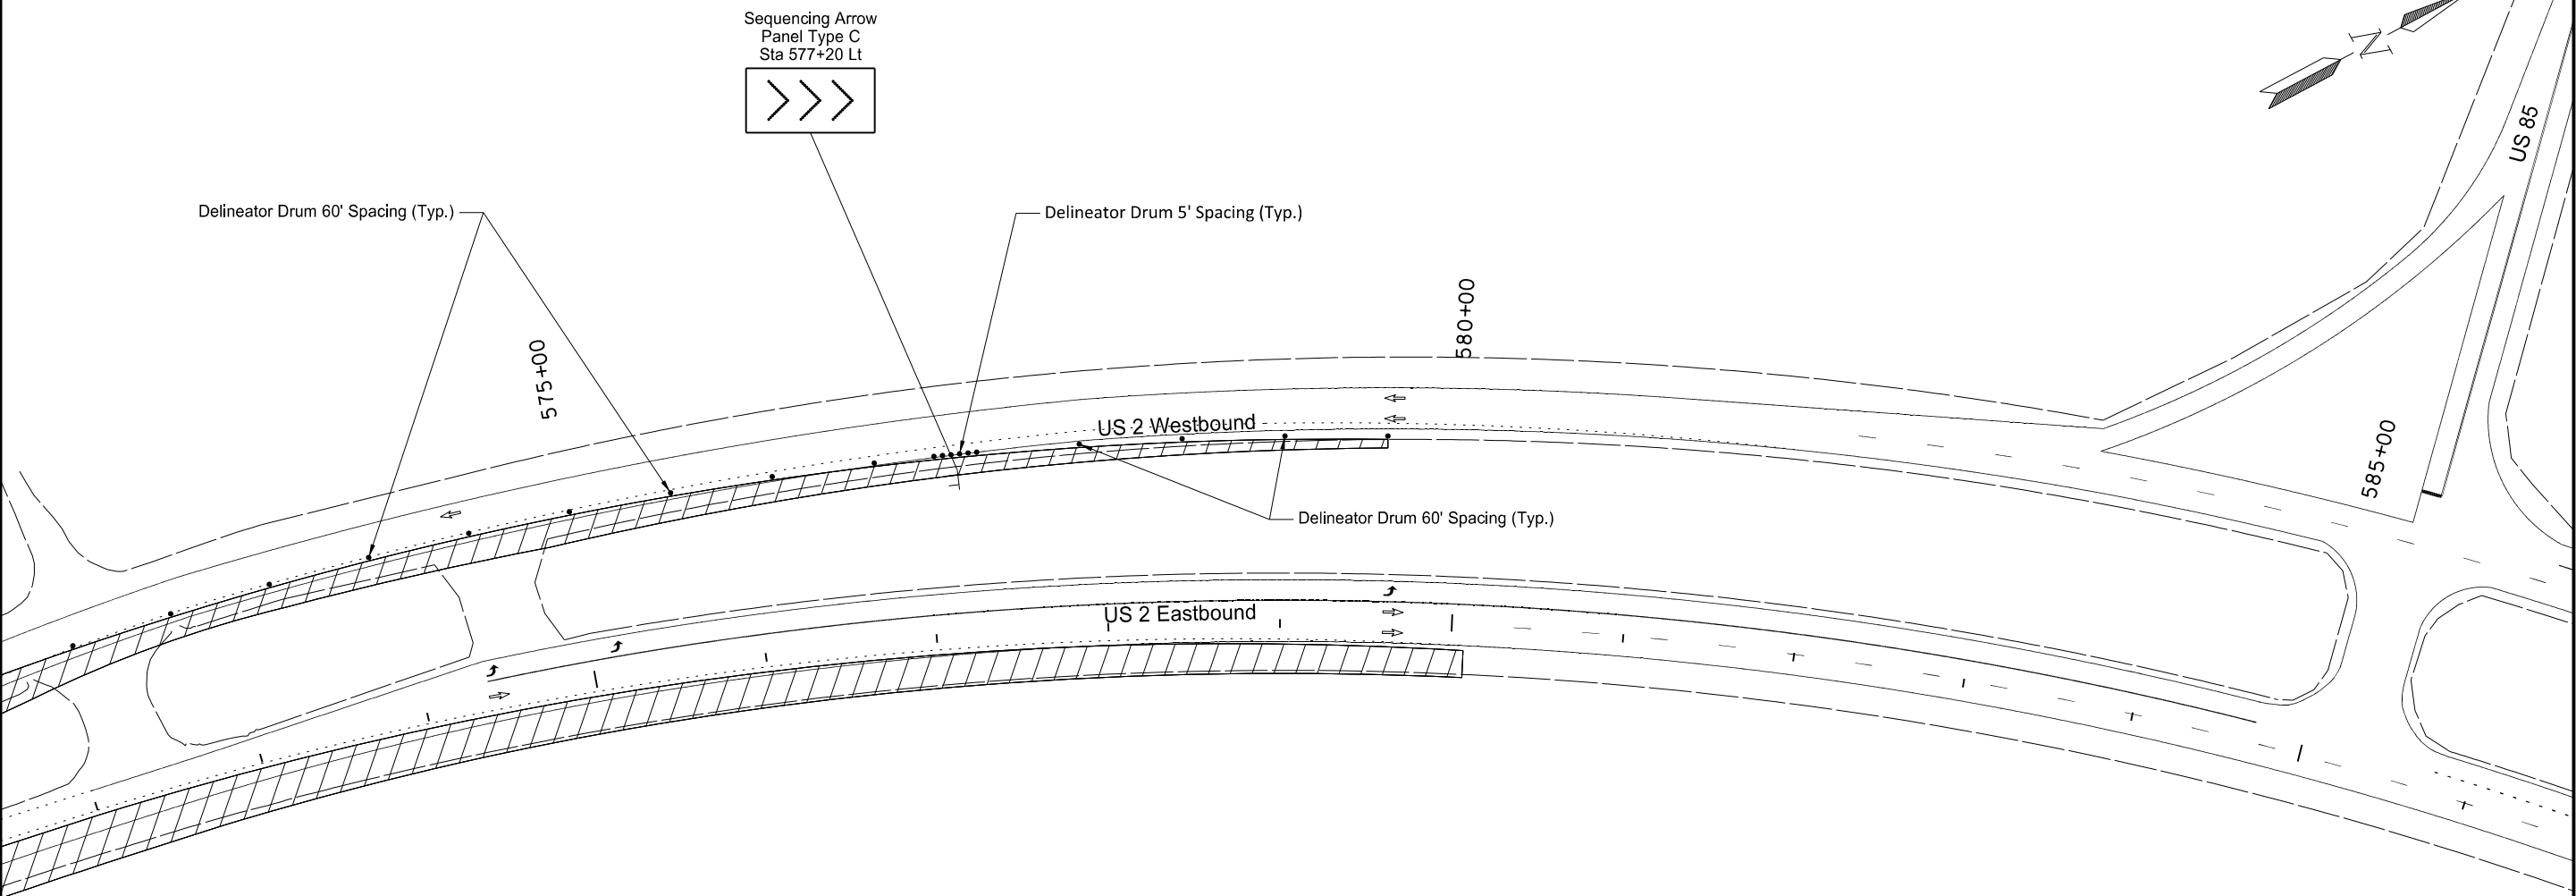

-  Lane Closure
-  Work Zone

Note:
Refer to Section 100 Sheet 2 and
Standard Drawing D-704-39 for temporary
pavement marking and obliteration details


This document was originally
issued and sealed by
Levi J Heller,
Registration Number
PE-10394
on 08/02/17 and the original
document is stored at the
North Dakota Department
of Transportation

Work Zone Traffic Control

US 2

Sta 573+00 to 585+00


	STATE	PROJECT NO.	SECTION NO.	SHEET NO.
	ND	NH-NHU-7-002(156)022	100	14

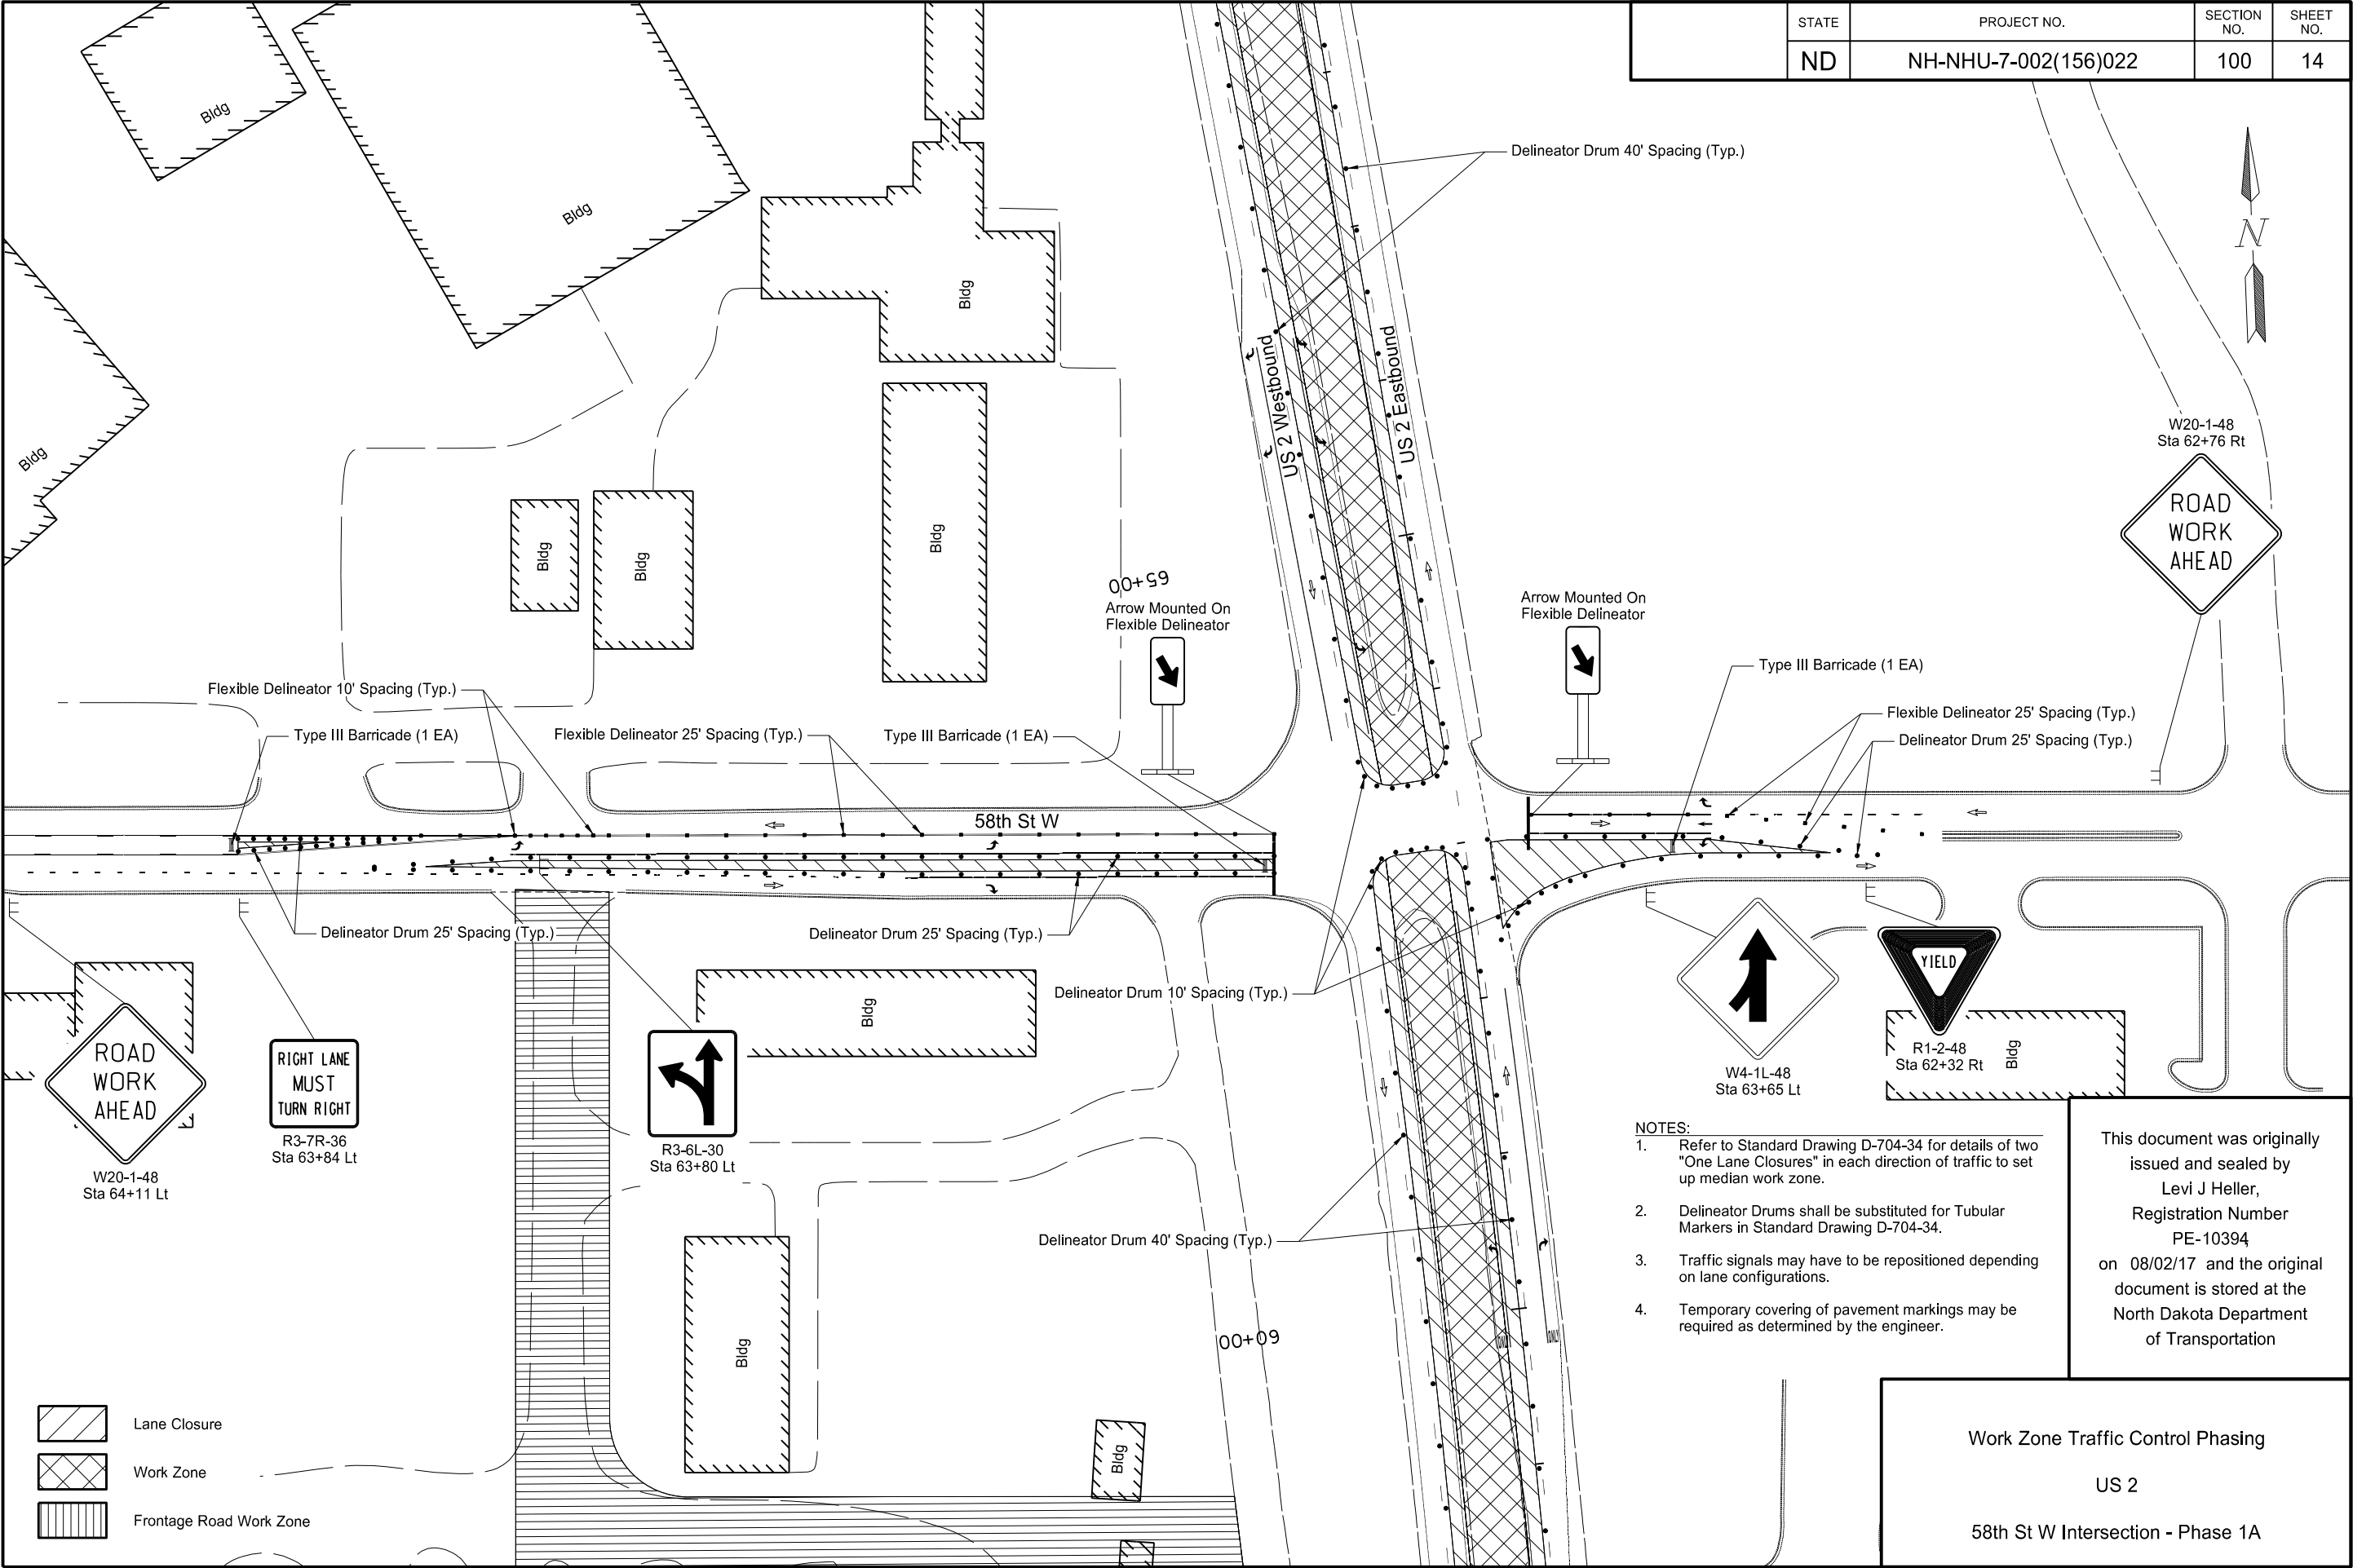

- NOTES:
1. Refer to Standard Drawing D-704-34 for details of two "One Lane Closures" in each direction of traffic to set up median work zone.
 2. Delineator Drums shall be substituted for Tubular Markers in Standard Drawing D-704-34.
 3. Traffic signals may have to be repositioned depending on lane configurations.
 4. Temporary covering of pavement markings may be required as determined by the engineer.

This document was originally issued and sealed by
Levi J Heller,
Registration Number
PE-10394
on 08/02/17 and the original document is stored at the
North Dakota Department
of Transportation

Work Zone Traffic Control Phasing
US 2
58th St W Intersection - Phase 1A

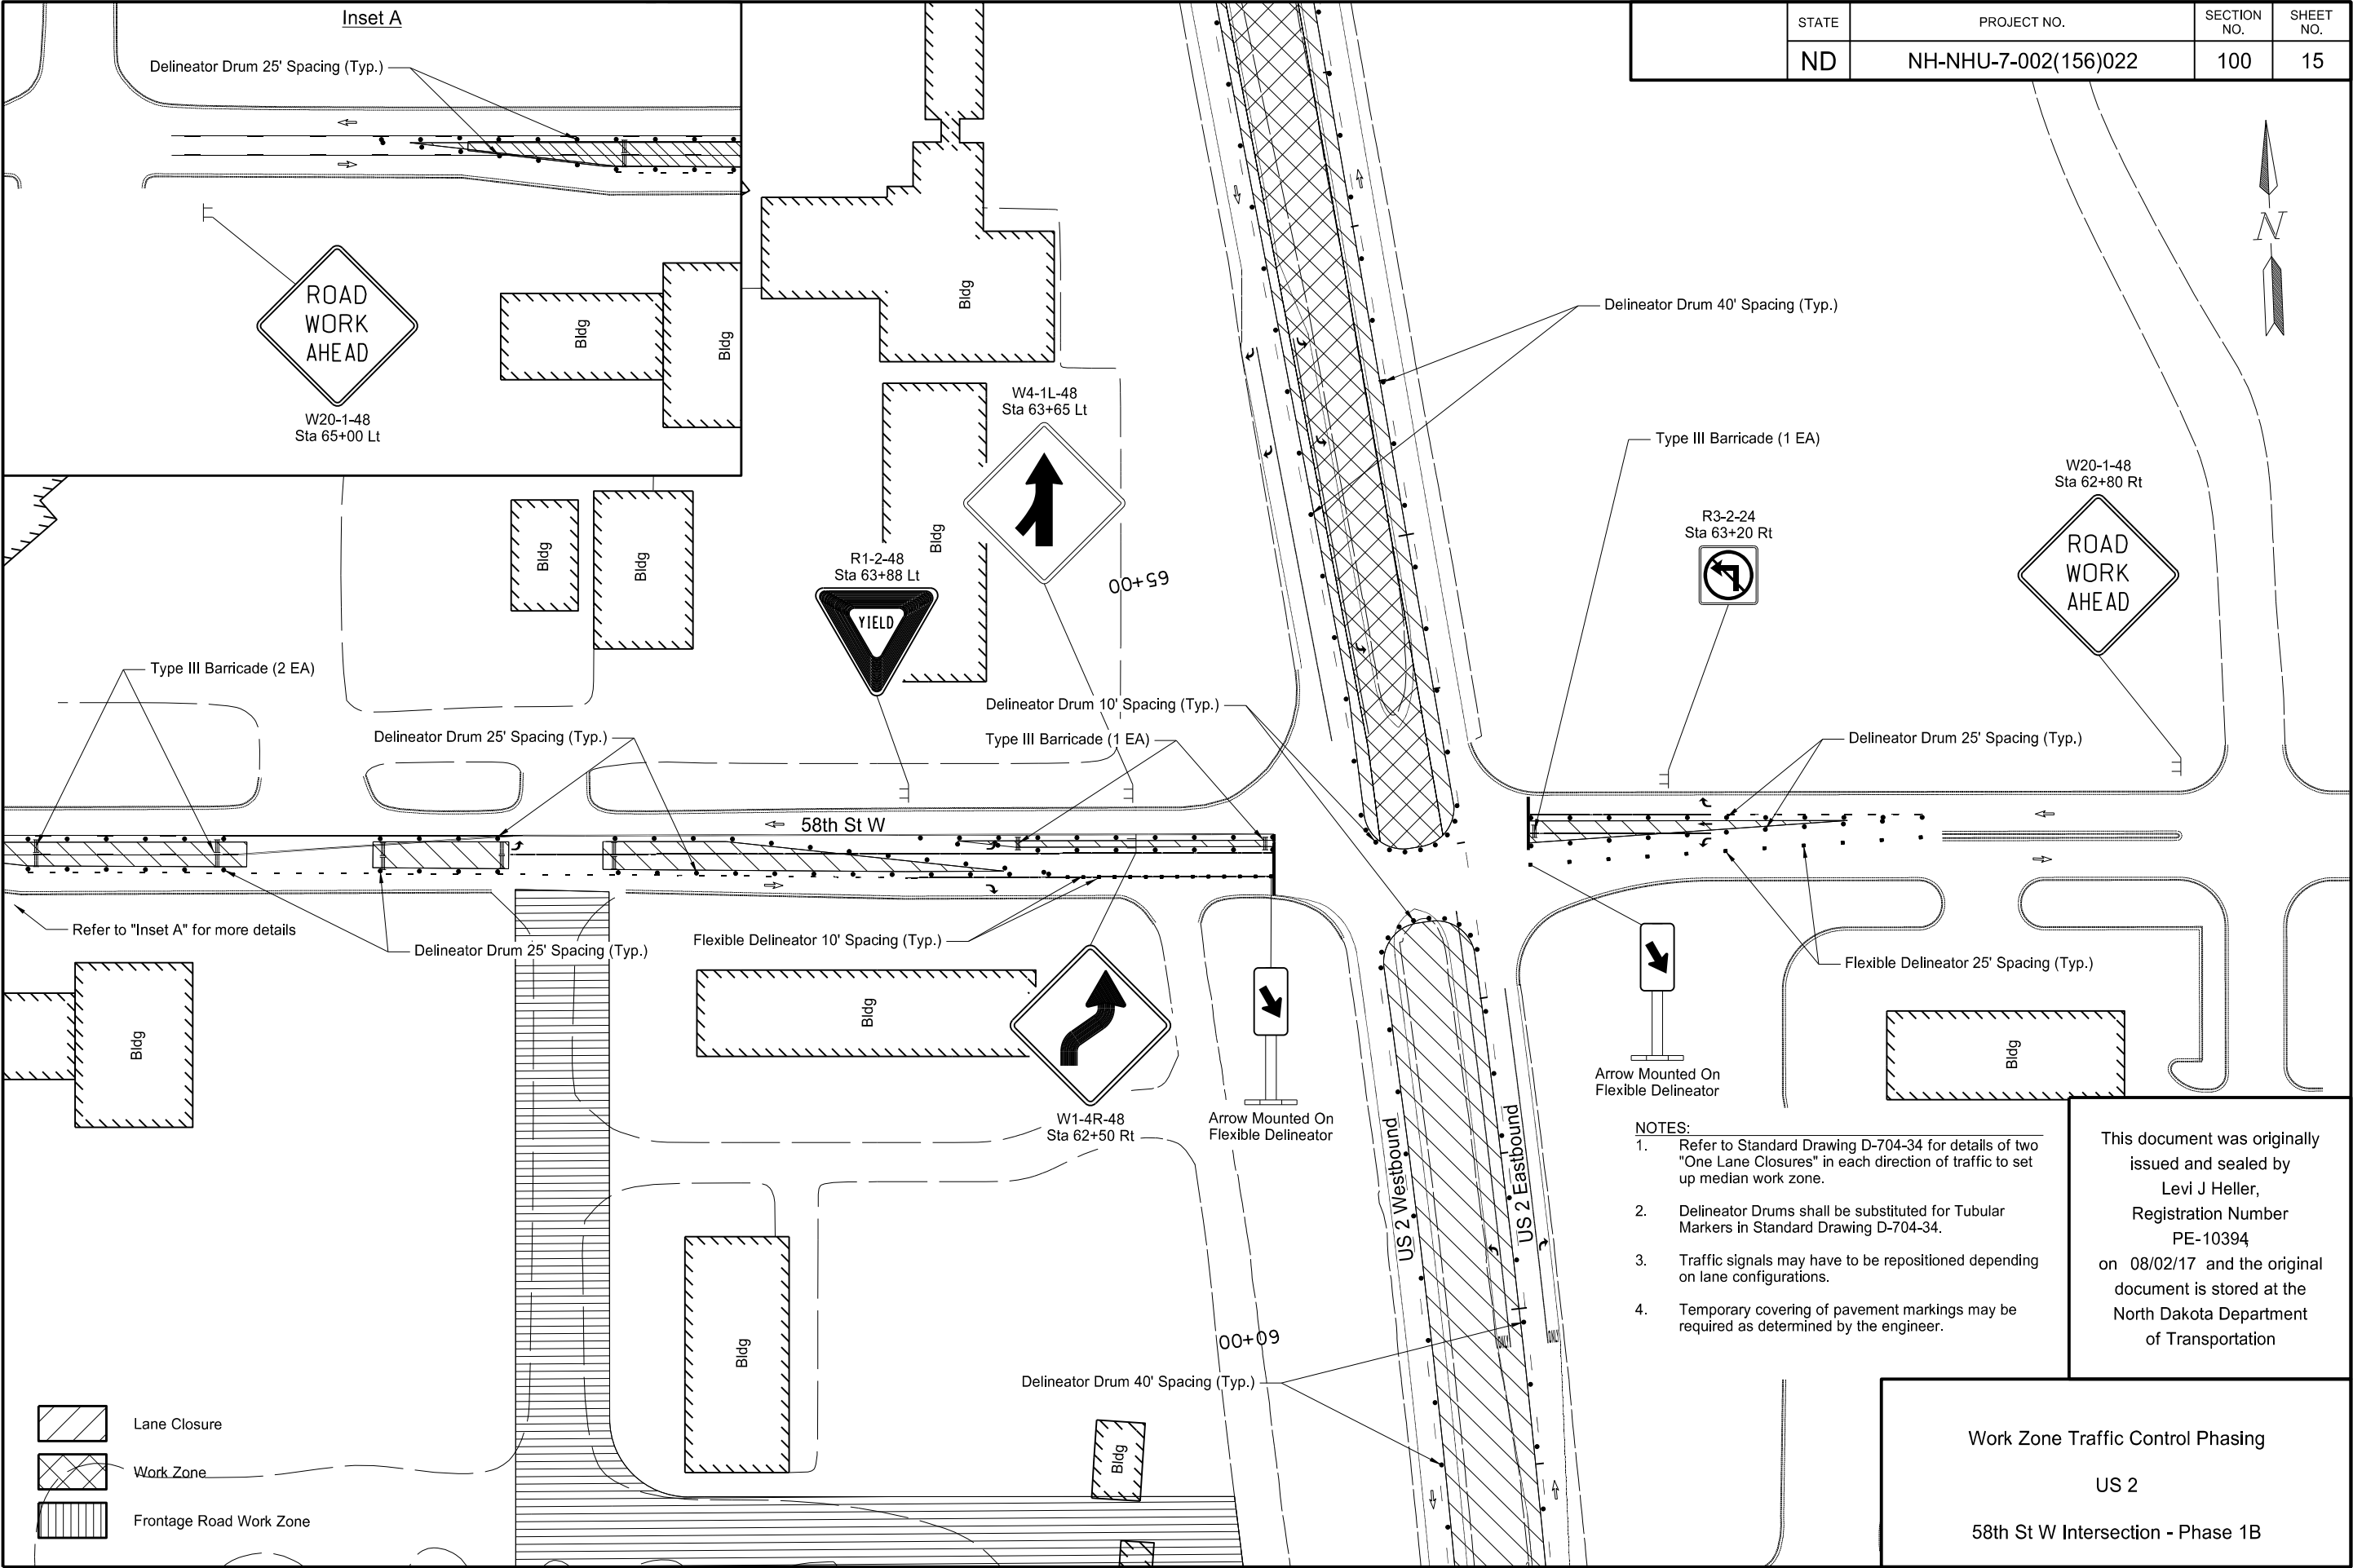


	STATE	PROJECT NO.	SECTION NO.	SHEET NO.
	ND	NH-NHU-7-002(156)022	100	15


- NOTES:
1. Refer to Standard Drawing D-704-34 for details of two "One Lane Closures" in each direction of traffic to set up median work zone.
 2. Delineator Drums shall be substituted for Tubular Markers in Standard Drawing D-704-34.
 3. Traffic signals may have to be repositioned depending on lane configurations.
 4. Temporary covering of pavement markings may be required as determined by the engineer.

This document was originally issued and sealed by
Levi J Heller,
Registration Number
PE-10394
on 08/02/17 and the original document is stored at the
North Dakota Department
of Transportation

Work Zone Traffic Control Phasing
US 2
58th St W Intersection - Phase 1B




	STATE	PROJECT NO.	SECTION NO.	SHEET NO.
	ND	NH-NHU-7-002(156)022	100	16

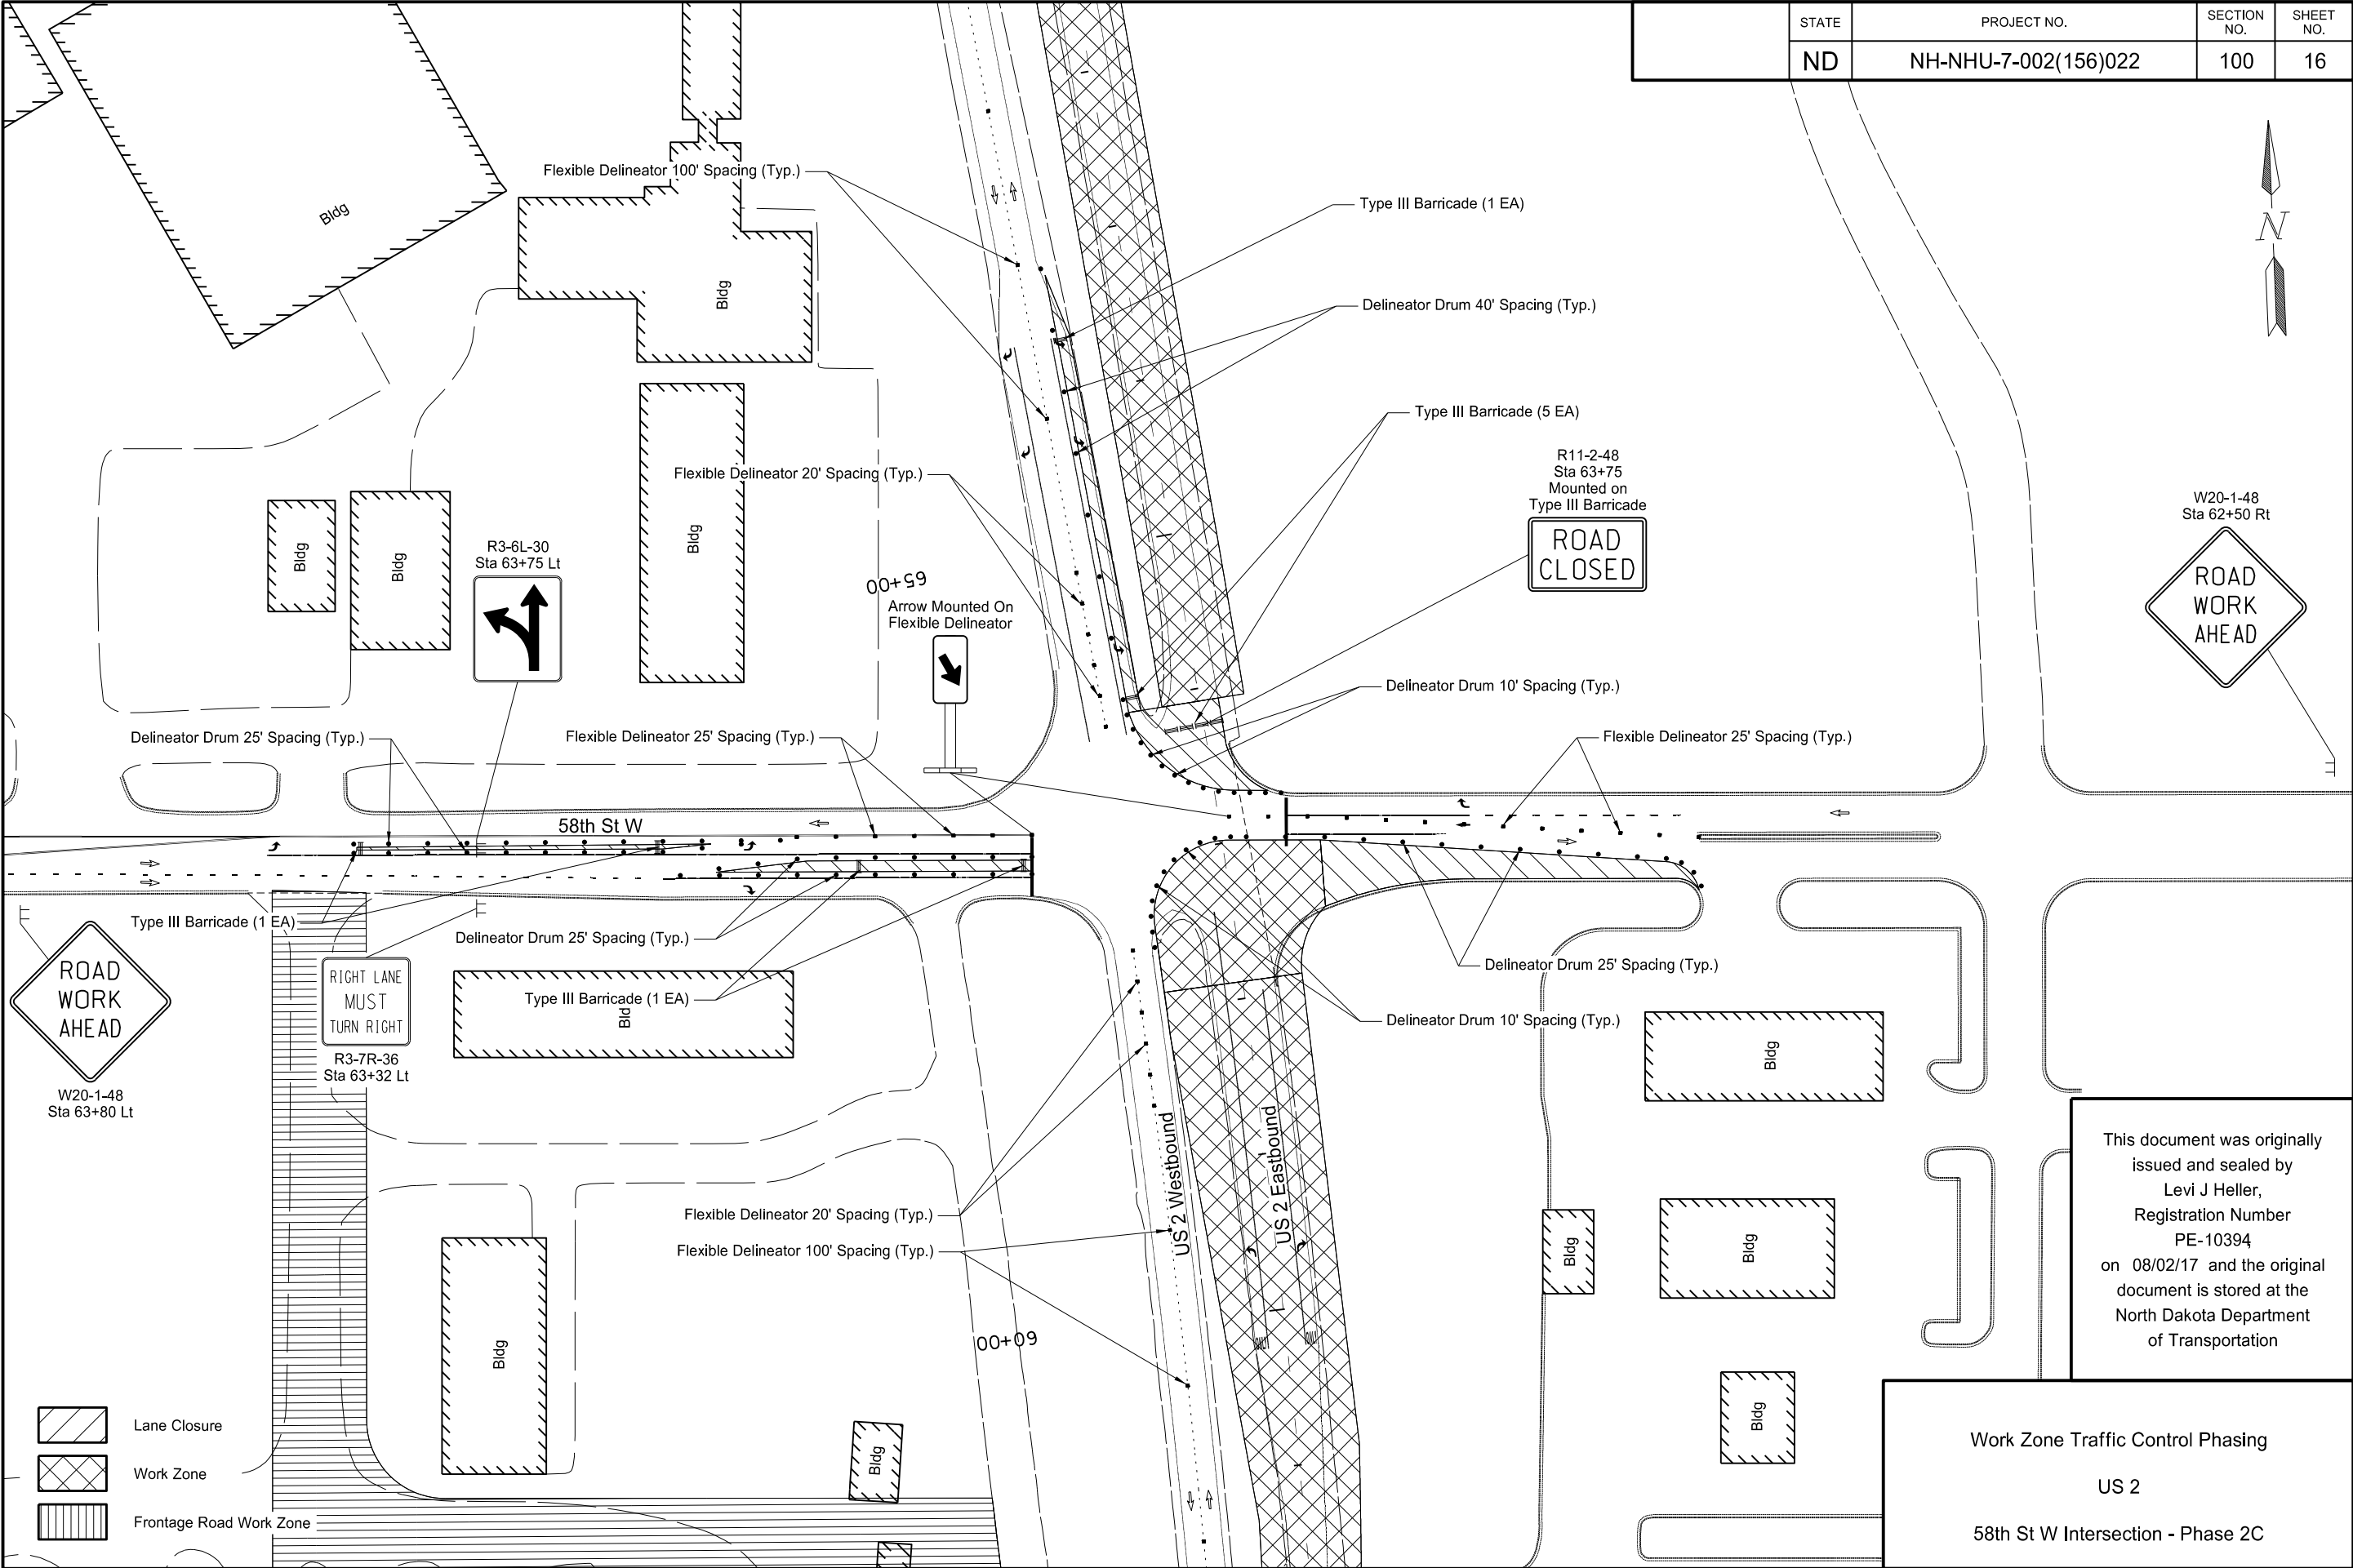

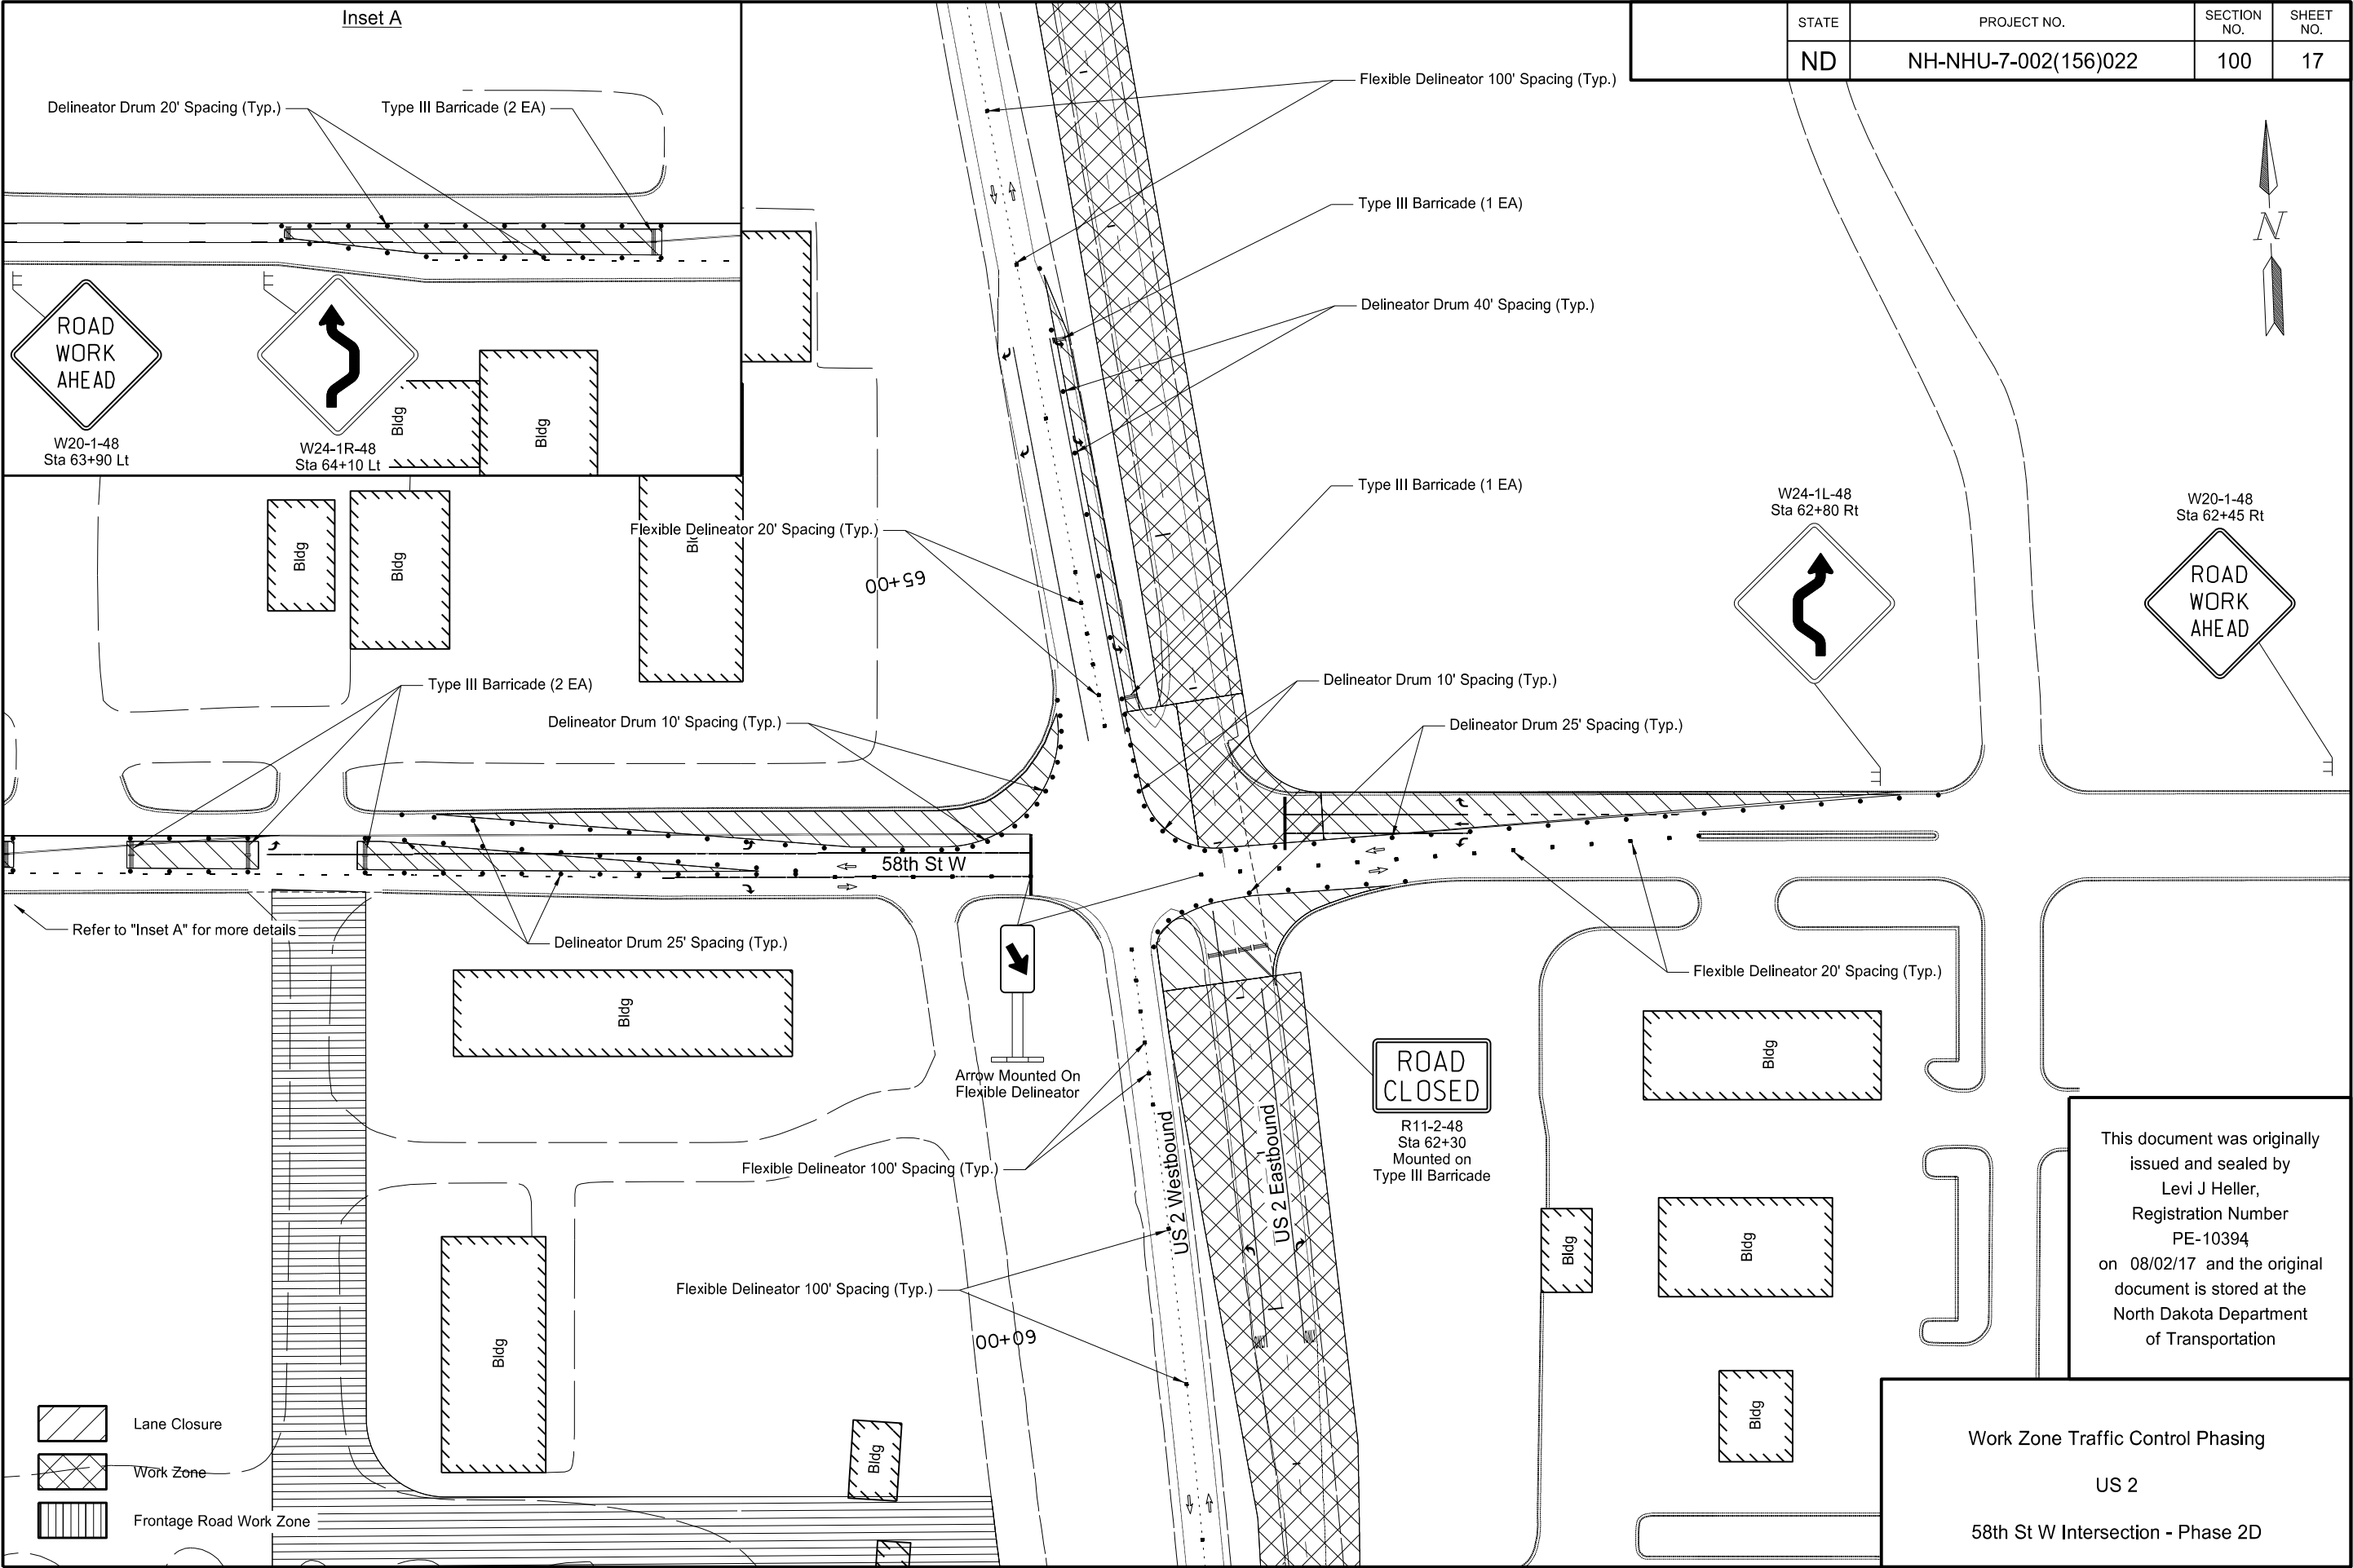


STATE	PROJECT NO.	SECTION NO.	SHEET NO.
ND	NH-NHU-7-002(156)022	100	17


Inset A

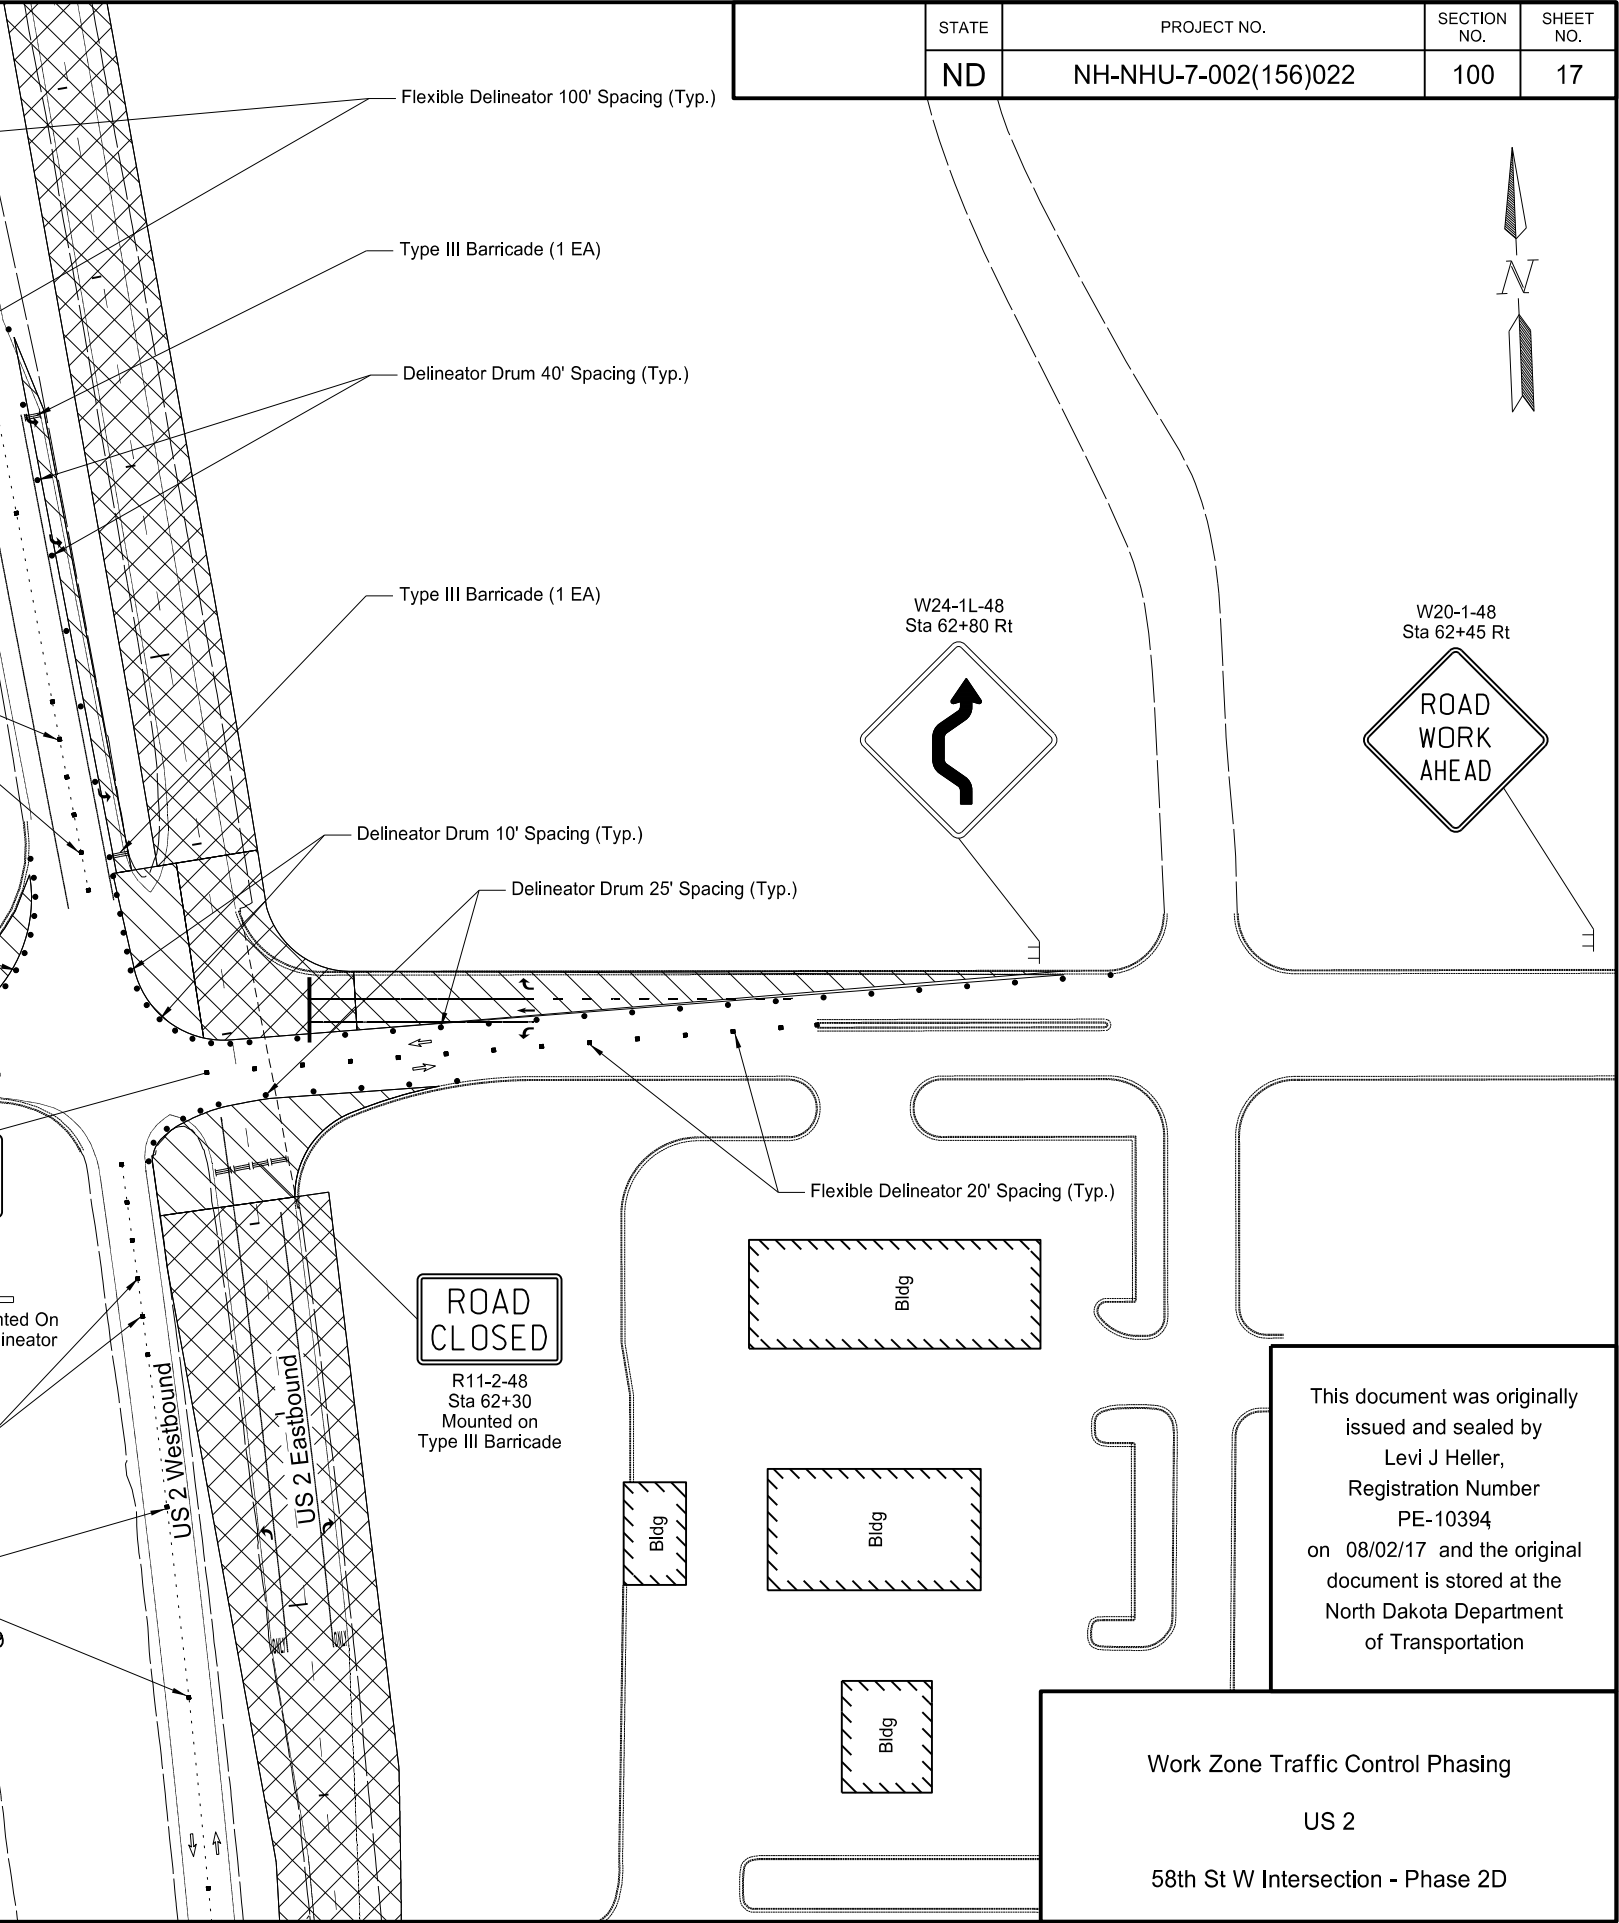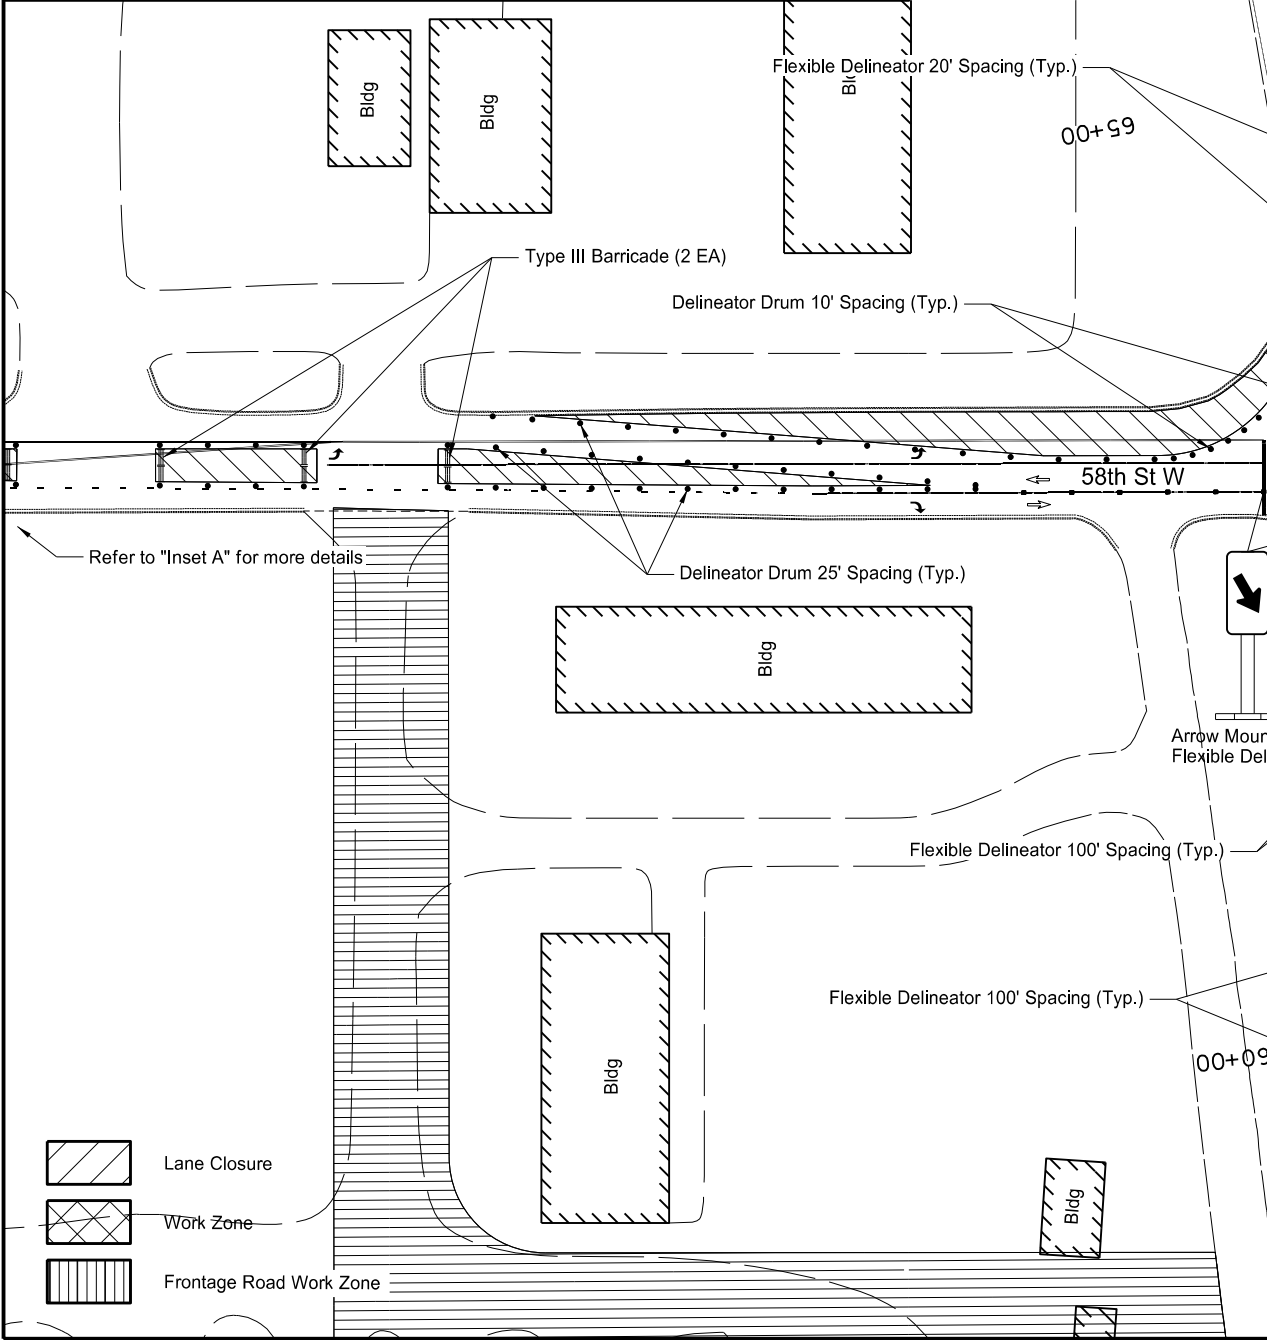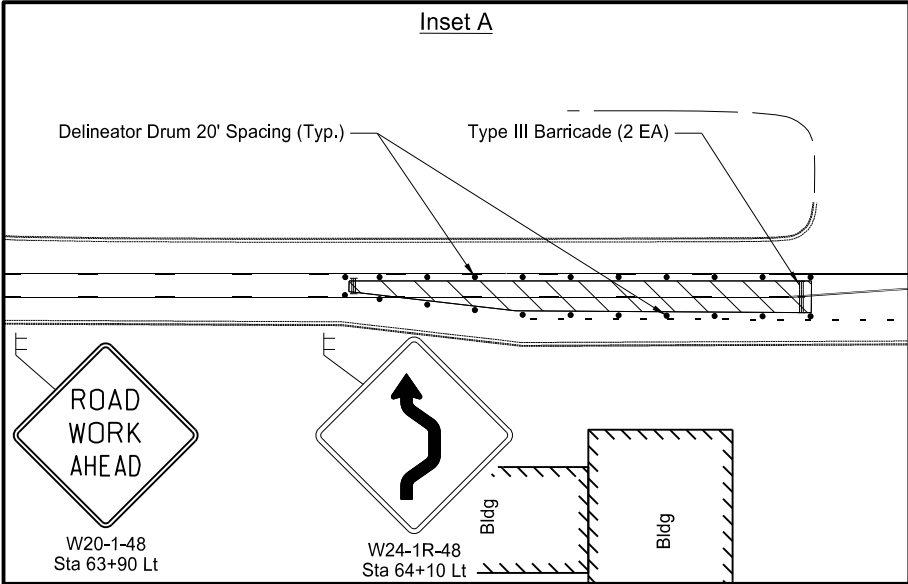



This document was originally issued and sealed by
Levi J Heller,
Registration Number
PE-10394
on 08/02/17 and the original document is stored at the
North Dakota Department
of Transportation

Work Zone Traffic Control Phasing
US 2
58th St W Intersection - Phase 2D

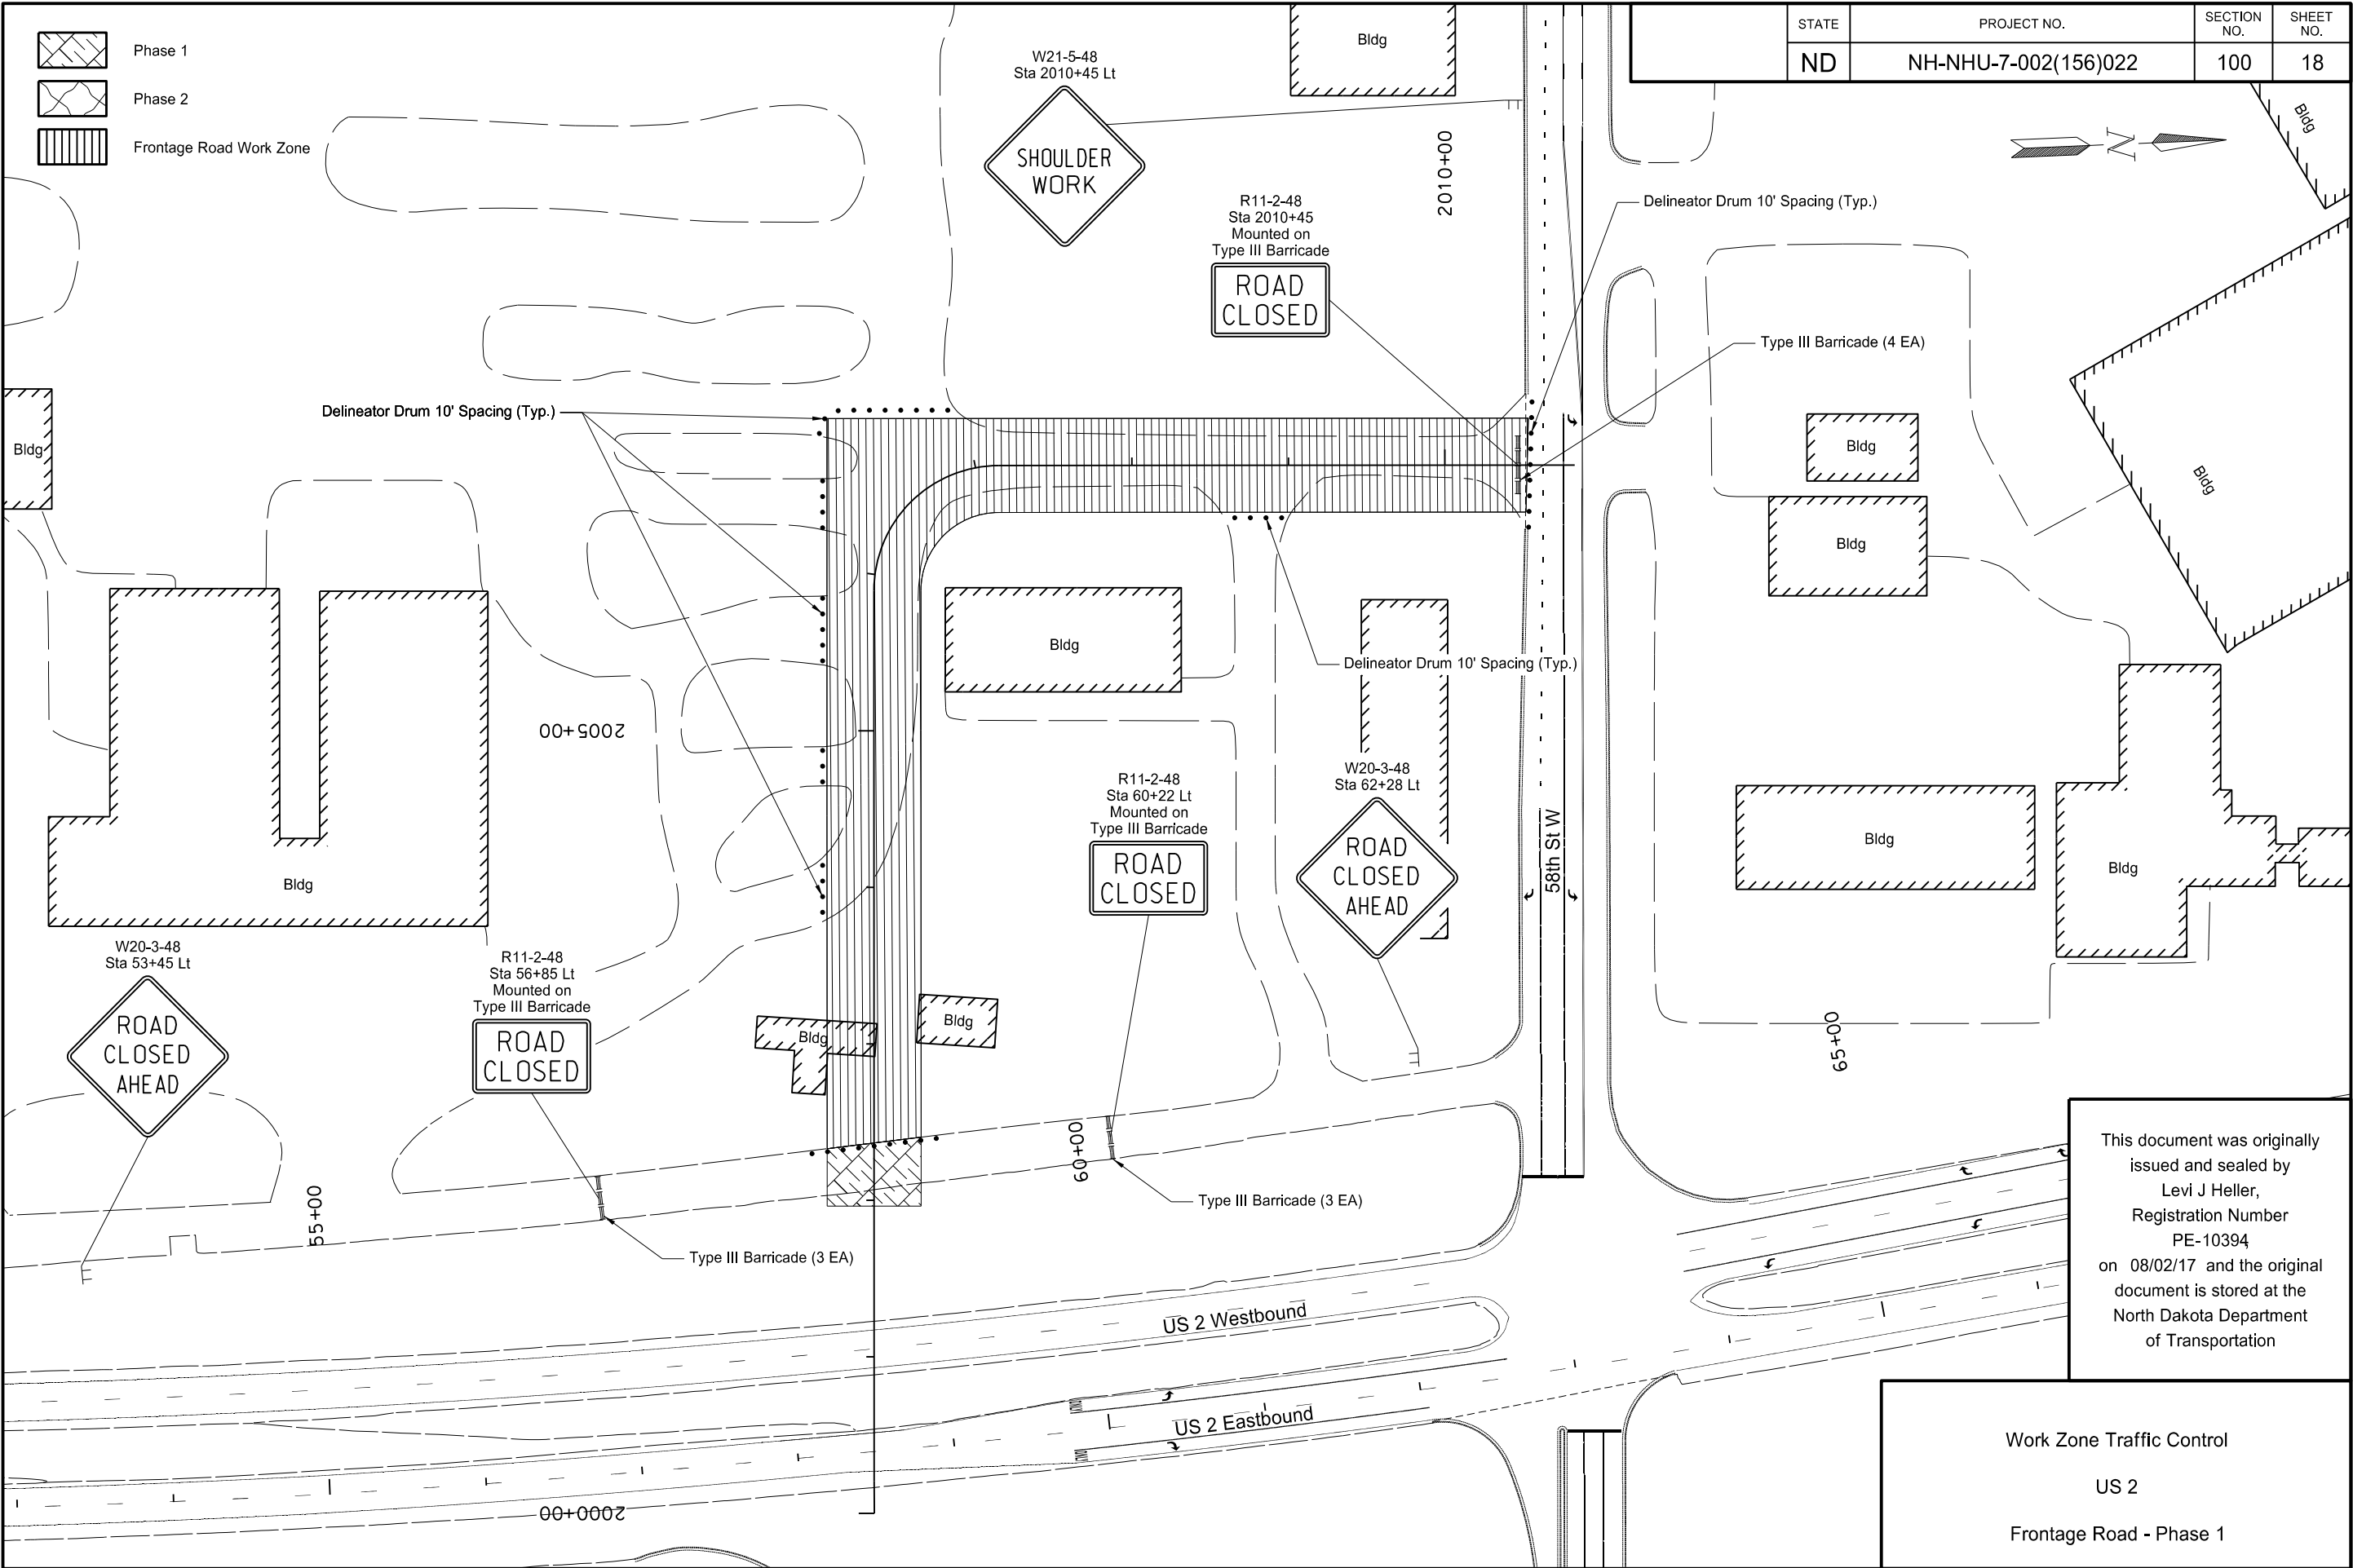

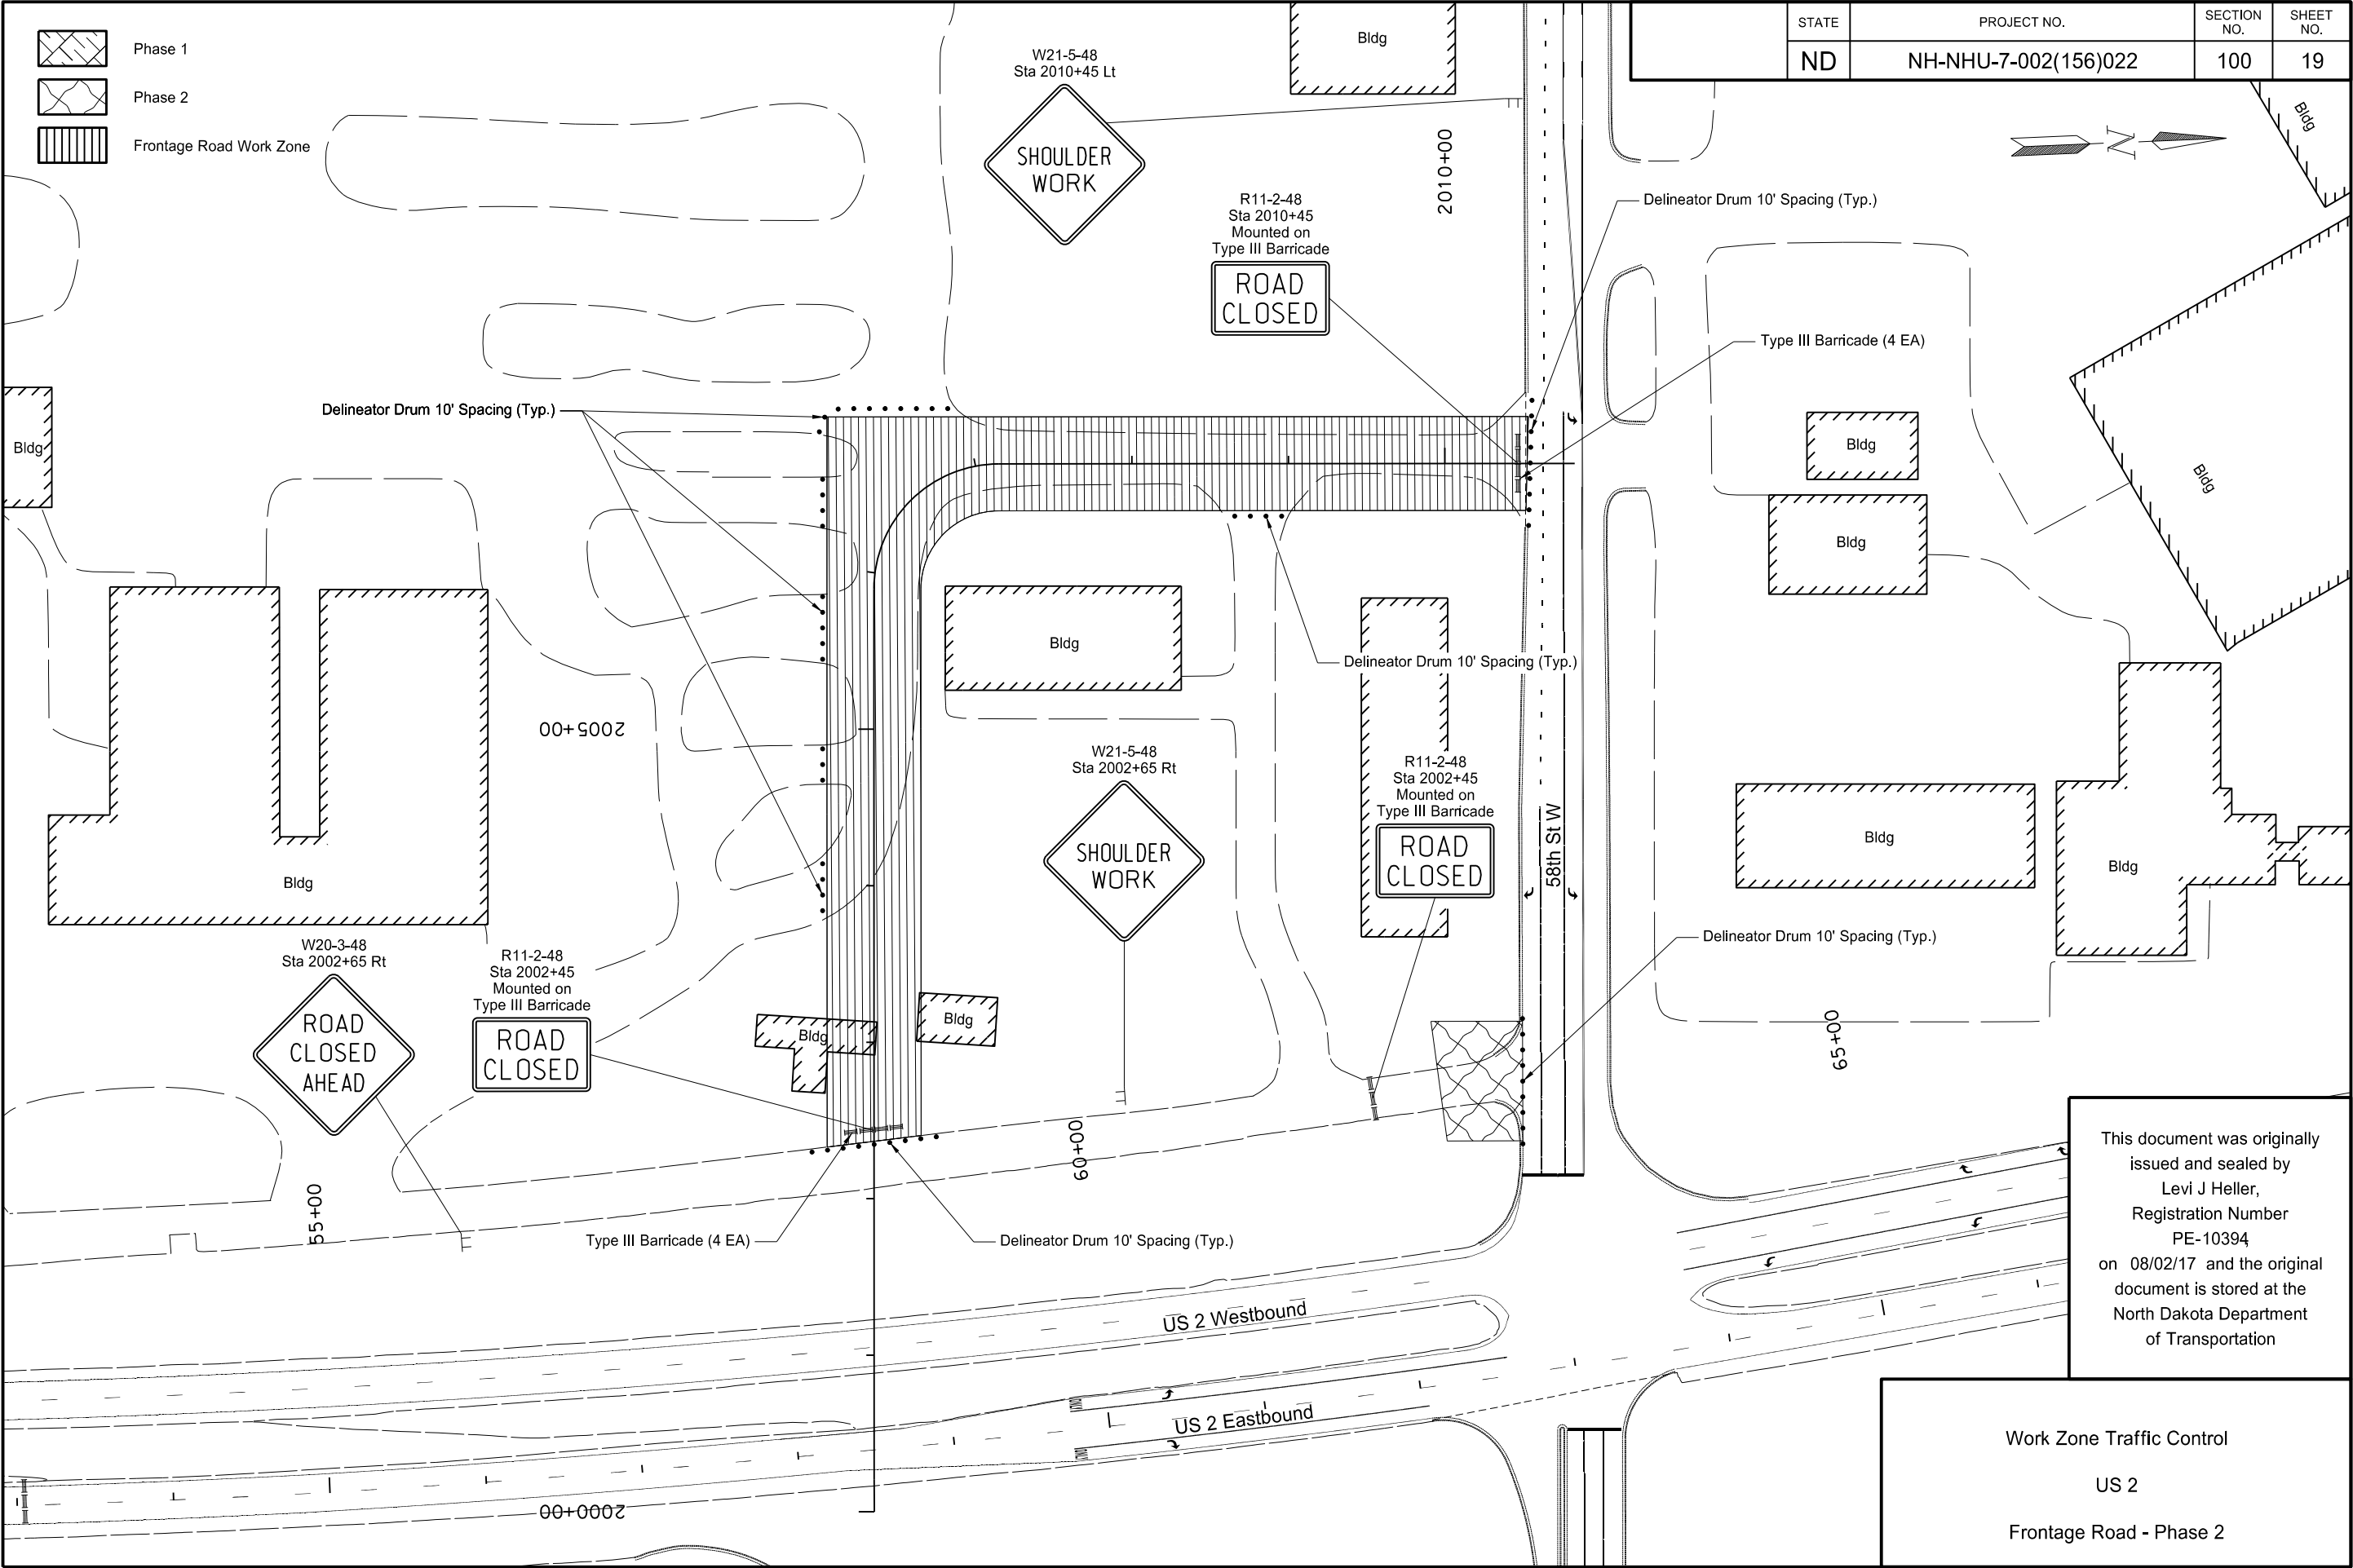


1" = 20'

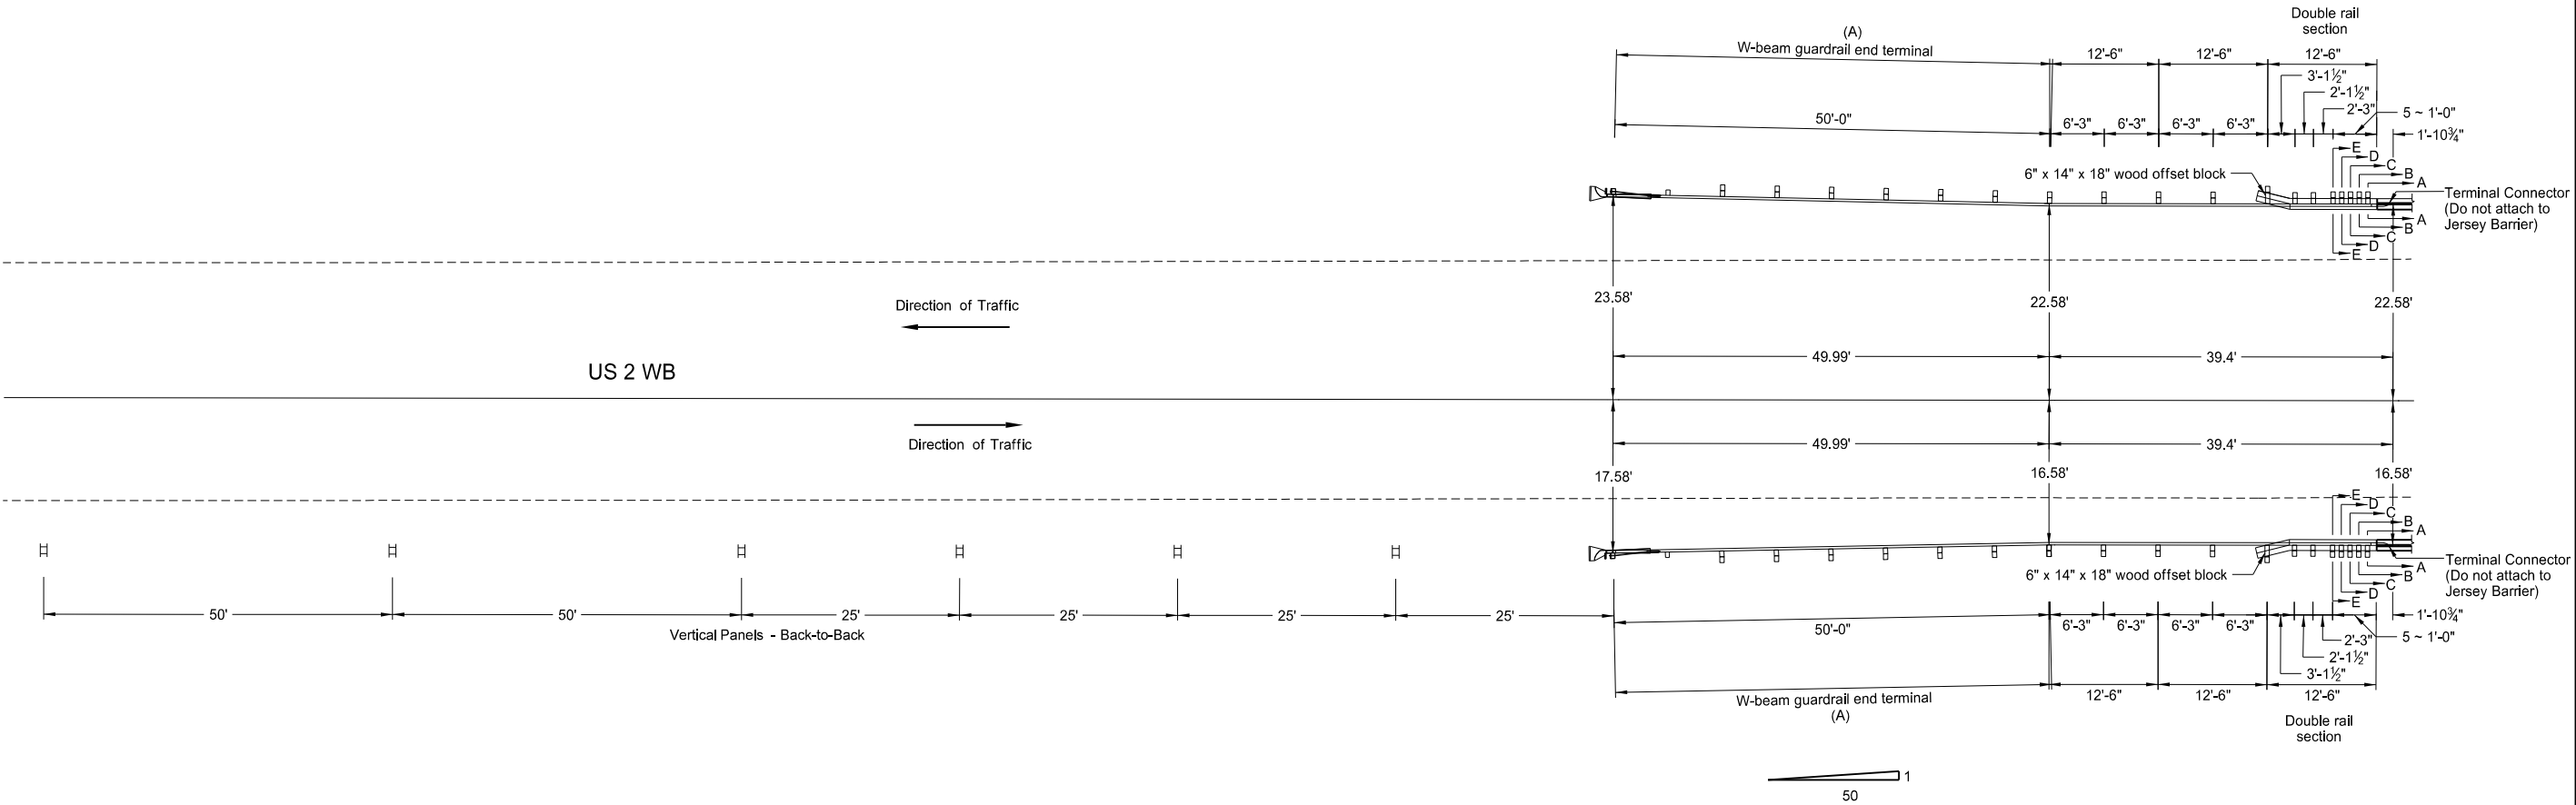 

SPEC	CODE	BID ITEM	QTY	UNIT
704	1081	VERTICAL PANELS-BACK TO BACK		
		Cow Creek WB Bridge	6	EA
764	0145	W-BEAM GUARDRAIL END TERMINALS		
		Cow Creek WB Bridge	2	EA

Notes
(A) Install a Sequential Kinking Terminal at this location

This document was originally issued and sealed by
Levi J Heller,
Registration Number
PE-10394
on 08/09/17 and the original document is stored at the
North Dakota Department
of Transportation

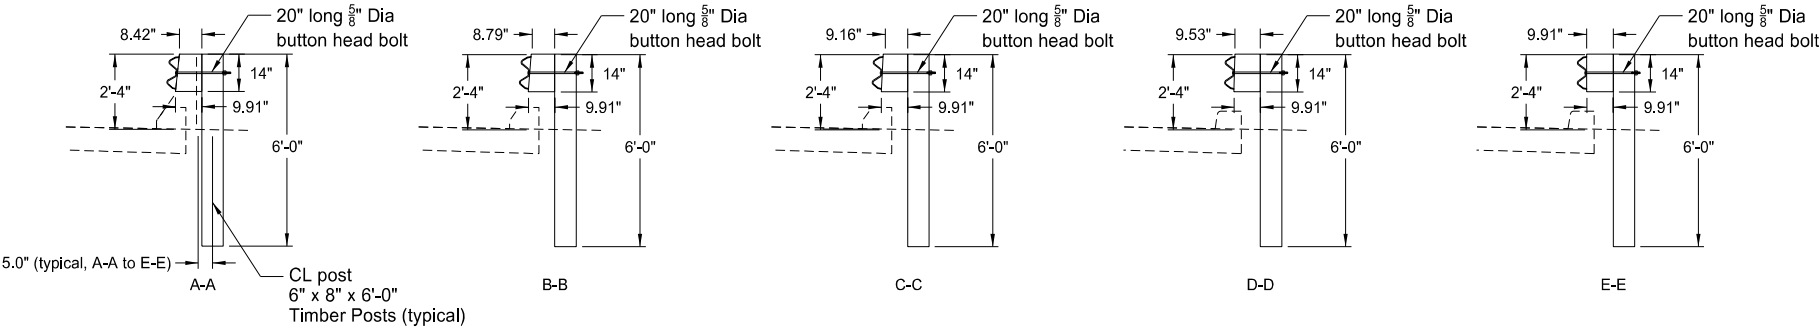



Vertical Panel and W-Beam Guardrail Layout
For Two-Way Traffic


Cow Creek Crossing - RP 29.262

US 2 Westbound

																					STATE	PROJECT NO.		SECTION NO.	SHEET NO.
																				N.D.	NH-NHU-7-002(156)022		110	1	
Station / RP	Sign No.	Assembly No.	Flat Sheet For Signs		Sign Support Length				Vert Clear- ance FT	Support Size	Max Post Len LF	Sleeve Length				Sleeve Size	Anchor EA	Anchor LF	Anchor Size	Reset Sign Panel EA	Reset Sign Support EA	Break-Away EA	Comments		
			IV SF	XI SF	1st LF	2nd LF	3rd LF	4th LF				1st LF	2nd LF	3rd LF	4th LF										
60+29 Rt	Spring Lake Park				13.70	14.20	14.70		7.0	2.5 x 2.5 10 ga	15.4						3	12	3 x 3 7 ga	1		3			
62+27 Lt	Sign 1		15.0																				Mount on Mast Arm		
62+27 Lt	Sign 4	17		16.0																			Mount on Mast Arm		
62+32 Rt	Sign 3		15.0																				Mount on Mast Arm		
62+32 Rt	Sign 4	17		16.0																			Mount on Mast Arm		
63+36 Rt	R6-1R	27	3.0		9.90				5.0	2 x 2 12 ga	13.2						1	4	2.25 x 2.25 12 ga						
63+72 Rt	Sign 1		15.0																				Mount on Mast Arm		
63+72 Rt	Sign 4	17		16.0																			Mount on Mast Arm		
63+75 Lt	Sign 3		15.0																				Mount on Mast Arm		
63+75 Lt	Sign 4	17		16.0																			Mount on Mast Arm		
66+44 Lt mdn	R2-1 & R2-1			24.0	14.70	14.70			7.0	2.5 x 2.5 12 ga	16.2						2	8	3 x 3 7 ga			2			
66+68 Lt	R2-1	11		12.0					7.0														Mount on Light Standard		
68+56 Lt	W3-4	58		19.0	17.00	17.20	17.50		7.0	2.5 x 2.5 10 ga	19.4						3	12	3 x 3 7 ga			3			
68+56 Lt mdn	W3-4	58		19.0	17.00	17.20	17.50		7.0	2.5 x 2.5 10 ga	19.4						3	12	3 x 3 7 ga			3			
70+56 Lt	R2-1	10		7.5	14.40				7.0	2.5 x 2.5 10 ga	15.9						1	4	3 x 3 7 ga			1			
70+56 Rt	R2-1	10		7.5	14.40				7.0	2.5 x 2.5 10 ga	15.9						1	4	3 x 3 7 ga			1			
70+56 Lt mdn	R2-1			15.0	14.40				7.0	2.5 x 2.5 10 ga	15.9						1	4	3 x 3 7 ga			1			
72+79 Lt	Spring Lake Park				12.90	13.90			7.0	2.5 x 2.5 12 ga	15.0	4.0	5.0			2.25 x 2.25 12 ga	2	8	3 x 3 7 ga	1		2			
129+47 Rt	R6-1L	27		3.0	10.90				5.0	2 x 2 12 ga	13.2						1	4	2.25 x 2.25 12 ga						
158+62 Lt mdn	W3-3	21		16.0	15.50	16.00			7.0	2.5 x 2.5 12 ga	20.0	3.5	4.0			2.25 x 2.25 12 ga	2	8	3 x 3 7 ga			2			
158+62 Rt	W3-3	21		16.0	15.50	16.00			7.0	2.5 x 2.5 12 ga	20.0	3.5	4.0			2.25 x 2.25 12 ga	2	8	3 x 3 7 ga			2			
162+62 Lt mdn	W3-4	58		19.0	17.00	17.20	17.50		7.0	2.5 x 2.5 10 ga	19.4						3	12	3 x 3 7 ga			3			
162+62 Rt	W3-4	58		19.0	17.00	17.20	17.50		7.0	2.5 x 2.5 10 ga	19.4						3	12	3 x 3 7 ga			3			
164+57 Rt	W12-2	58			17.40	17.70	17.90		7.0	2.5 x 2.5 10 ga	19.4						3	12	3 x 3 7 ga	1		3			
169+15 Lt	Sign 4	17		16.0																			Mount on Mast Arm		
169+15 Lt	Sign 2		15.0																				Mount on Mast Arm		
169+15 Rt	Sign 3		15.0																				Mount on Mast Arm		
169+25 Lt mdn	R6-1	27			12.50				7.0	2 x 2 12 ga	13.2						1	4	2.25 x 2.25 12 ga	1					
169+80 Lt	Sign 3		15.0																				Mount on Mast Arm		
169+80 Lt	Sign 4	17		16.0																			Mount on Mast Arm		
170+13 Lt mdn	R6-1	27			12.50				7.0	2 x 2 12 ga	13.2						1	4	2.25 x 2.25 12 ga	1					
170+15 Rt	Sign 2		15.0																				Mount on Mast Arm		
176+48 Lt	W3-4	58		19.0	17.00	17.20	17.50		7.0	2.5 x 2.5 10 ga	19.4						3	12	3 x 3 7 ga			3			
176+48 Lt mdn	W3-4	58		19.0	17.00	17.20	17.50		7.0	2.5 x 2.5 10 ga	19.4						3	12	3 x 3 7 ga			3			
180+48 Lt mdn	W3-3	21		16.0	15.50	16.00			7.0	2.5 x 2.5 12 ga	20.0	3.5	4.0			2.25 x 2.25 12 ga	2	8	3 x 3 7 ga			2			
180+48 Lt	W3-3	21		16.0	15.50	16.00			7.0	2.5 x 2.5 12 ga	20.0	3.5	4.0			2.25 x 2.25 12 ga	2	8	3 x 3 7 ga			2			
181+19 Rt	R5-1	16		9.0	13.90				7.0	2.5 x 2.5 12 ga	14.4	5.3				2.25 x 2.25 12 ga	1	4	3 x 3 7 ga			1			
181+19 Lt mdn	R5-1	16		9.0	14.00				7.0	2.5 x 2.5 12 ga	14.4	5.3				2.25 x 2.25 12 ga	1	4	3 x 3 7 ga			1			
183+43 Rt					11.50				5.0	2.5 x 2.5 12 ga	13.3	3.1				2.25 x 2.25 12 ga	1	4	3 x 3 7 ga	1		1			
183+79 Rt	Street		14.0		10.90				5.0	2.5 x 2.5 12 ga	11.3						1	4	3 x 3 7 ga				Special Assembly 1E		
																		This document was originally issued and sealed by Derek Anderson, Registration Number 7107, on 8/2/2017 and is stored at the North Dakota Department of Transportation.		Sign Summary Perforated Tube					
8/1/2017 11:35:37AM																									
Page 1 of 2																									

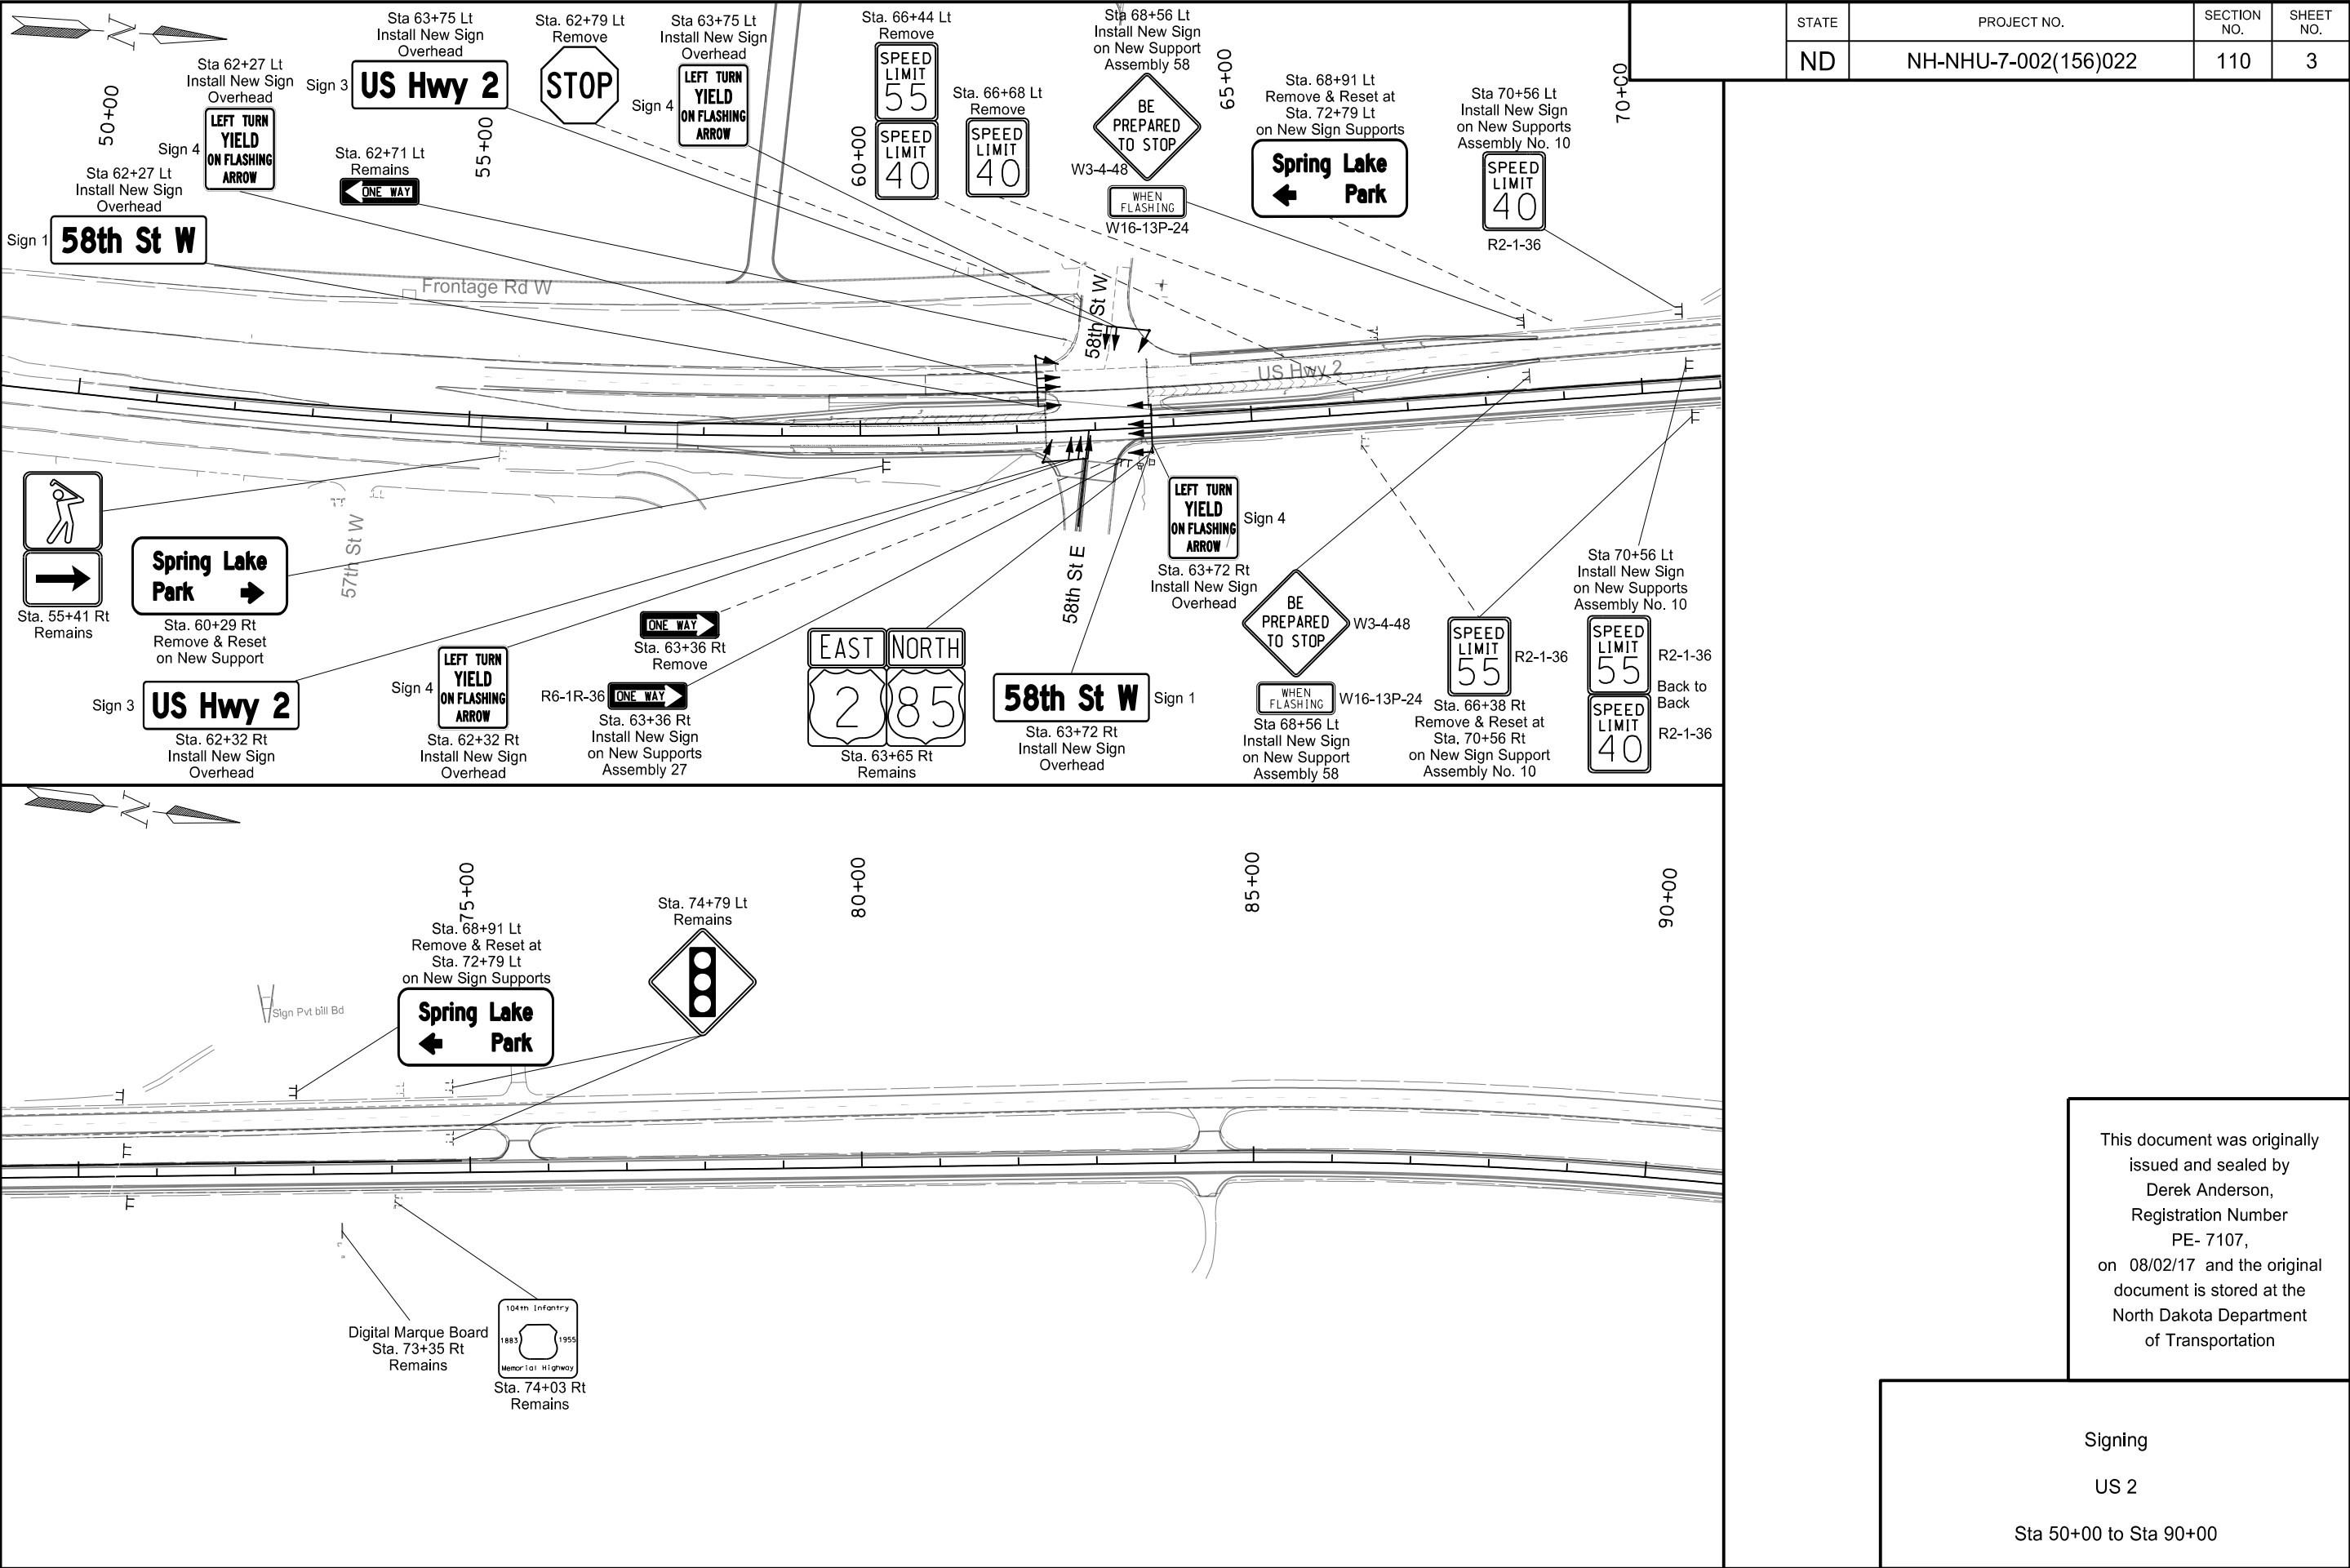

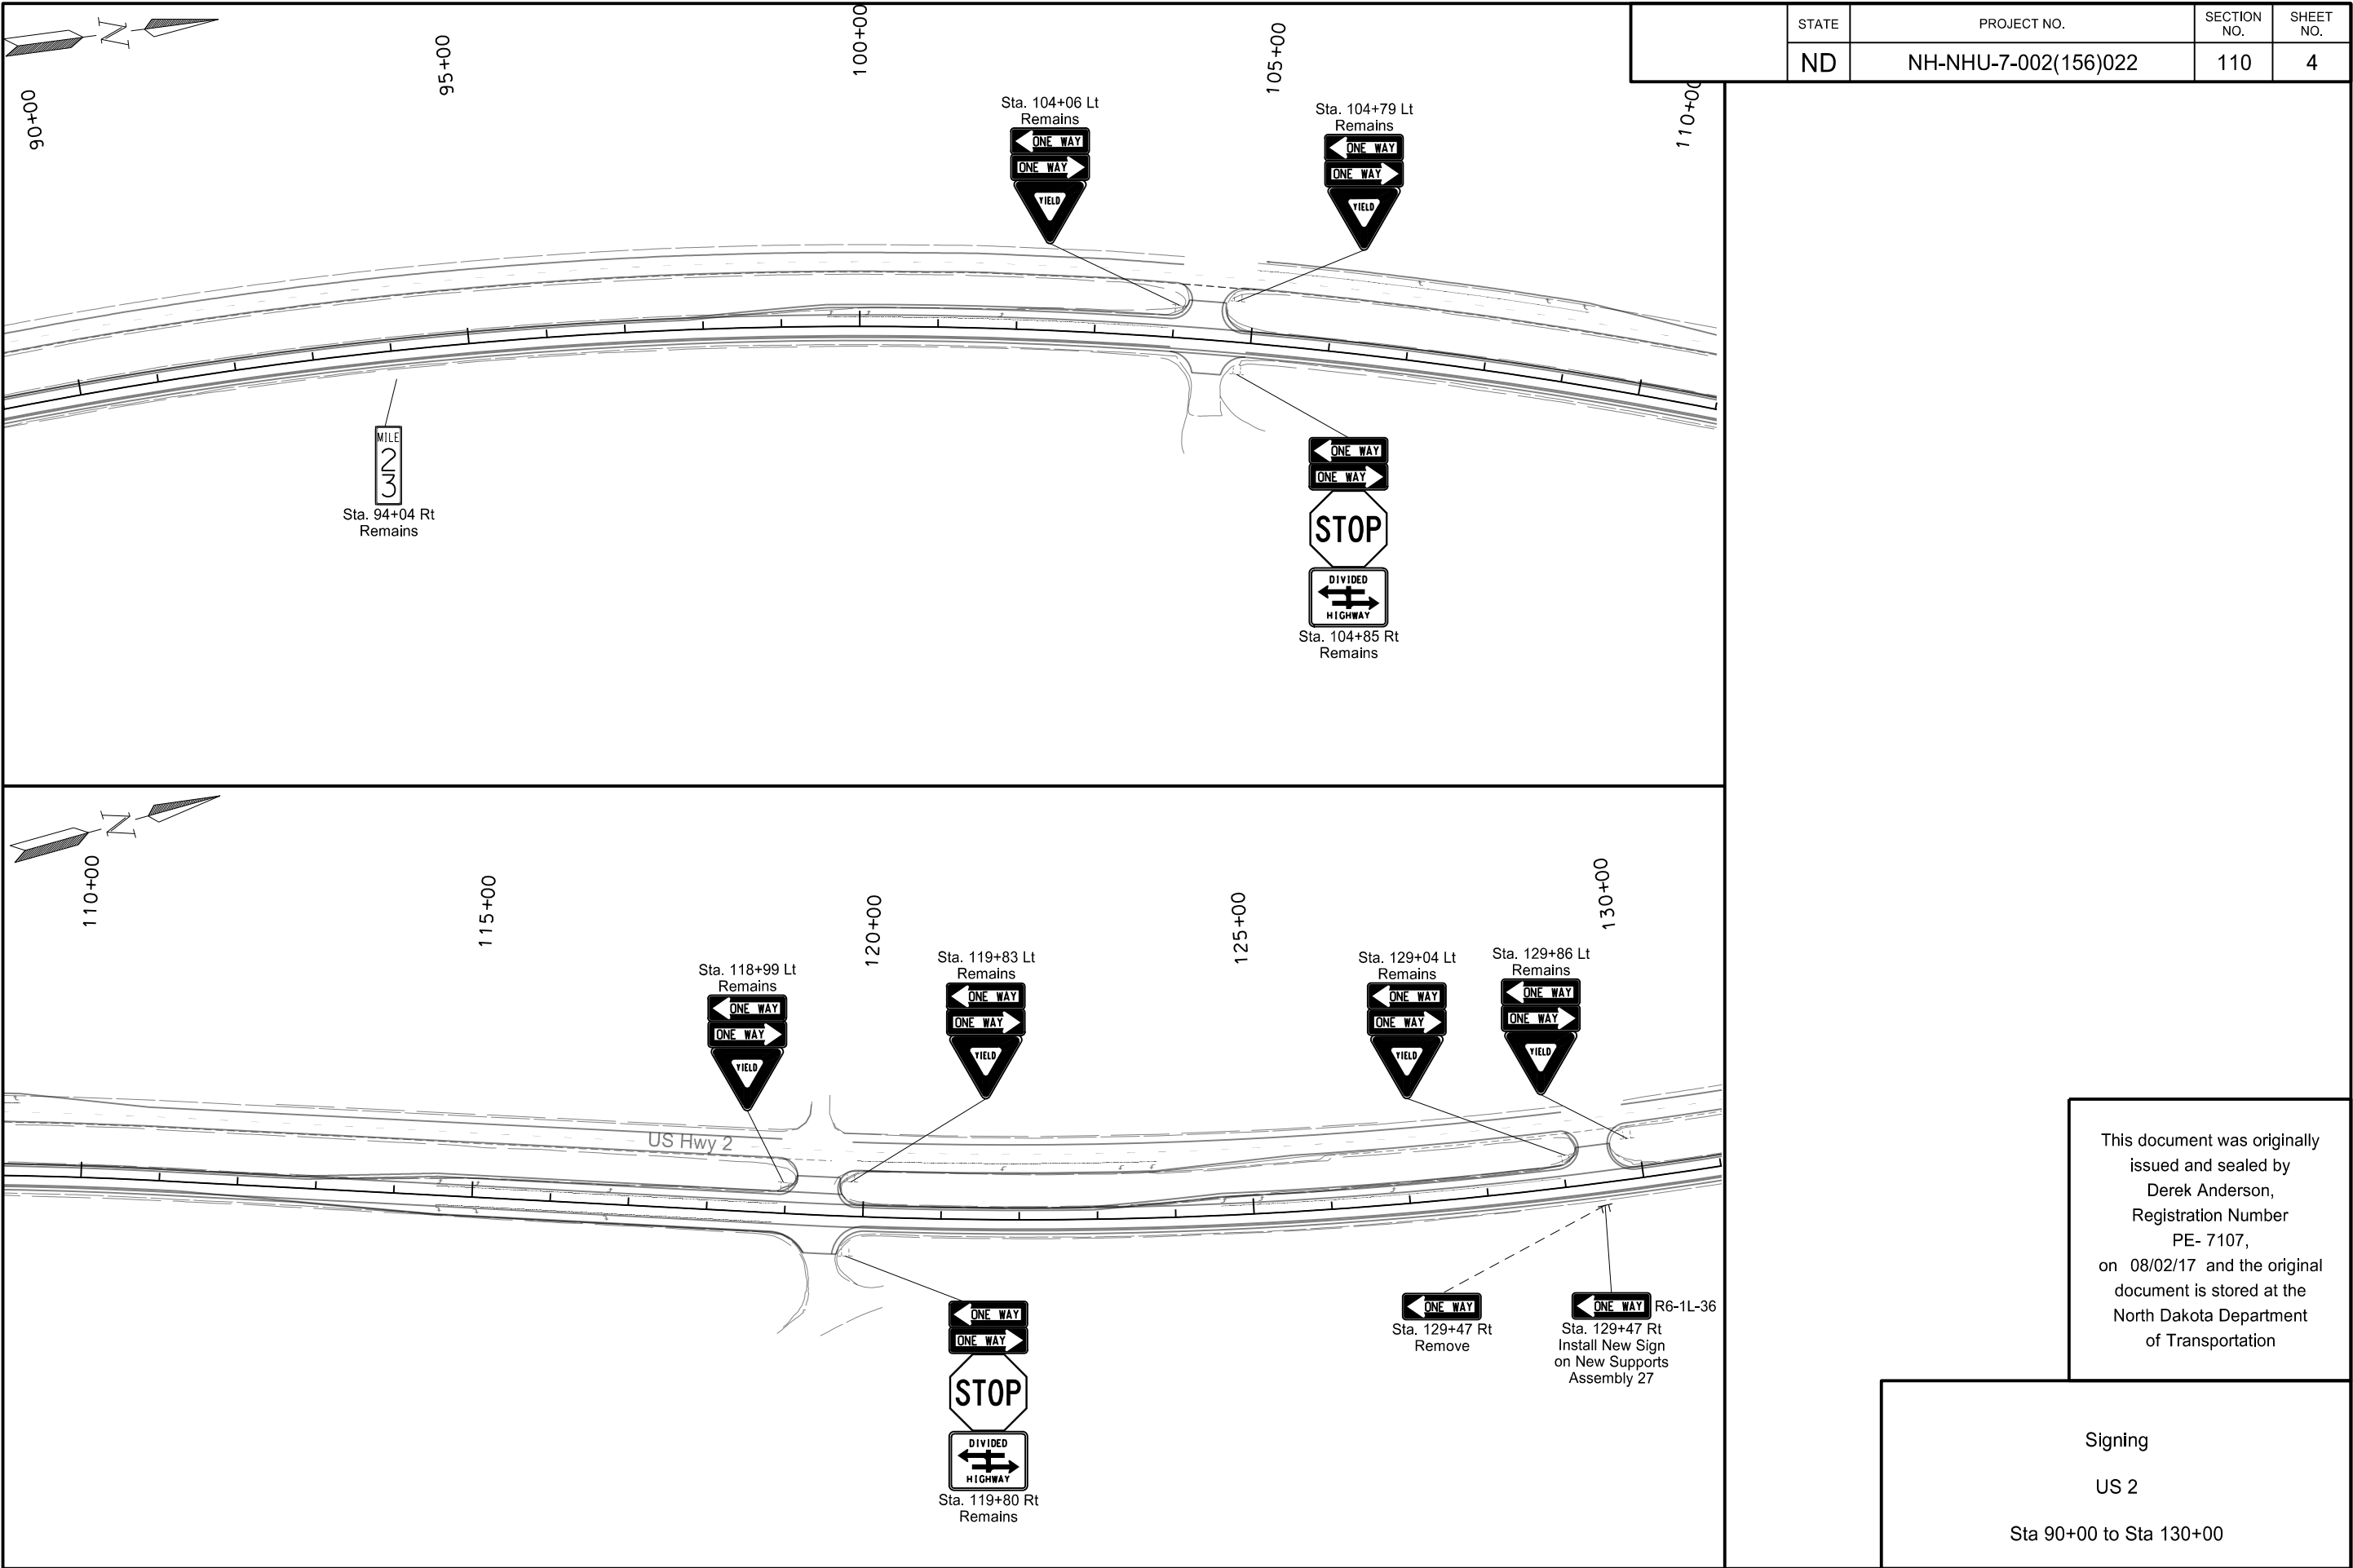

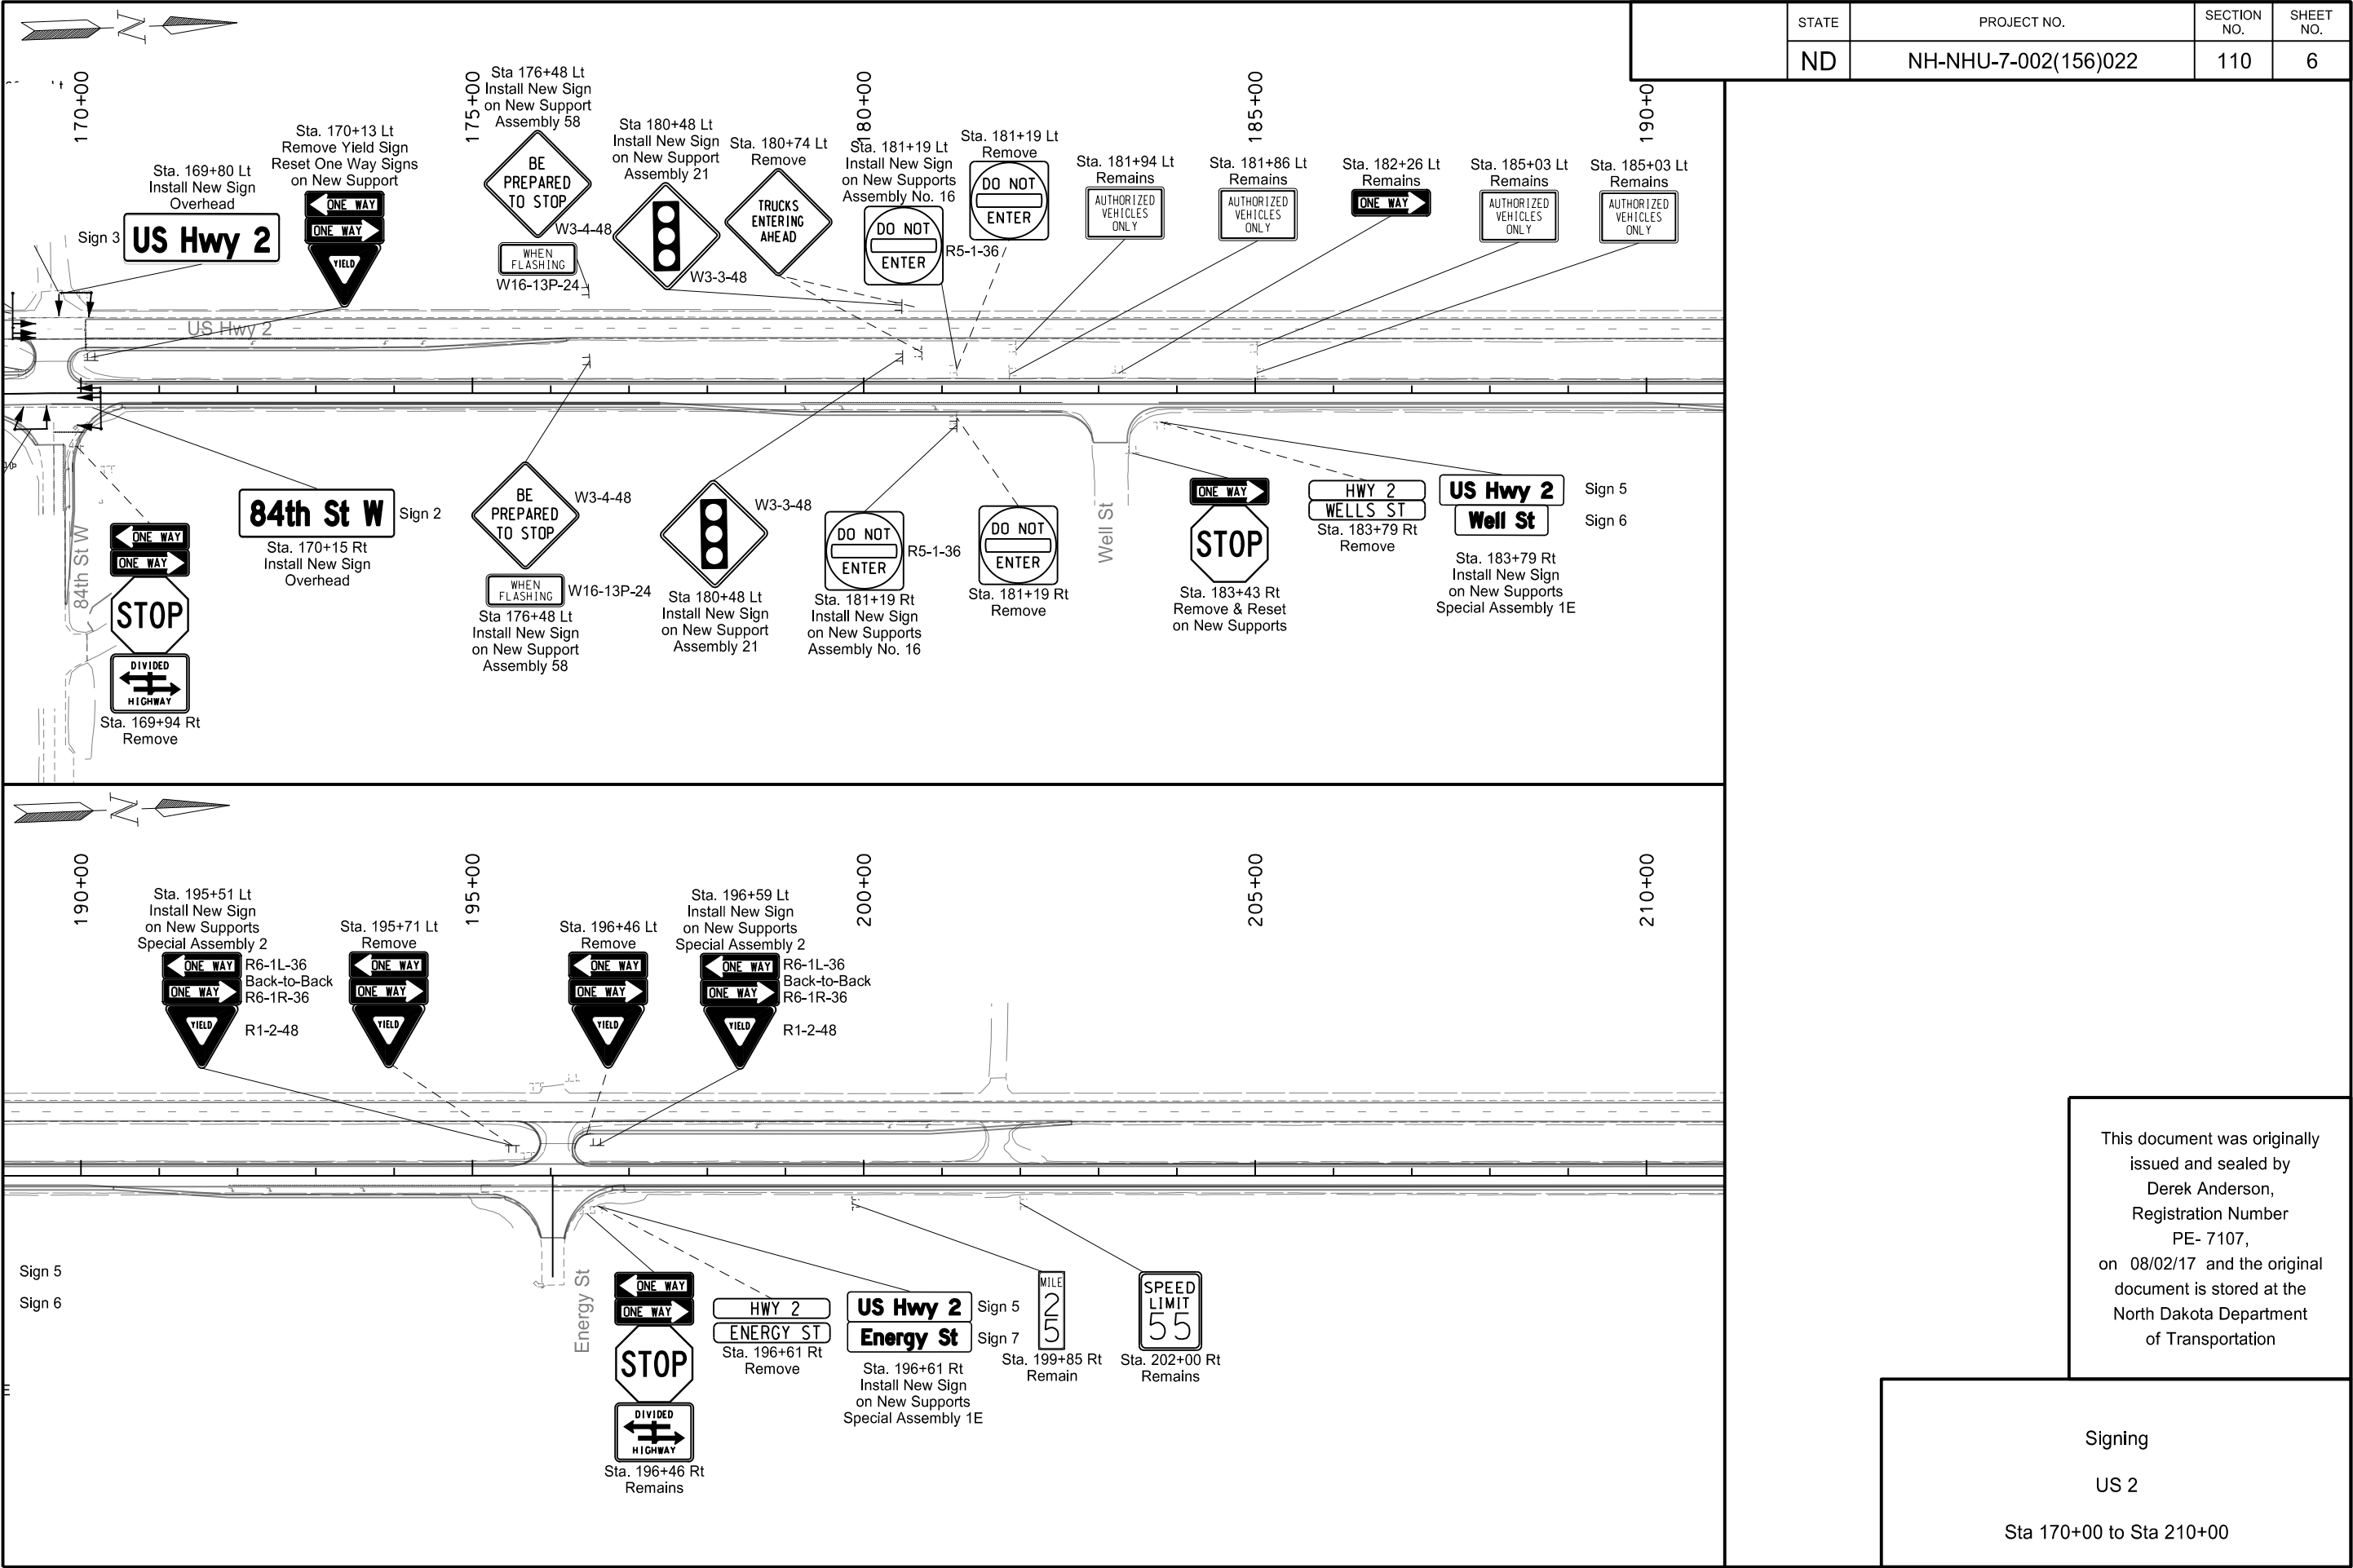



This document was originally issued and sealed by
Derek Anderson,
Registration Number
PE- 7107,
on 08/02/17 and the original document is stored at the
North Dakota Department
of Transportation

Signing

US 2


Sta 170+00 to Sta 210+00

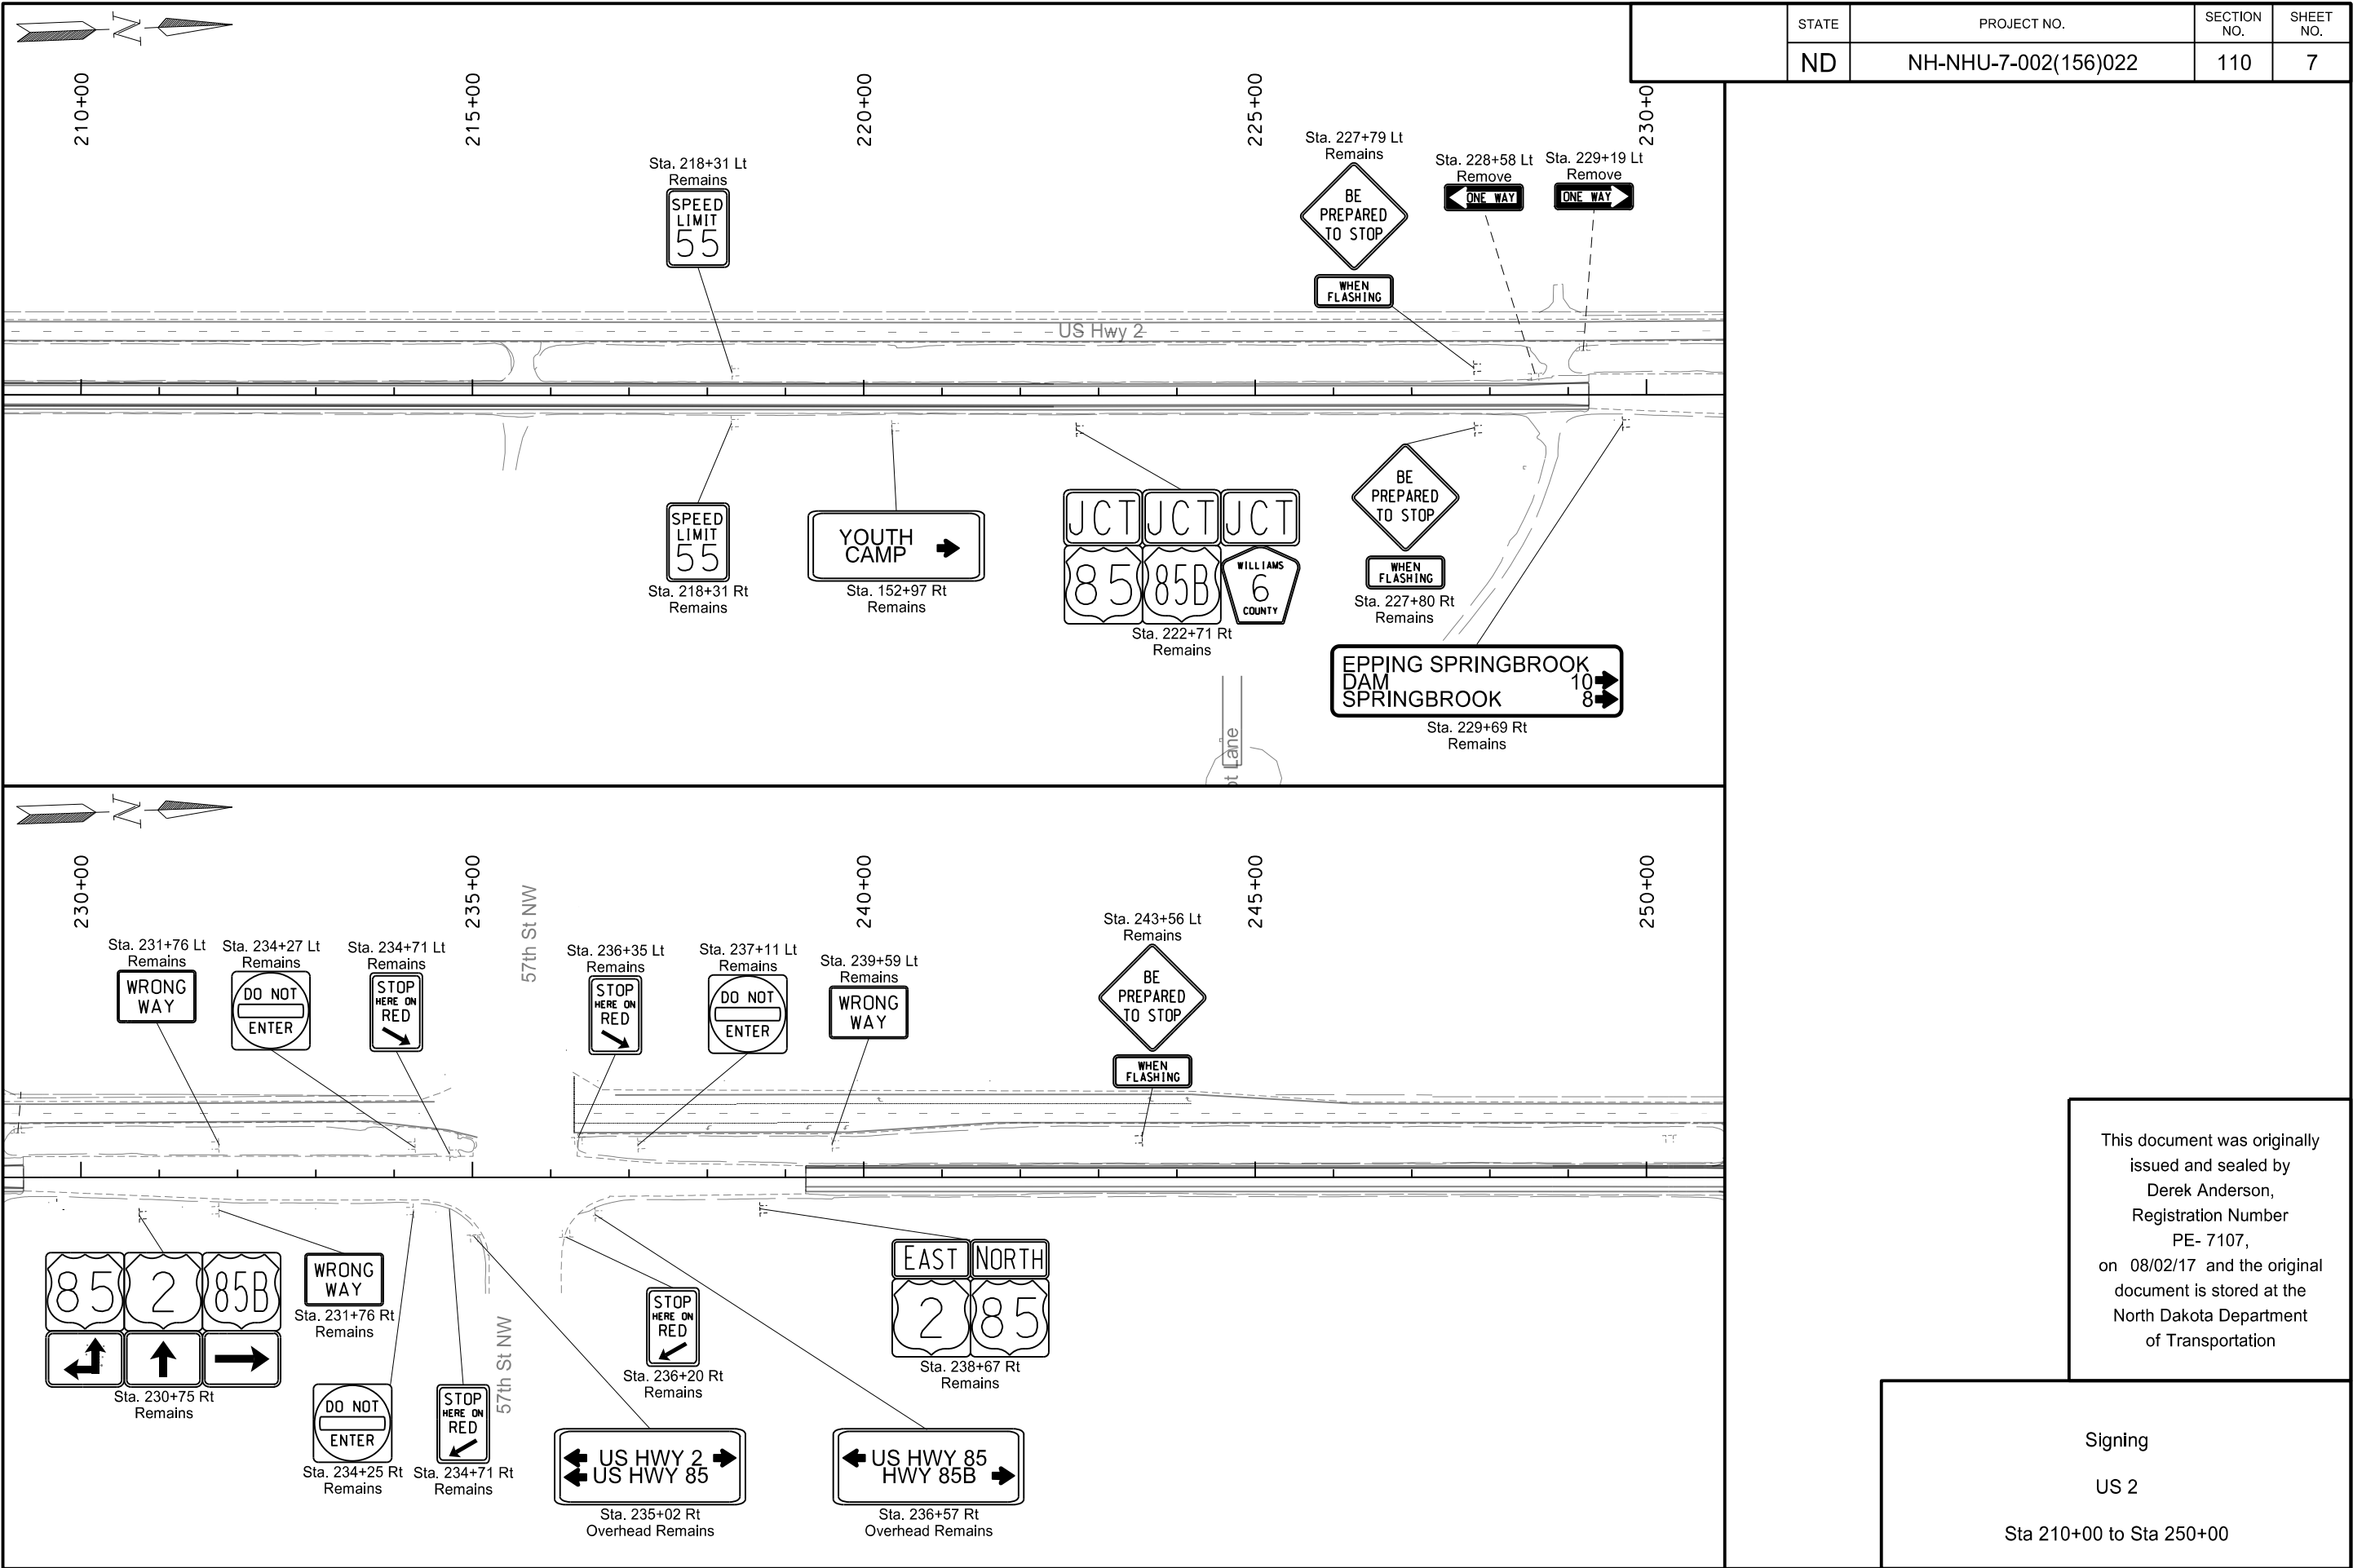


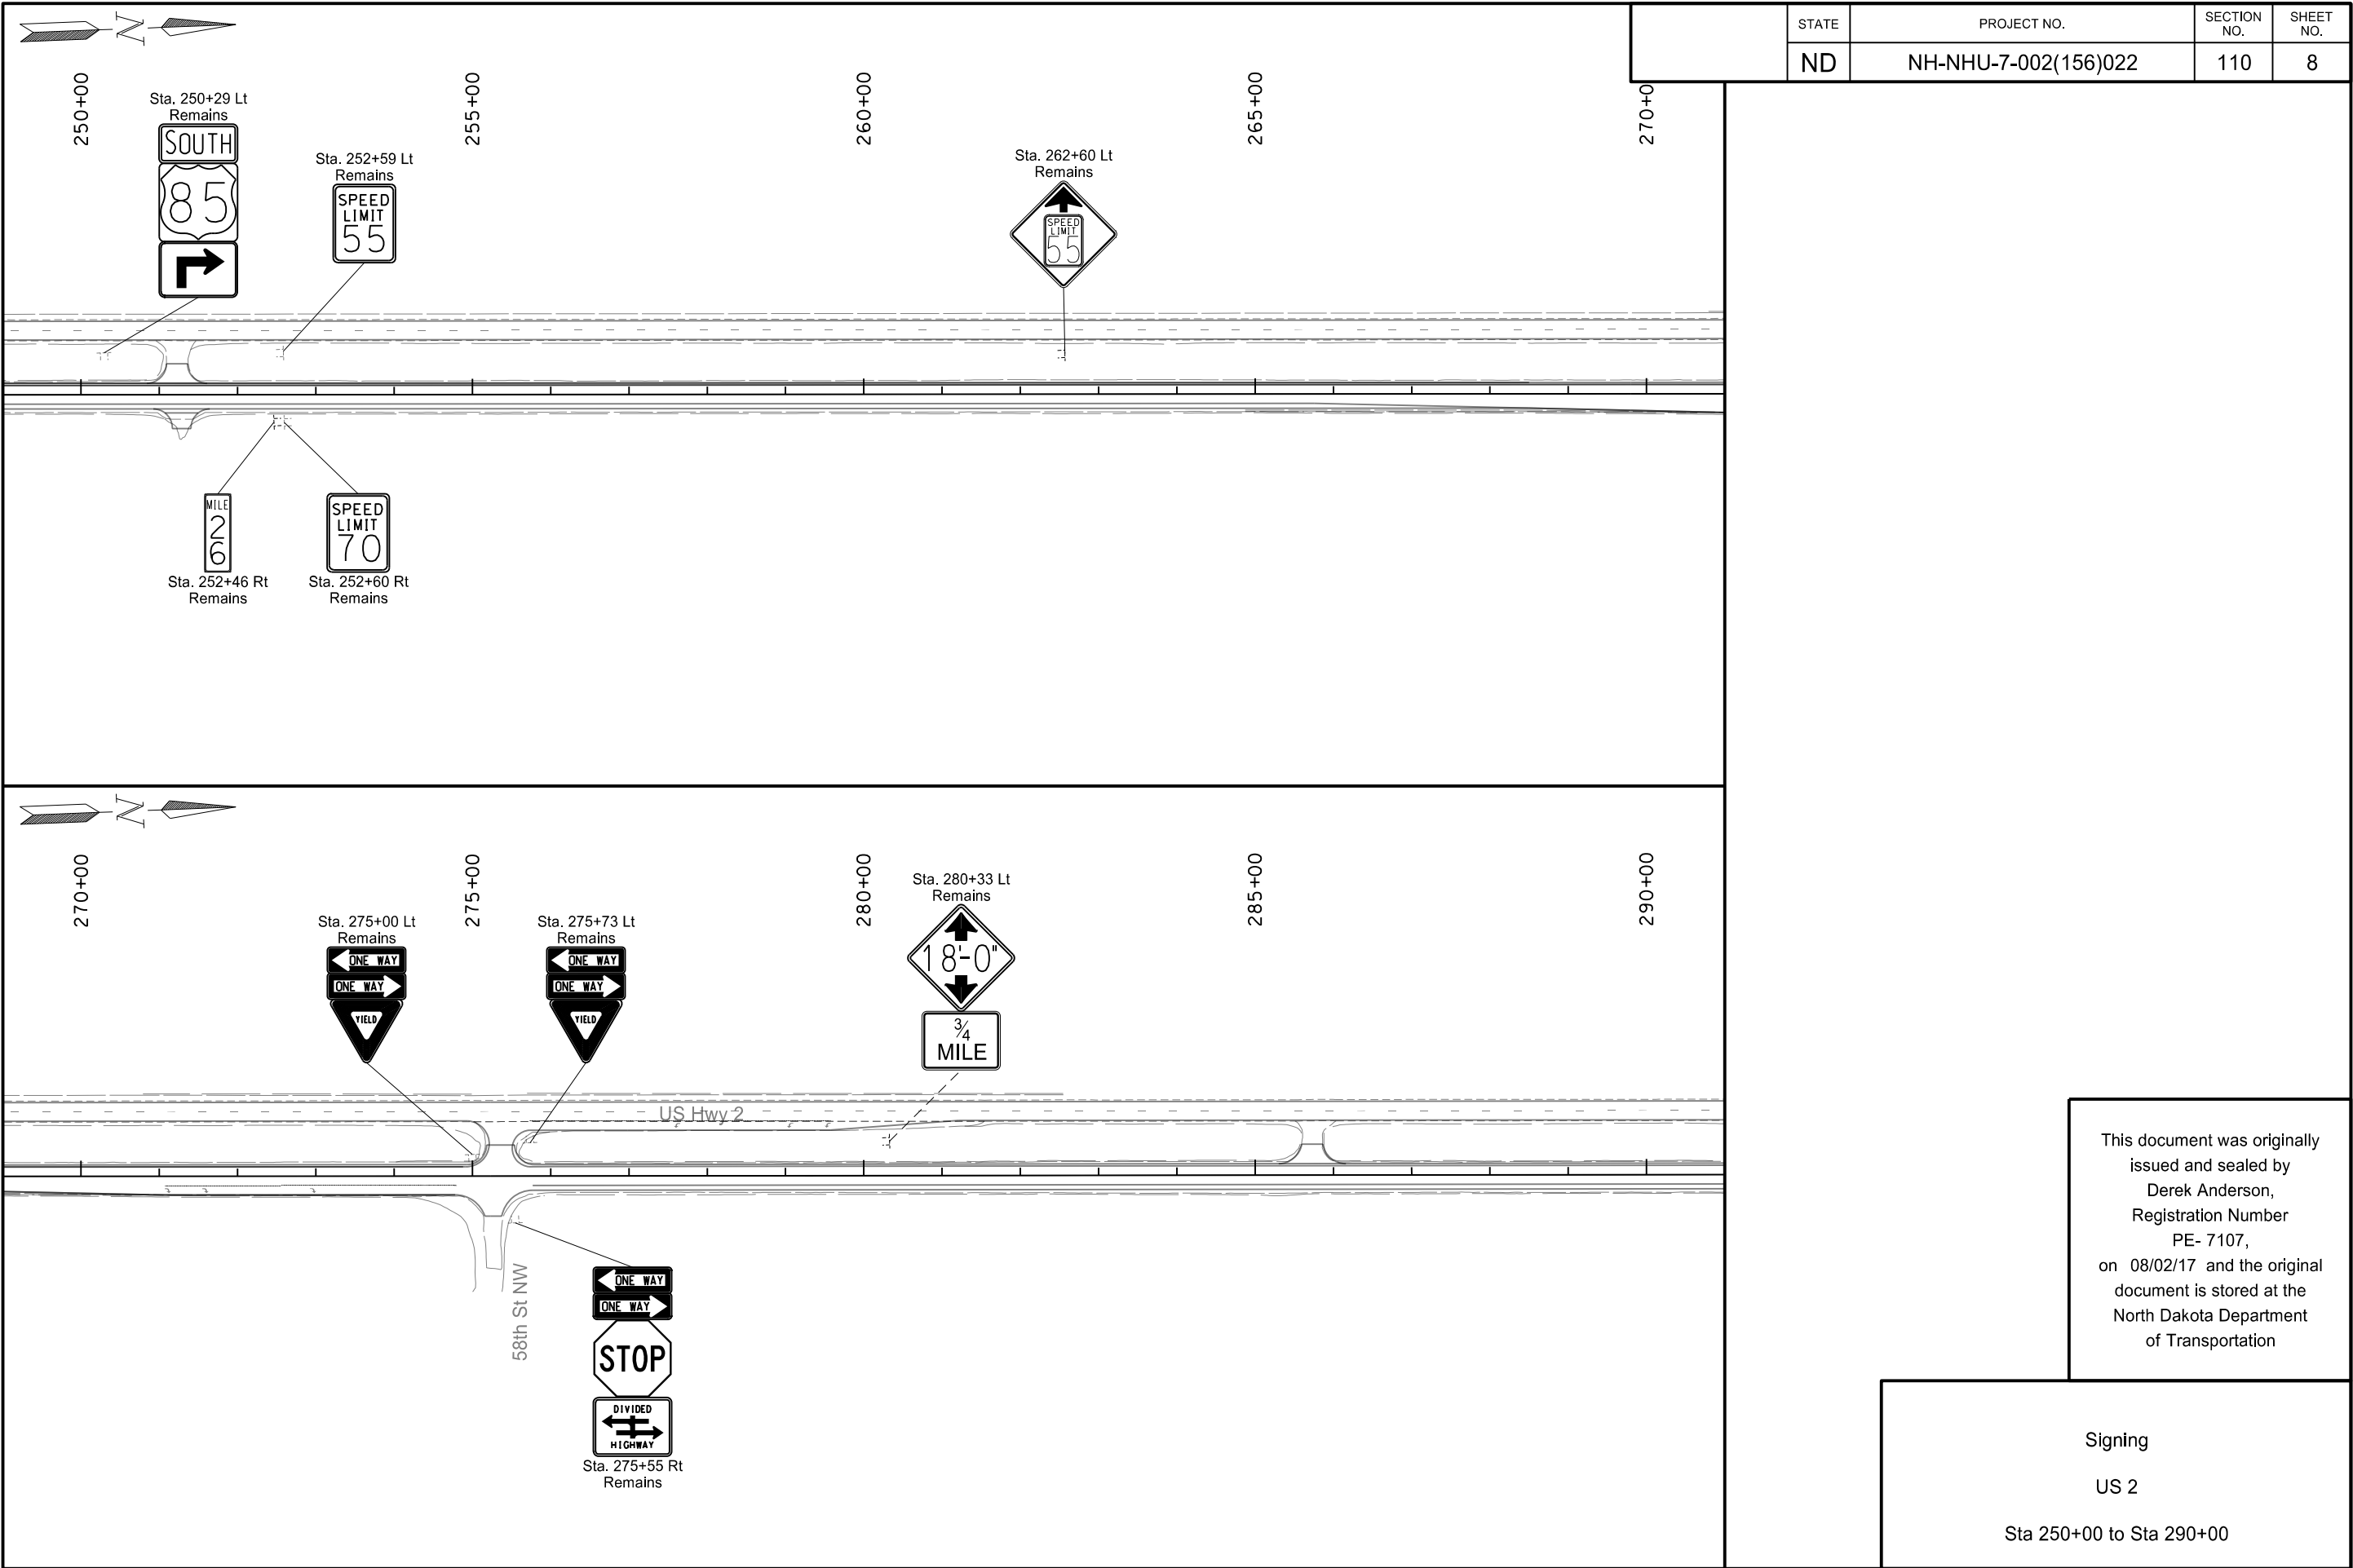



This document was originally issued and sealed by
Derek Anderson,
Registration Number
PE- 7107,
on 08/02/17 and the original document is stored at the
North Dakota Department
of Transportation


Signing
US 2
Sta 250+00 to Sta 290+00

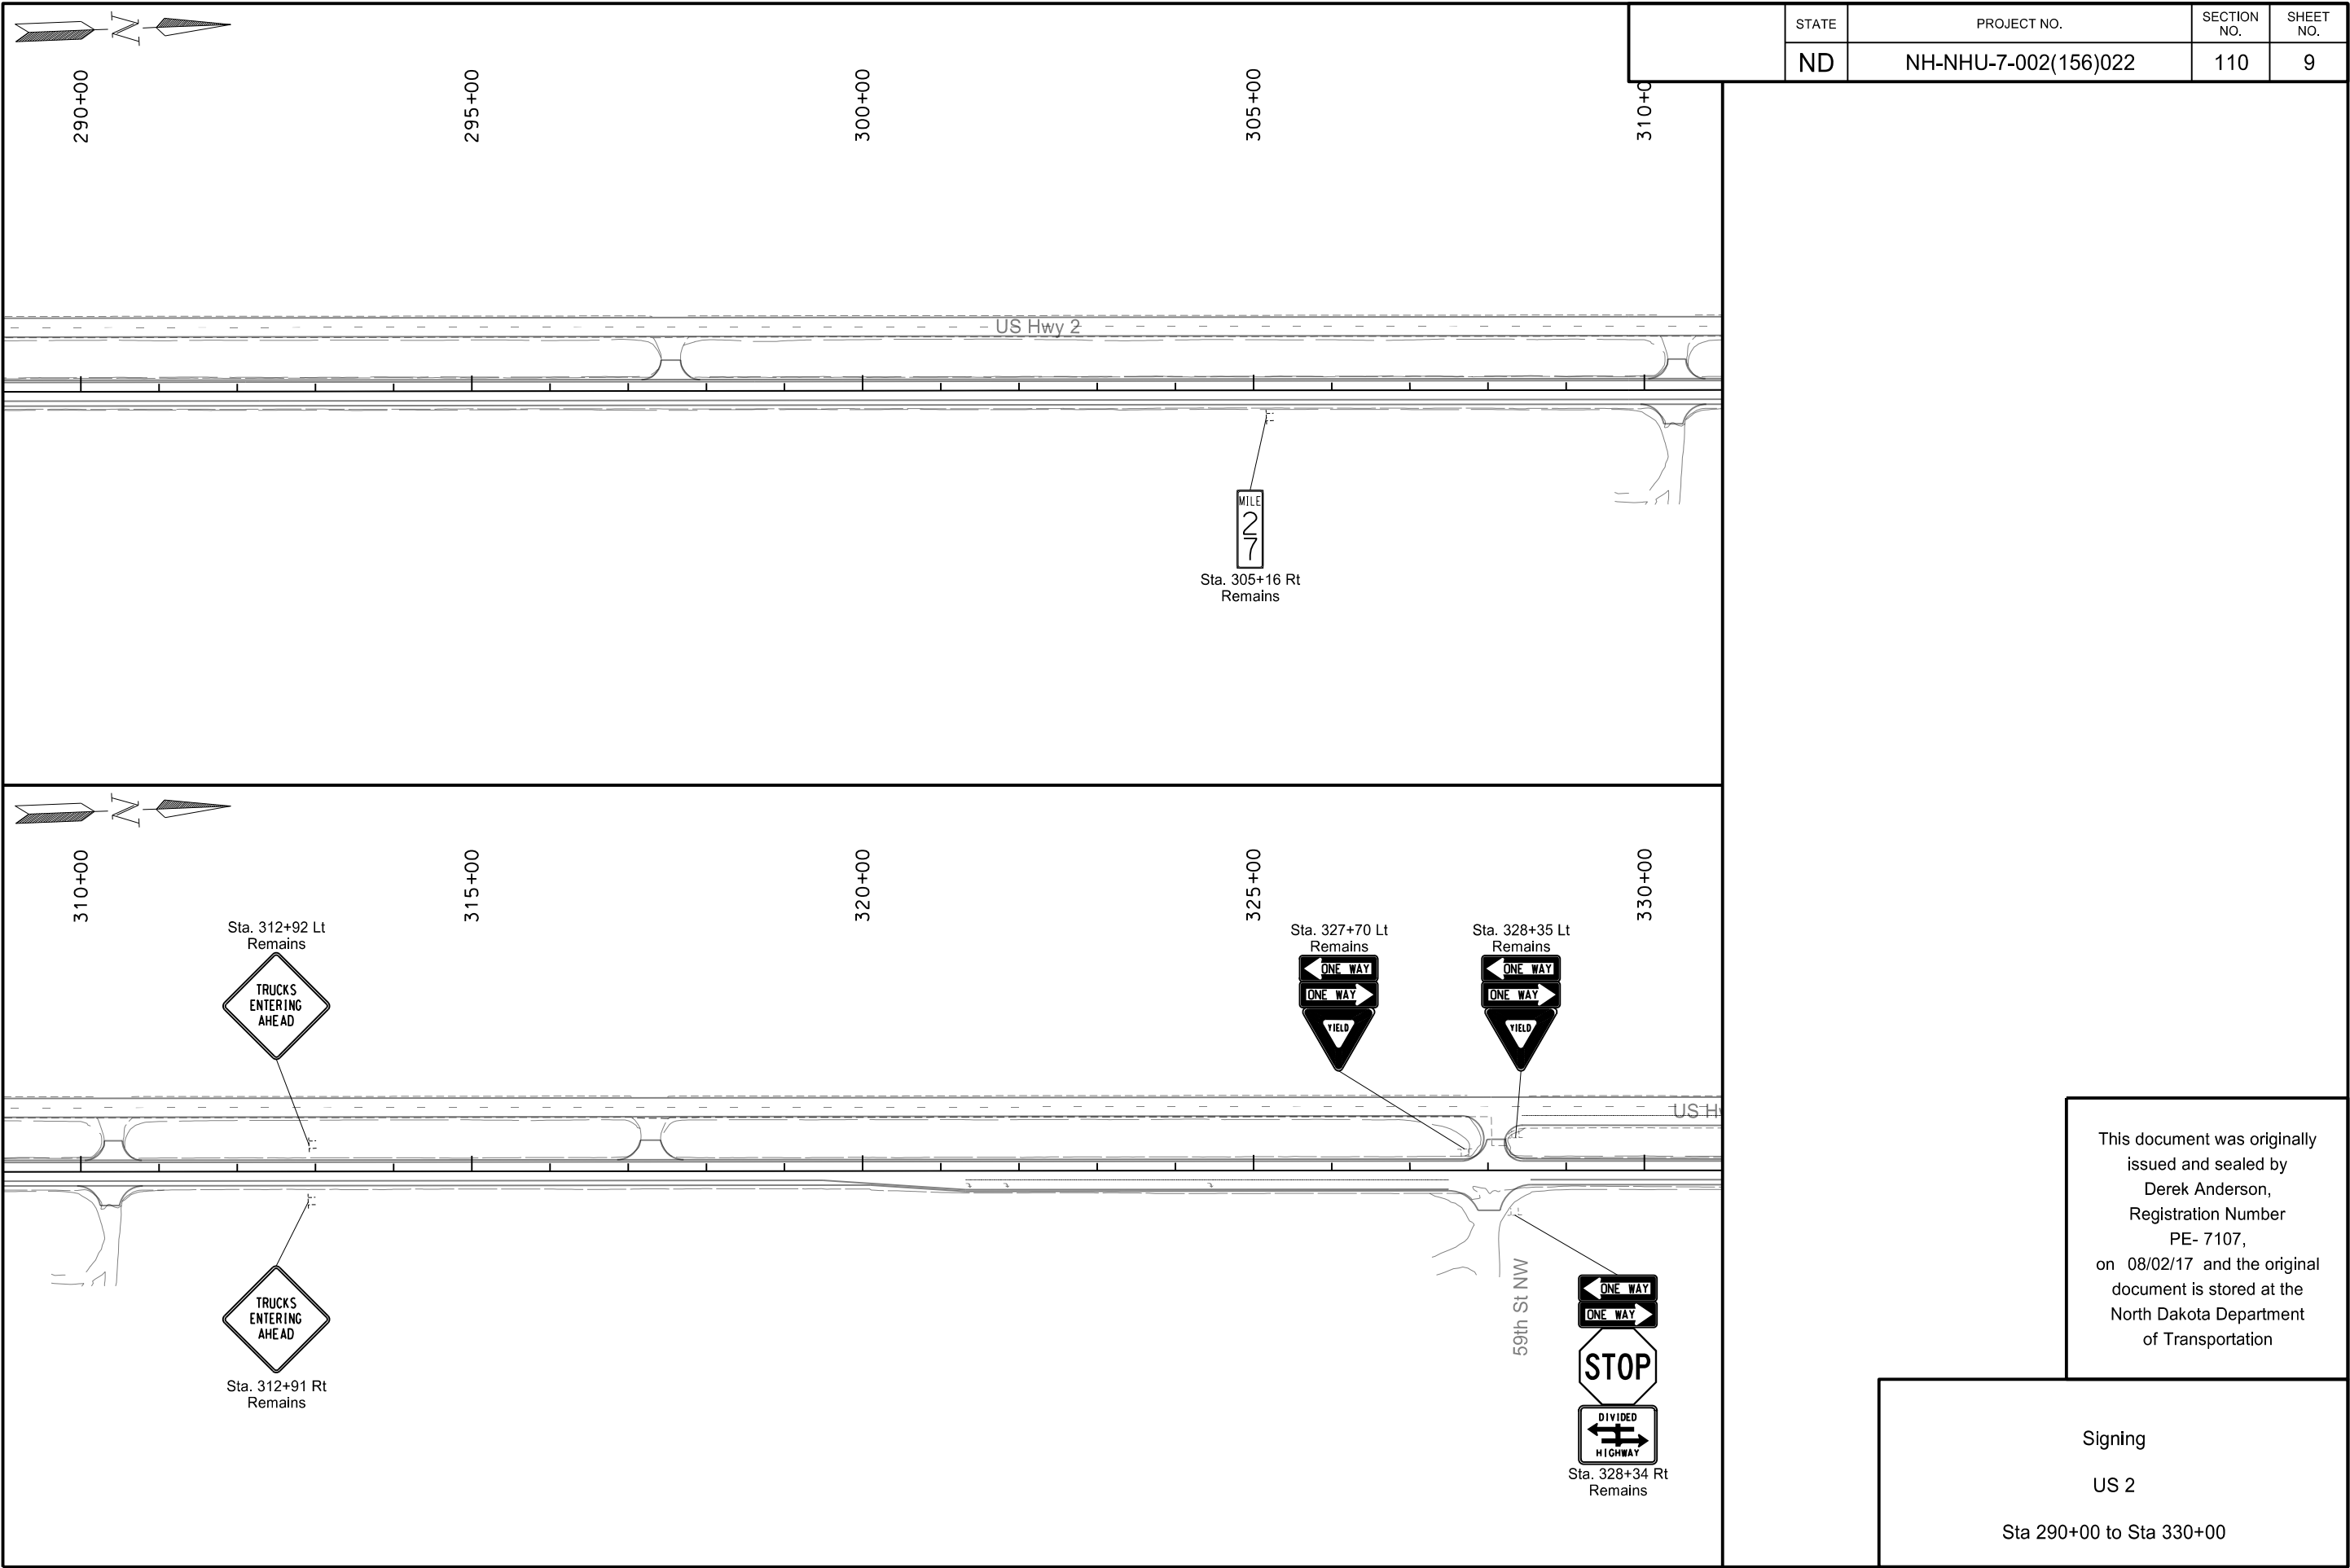


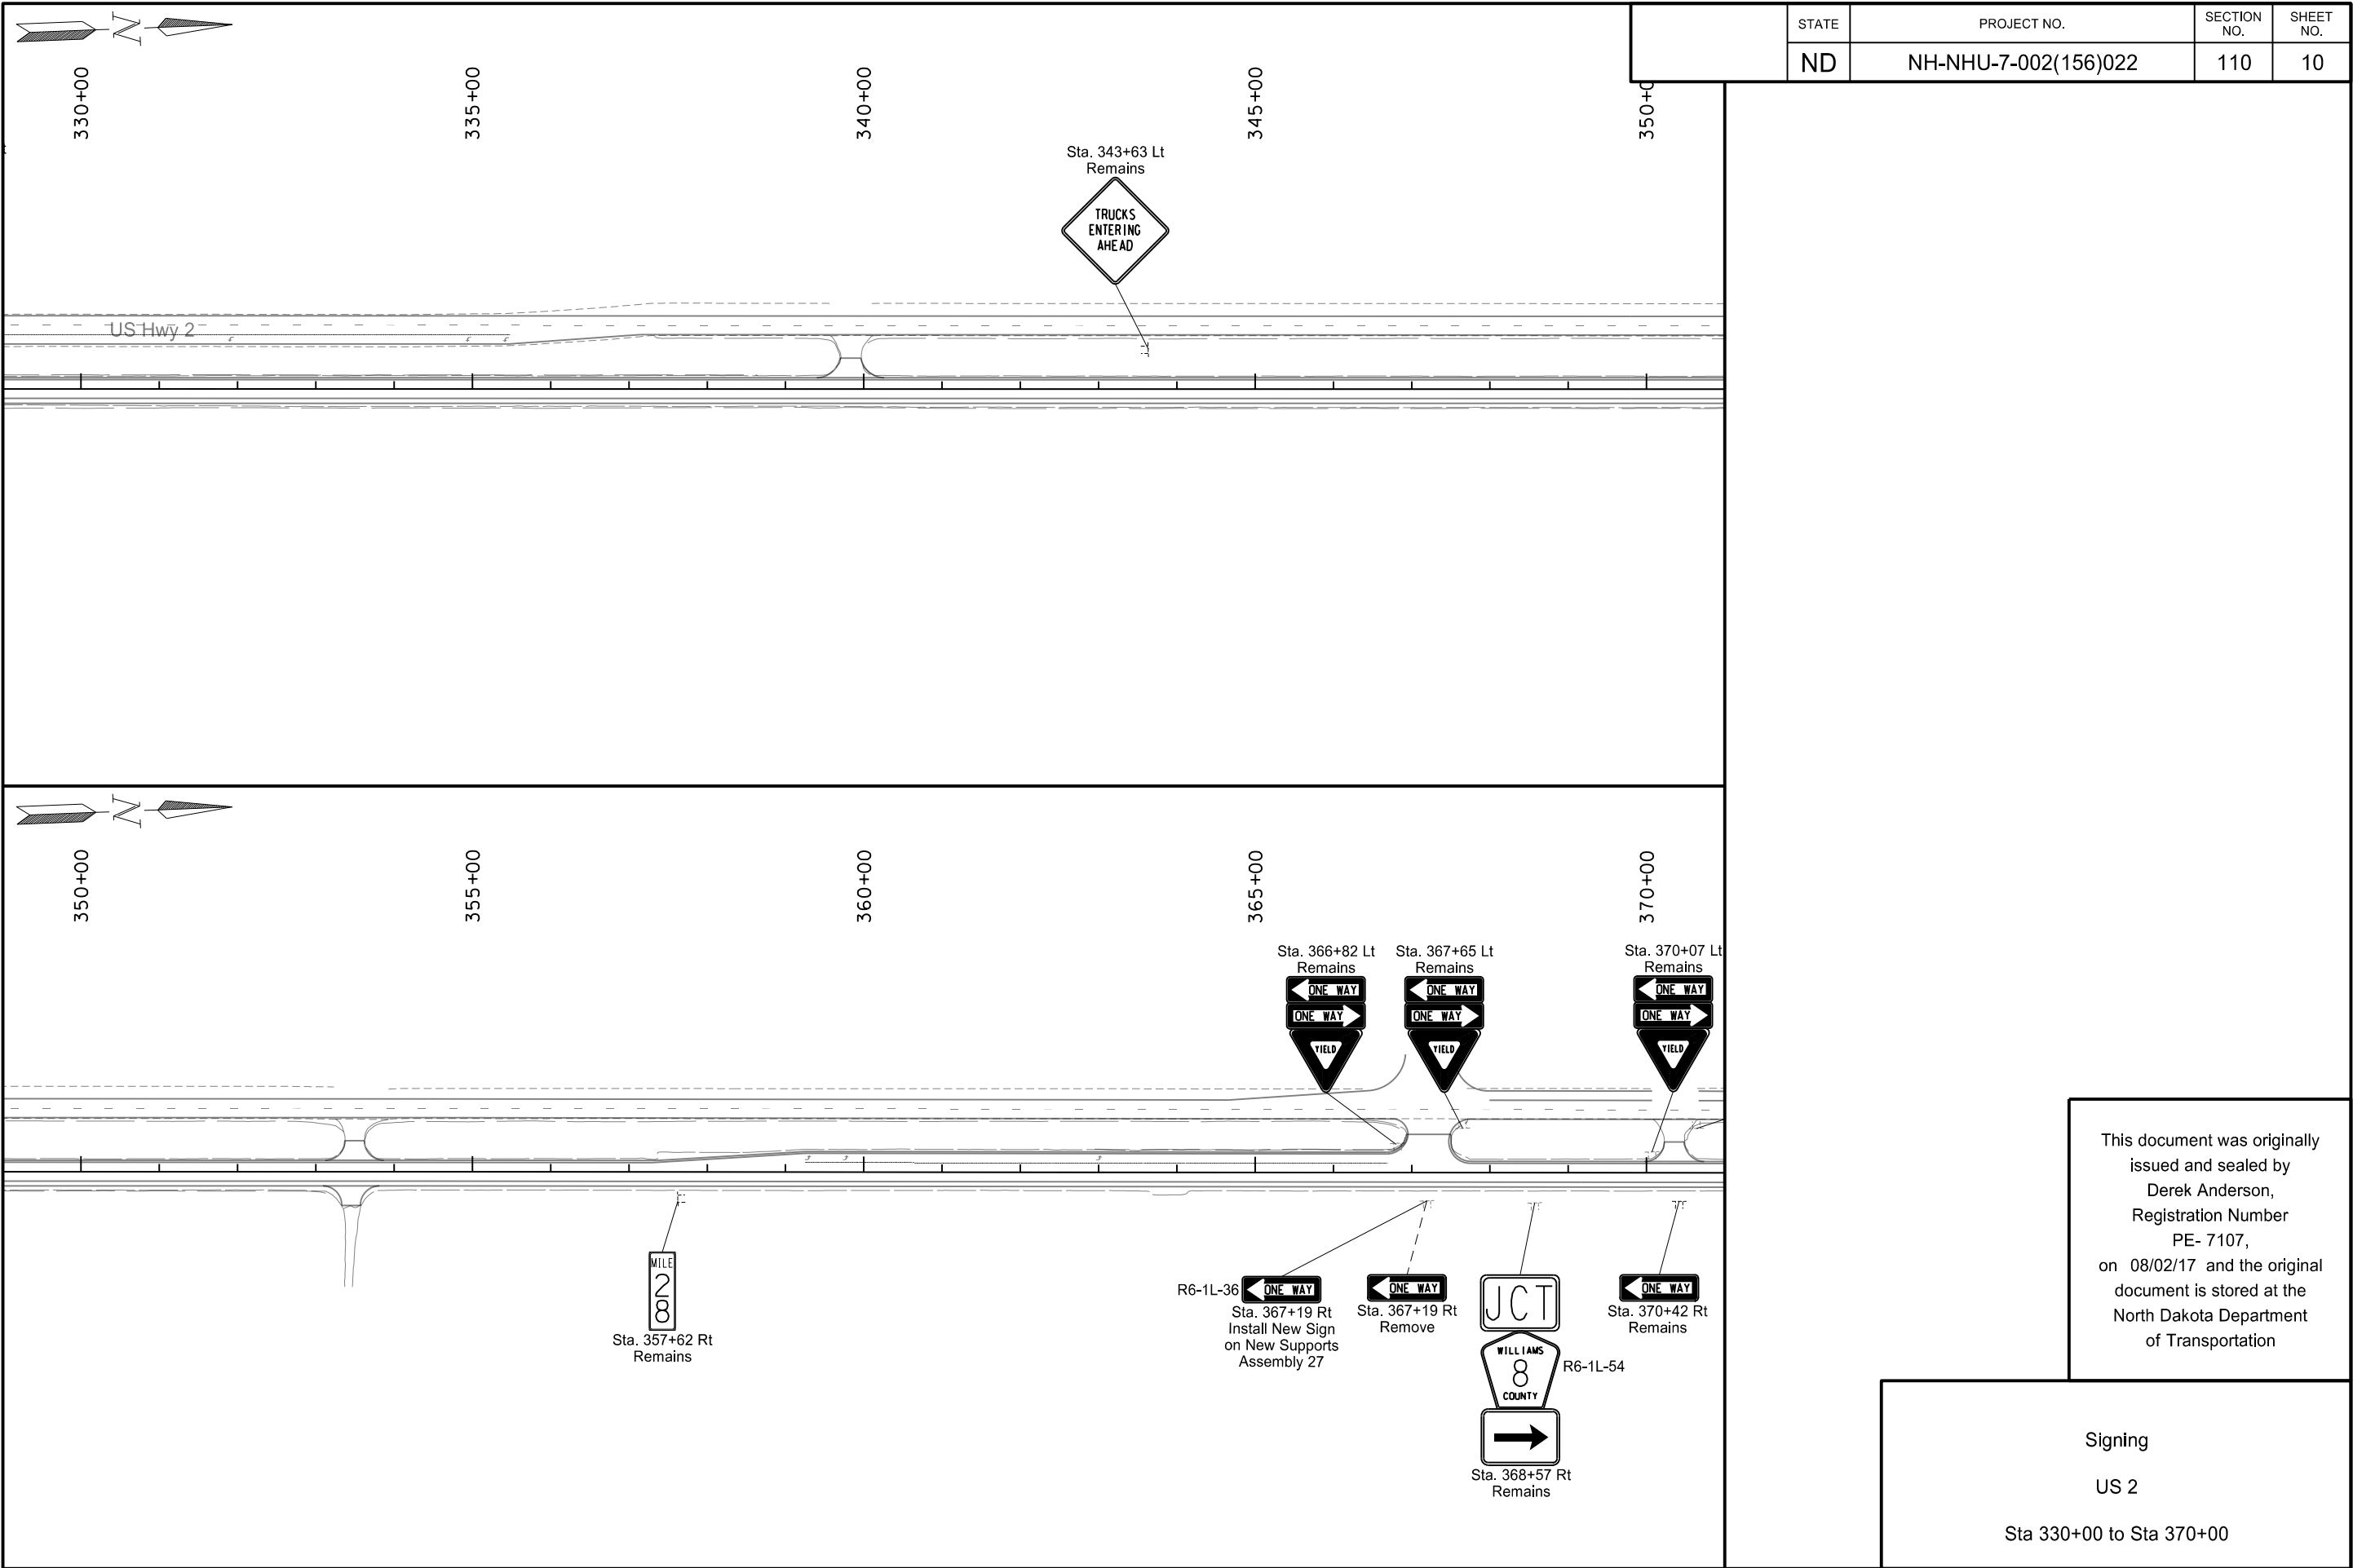

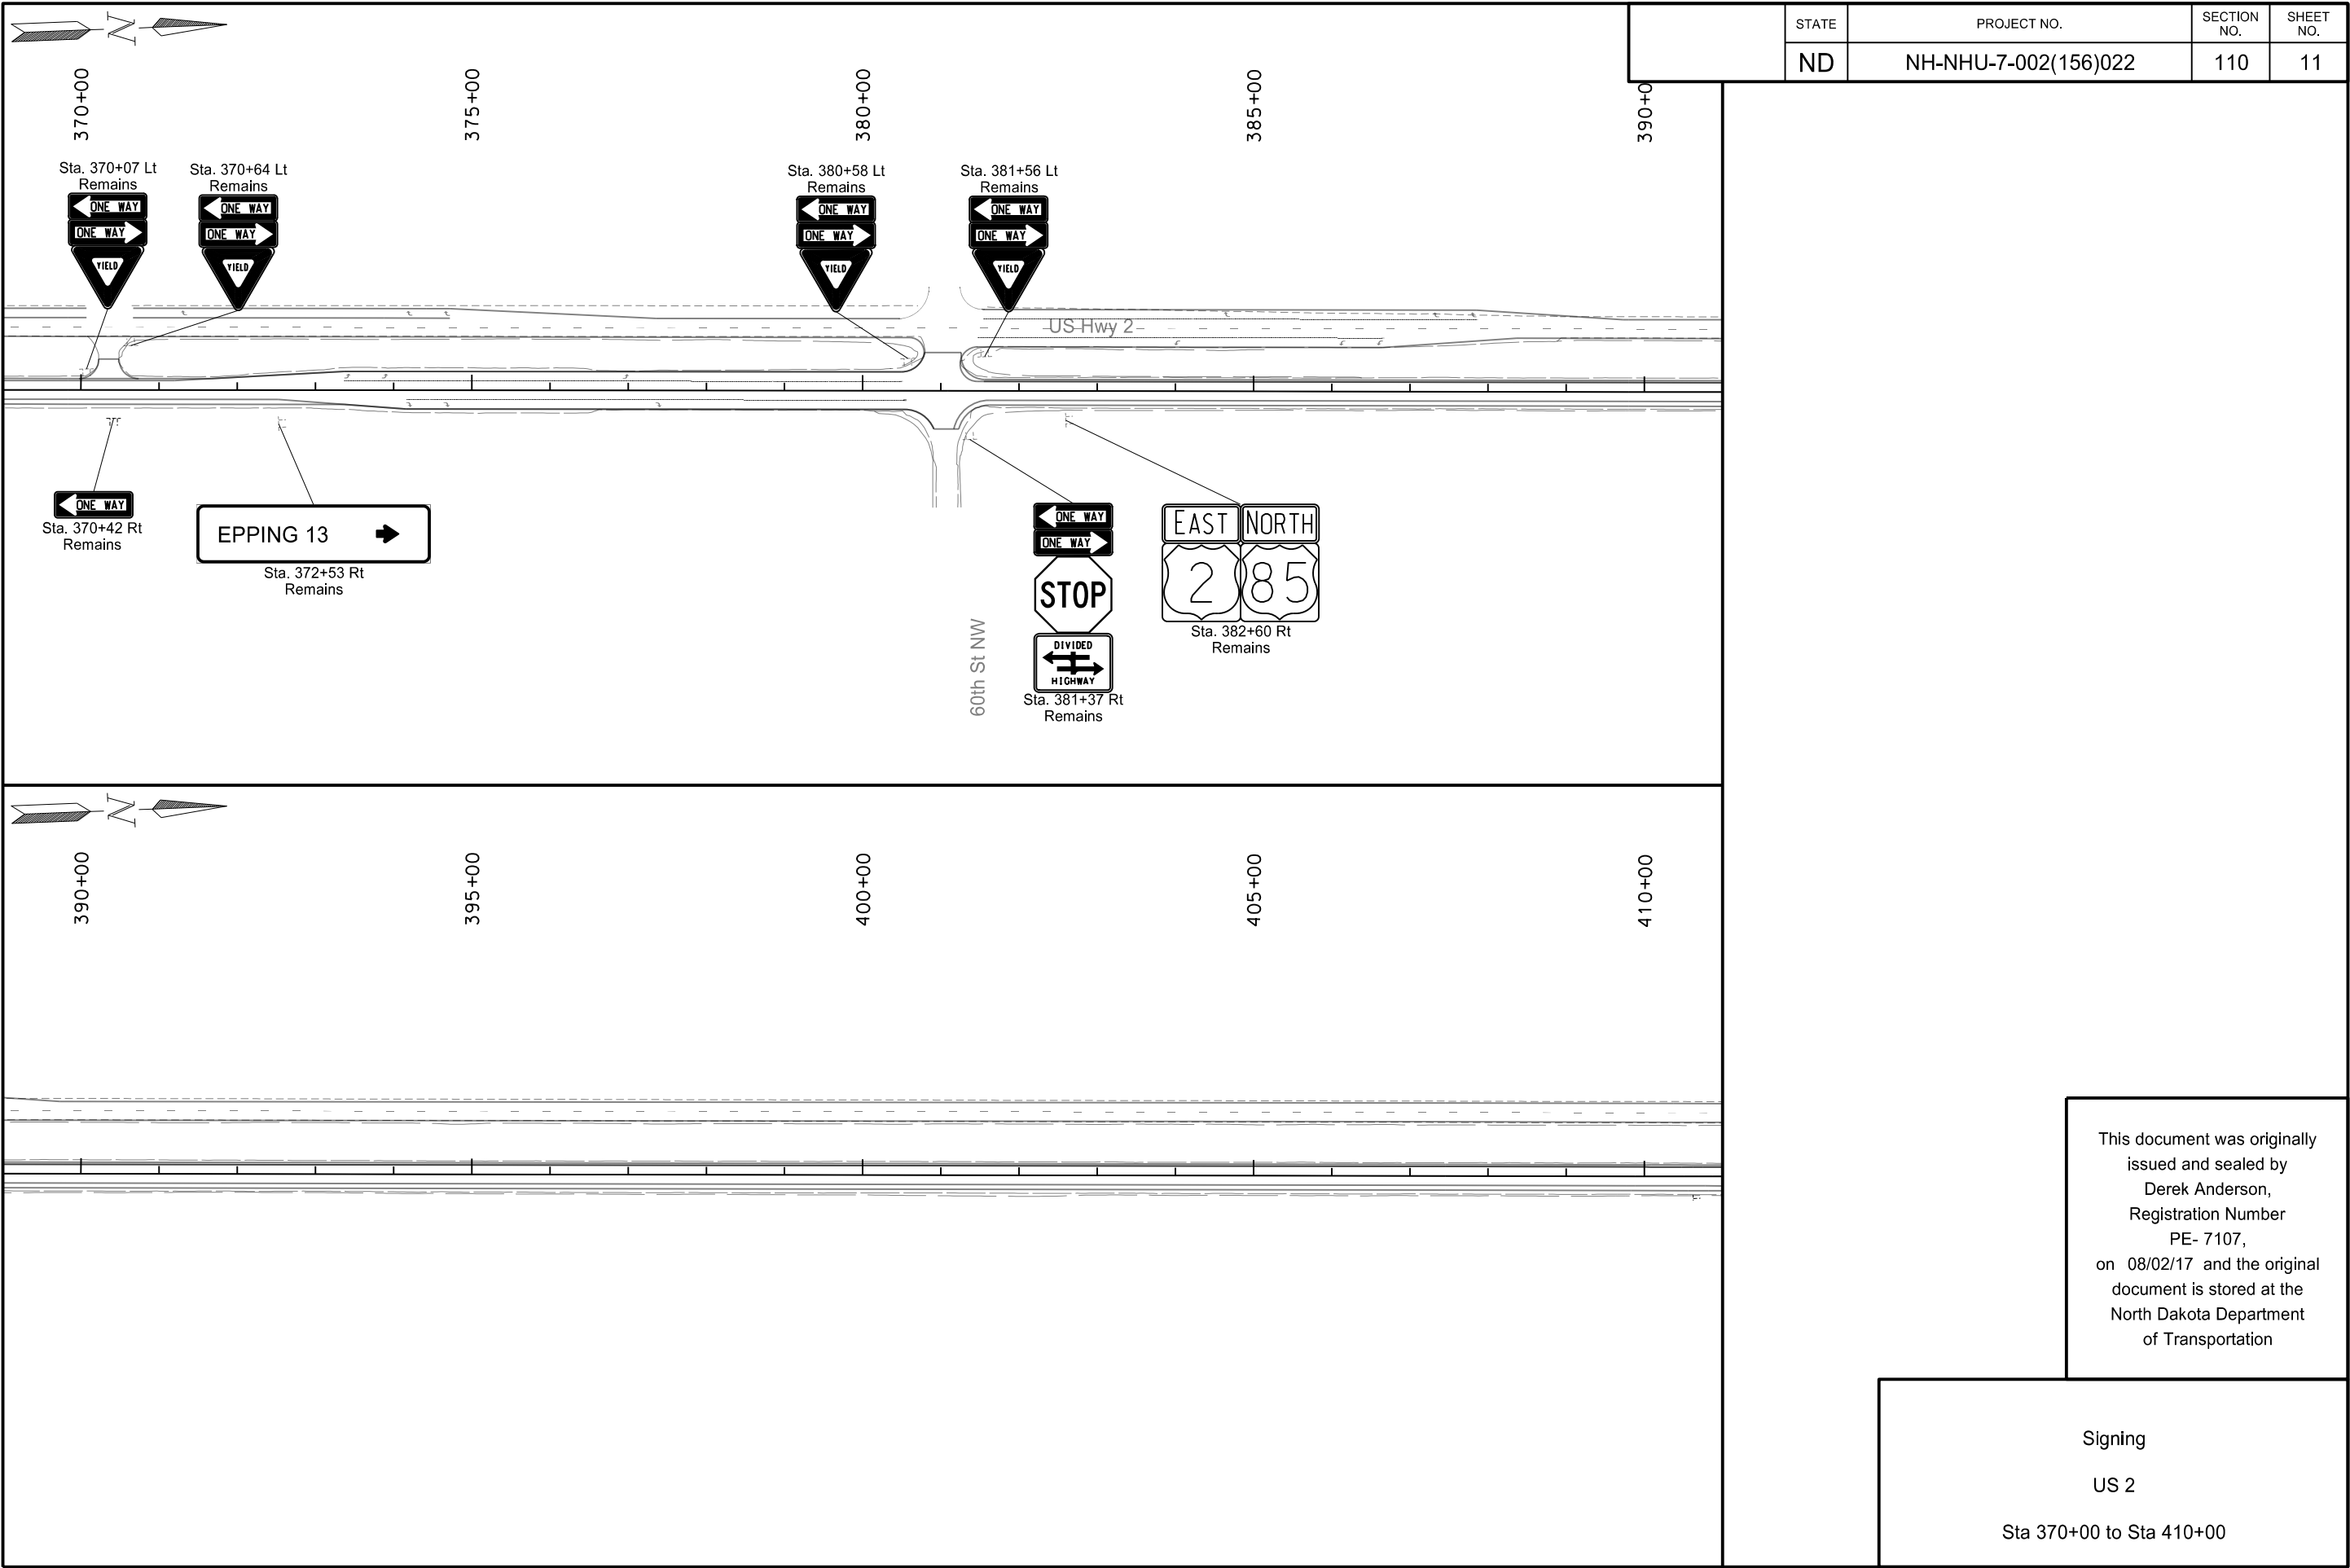

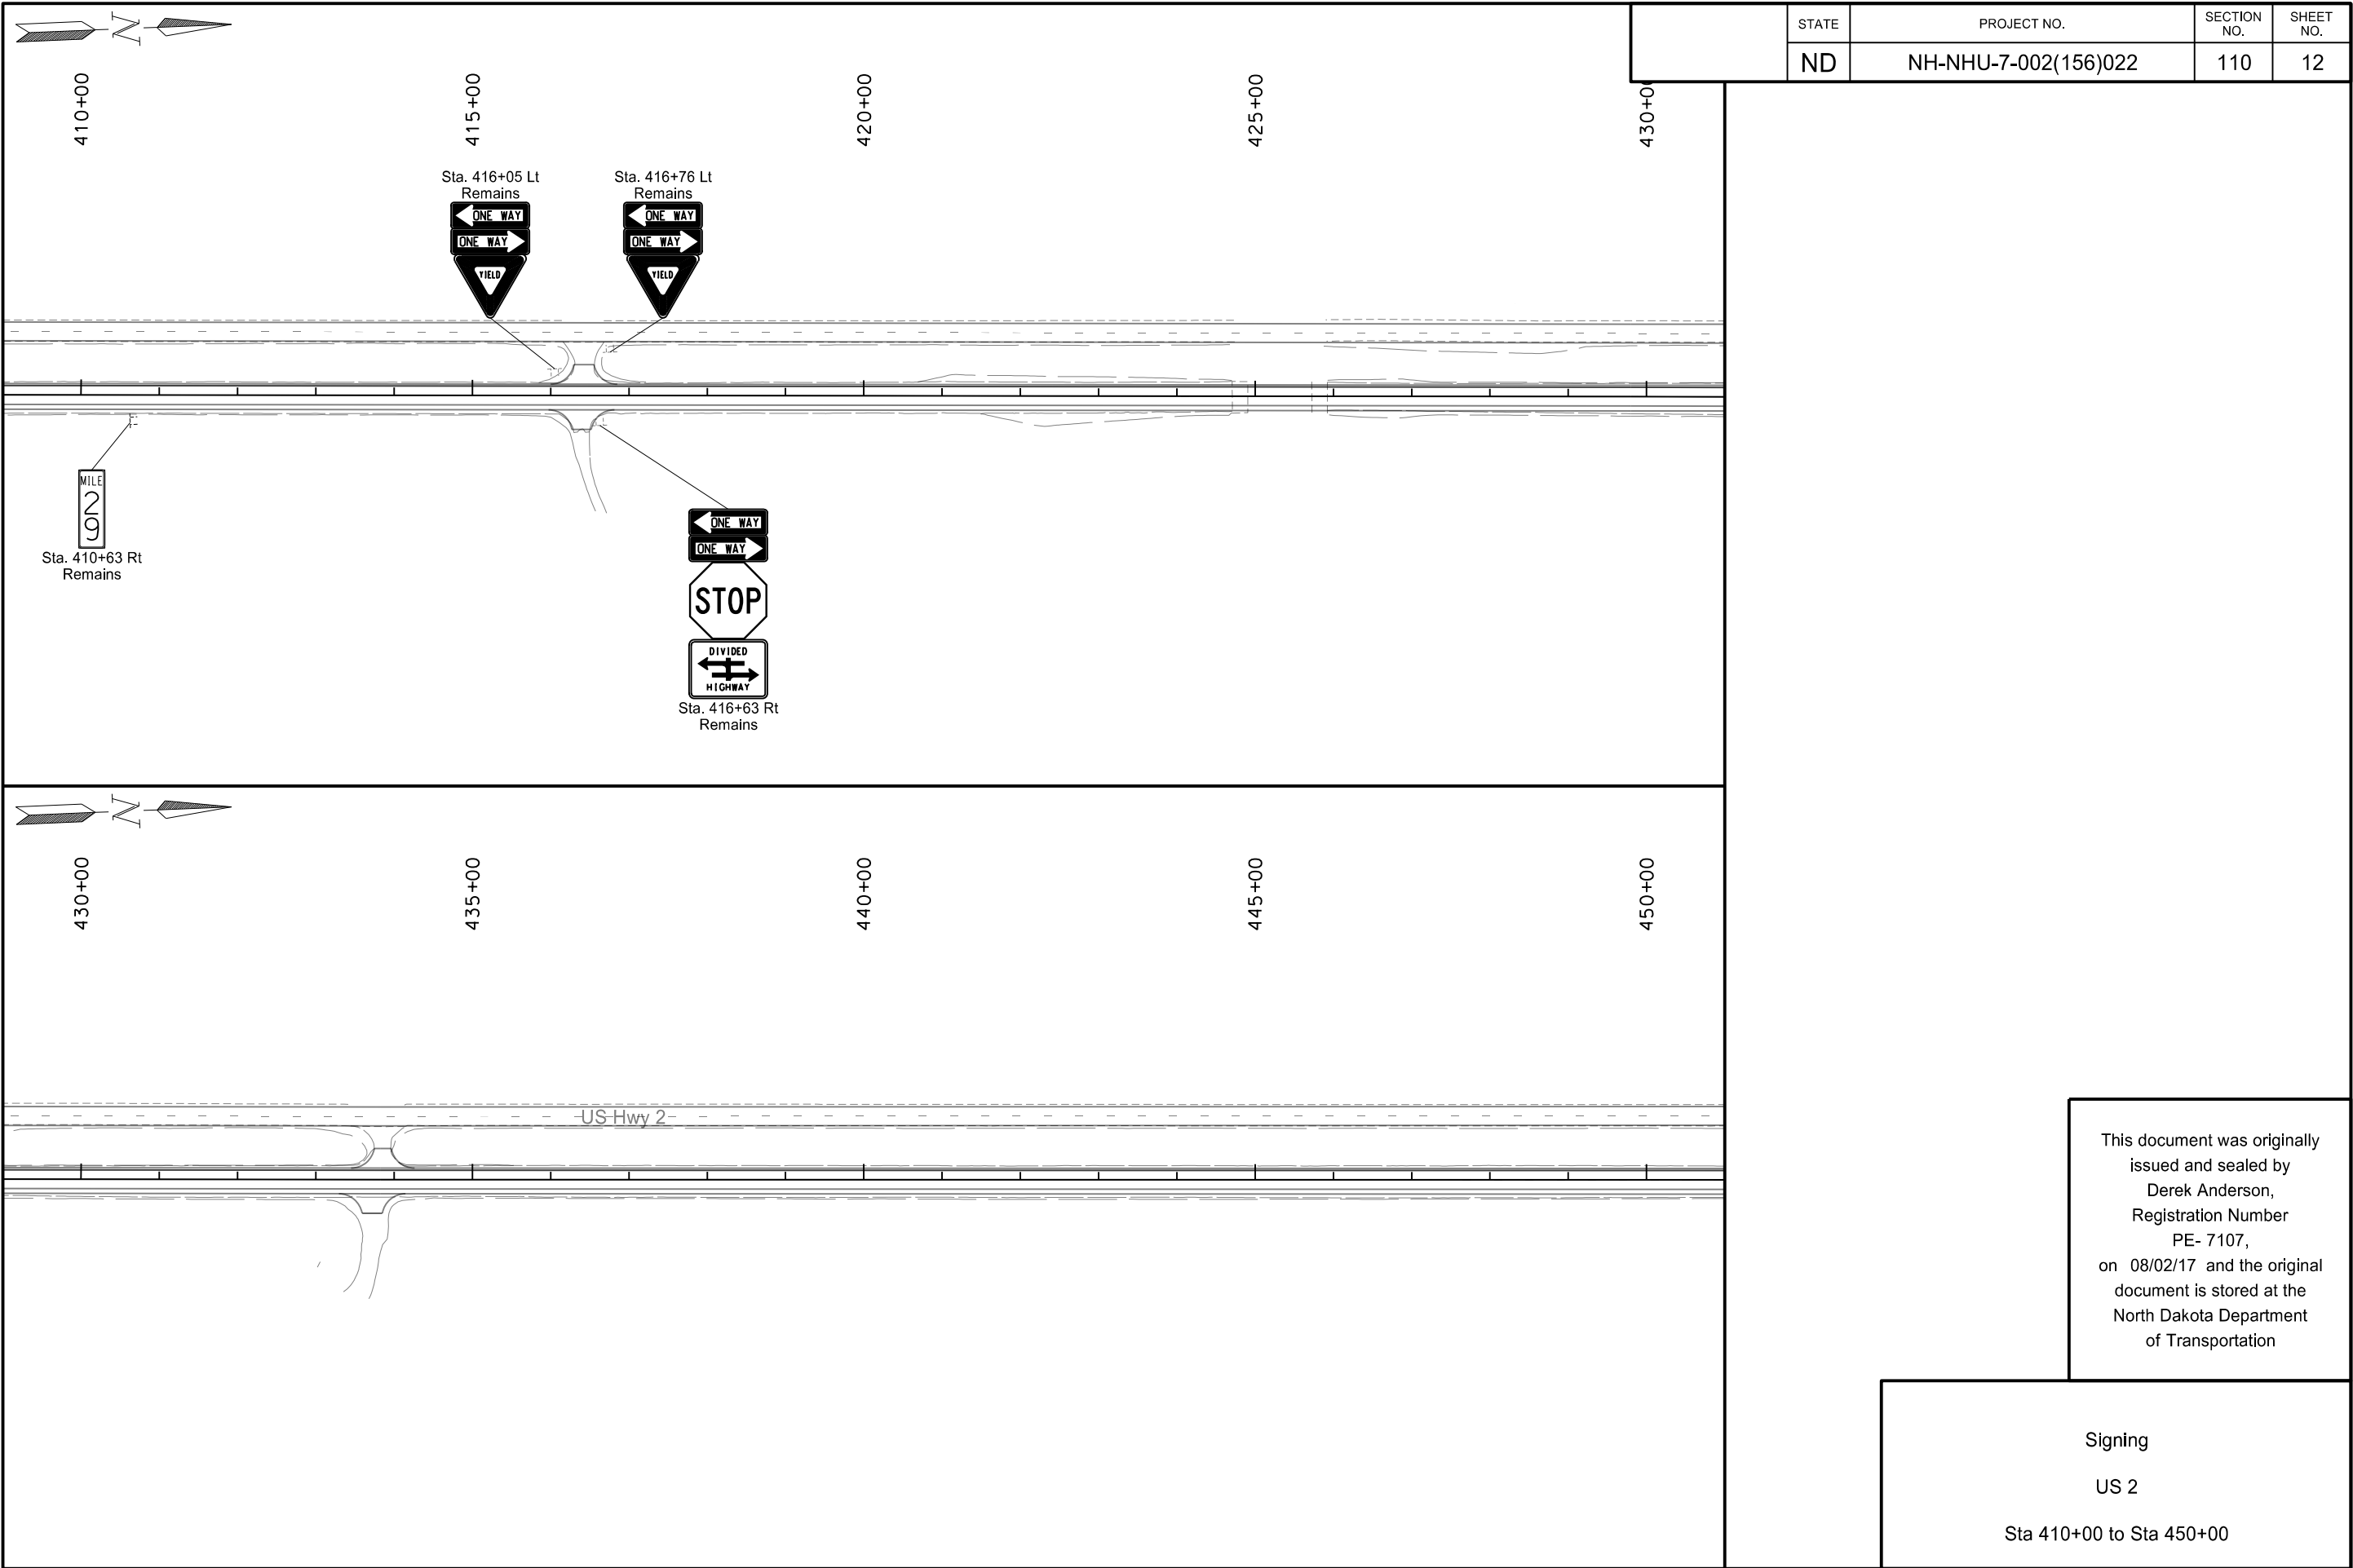


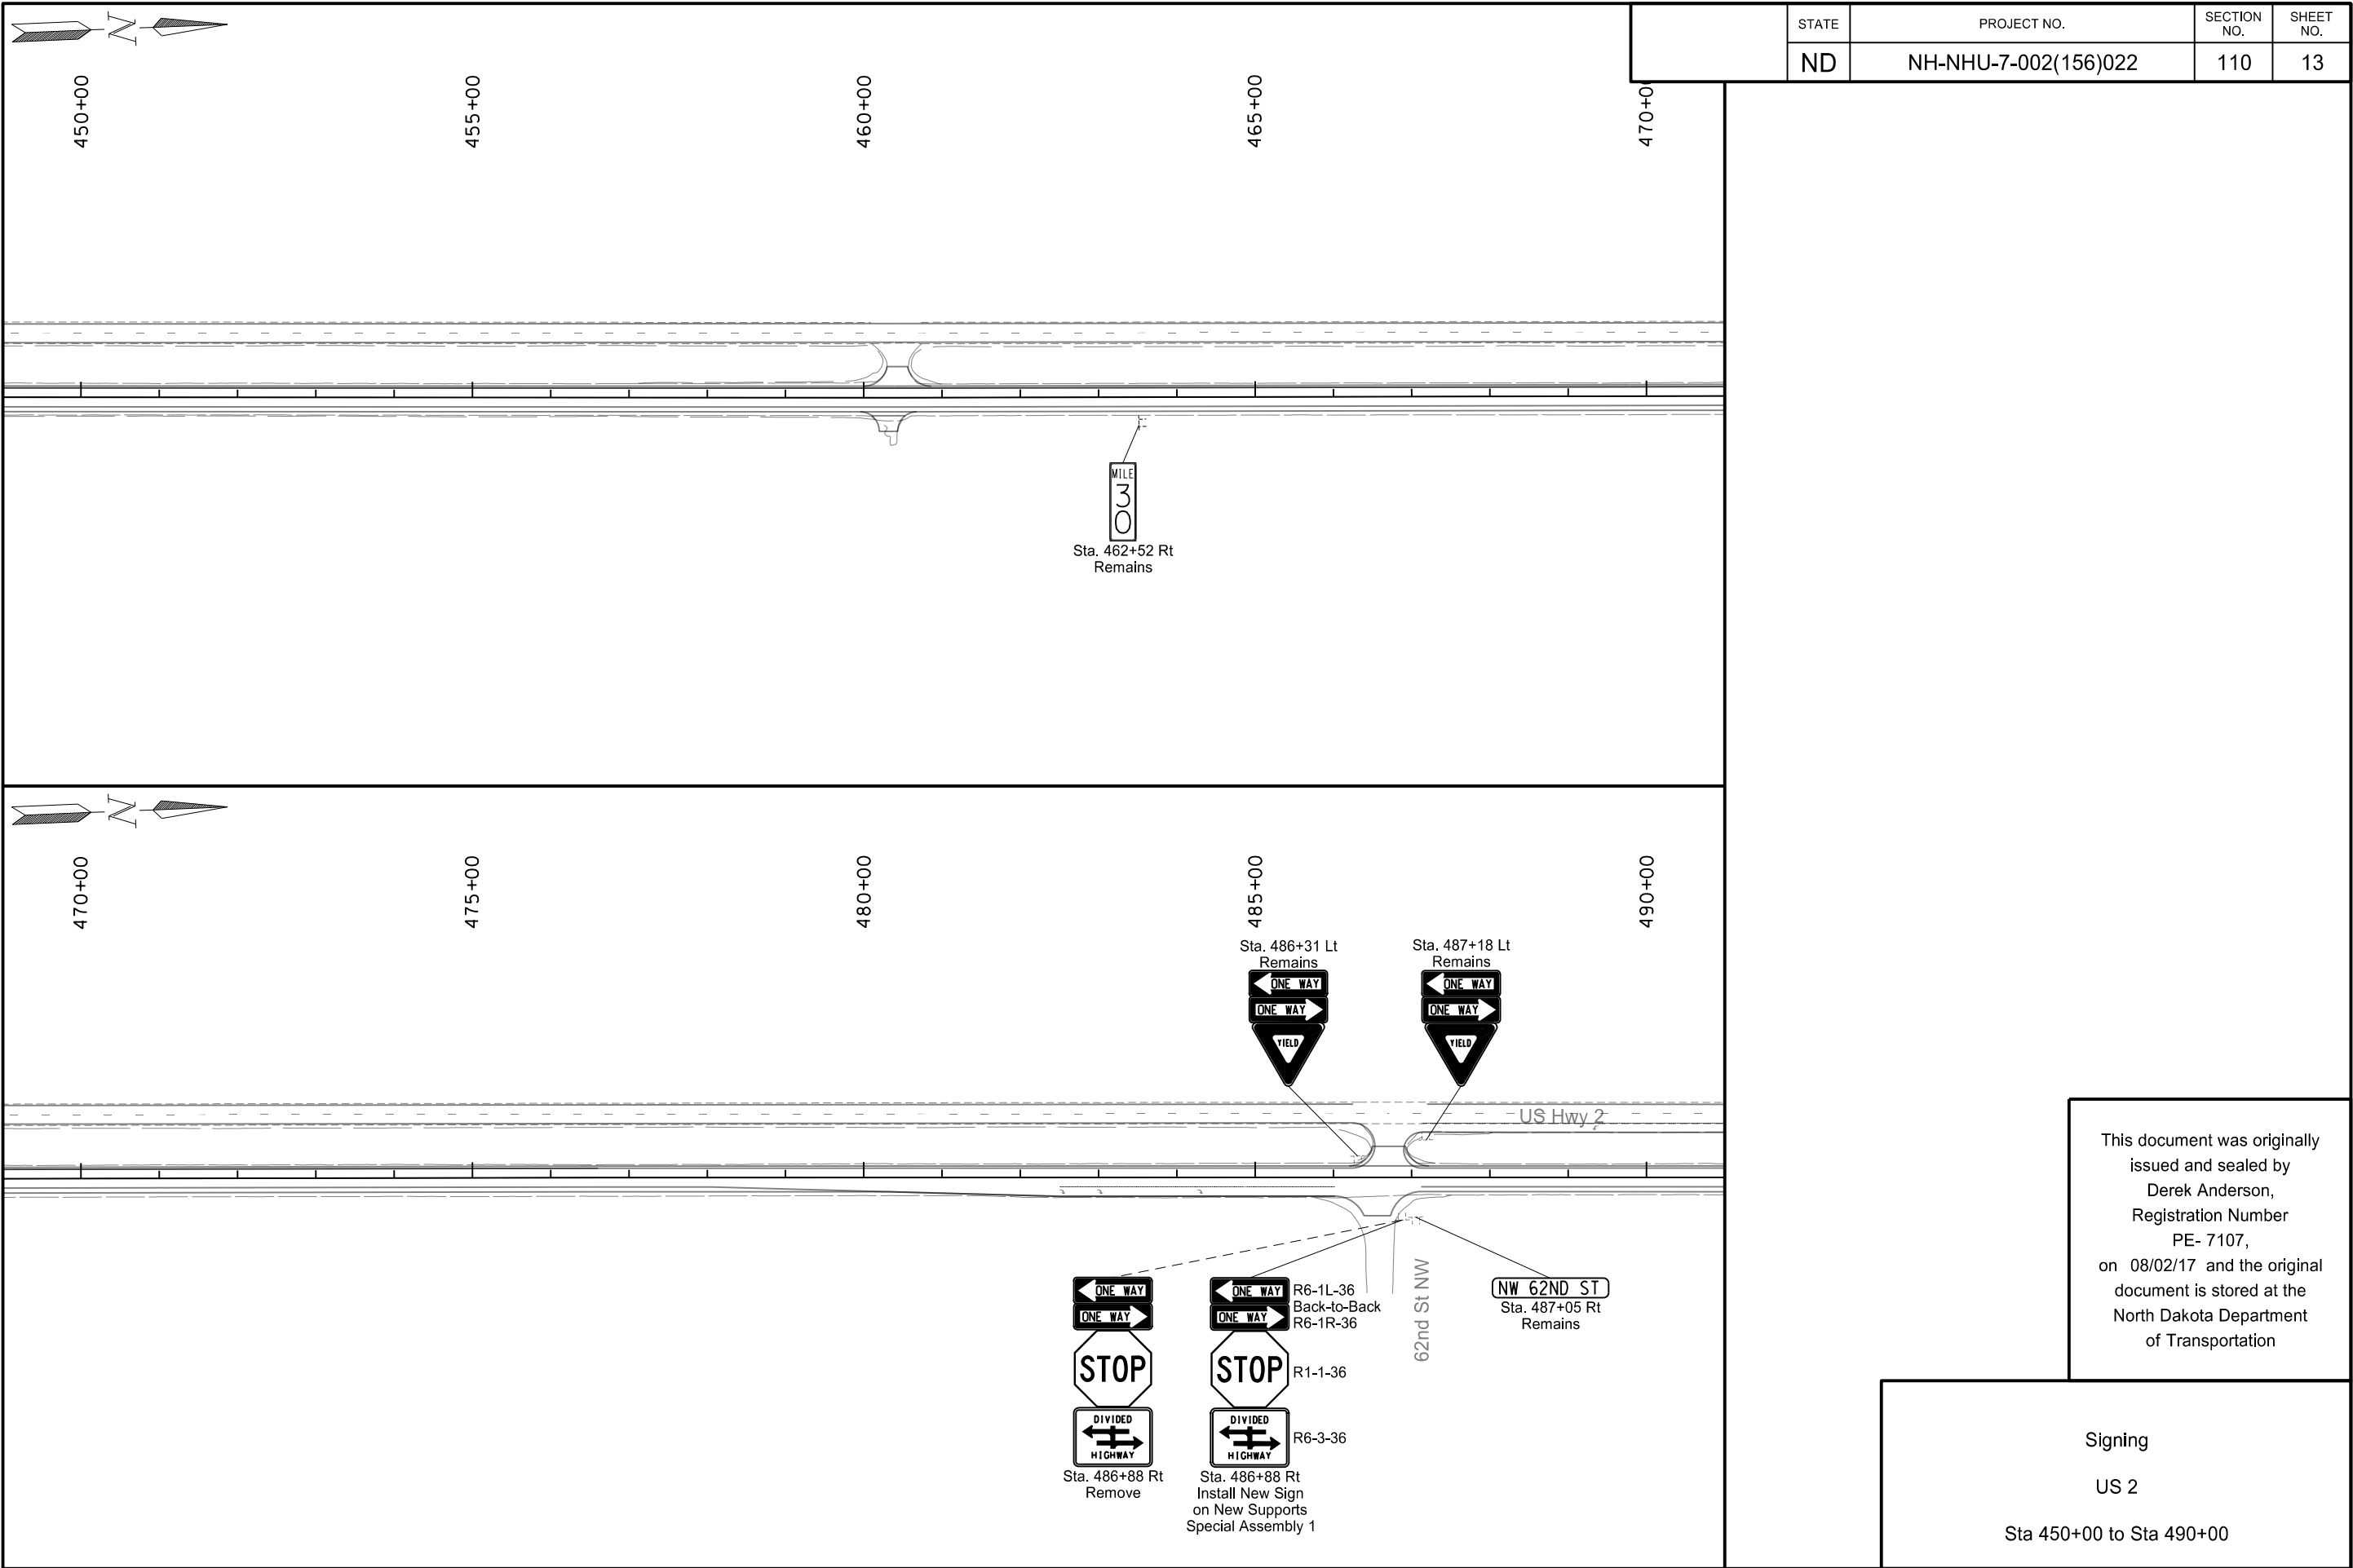


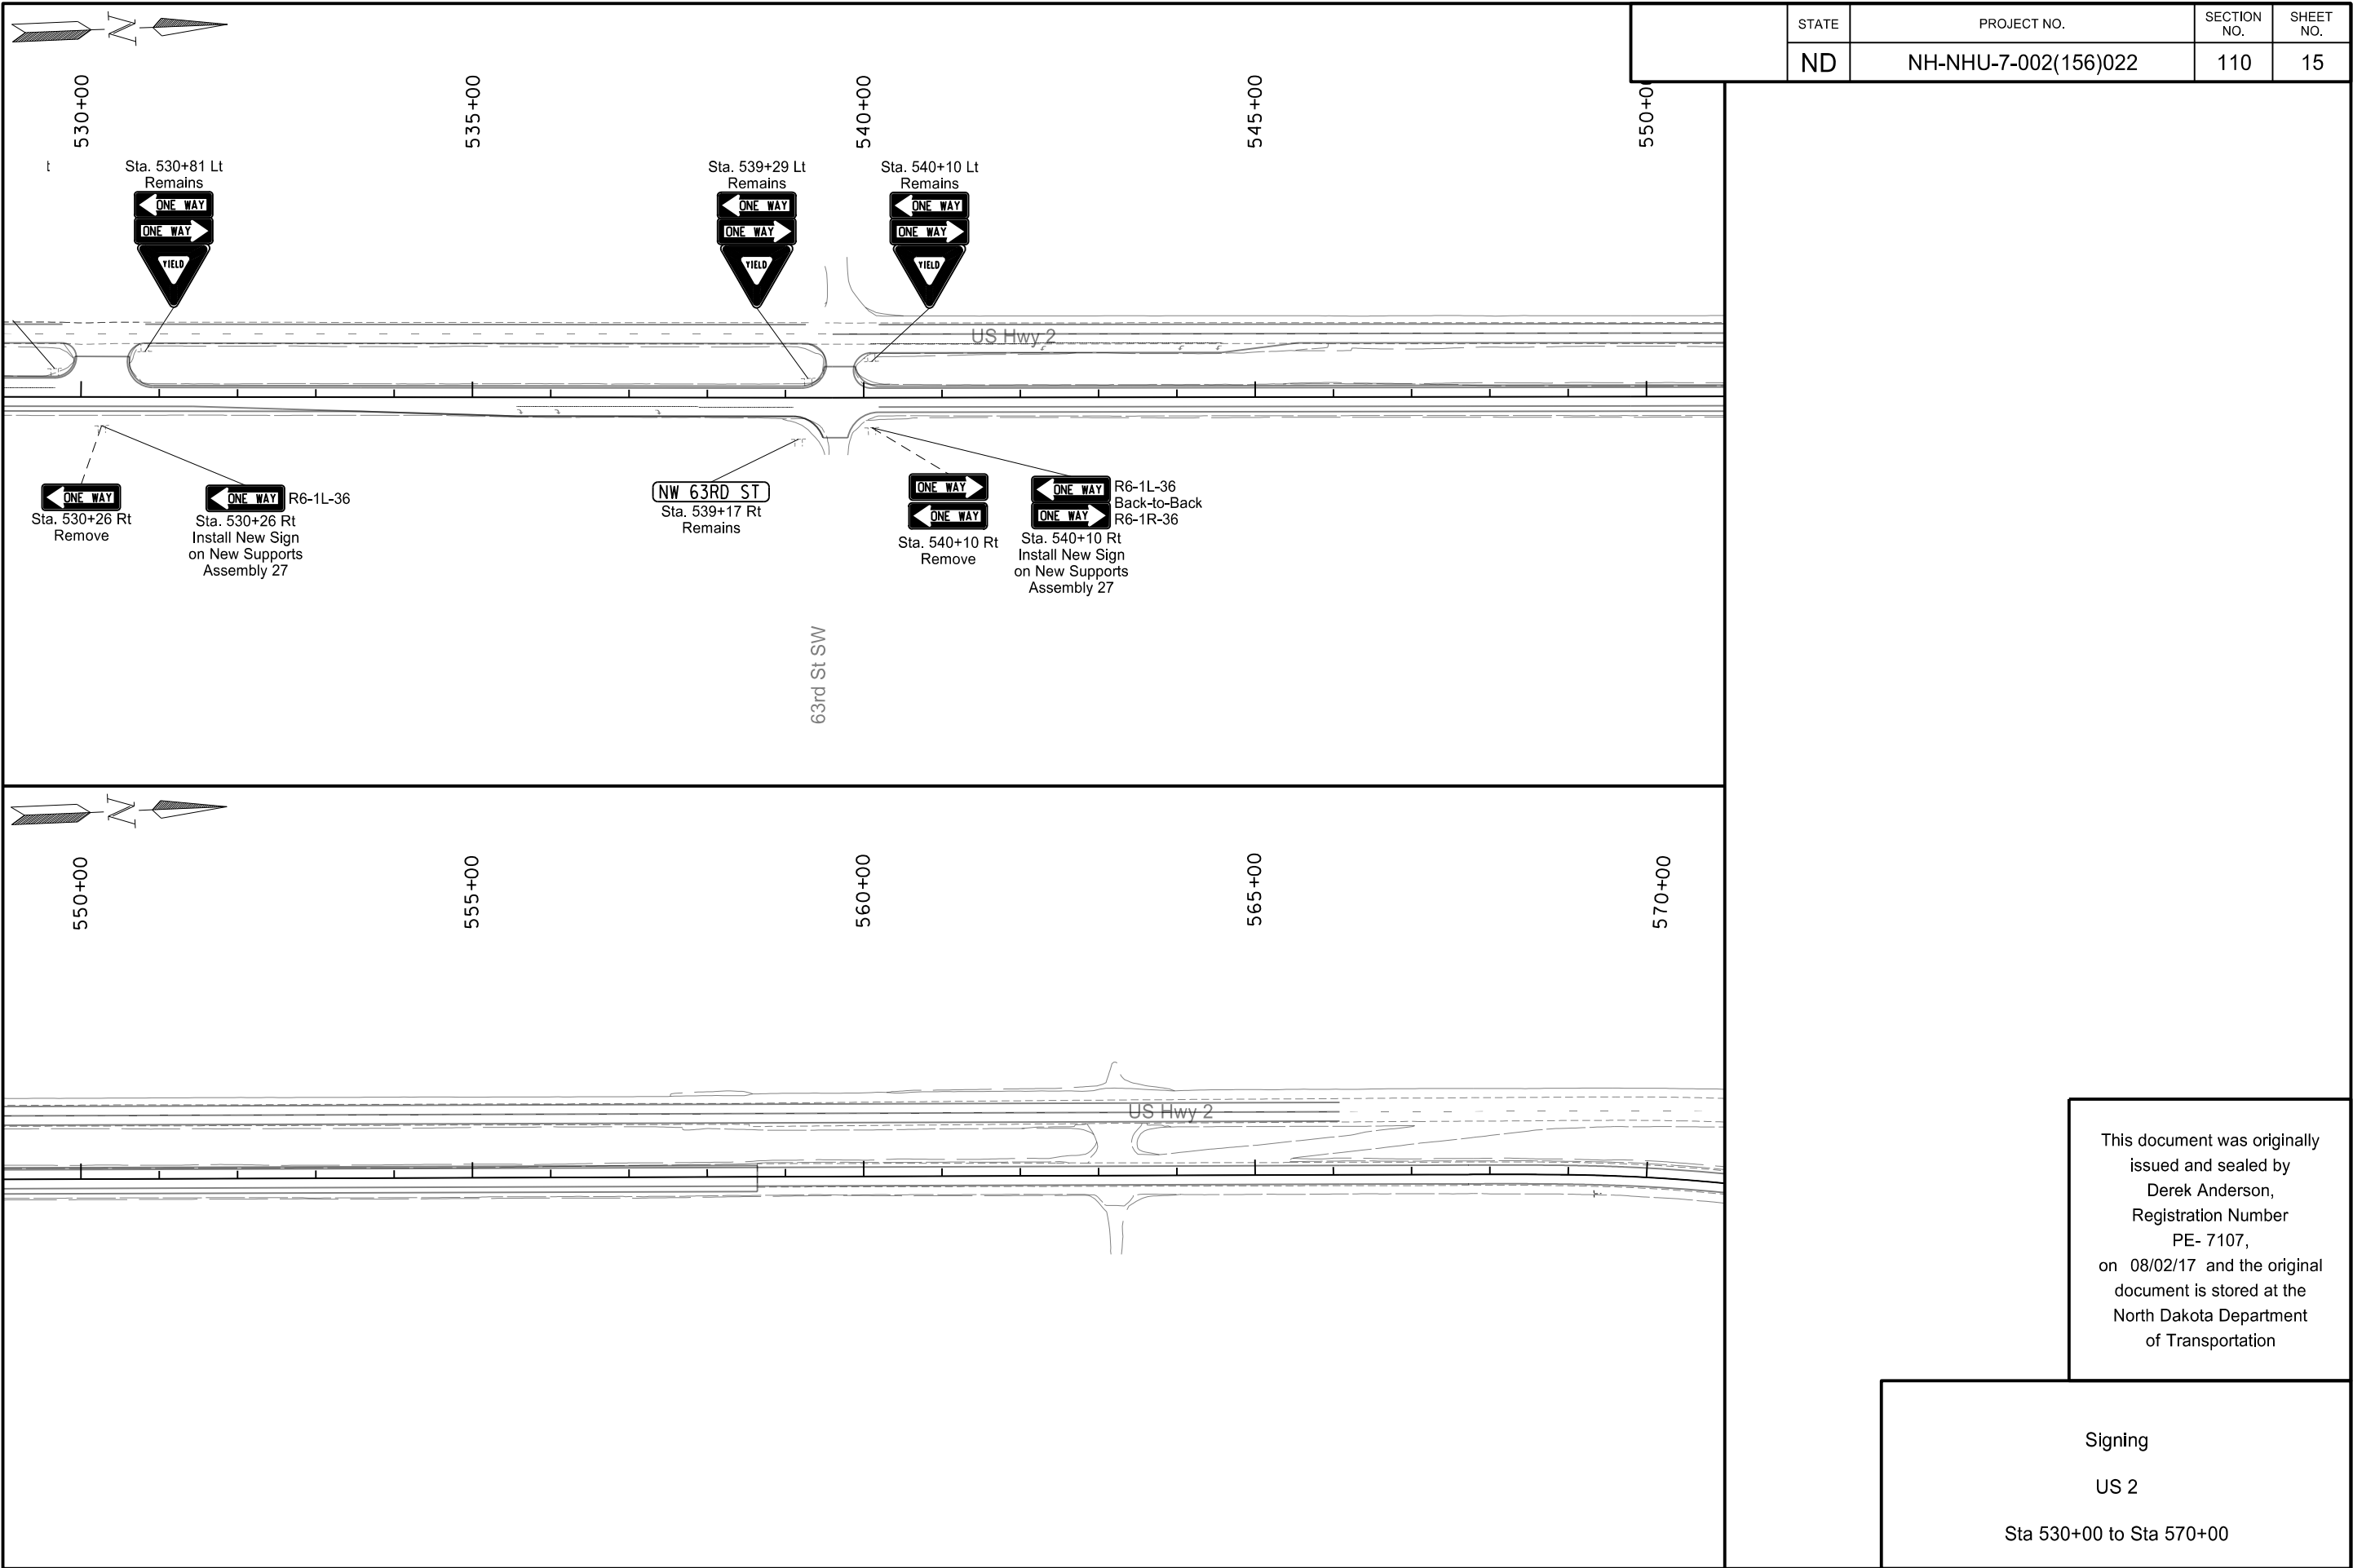

This document was originally issued and sealed by
Derek Anderson,
Registration Number
PE- 7107,
on 08/02/17 and the original document is stored at the
North Dakota Department
of Transportation

Signing
US 2
Sta 530+00 to Sta 570+00

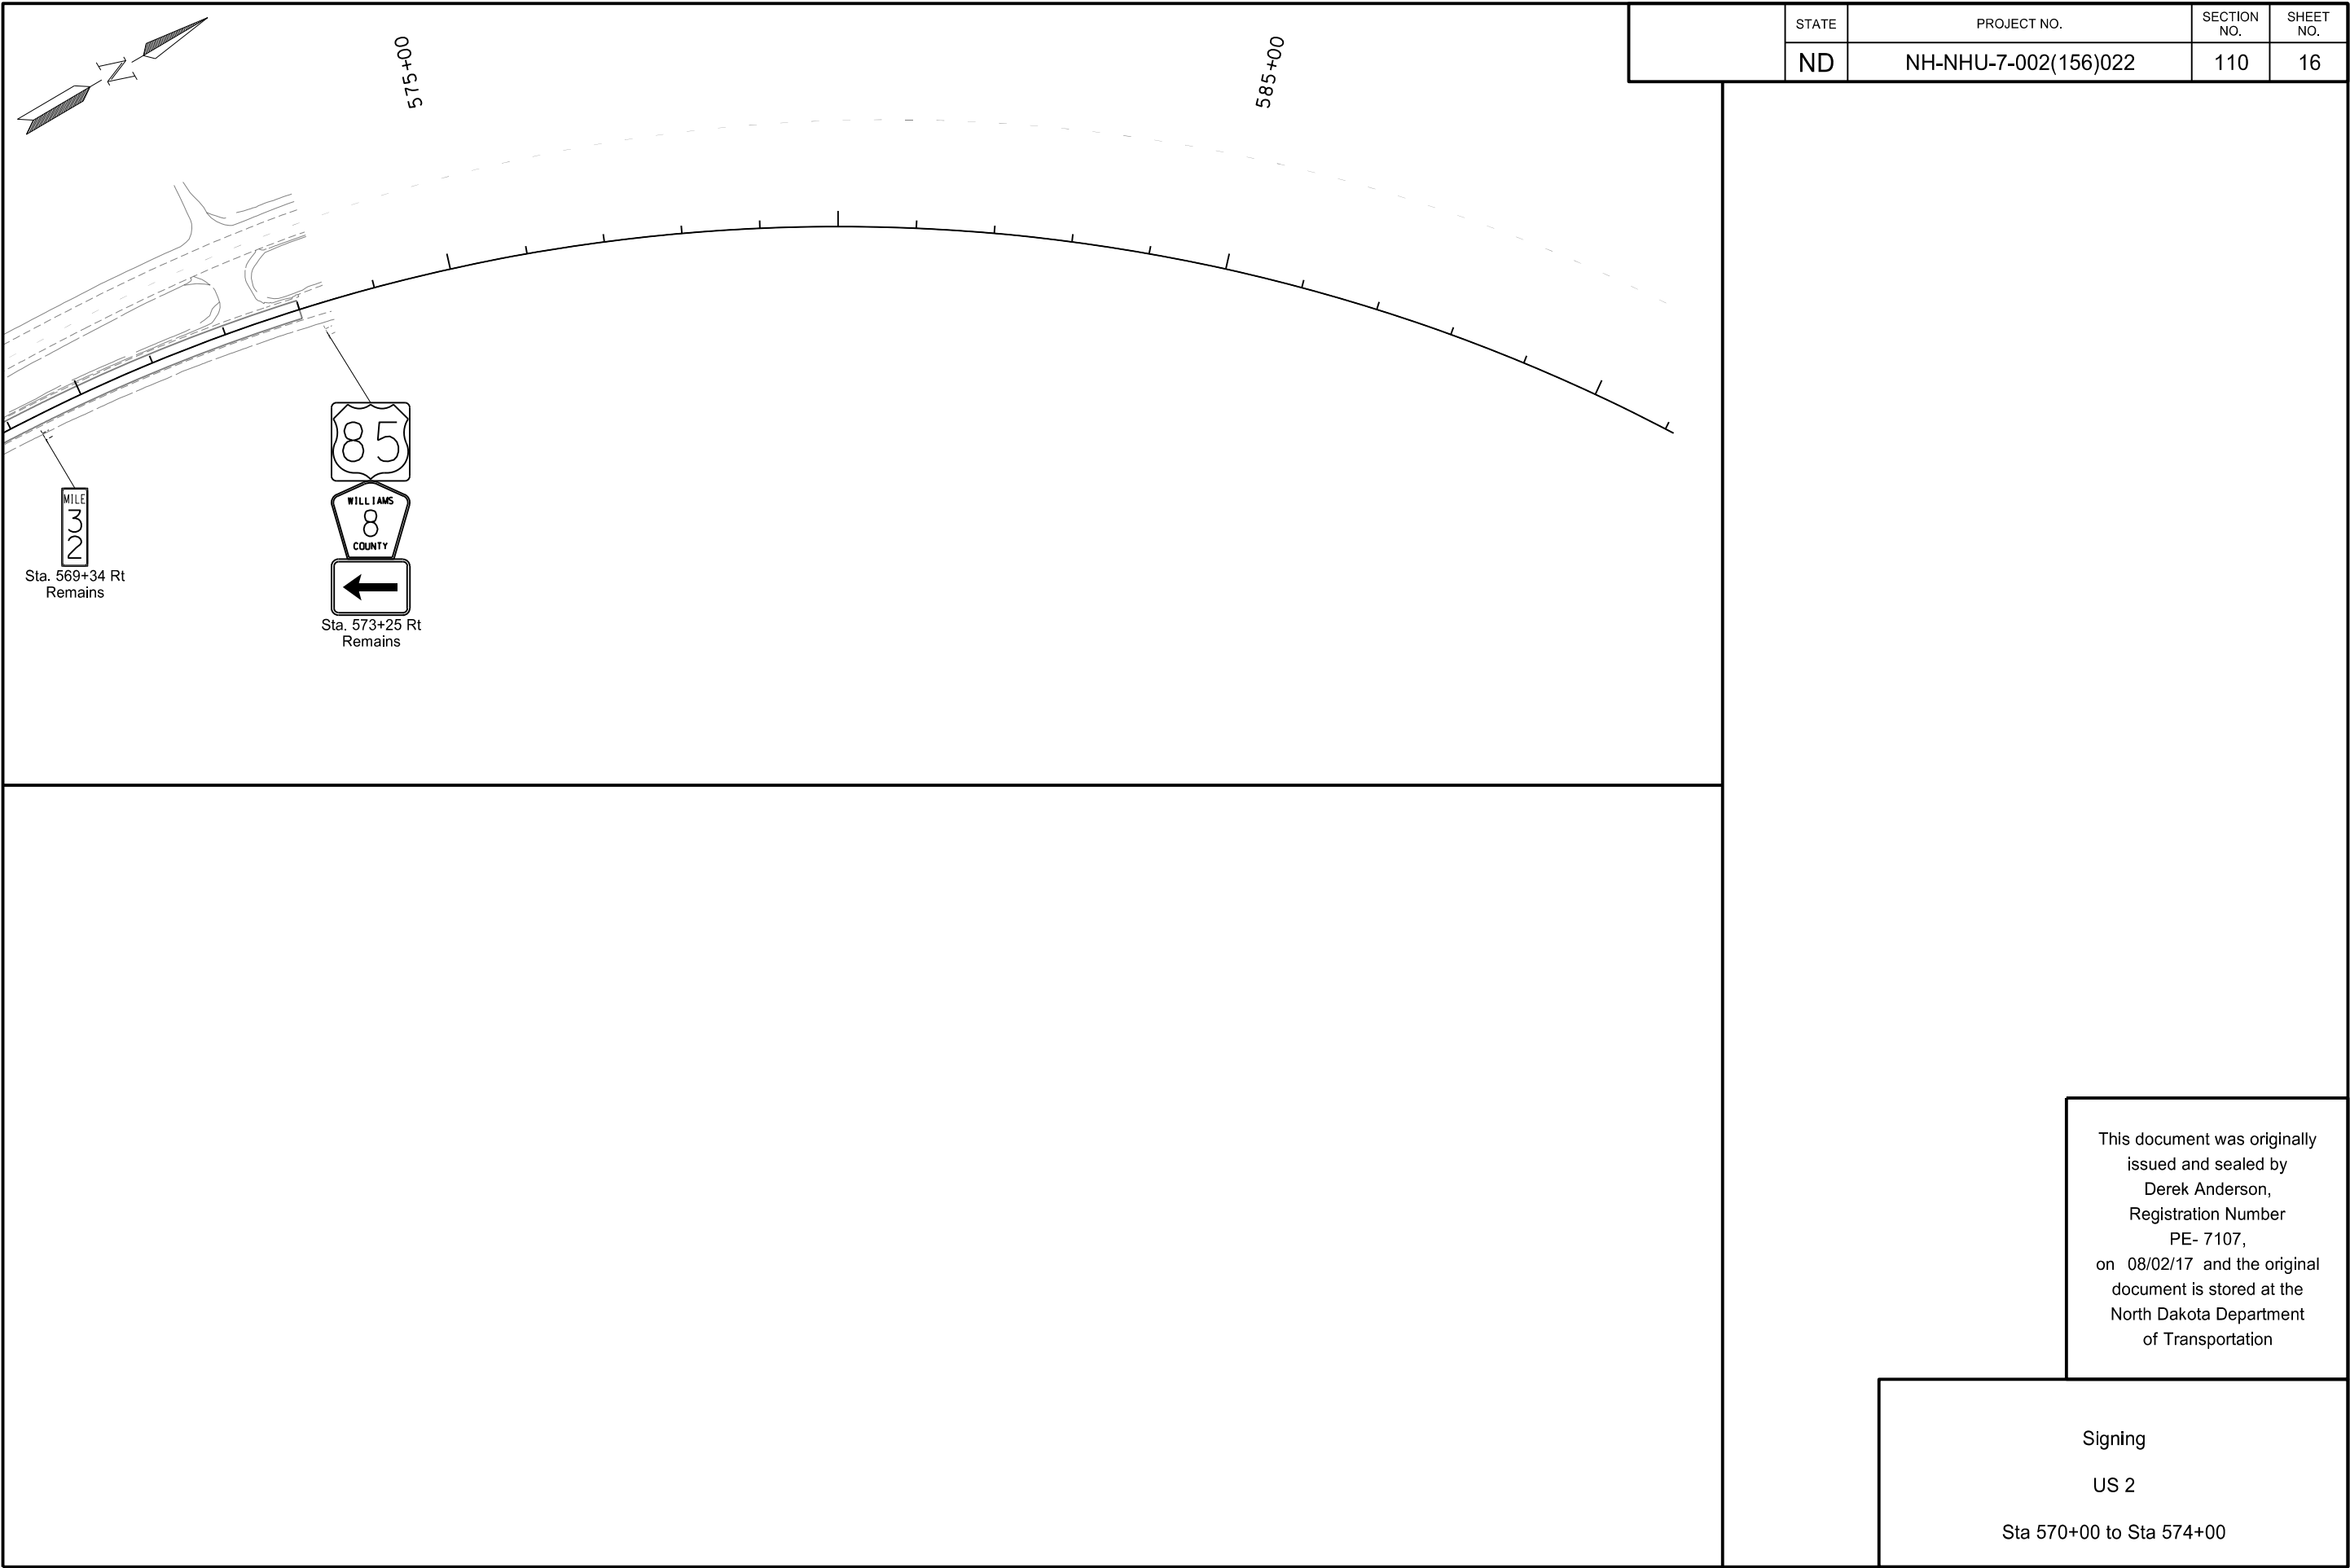

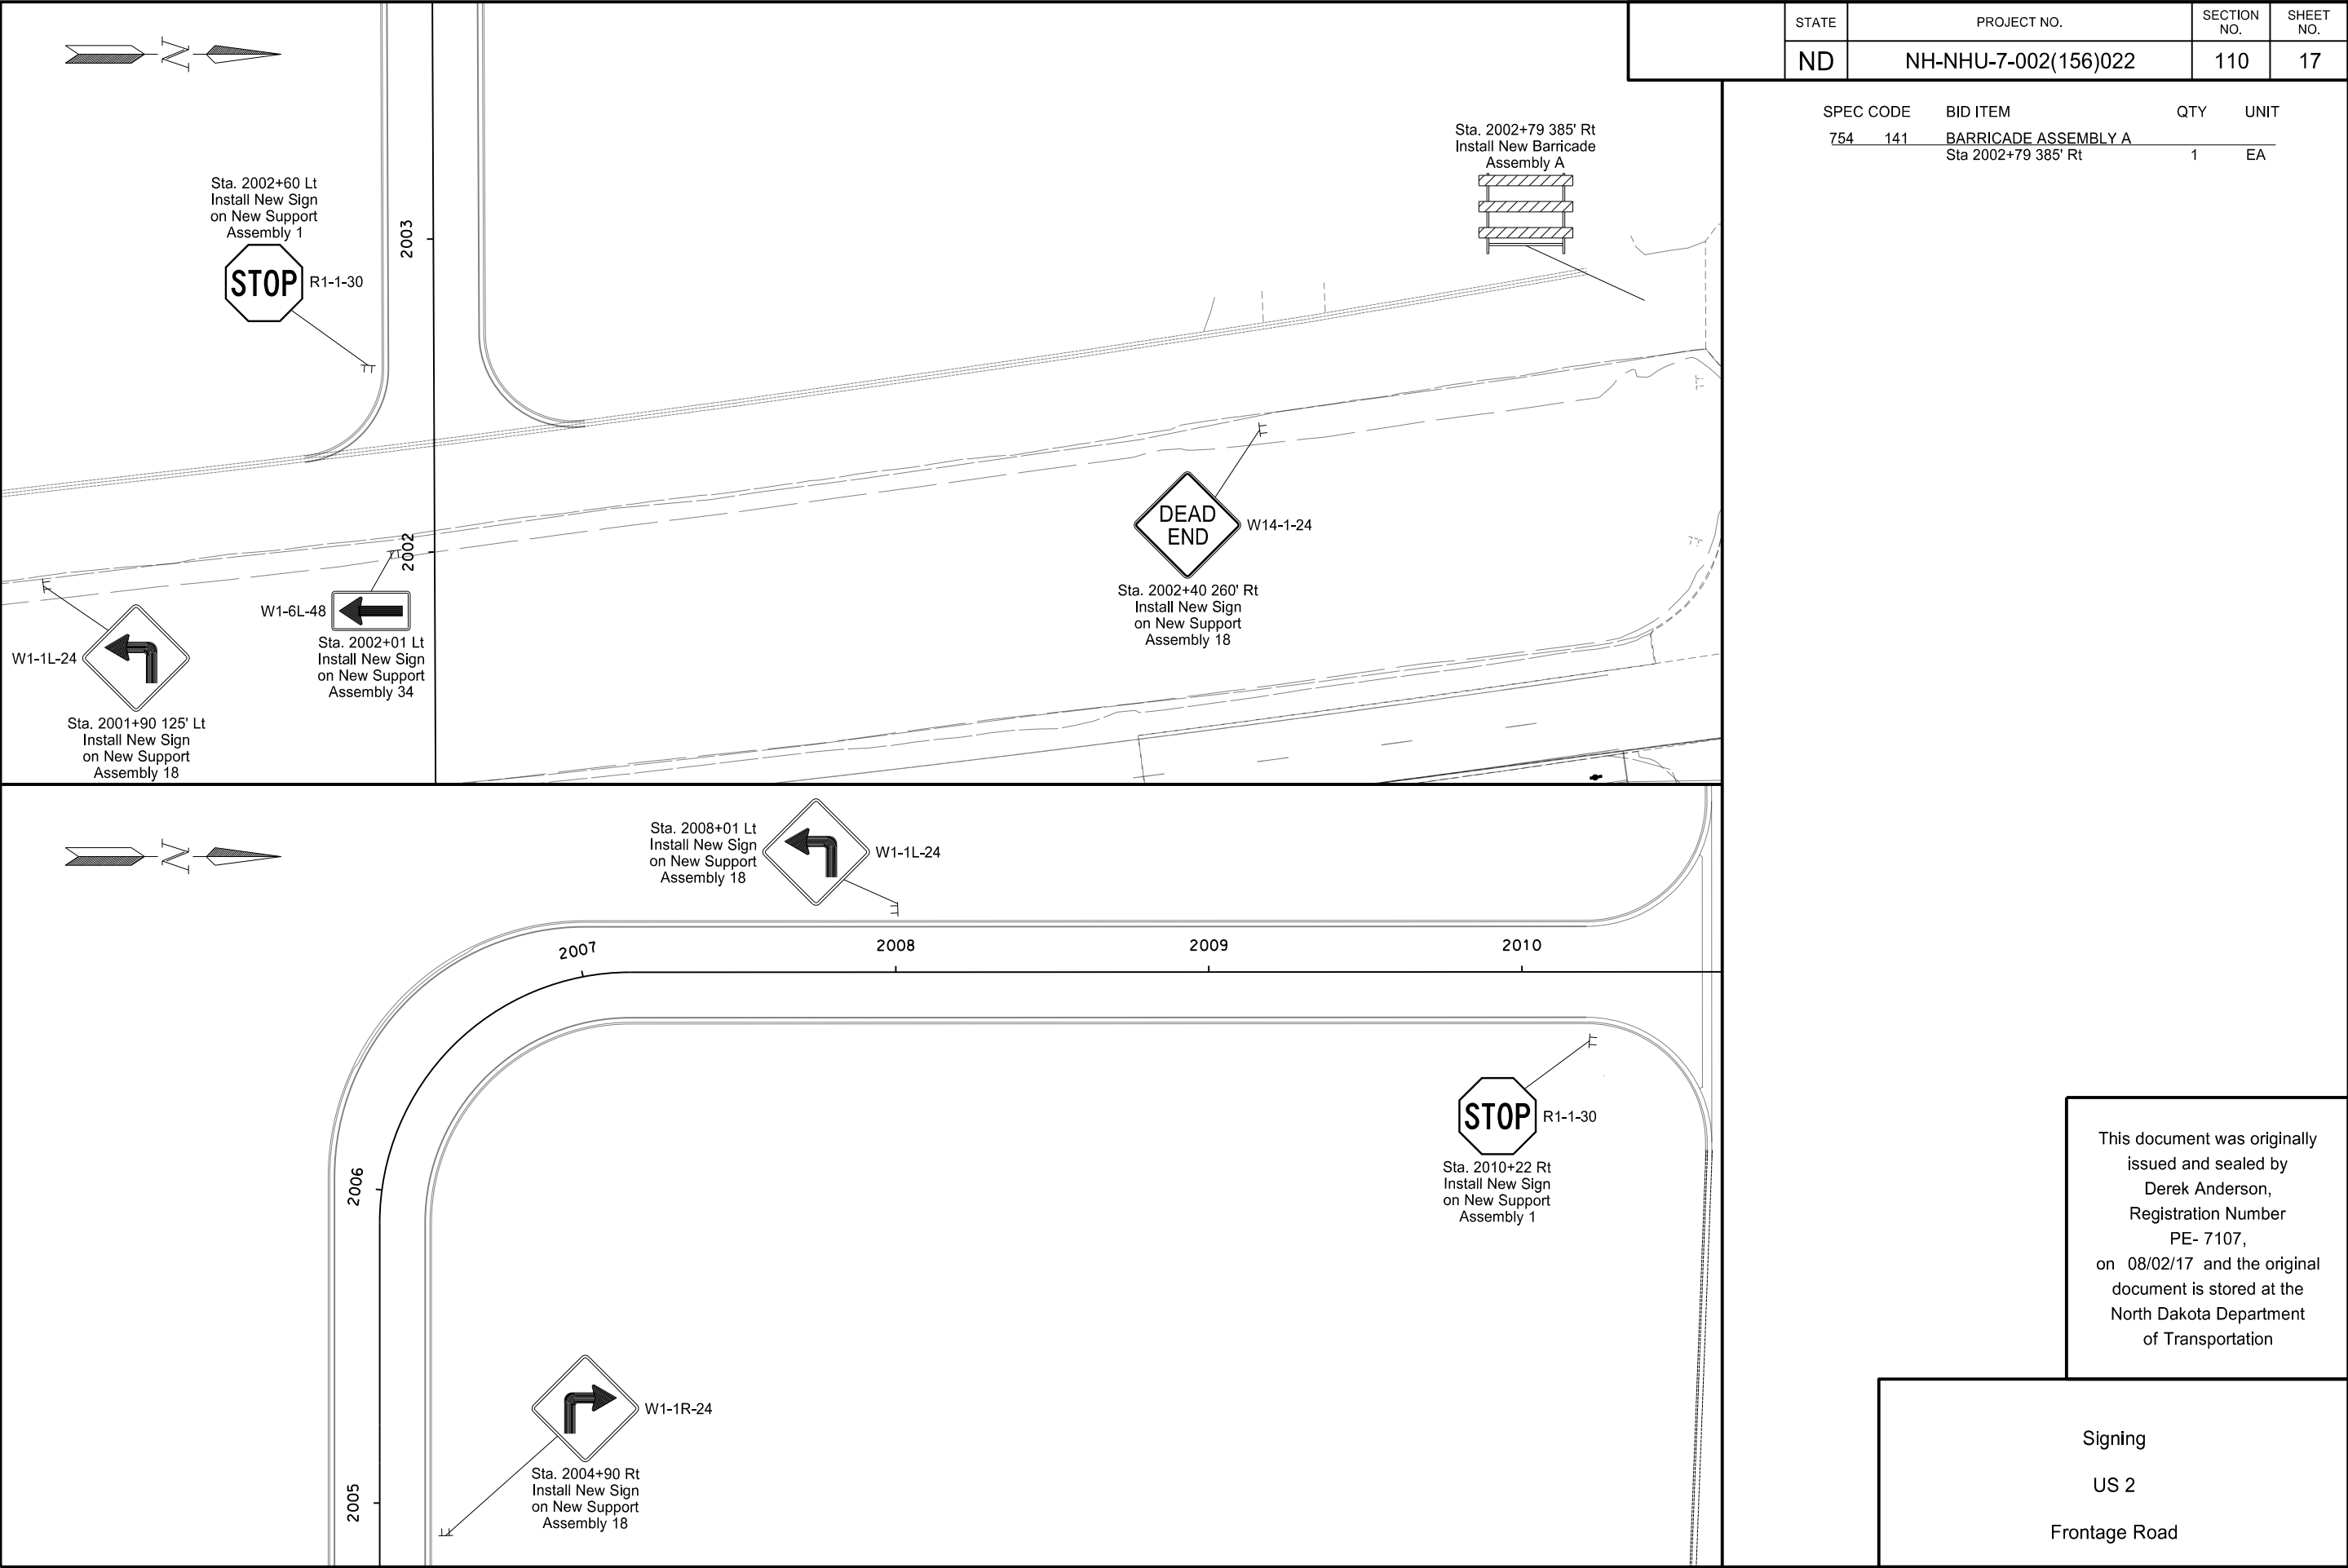


STATE	PROJECT NO.	SECTION NO.	SHEET NO.
ND	NH-NHU-7-002(156)022	110	17

SPEC CODE	BID ITEM	QTY	UNIT
754 141	BARRICADE ASSEMBLY A Sta 2002+79 385' Rt	1	EA


This document was originally issued and sealed by
Derek Anderson,
Registration Number
PE- 7107,
on 08/02/17 and the original document is stored at the
North Dakota Department
of Transportation

Signing
US 2
Frontage Road

	STATE	PROJECT NO.	SECTION NO.	SHEET NO.
	ND	NH-NHU-7-002(156)022	110	21

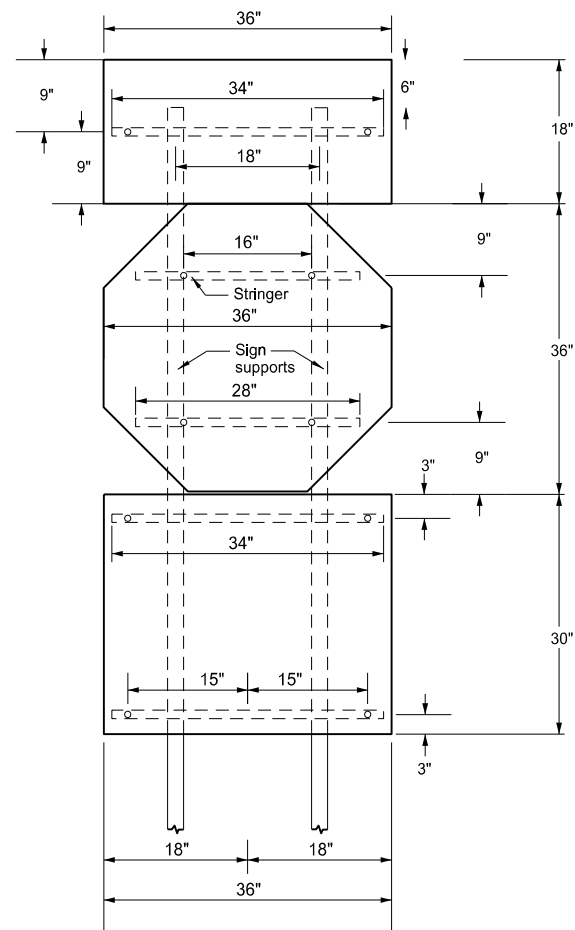

Special Assembly 1
(Perforated Tube)
Area: 28.46 SF

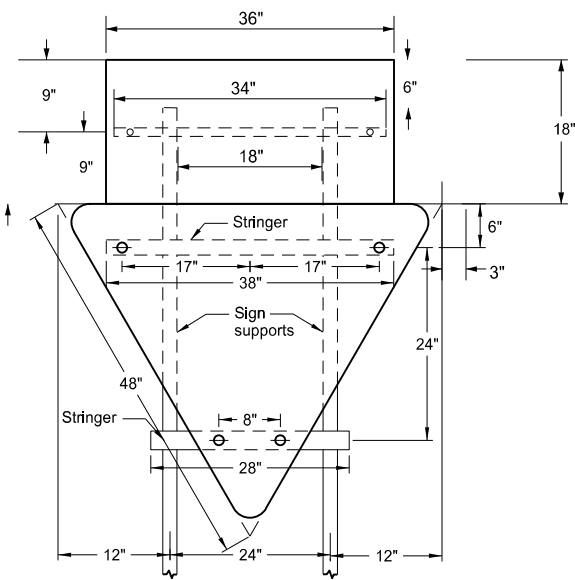

Special Assembly 2
(Perforated Tube)
Area: 20.43 SF

This document was originally issued and sealed by
Derek Anderson,
Registration Number
PE- 7107,
on 08/02/17 and the original document is stored at the
North Dakota Department
of Transportation

Sign Details
US 2

	STATE	PROJECT NO.	SECTION NO.	SHEET NO.
	ND	NH-NHU-7-002(156)022	120	1


(Table 1) Permanent Pavement Marking Summary													
Sheet No.	Begin Station	End Station	Lane	Obliteration of Pavement Marking (SF) 704 1500	EPOXY PAVEMENT MARKING						PREFORMED PATTERNED PAVEMENT MARKING		
					MESSAGE (SF) 762 0112		4IN LINE (LF) 762 0113			8IN LINE (LF) 762 0115	4IN LINE (LF) 762 1305	8IN LINE (LF) 762 1309	24IN LINE (LF) 762 1325
					Lt Arrow	Rt Arrow	White CL Skips	Yellow Edge Line	White Edge Line	White Channel Line	White CL Skips	White Channel Line	Stop Bar
-	50+64	55+16	EB	-	-	-	-	452	452	-	113	-	-
	-		WB	-	-	-	-	-	-	-	-	-	
3	55+16	69+00	EB	-	48	48	-	1,237	1,370	-	315	1,266	95
			WB	-	48	48	-	1,248	1,202	-	311	1,396	60
-	69+00	97+79	EB	-	-	-	-	2,881	2,876	-	720	-	-
			WB	-	-	-	-	2,895	2,901	-	725	-	-
3	97+79	105+00	EB	-	48	-	-	724	624	-	180	436	-
			WB	-	-	-	-	711	640	-	182	-	-
4	105+00	130+00	EB	-	96	48	-	2,489	2,494	-	625	1,297	-
			WB	-	48	48	-	2,443	2,320	-	623	806	-
-	130+00	135+00	EB	-	-	-	-	499	501	-	125	-	-
			WB	-	-	-	-	494	492	-	123	-	-
5	135+00	148+50	EB	-	48	48	-	1,247	1,351	-	338	723	-
			WB	-	48	-	-	1,297	1,316	-	337	374	-
-	148+50	162+80	EB	-	-	-	-	1,430	1,430	-	358	-	-
			WB	-	-	-	-	1,430	1,430	-	358	-	-
6	162+80	183+77	EB	226	48	128	-	2,086	2,192	-	524	1,309	88
			WB	-	48	-	-	2,085	2,020	-	524	435	36
-	183+77	190+00	EB	-	-	-	-	623	623	-	156	-	-
			WB	-	-	-	-	623	623	-	156	-	-
7	190+00	203+00	EB	-	-	48	-	1,293	1,334	-	325	335	-
			WB	-	48	-	-	1,283	1,300	-	325	435	-
-	203+00	228+00	EB	-	-	-	-	2,500	2,500	-	625	-	-
			WB	-	-	-	-	2,500	2,500	-	625	-	-
8	228+00	247+00	EB	-	-	-	194	901	901	-	32	-	-
			WB	-	48	48	-	1,778	1,669	-	376	1,139	72
-	247+00	269+00	EB	-	-	-	550	2,200	2,200	-	-	-	-
			WB	-	-	-	-	2,200	2,200	-	550	-	-
Part 1 Total				226	576	464	744	41,549	41,461	-	9,651	9,951	351

This document was originally issued and sealed by Matthew T. Kinsella, Registration Number PE- 5692, on 08/02/17 and the original document is stored at the North Dakota Department of Transportation


Permanent Pavement Marking Summary

Sta 50+64 to Sta 269+00



											STATE	PROJECT NO.		SECTION NO.	SHEET NO.
										ND	NH-NHU-7-002(156)022		120	2	
(Table 1) Permanent Pavement Marking Summary															
Sheet No.	Begin Station	End Station	Lane	Obliteration of Pavement Marking (SF) 704 1500	EPOXY PAVEMENT MARKING					PREFORMED PATTERNED PAVEMENT MARKING					
					MESSAGE (SF) 762 0112		4IN LINE (LF) 762 0113			8IN LINE (LF) 762 0115	4IN LINE (LF) 762 1305	8IN LINE (LF) 762 1309	24IN LINE (LF) 762 1325		
					Lt Arrow	Rt Arrow	White CL Skips	Yellow Edge Line	White Edge Line	White Channel Line	White CL Skips	White Channel Line	Stop Bar		
9	269+00	281+50	EB	-	-	48	313	1,253	1,151	371	-	-	-		
			WB	-	48	-	-	1,248	1,250	-	313	385	-		
-	281+50	319+00	EB	-	-	-	938	3,750	3,750	-	-	-	-		
			WB	-	-	-	-	3,750	3,750	-	938	-	-		
9	319+00	331+00	EB	-	-	48	300	1,207	1,096	618	-	-	-		
			WB	-	-	-	-	1,200	1,200	-	300	256	-		
10	331+00	338+00	EB	-	-	-	175	700	700	-	-	-	-		
			WB	-	48	-	-	700	700	-	175	447	-		
-	338+00	357+00	EB	-	-	-	475	1,900	1,900	-	-	-	-		
			WB	-	-	-	-	1,900	1,900	-	475	-	-		
11	357+00	382+00	EB	-	96	48	625	2,483	2,503	2,093	-	-	-		
			WB	-	-	48	-	2,428	2,431	-	625	712	-		
12	382+00	390+00	EB	-	-	-	200	800	800	-	-	-	-		
			WB	-	48	48	-	800	800	-	200	1,050	-		
-	390+00	478+00	EB	-	-	-	2,200	8,800	8,800	-	-	-	-		
			WB	-	-	-	-	8,800	8,800	-	2,200	-	-		
13	478+00	494+00	EB	-	-	48	400	1,596	1,490	352	-	-	-		
			WB	-	48	-	-	1,589	1,506	-	400	451	-		
-	494+00	507+00	EB	-	-	-	325	1,300	1,300	-	-	-	-		
			WB	-	-	-	-	1,300	1,300	-	325	-	-		
14	507+00	513+64	EB	-	48	-	166	684	664	344	-	-	-		
			WB	-	-	-	-	655	664	-	166	-	-		
-	513+64	524+00	EB	-	-	-	259	1,036	1,036	-	-	-	-		
			WB	-	-	-	-	1,036	1,036	-	259	-	-		
15	524+00	546+00	EB	-	48	48	550	2,173	2,141	720	-	-	-		
			WB	-	48	-	-	2,144	2,001	-	550	449	-		
-	546+00	573+00	EB	-	-	-	675	2,702	2,698	-	-	-	-		
		566+08	WB	-	-	-	-	2,008	2,008	-	502	-	-		
Part 2 Total				-	432	336	7,601	59,942	59,375	4,498	7,428	3,750	-		
Overall Total				226	1,008	800	8,345	101,491	100,836	4,498	17,079	13,701	351		
												Permanent Pavement Marking Summary			
												Sta 269+00 to Sta 573+00			
This document was originally issued and sealed by Matthew T. Kinsella, Registration Number PE- 5692, on 08/02/17 and the original document is stored at the North Dakota Department of Transportation															

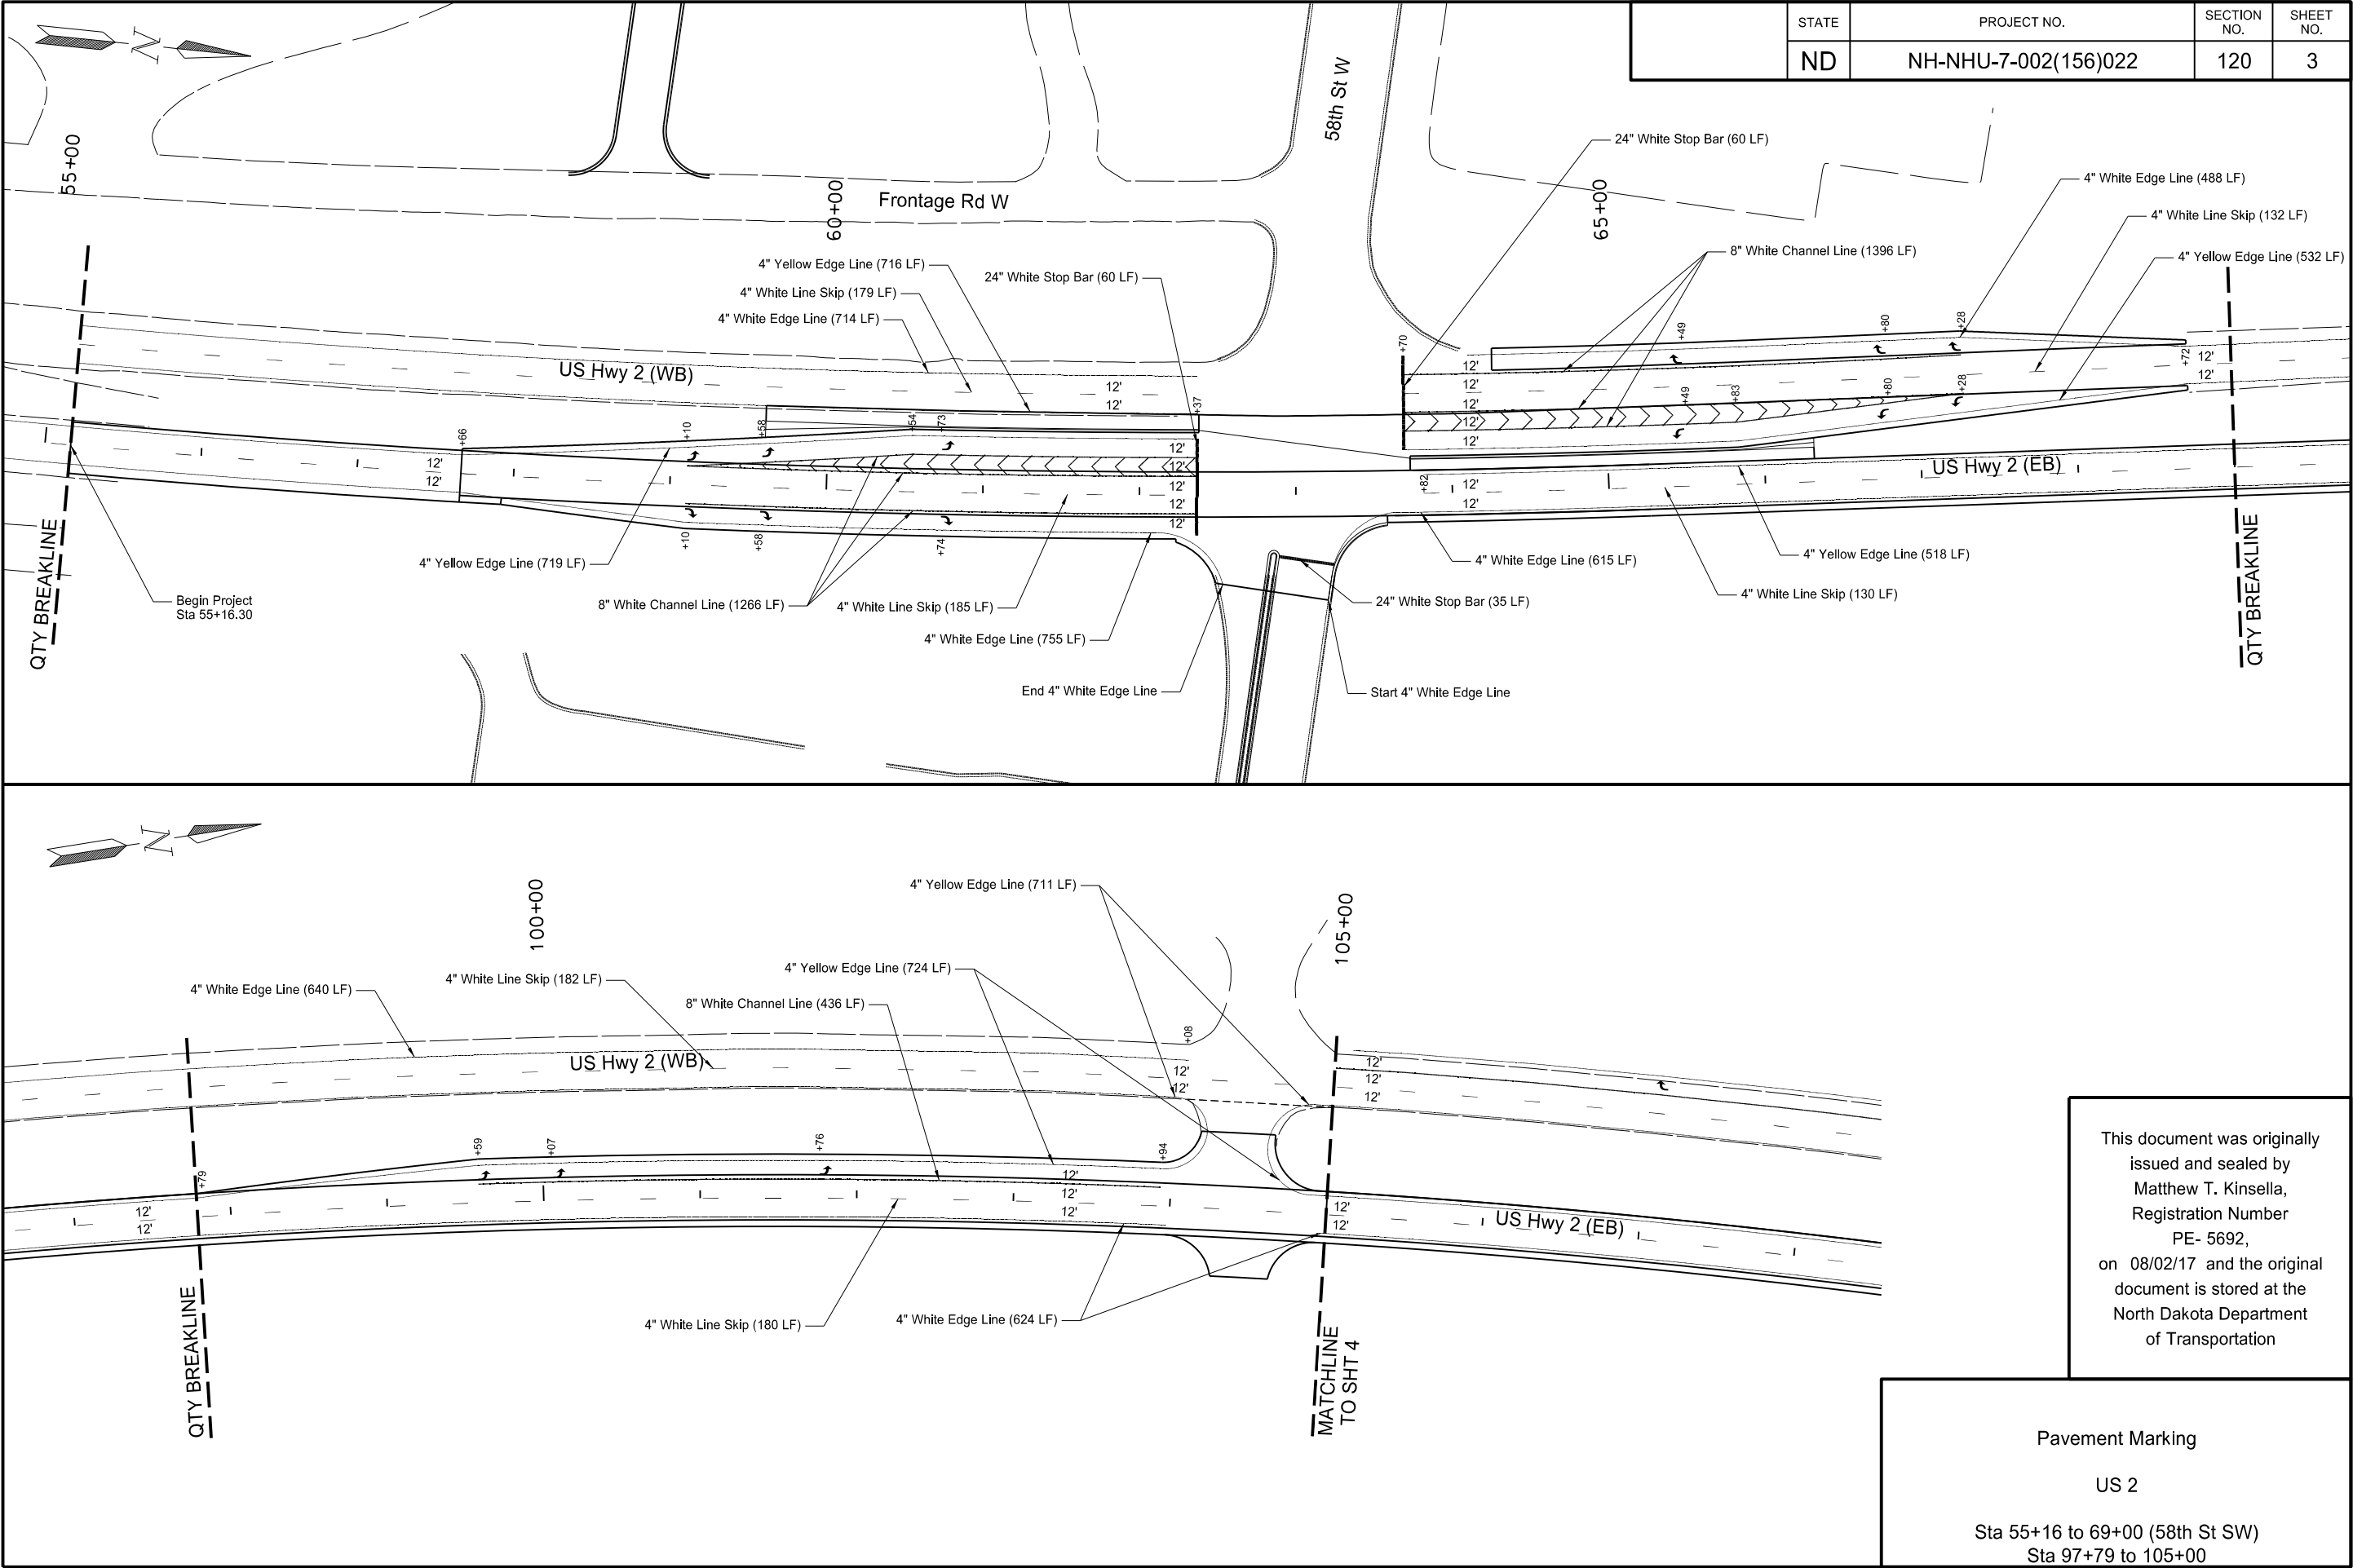

	STATE	PROJECT NO.	SECTION NO.	SHEET NO.
	ND	NH-NHU-7-002(156)022	120	4

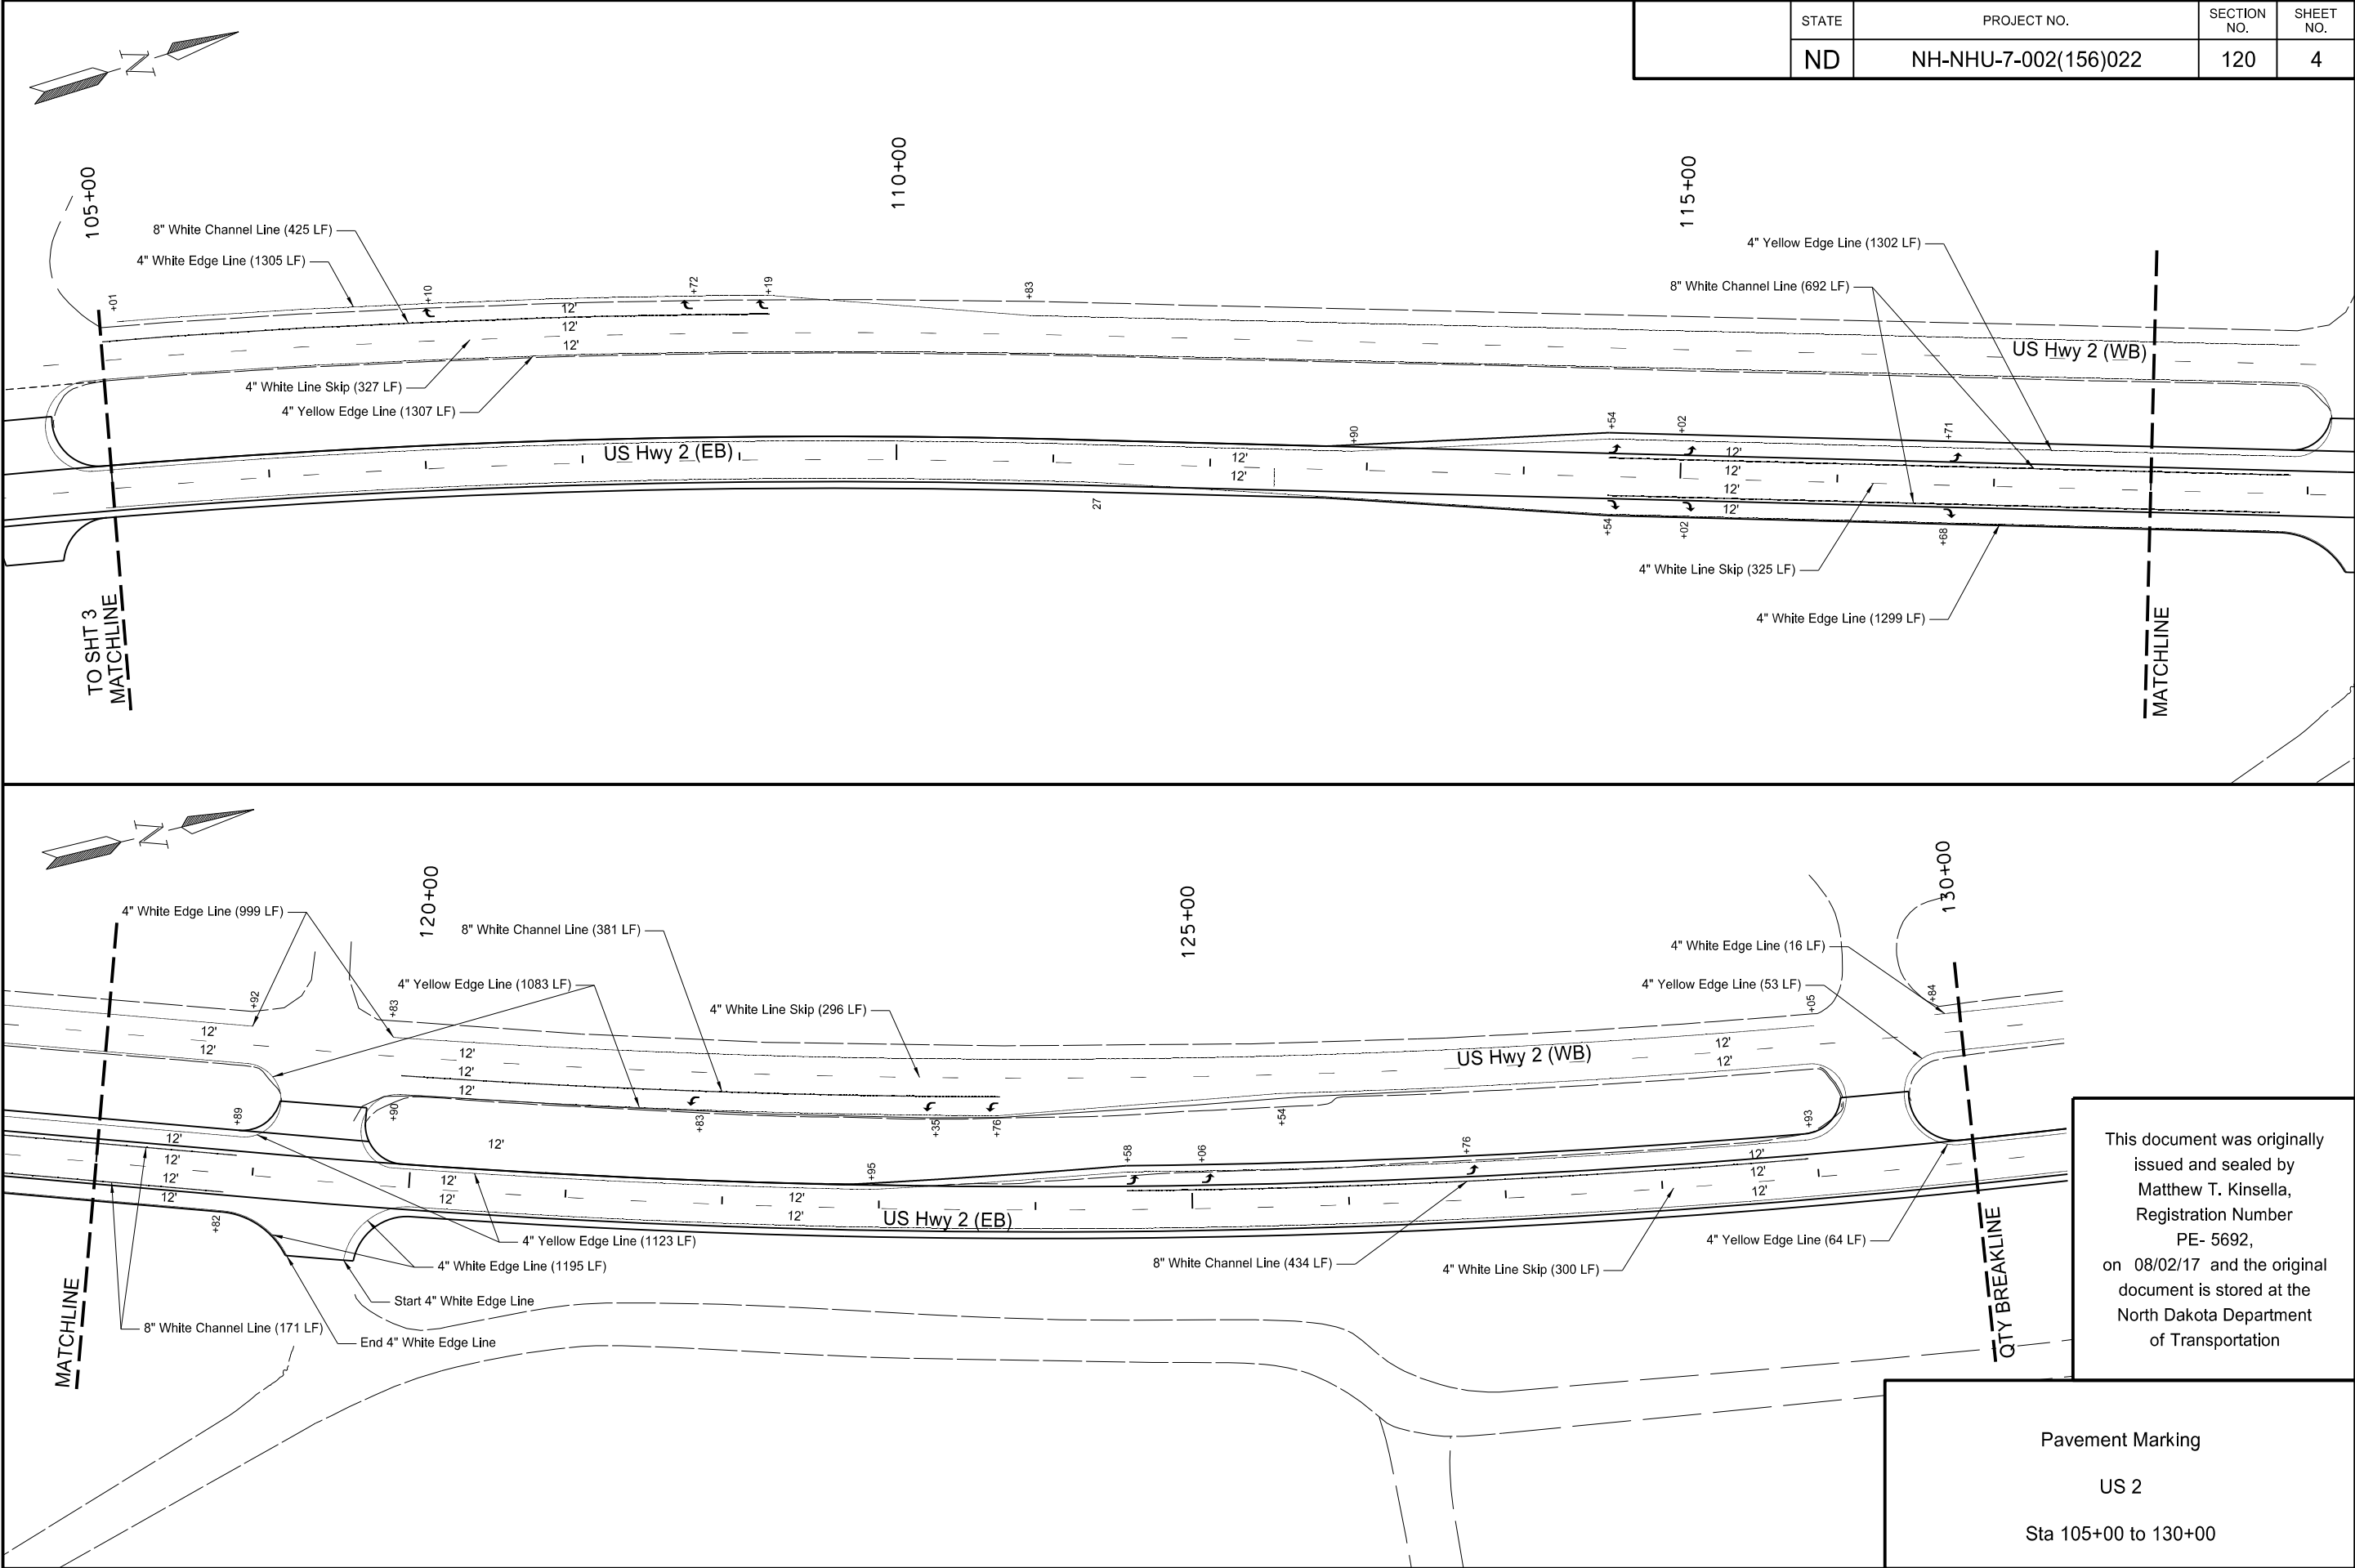



	STATE	PROJECT NO.	SECTION NO.	SHEET NO.
	ND	NH-NHU-7-002(156)022	120	5

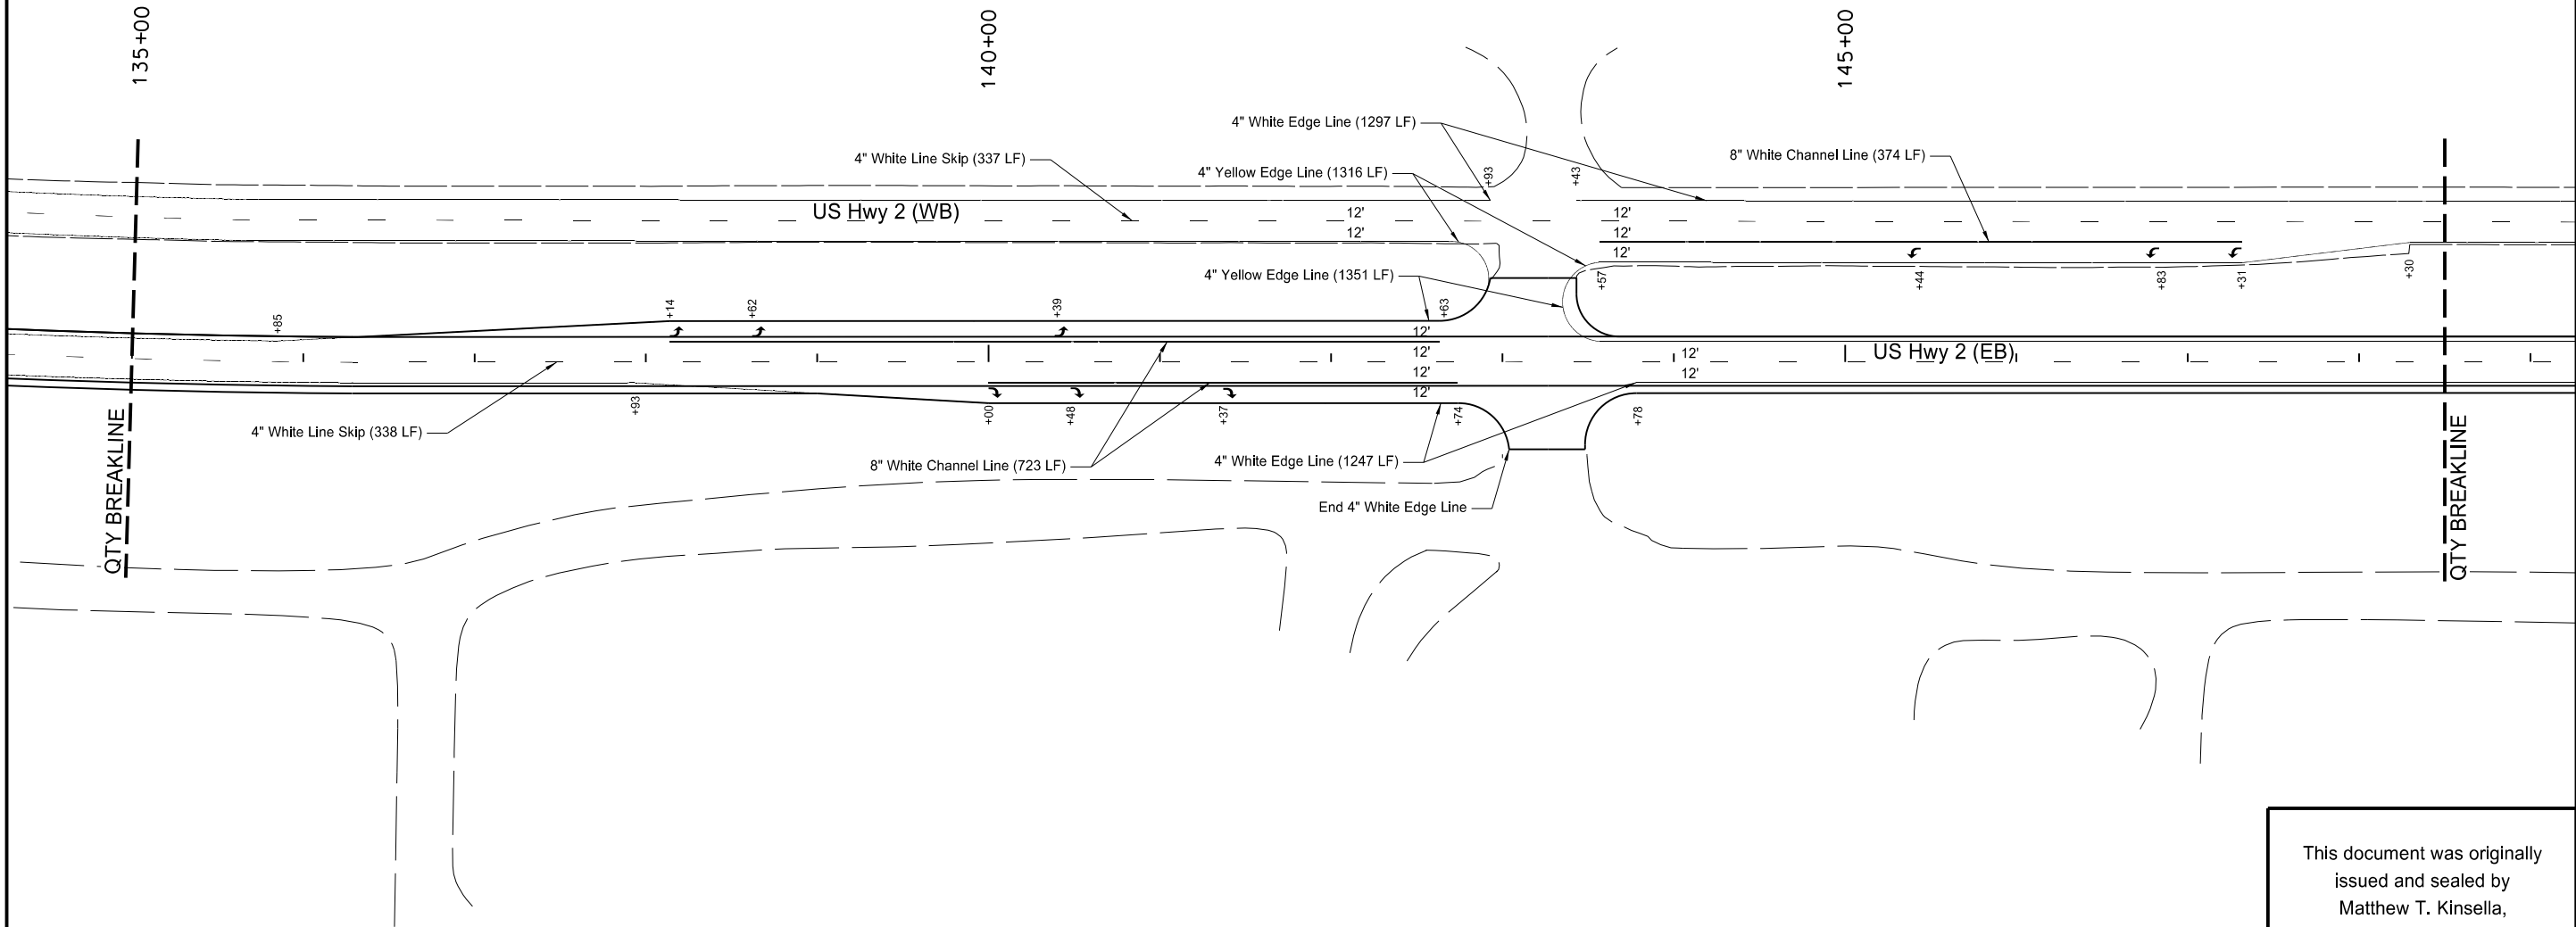 


This document was originally issued and sealed by Matthew T. Kinsella, Registration Number PE- 5692, on 08/02/17 and the original document is stored at the North Dakota Department of Transportation

 Pavement Marking
US 2
Sta 135+00 to 148+50

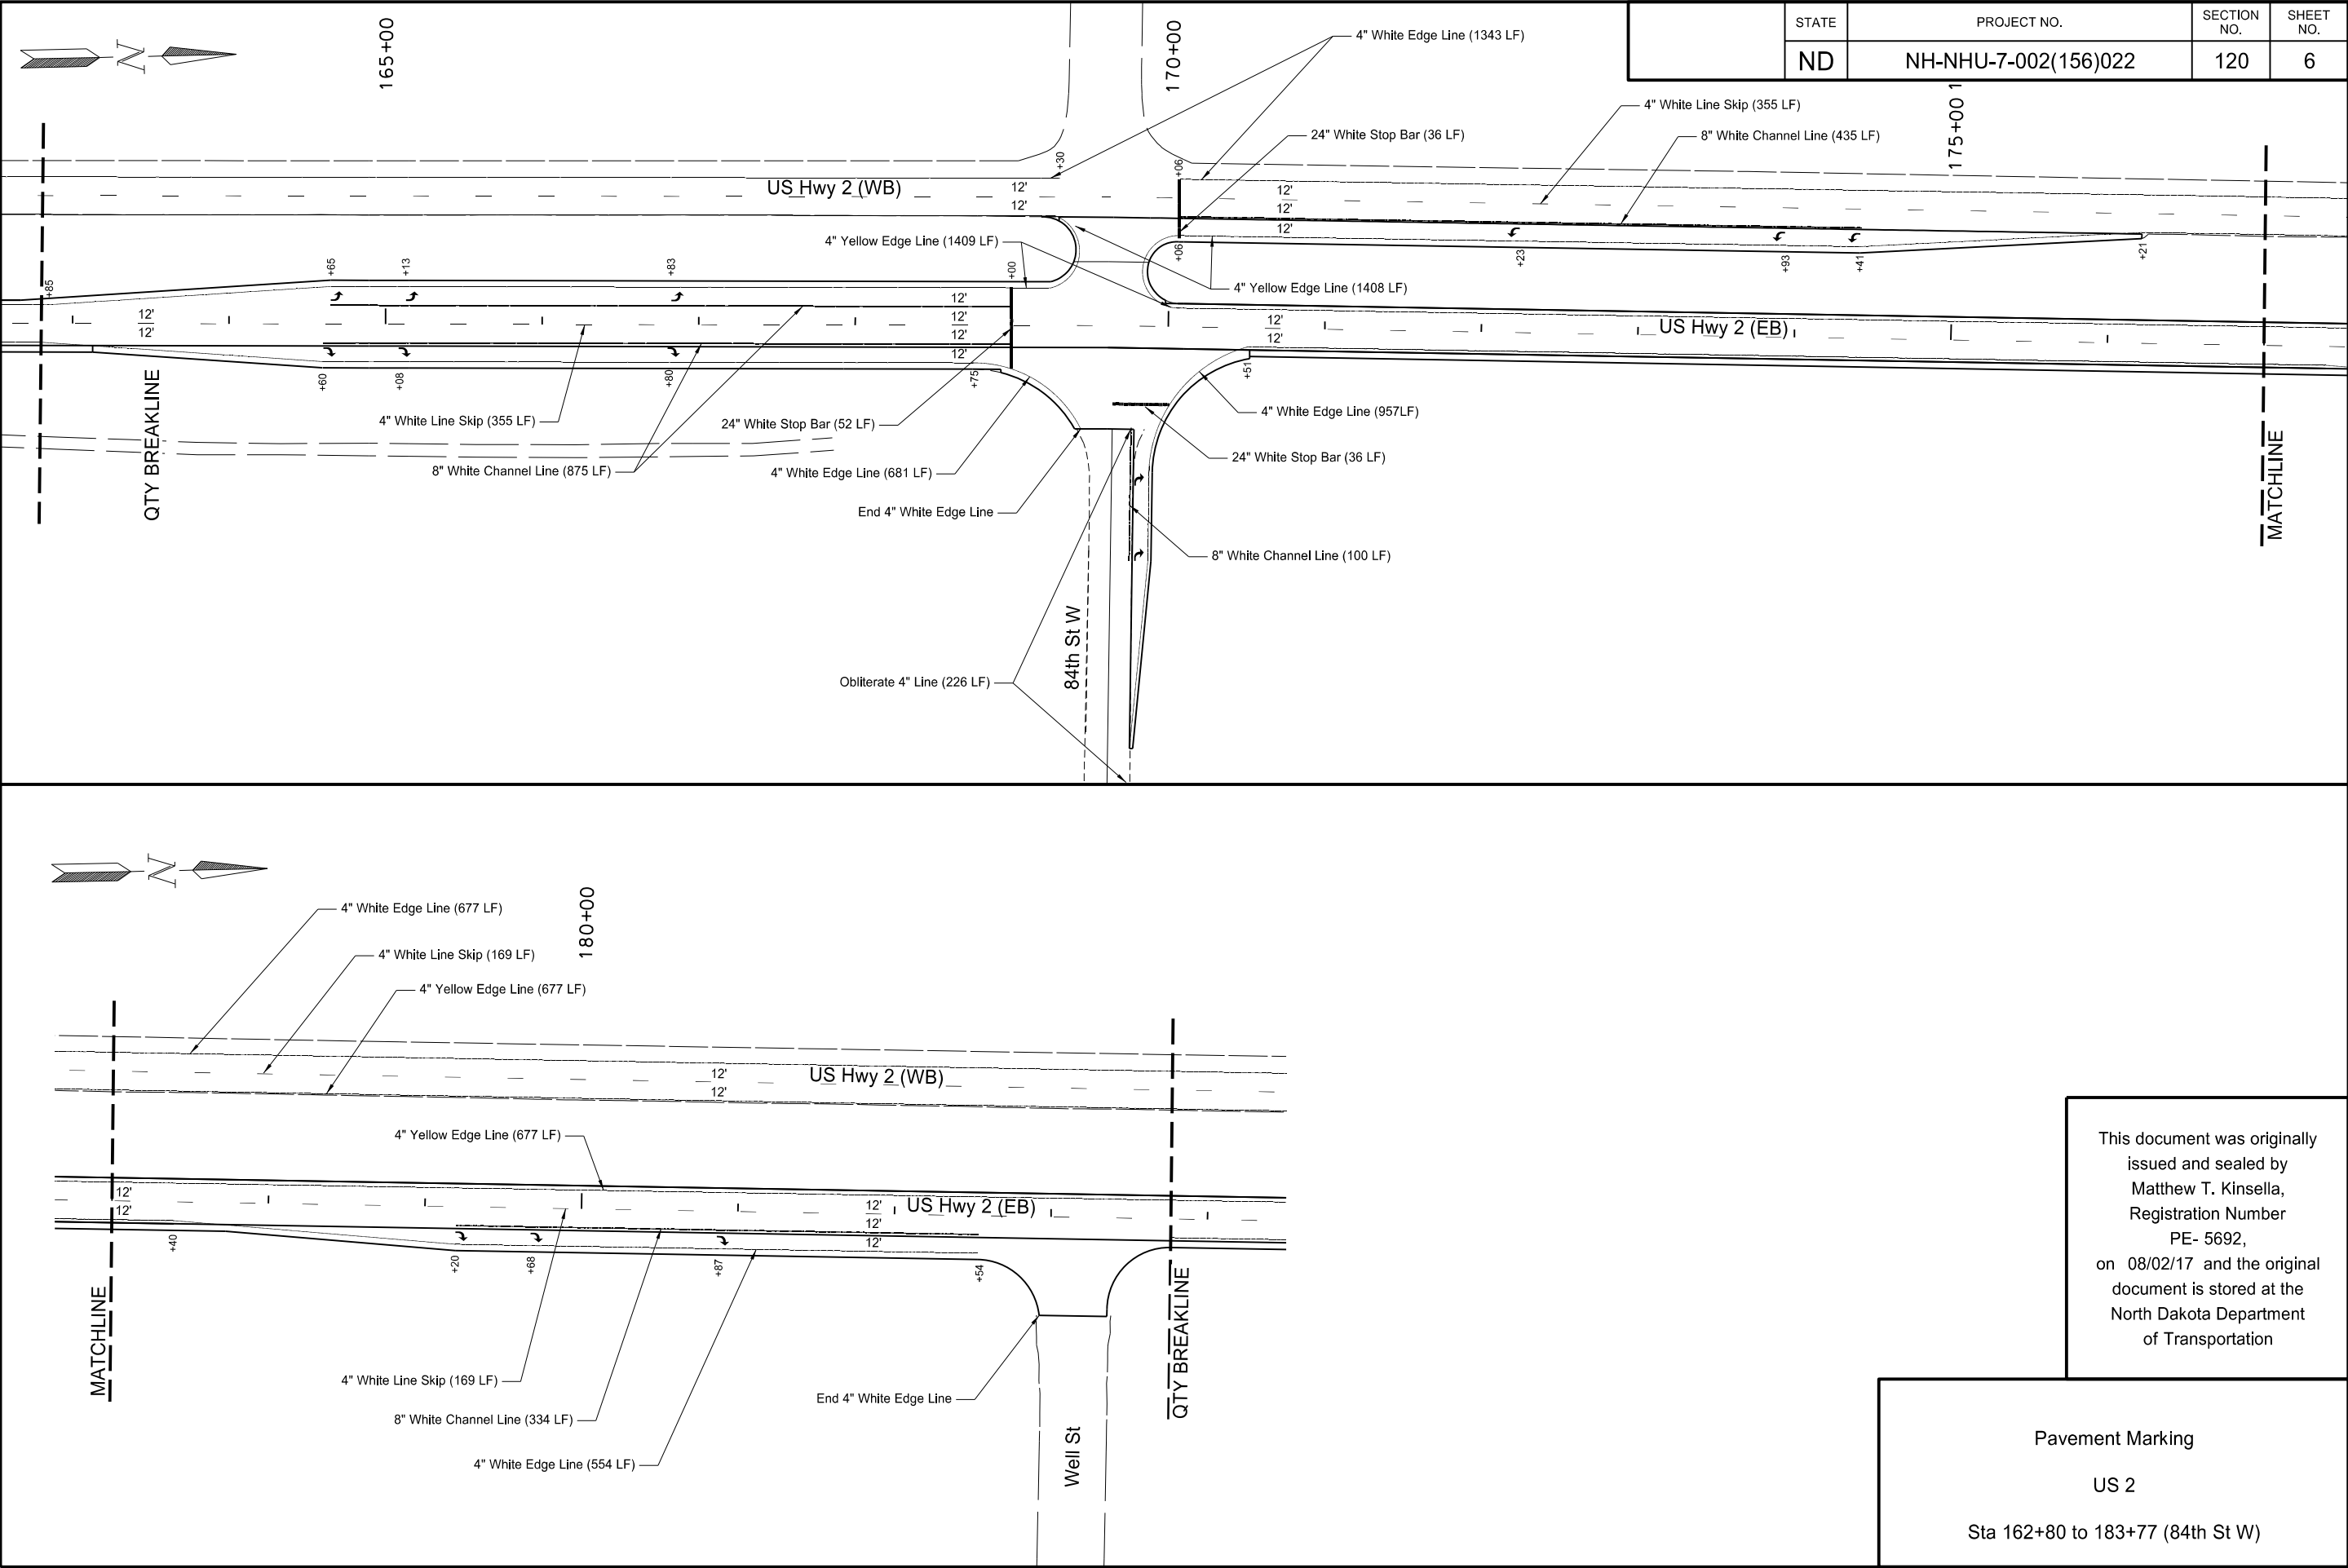





	STATE	PROJECT NO.	SECTION NO.	SHEET NO.
	ND	NH-NHU-7-002(156)022	120	7

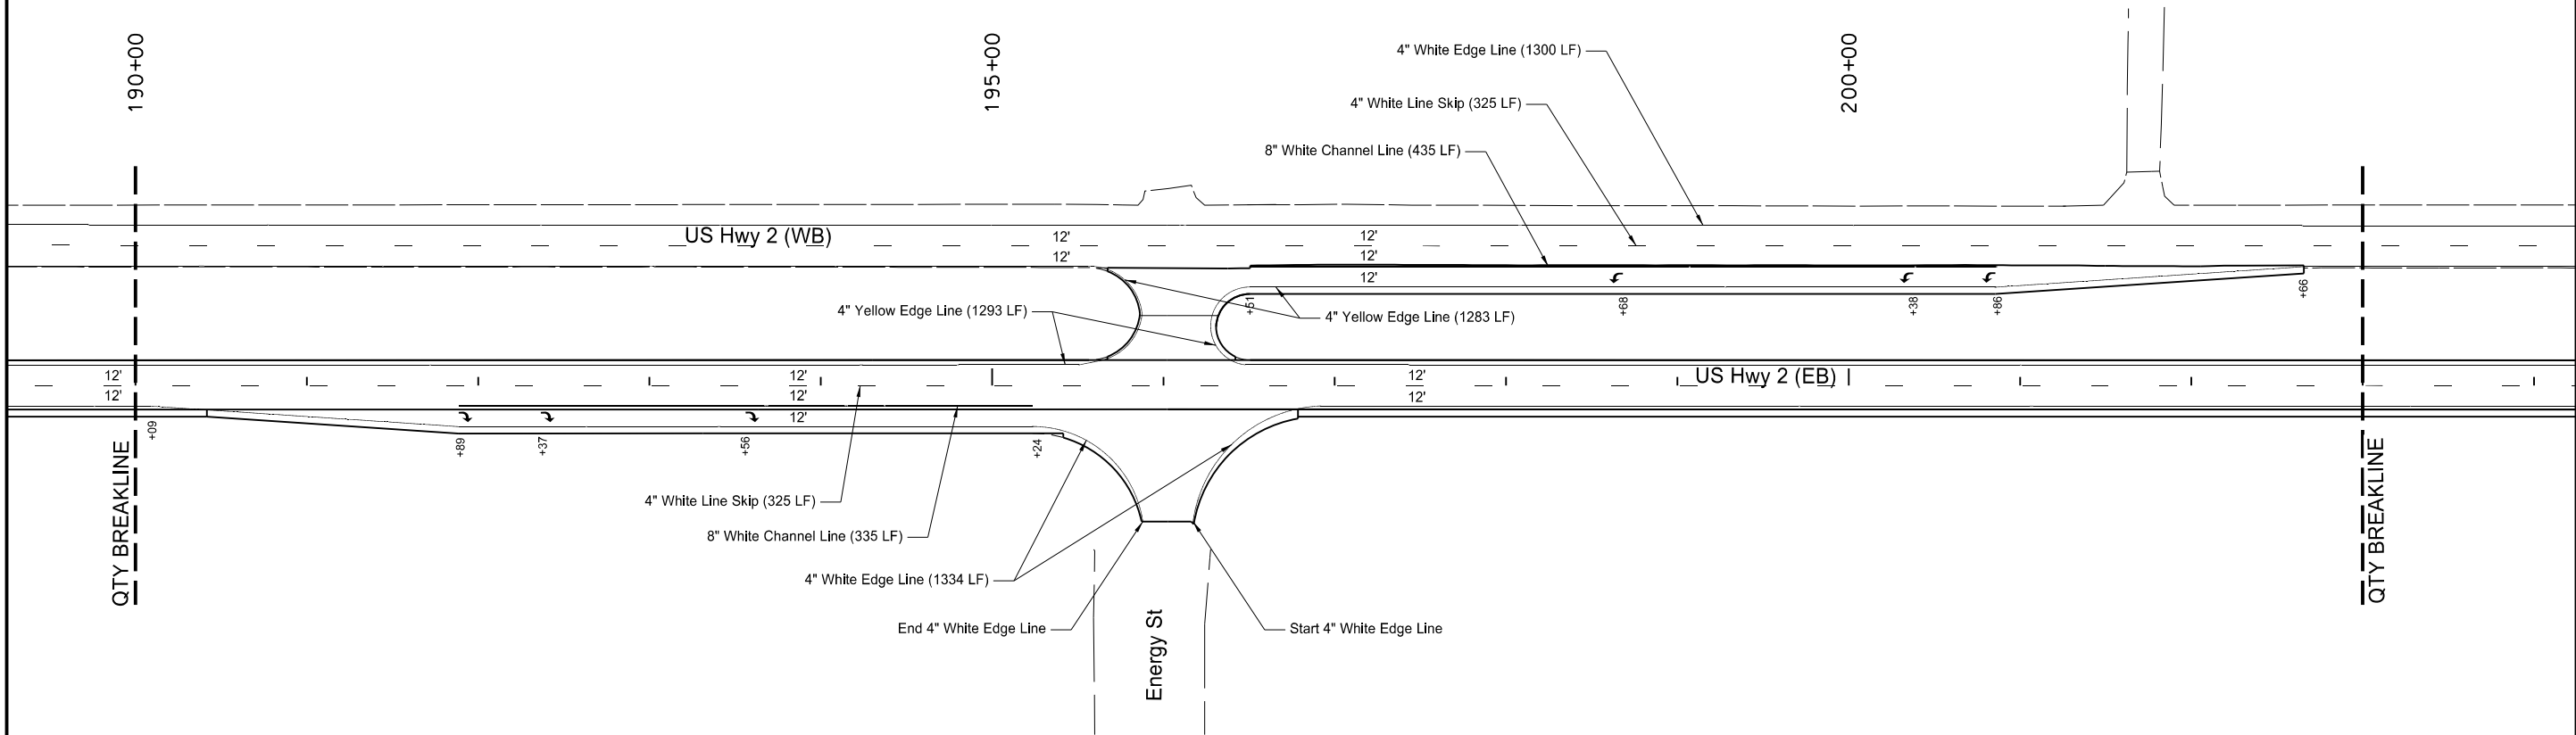

This document was originally issued and sealed by Matthew T. Kinsella, Registration Number PE- 5692, on 08/02/17 and the original document is stored at the North Dakota Department of Transportation

Pavement Marking
US 2
Sta 190+00 to 203+00 (Energy St)

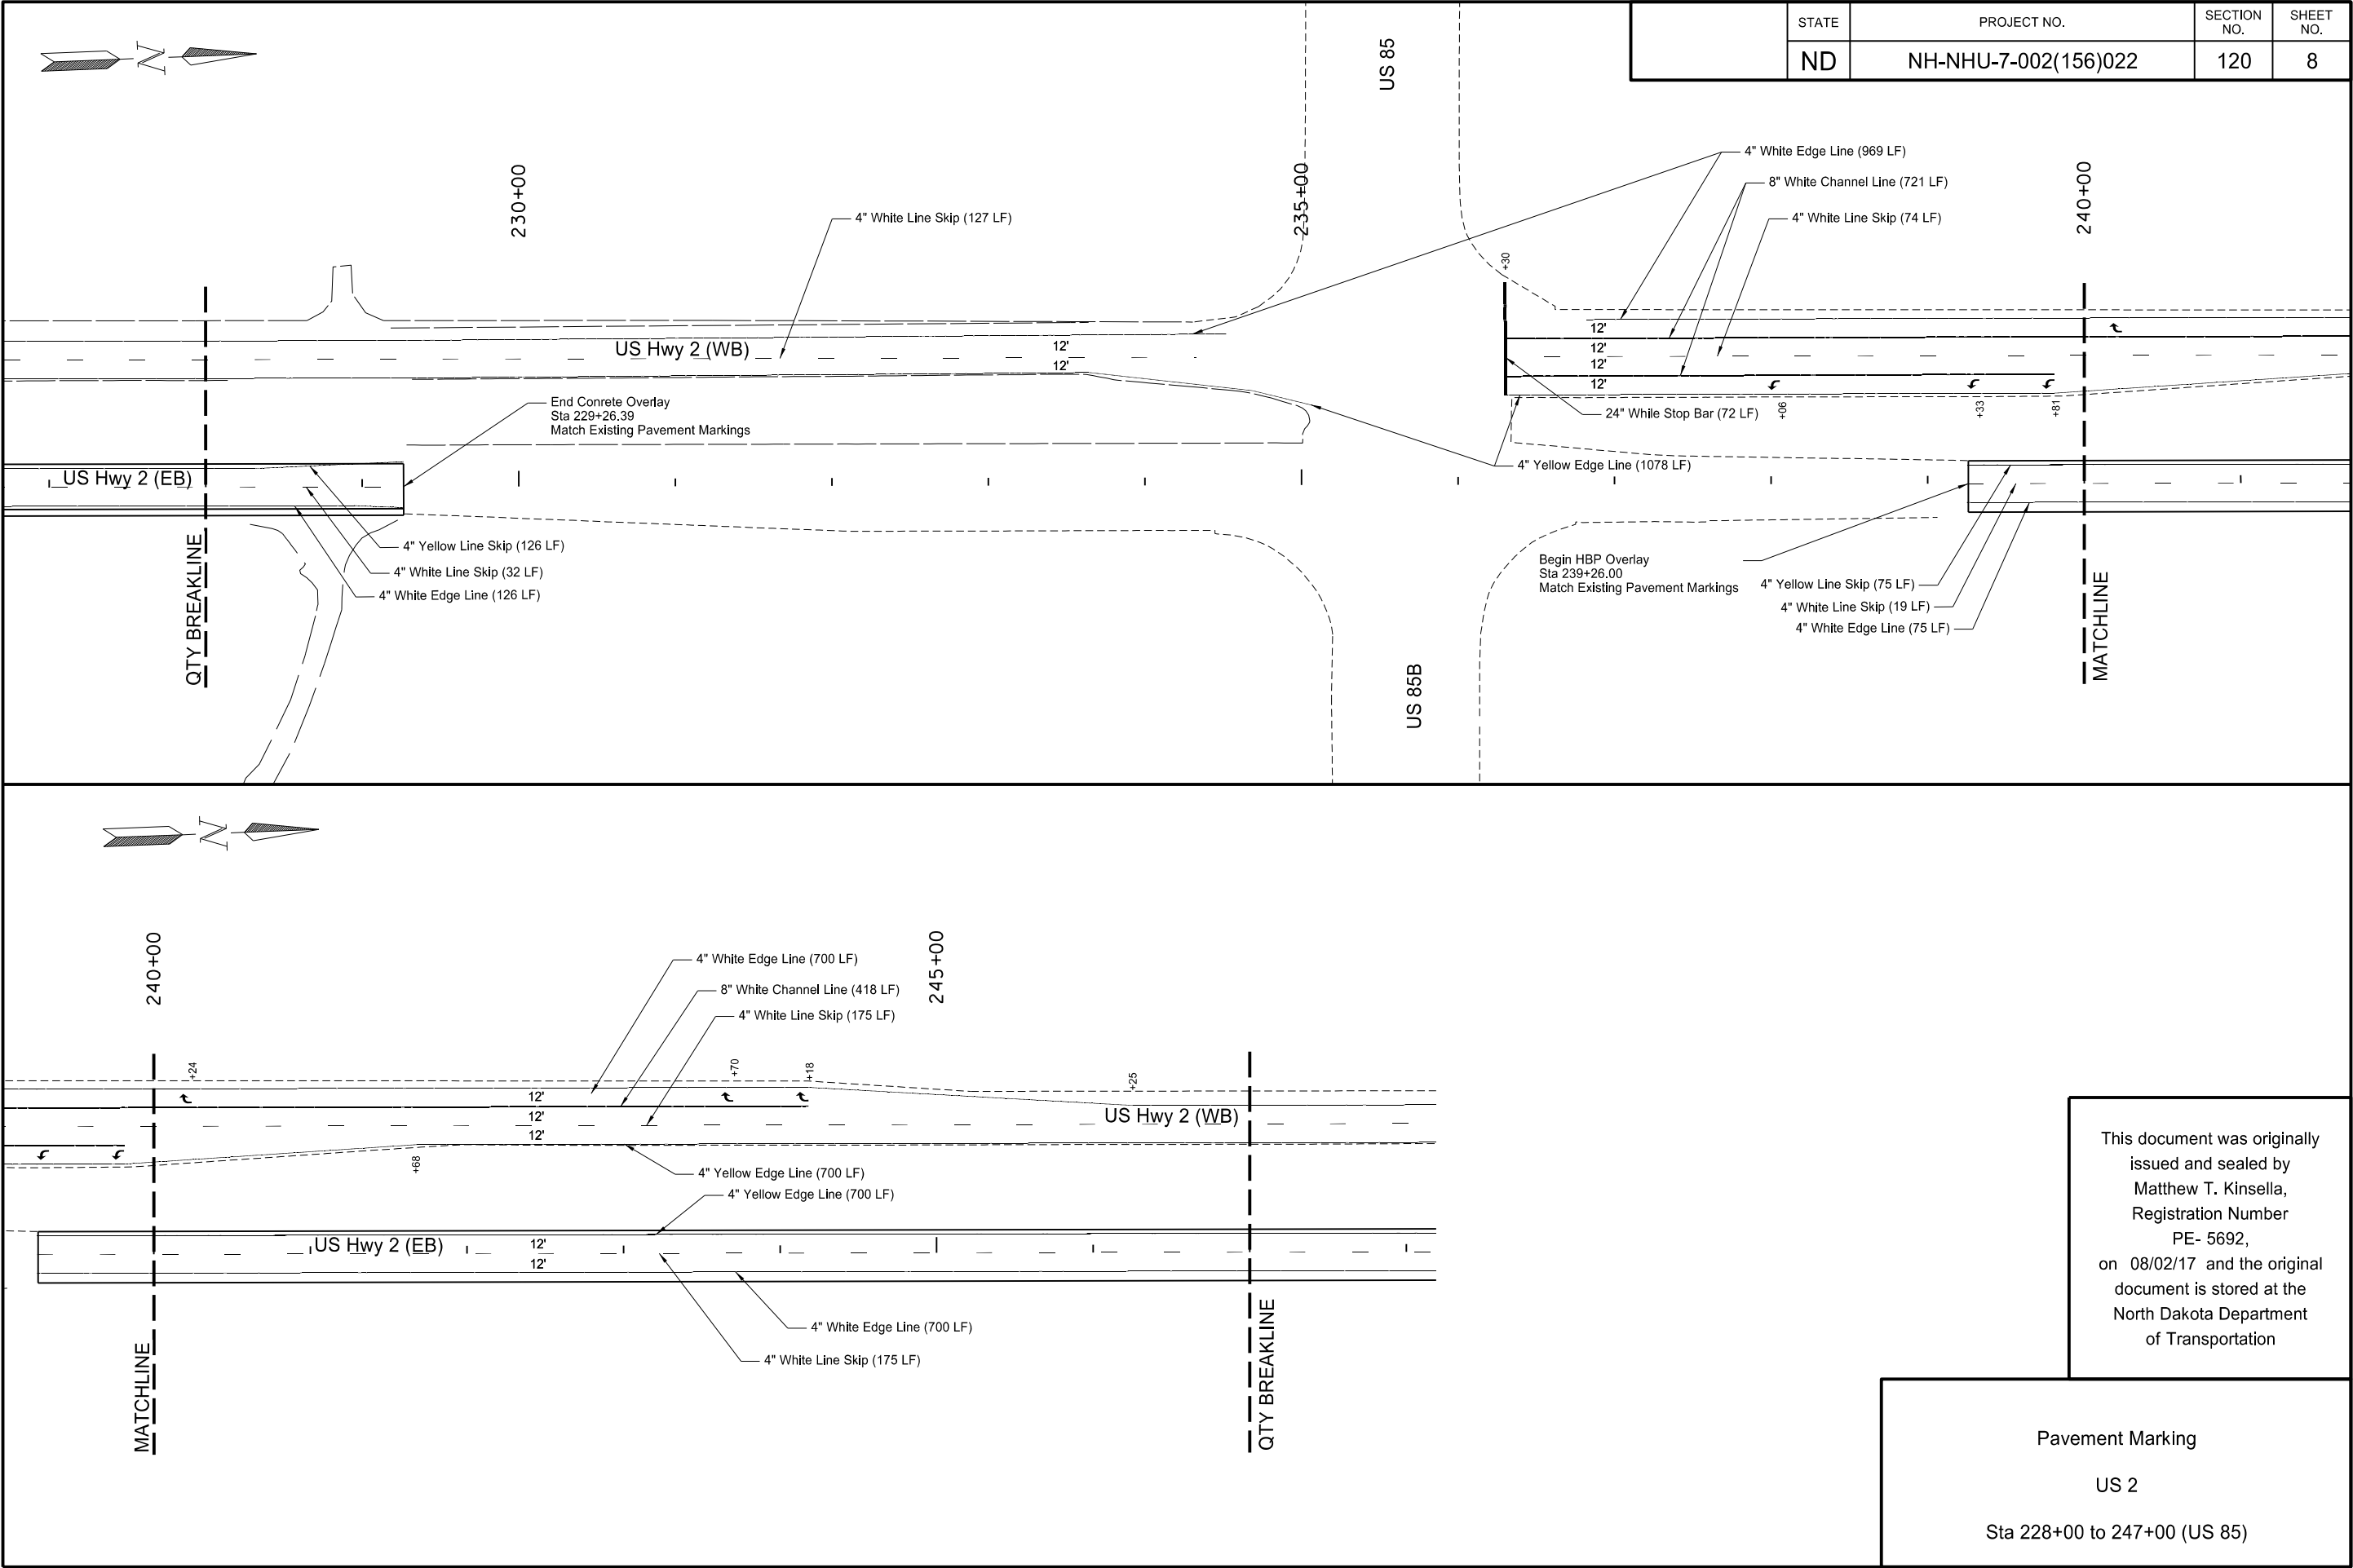

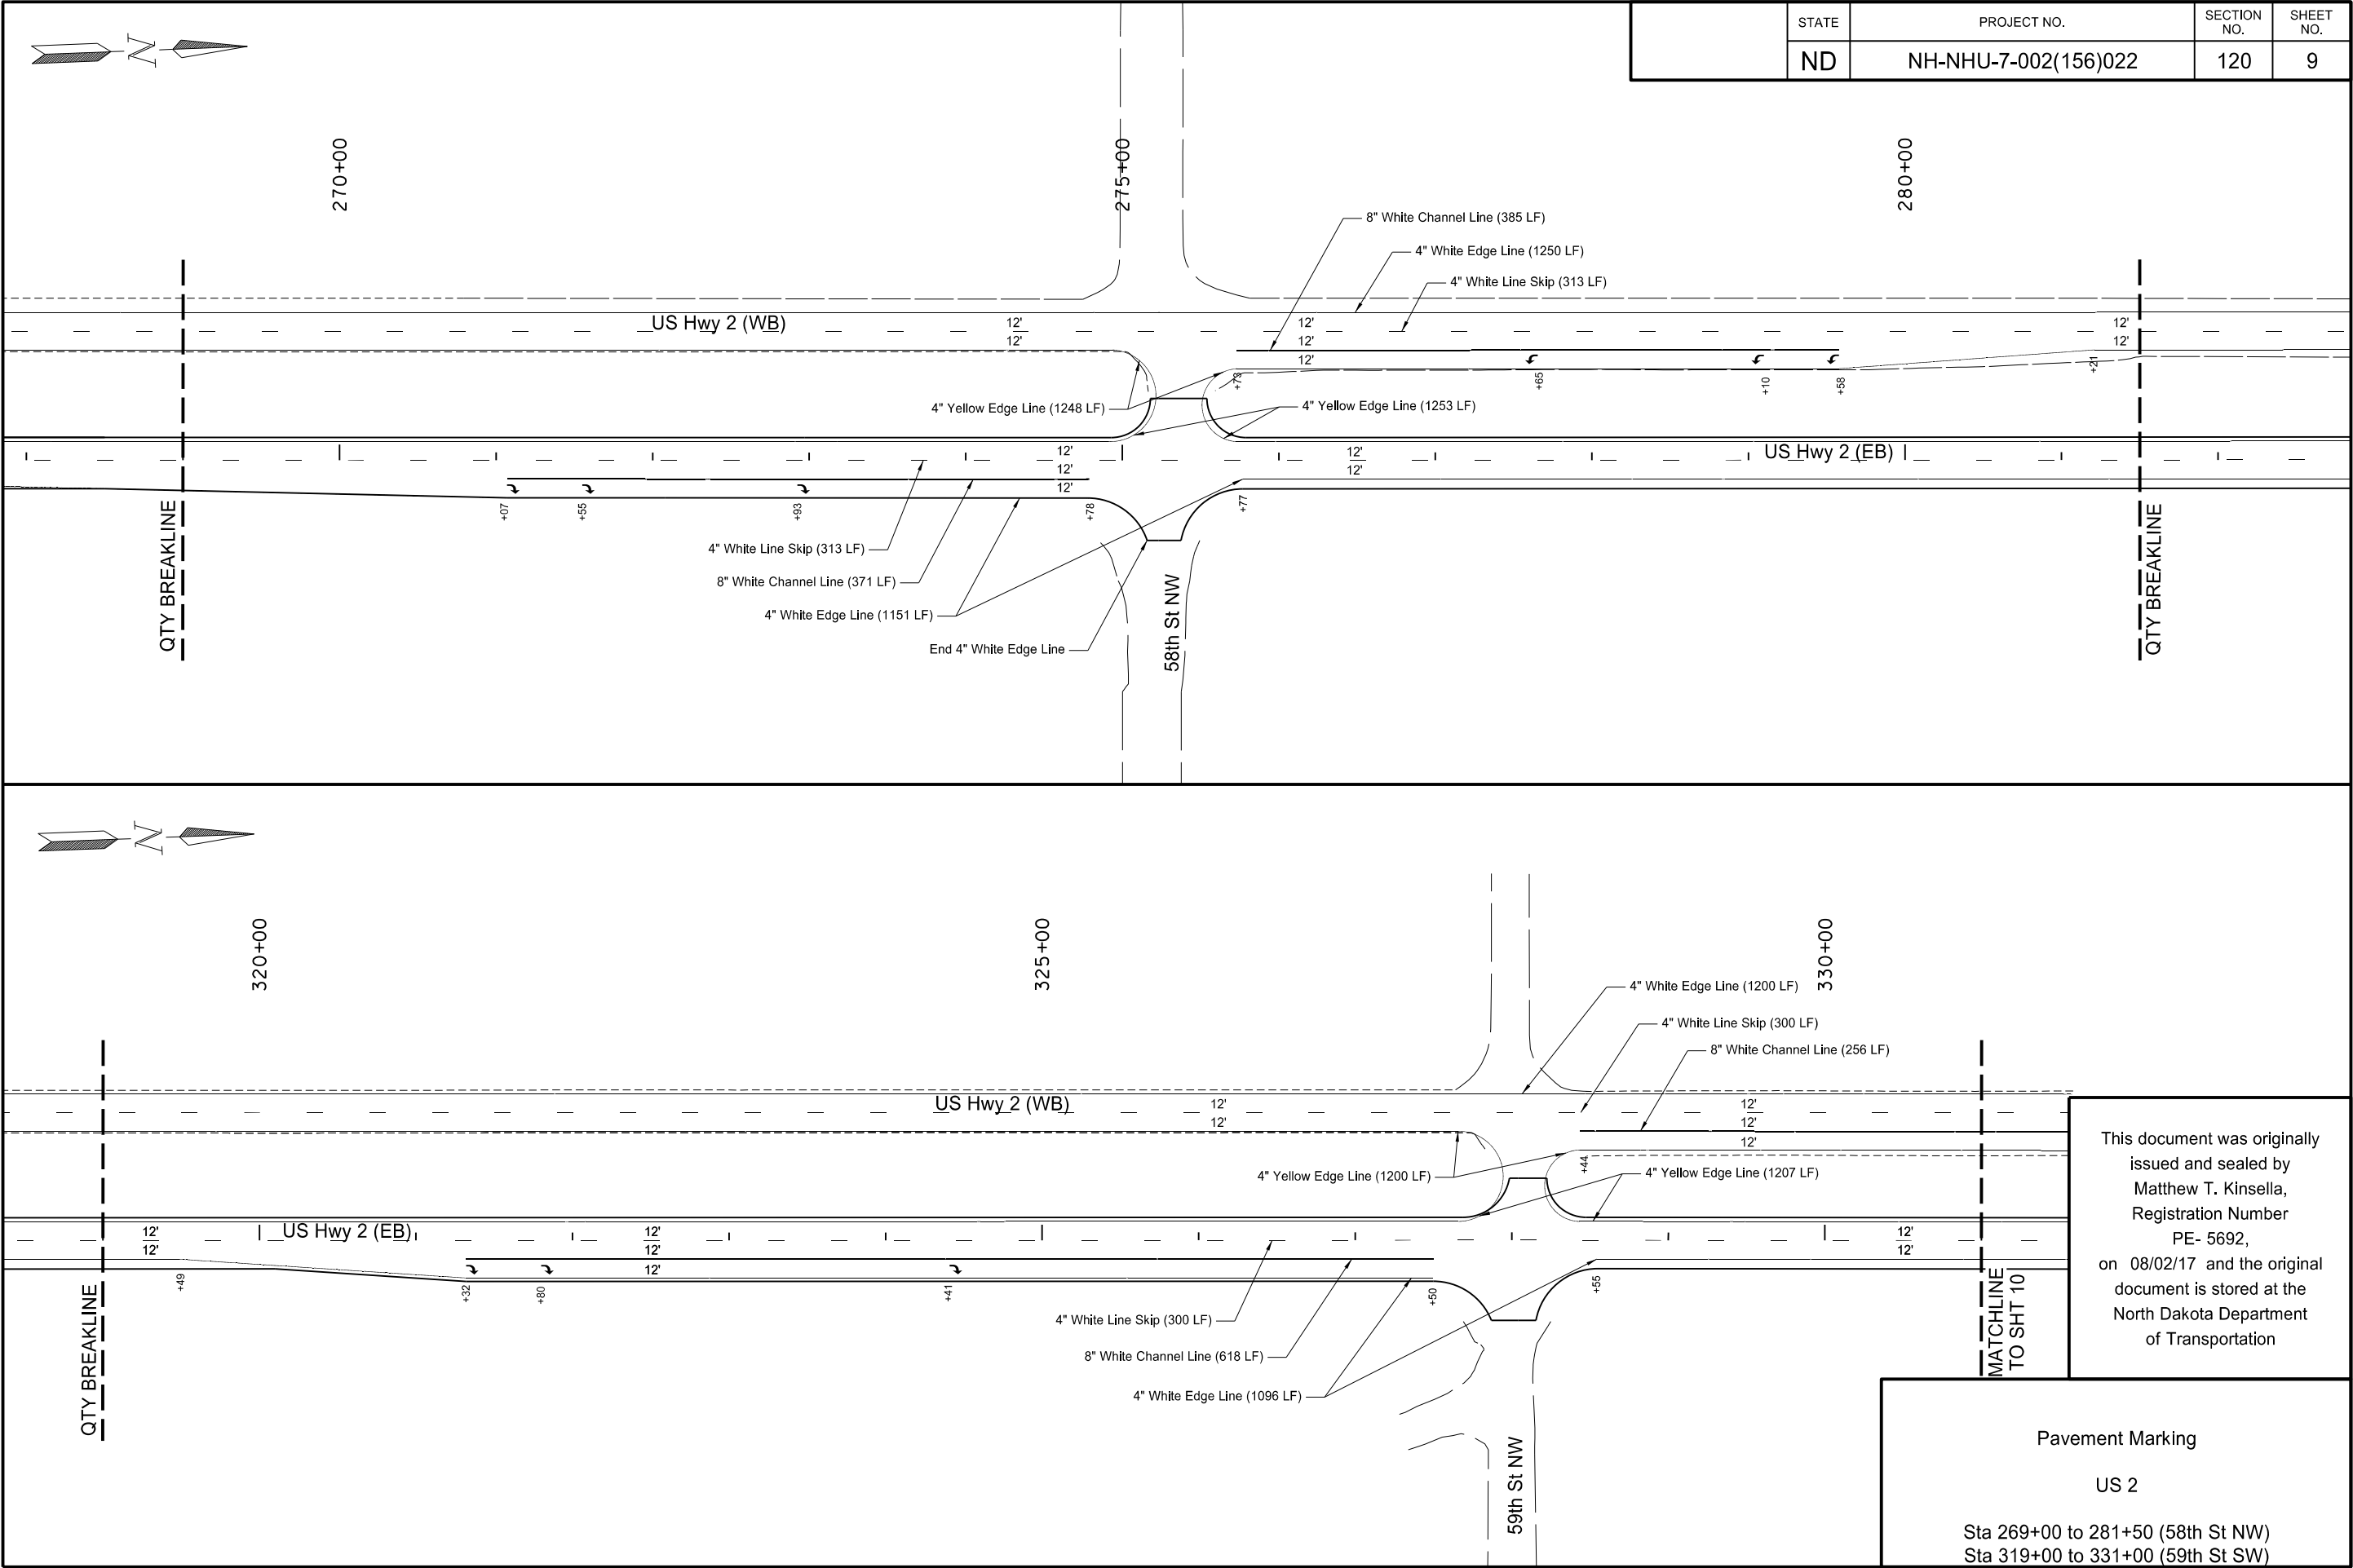


8/2/2017


3:35:36 PM

Sarah.Mohl

 K:\Projects\2016\16.101.0030 NDDOT - US Hwy 2_Williston North_EBI70002156.022\Traffic\120_Pavement Marking\LPVMT_120MK_009.dgn



	STATE	PROJECT NO.	SECTION NO.	SHEET NO.
	ND	NH-NHU-7-002(156)022	120	10

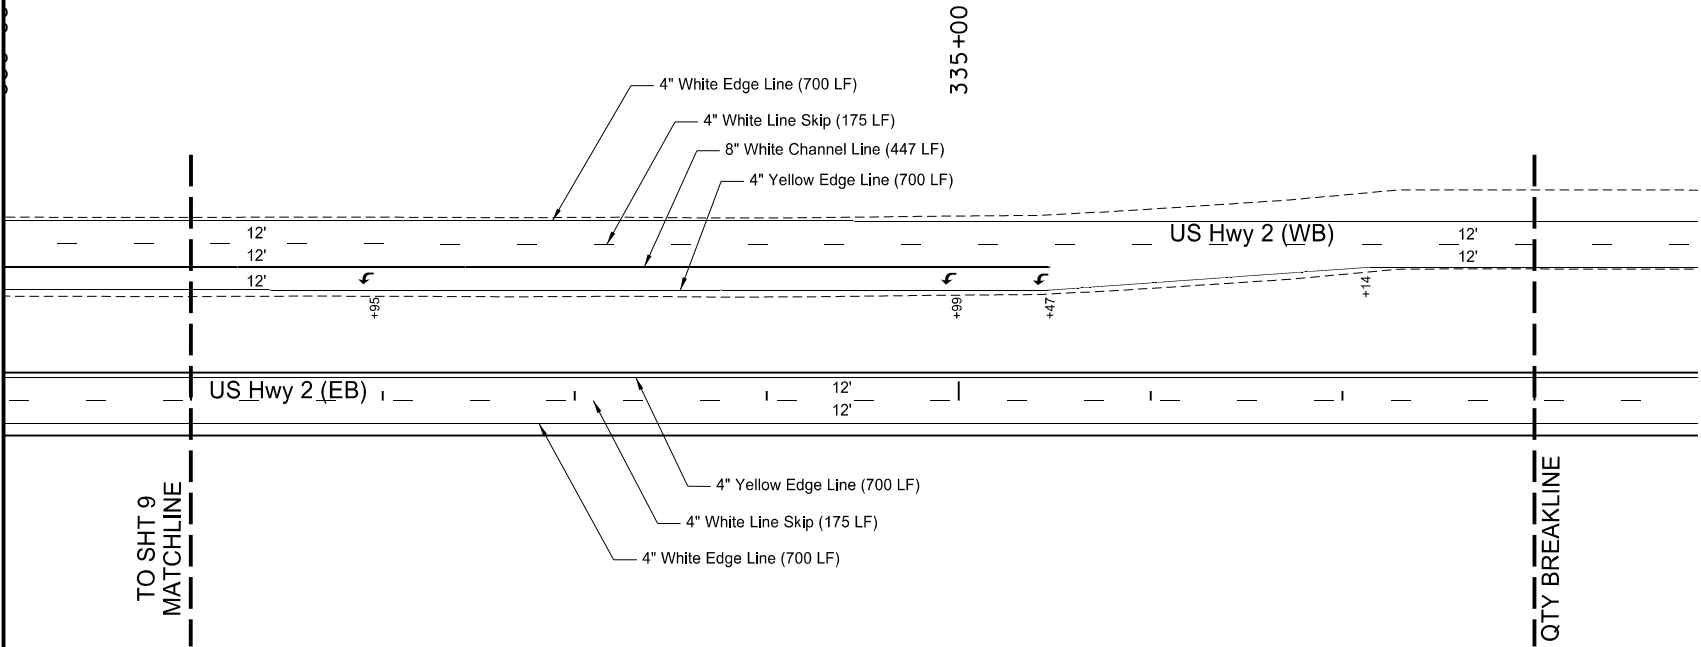


This document was originally issued and sealed by Matthew T. Kinsella, Registration Number PE- 5692, on 08/02/17 and the original document is stored at the North Dakota Department of Transportation


Pavement Marking

US 2

 Sta 331+00 to 338+00



	STATE	PROJECT NO.	SECTION NO.	SHEET NO.
	ND	NH-NHU-7-002(156)022	120	12

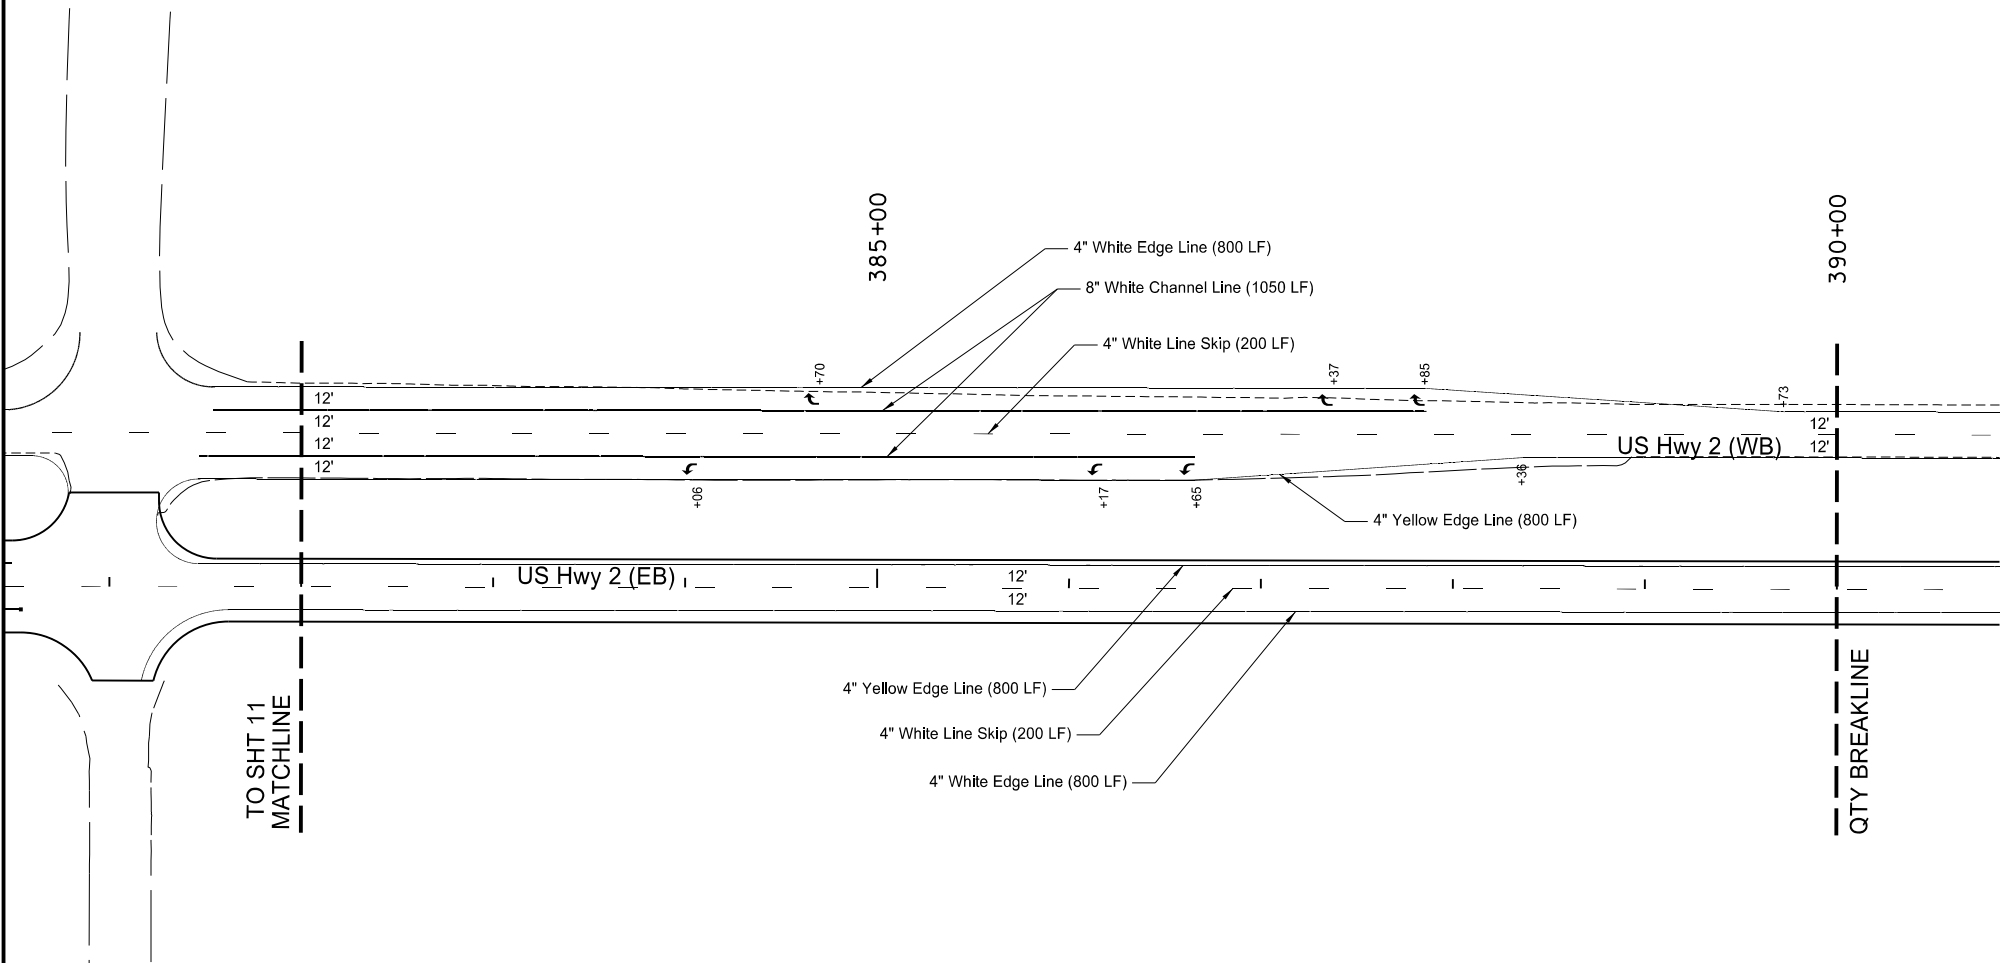



This document was originally issued and sealed by Matthew T. Kinsella, Registration Number PE- 5692, on 08/02/17 and the original document is stored at the North Dakota Department of Transportation

Pavement Marking


US 2

 Sta 382+00 to 390+00

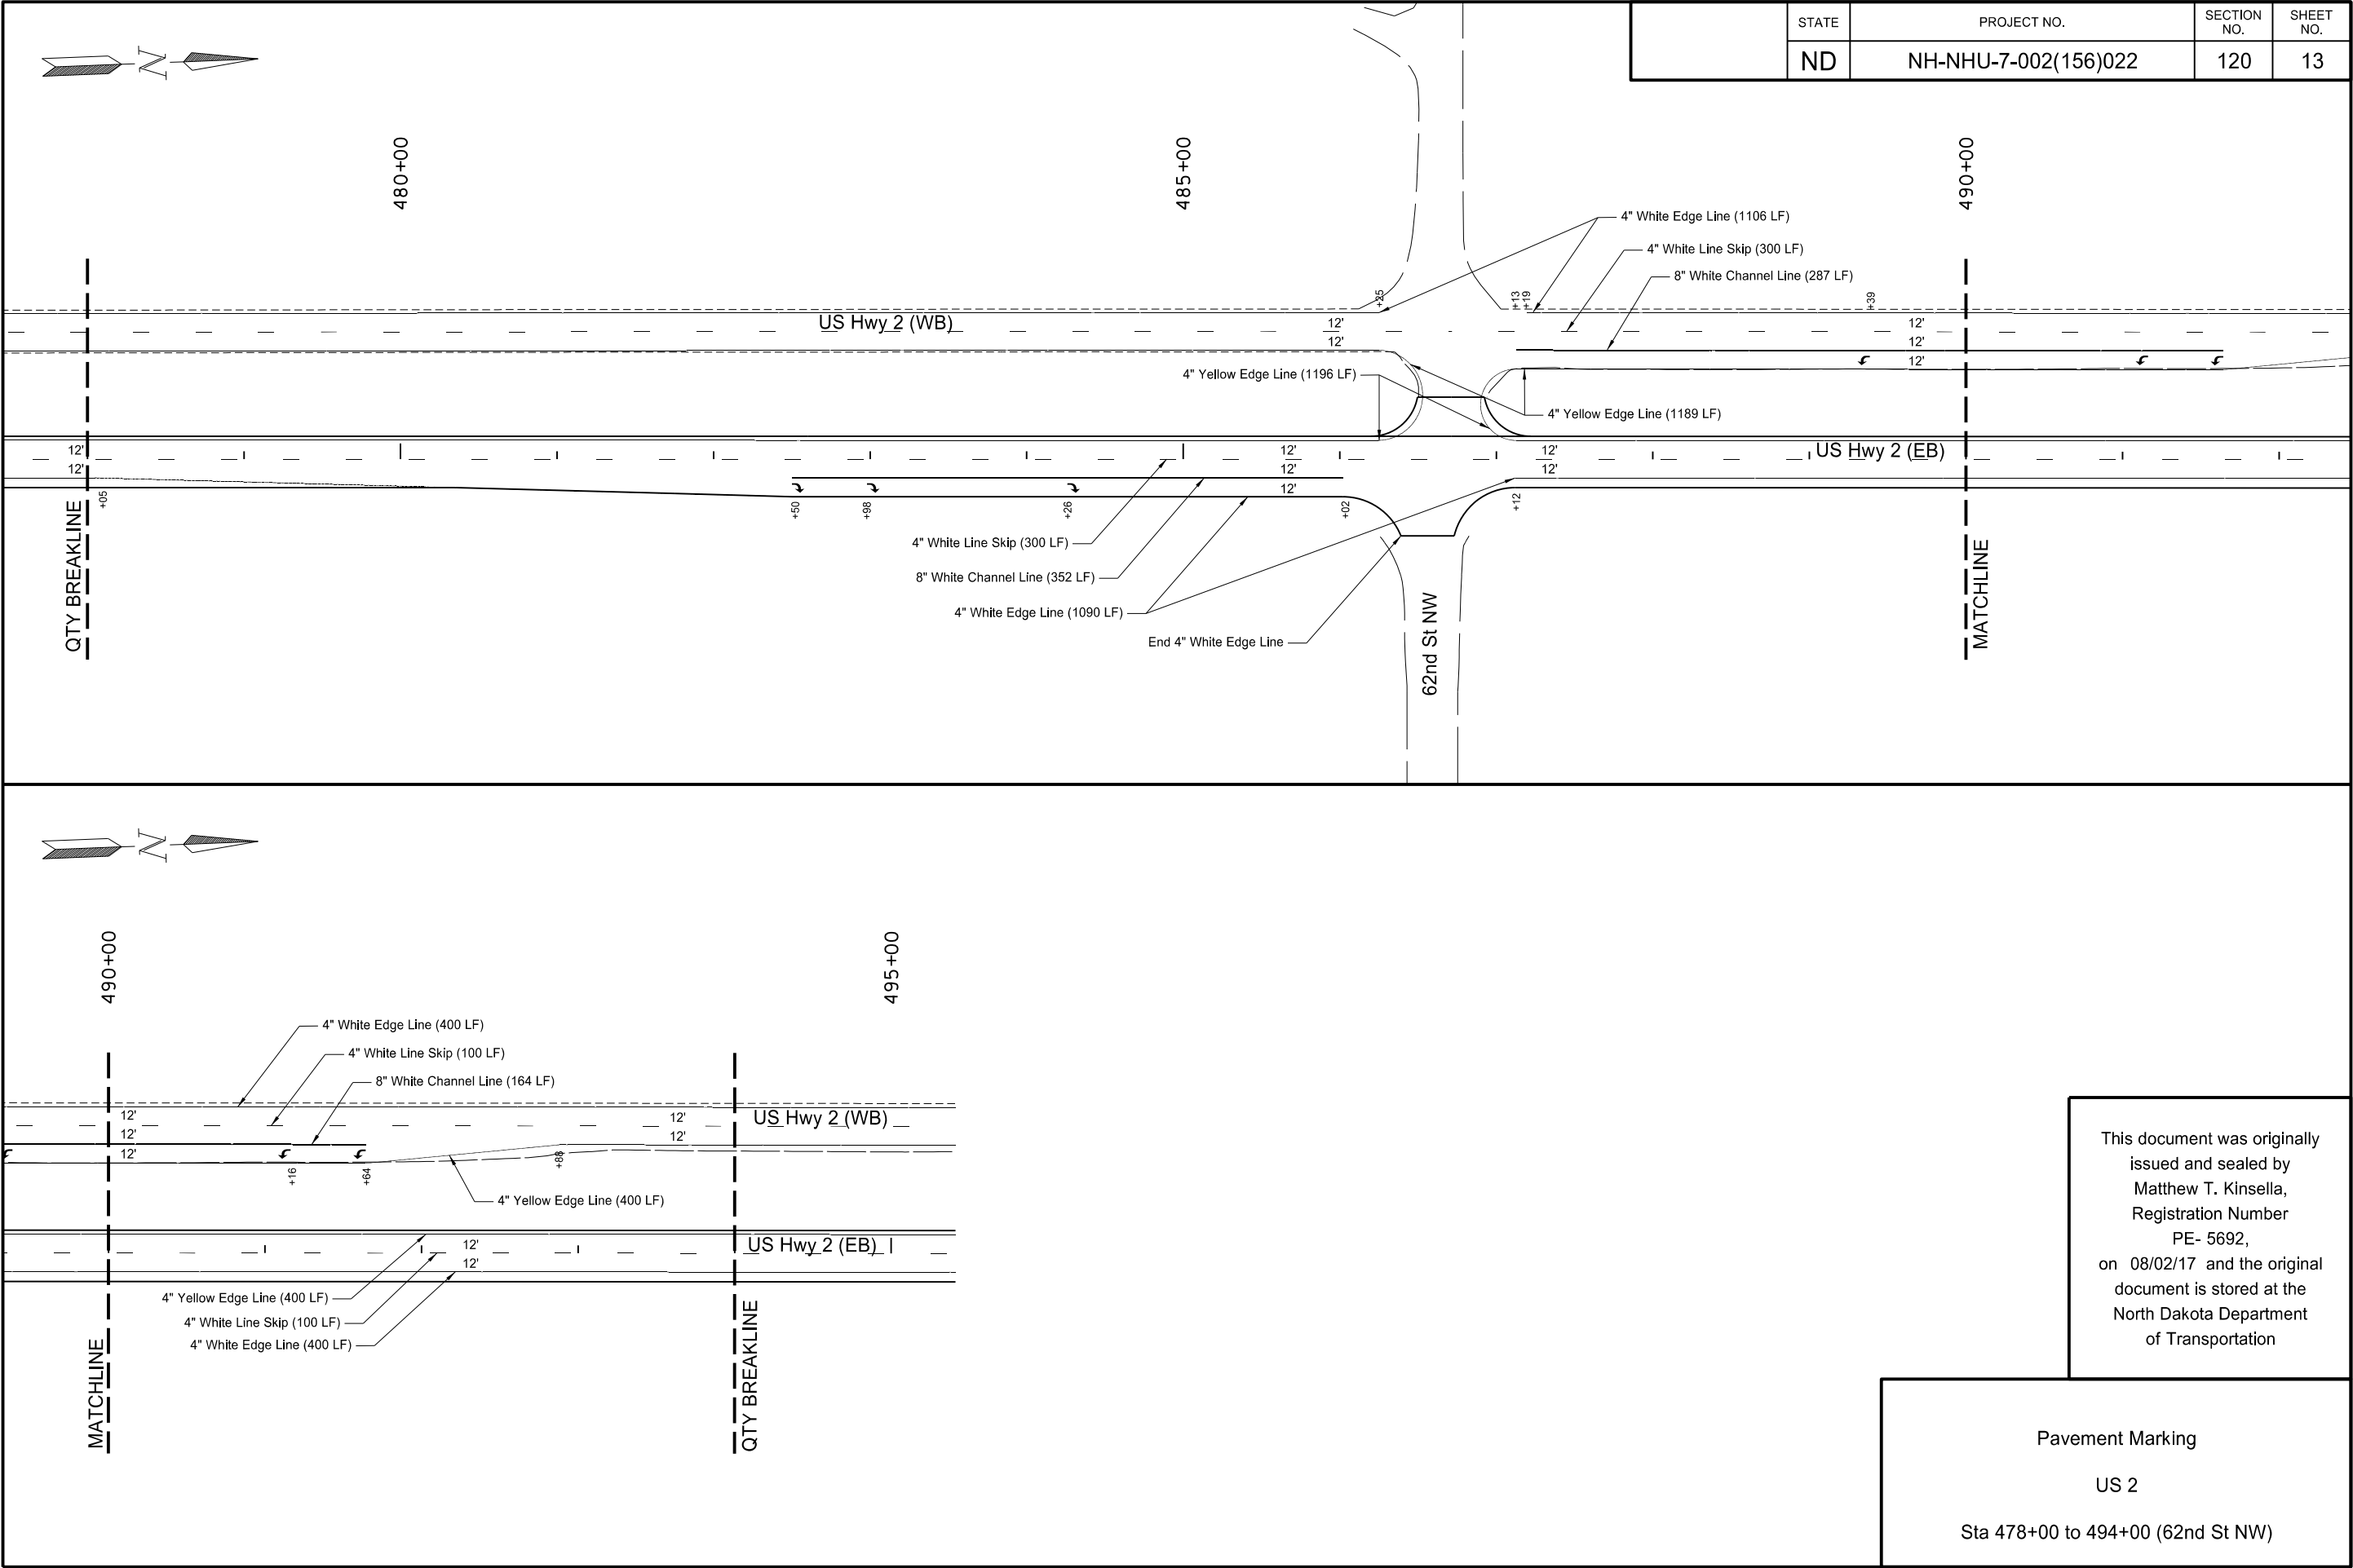



	STATE	PROJECT NO.	SECTION NO.	SHEET NO.
	ND	NH-NHU-7-002(156)022	120	14

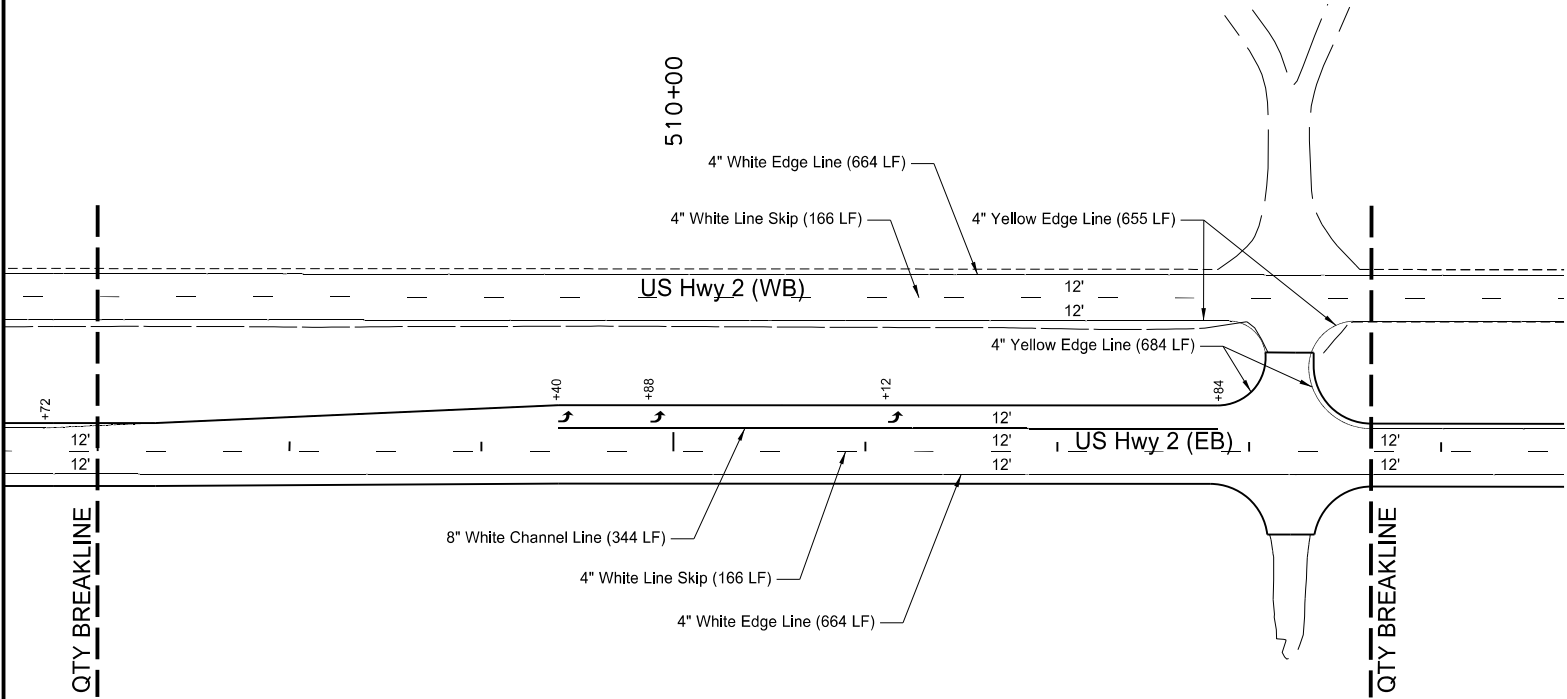


This document was originally issued and sealed by Matthew T. Kinsella, Registration Number PE- 5692, on 08/02/17 and the original document is stored at the North Dakota Department of Transportation

Pavement Marking

US 2

Sta 507+00 to 513+64

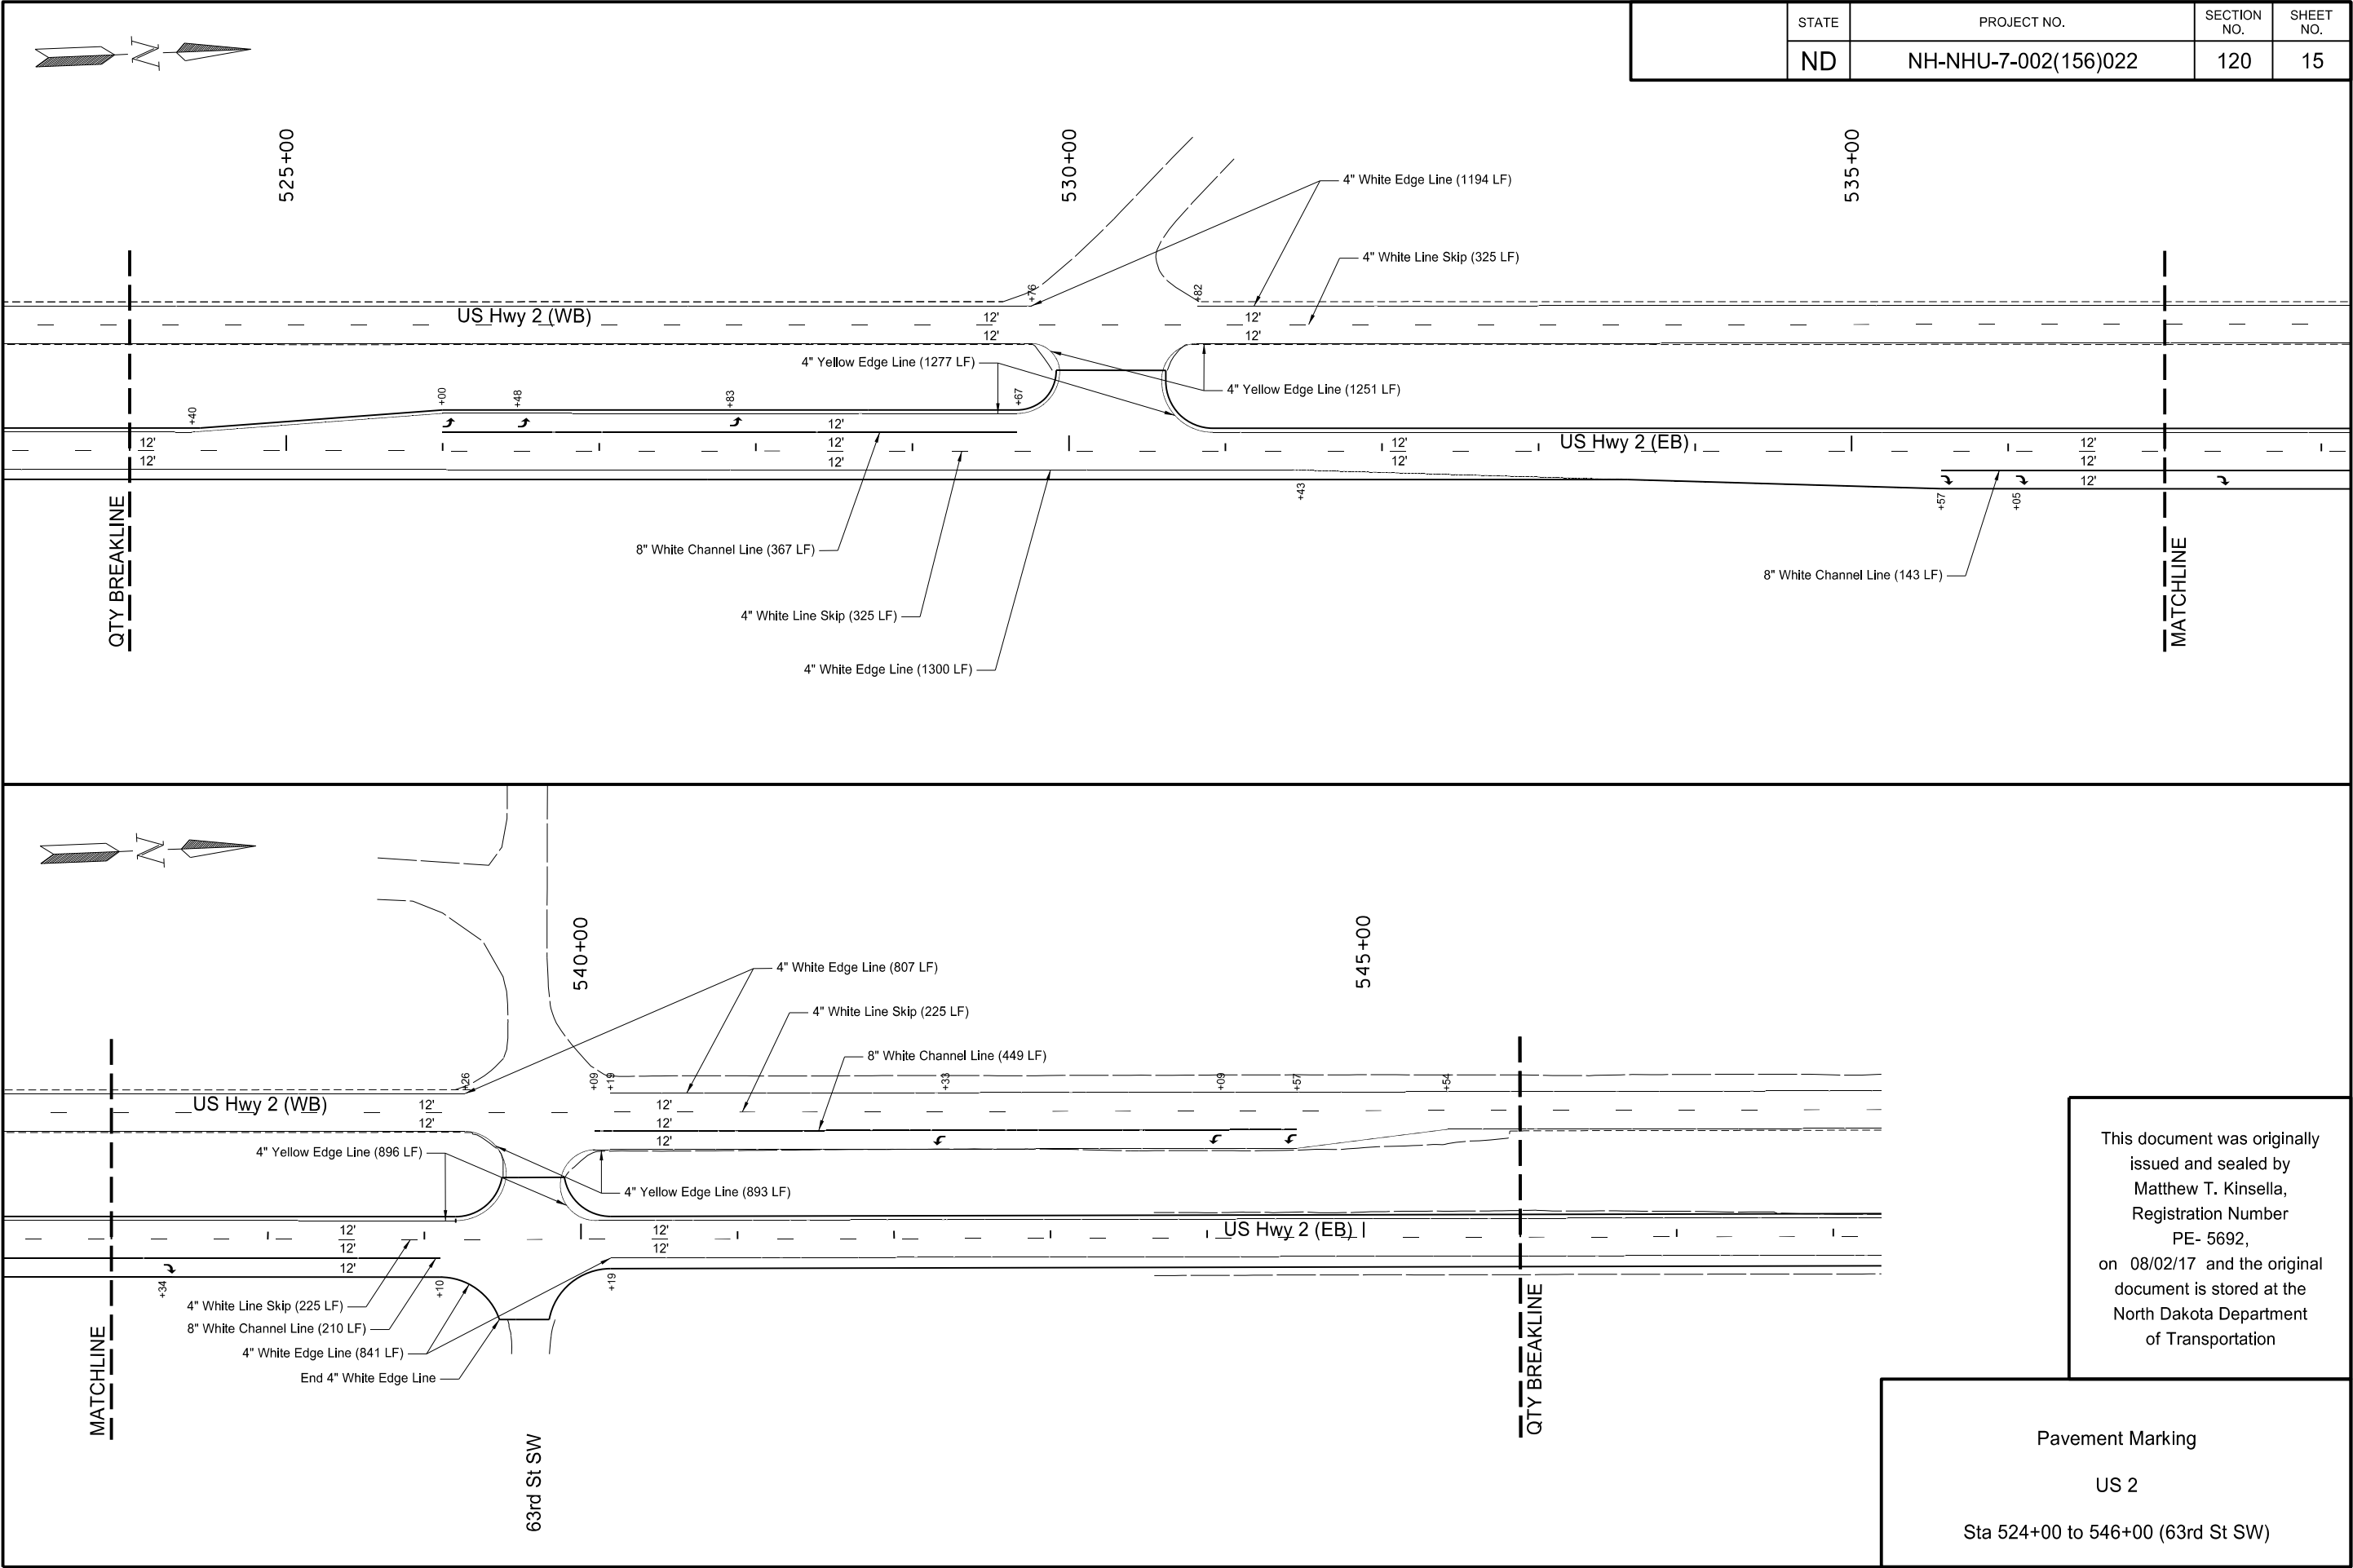



8/2/2017

3:35:41 PM


Sarah.Mohl

 K:\Projects\2016\16.101.0030 NDDOT - US Hwy 2_Williston North_EBI70002156.022\Traffic\120_Pavement Marking\LPVMT_120MK_015.dgn

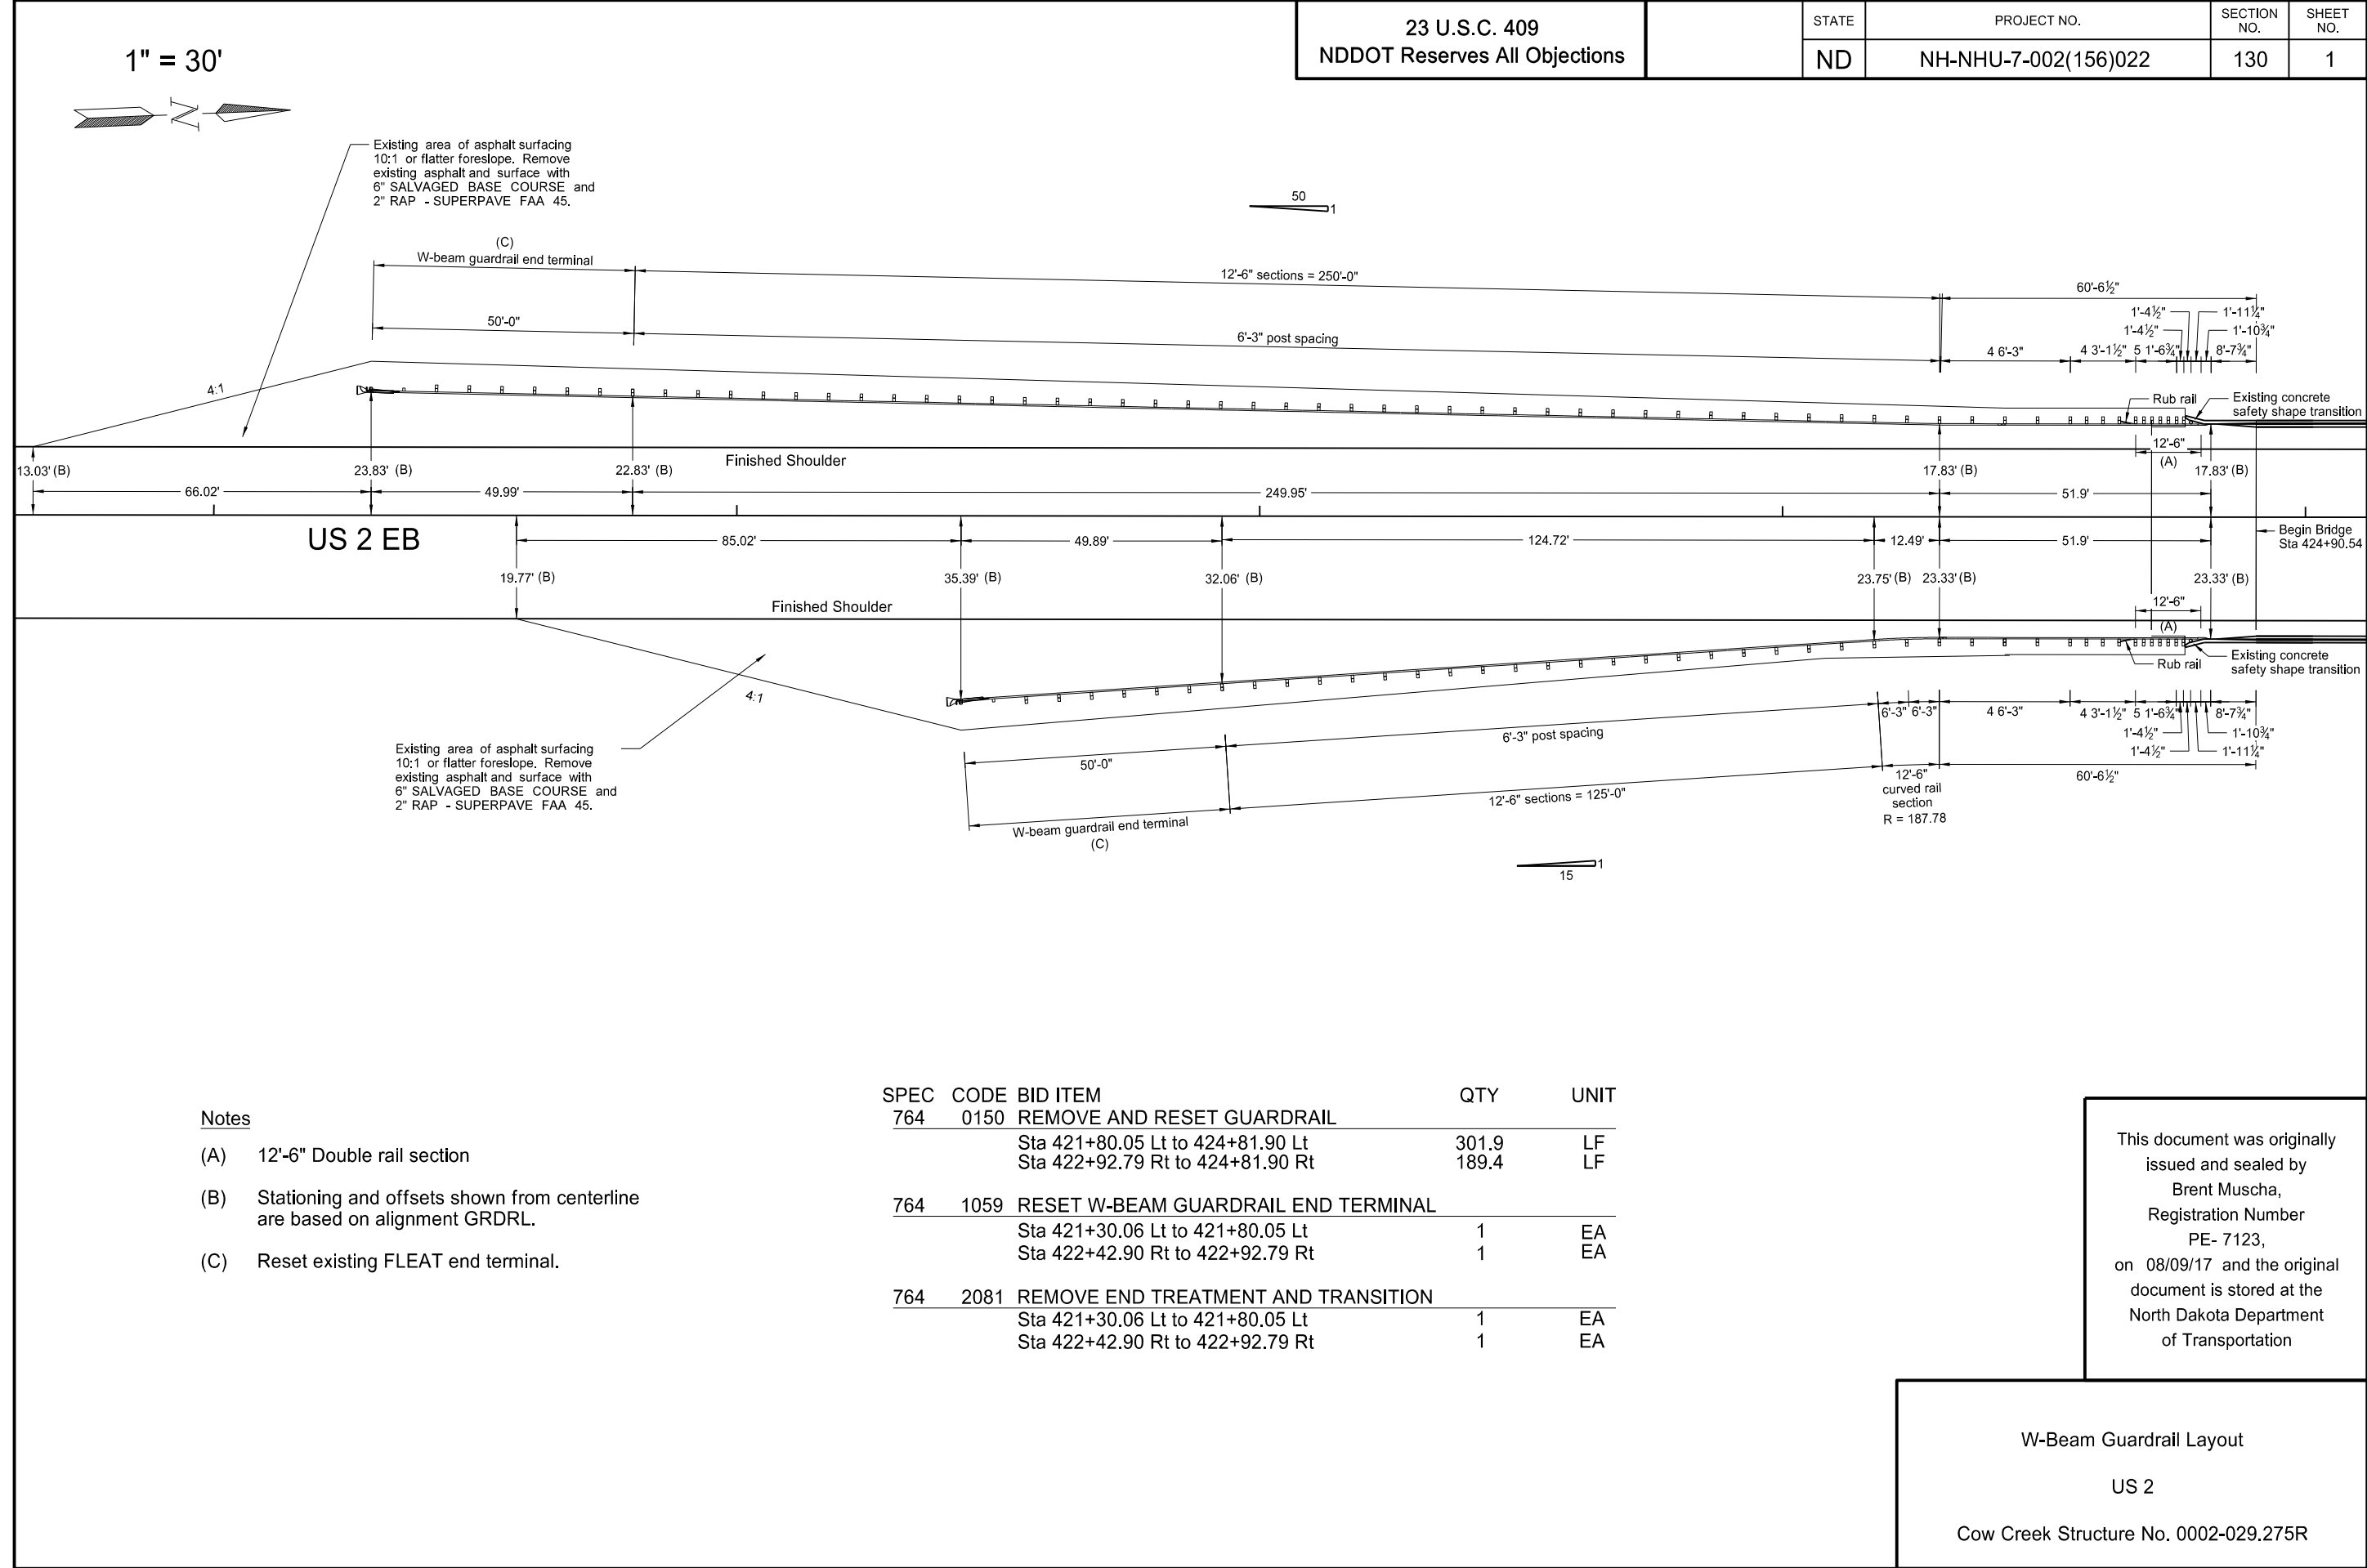




STATE	PROJECT NO.	SECTION NO.	SHEET NO.
ND	NH-NHU-7-002(156)022	140	1

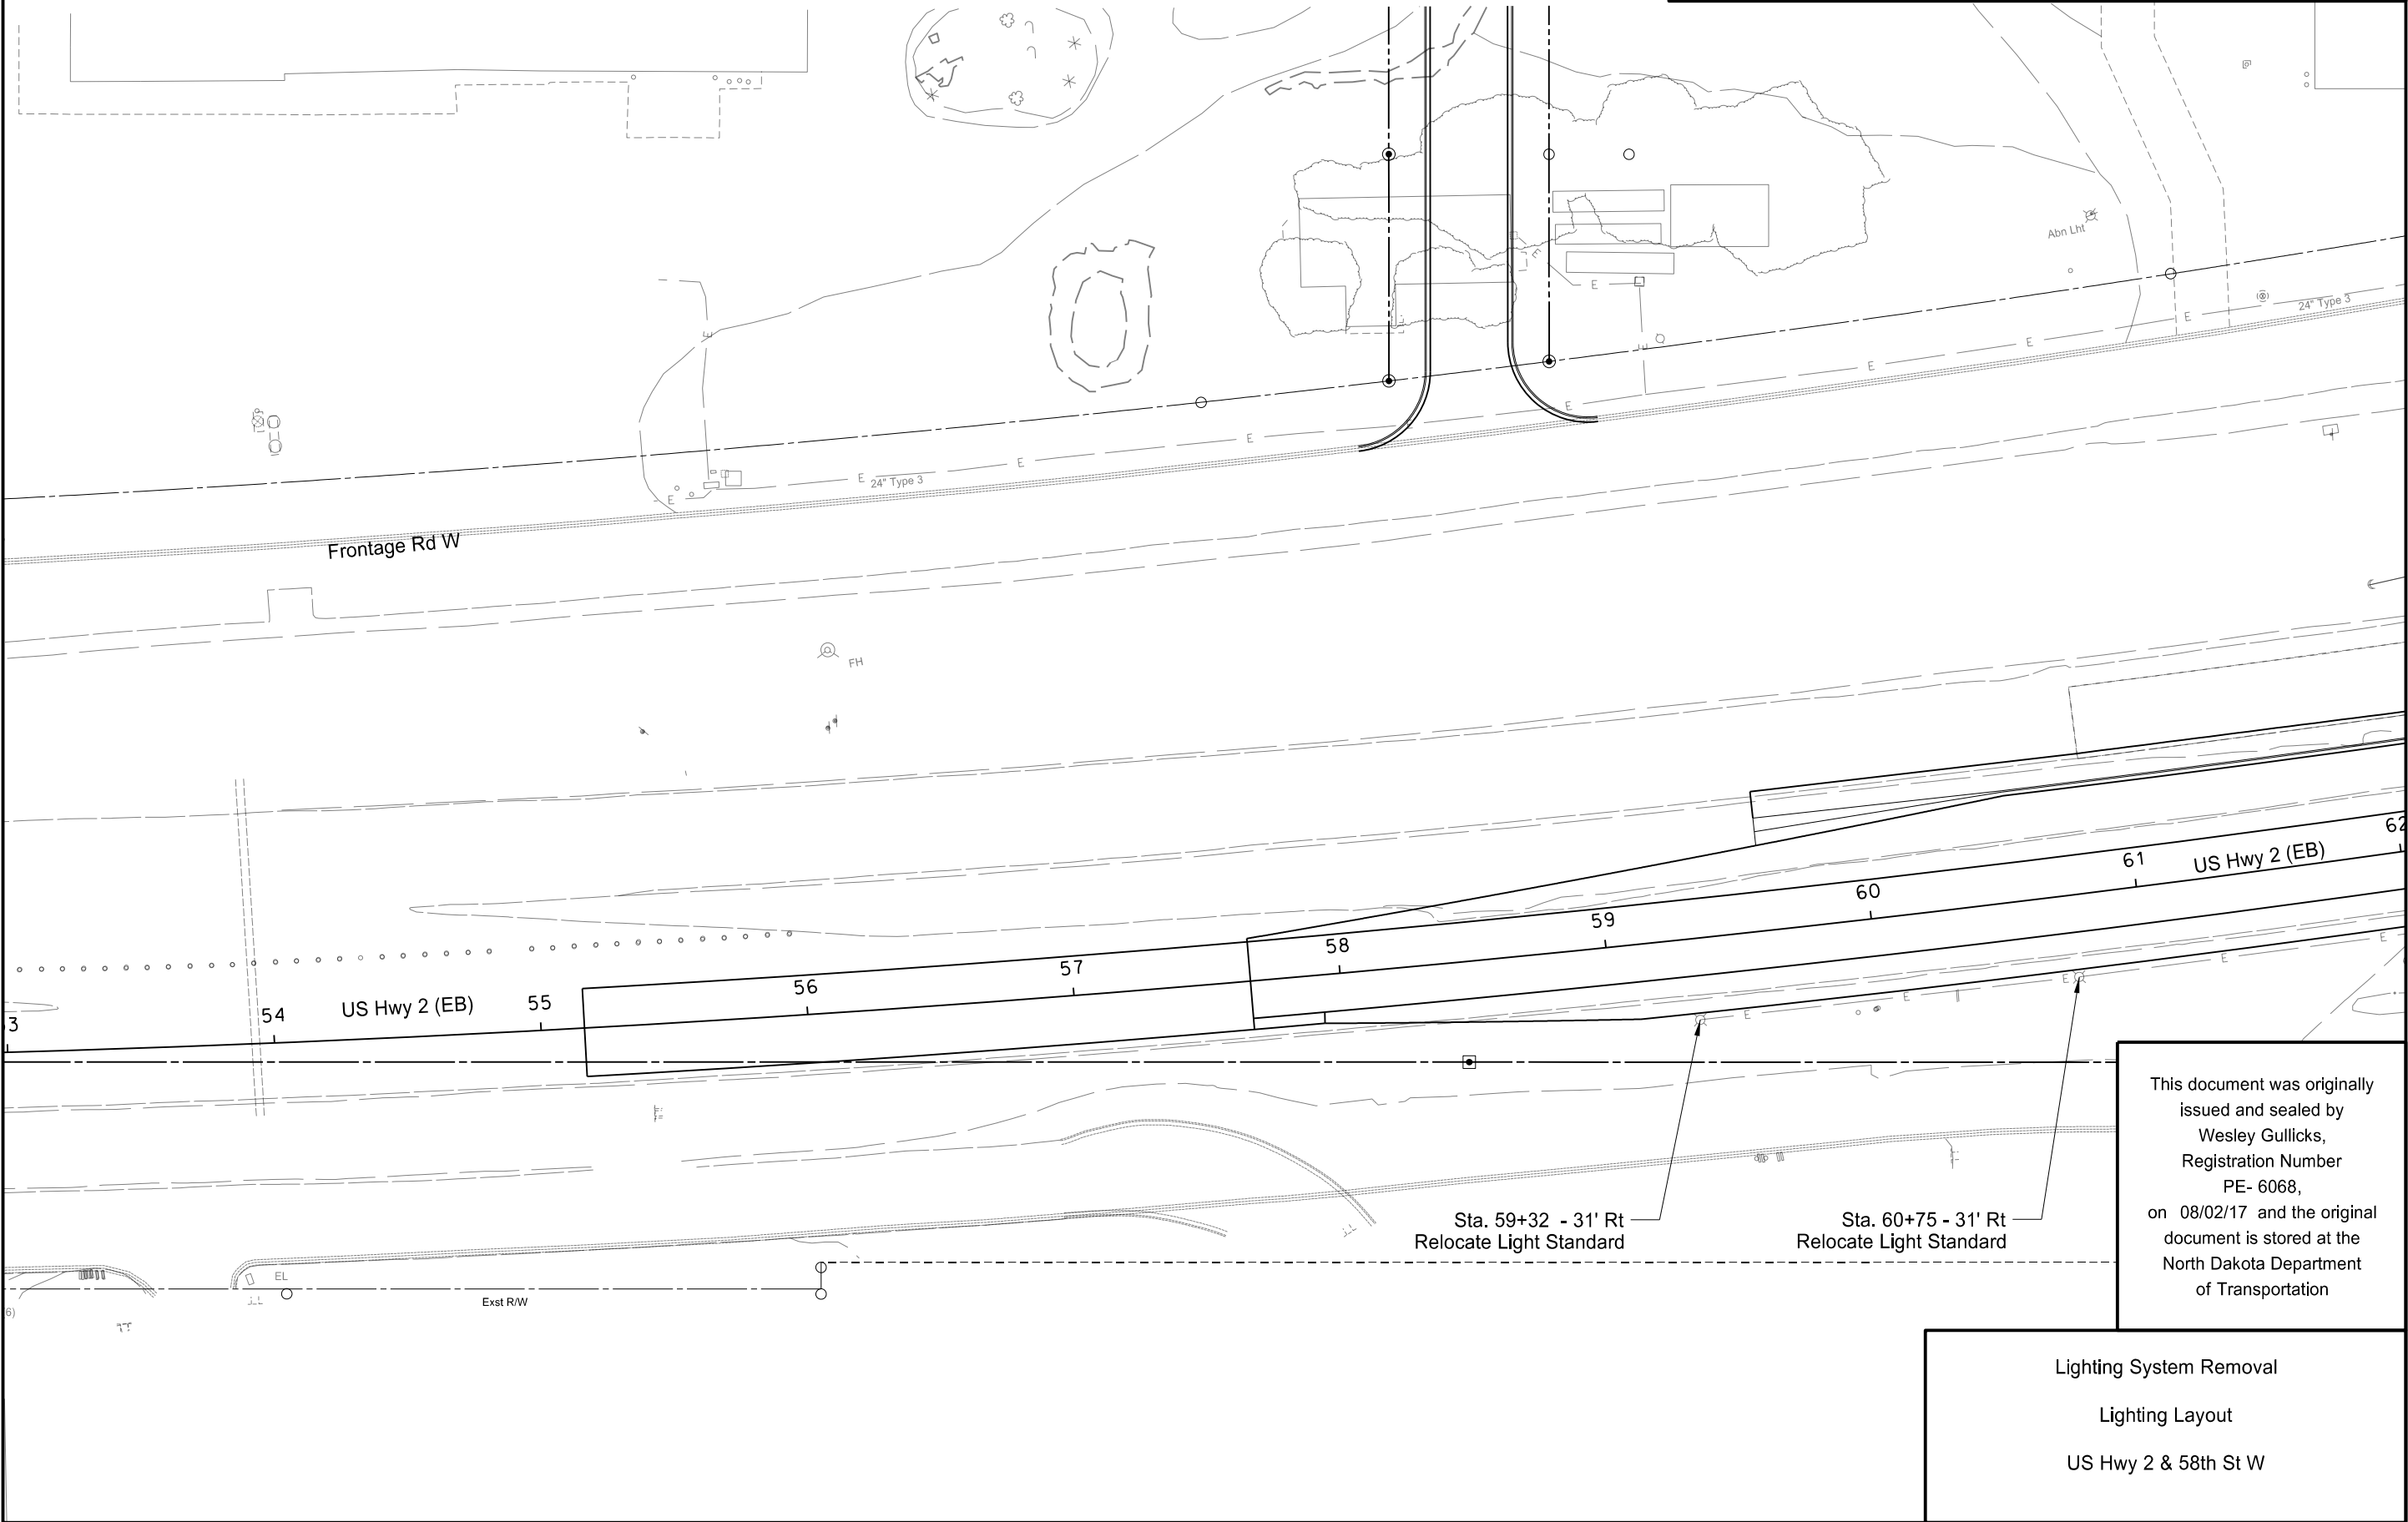

This document was originally issued and sealed by Wesley Gullicks, Registration Number PE- 6068, on 08/02/17 and the original document is stored at the North Dakota Department of Transportation


Lighting System Removal
Lighting Layout
US Hwy 2 & 58th St W

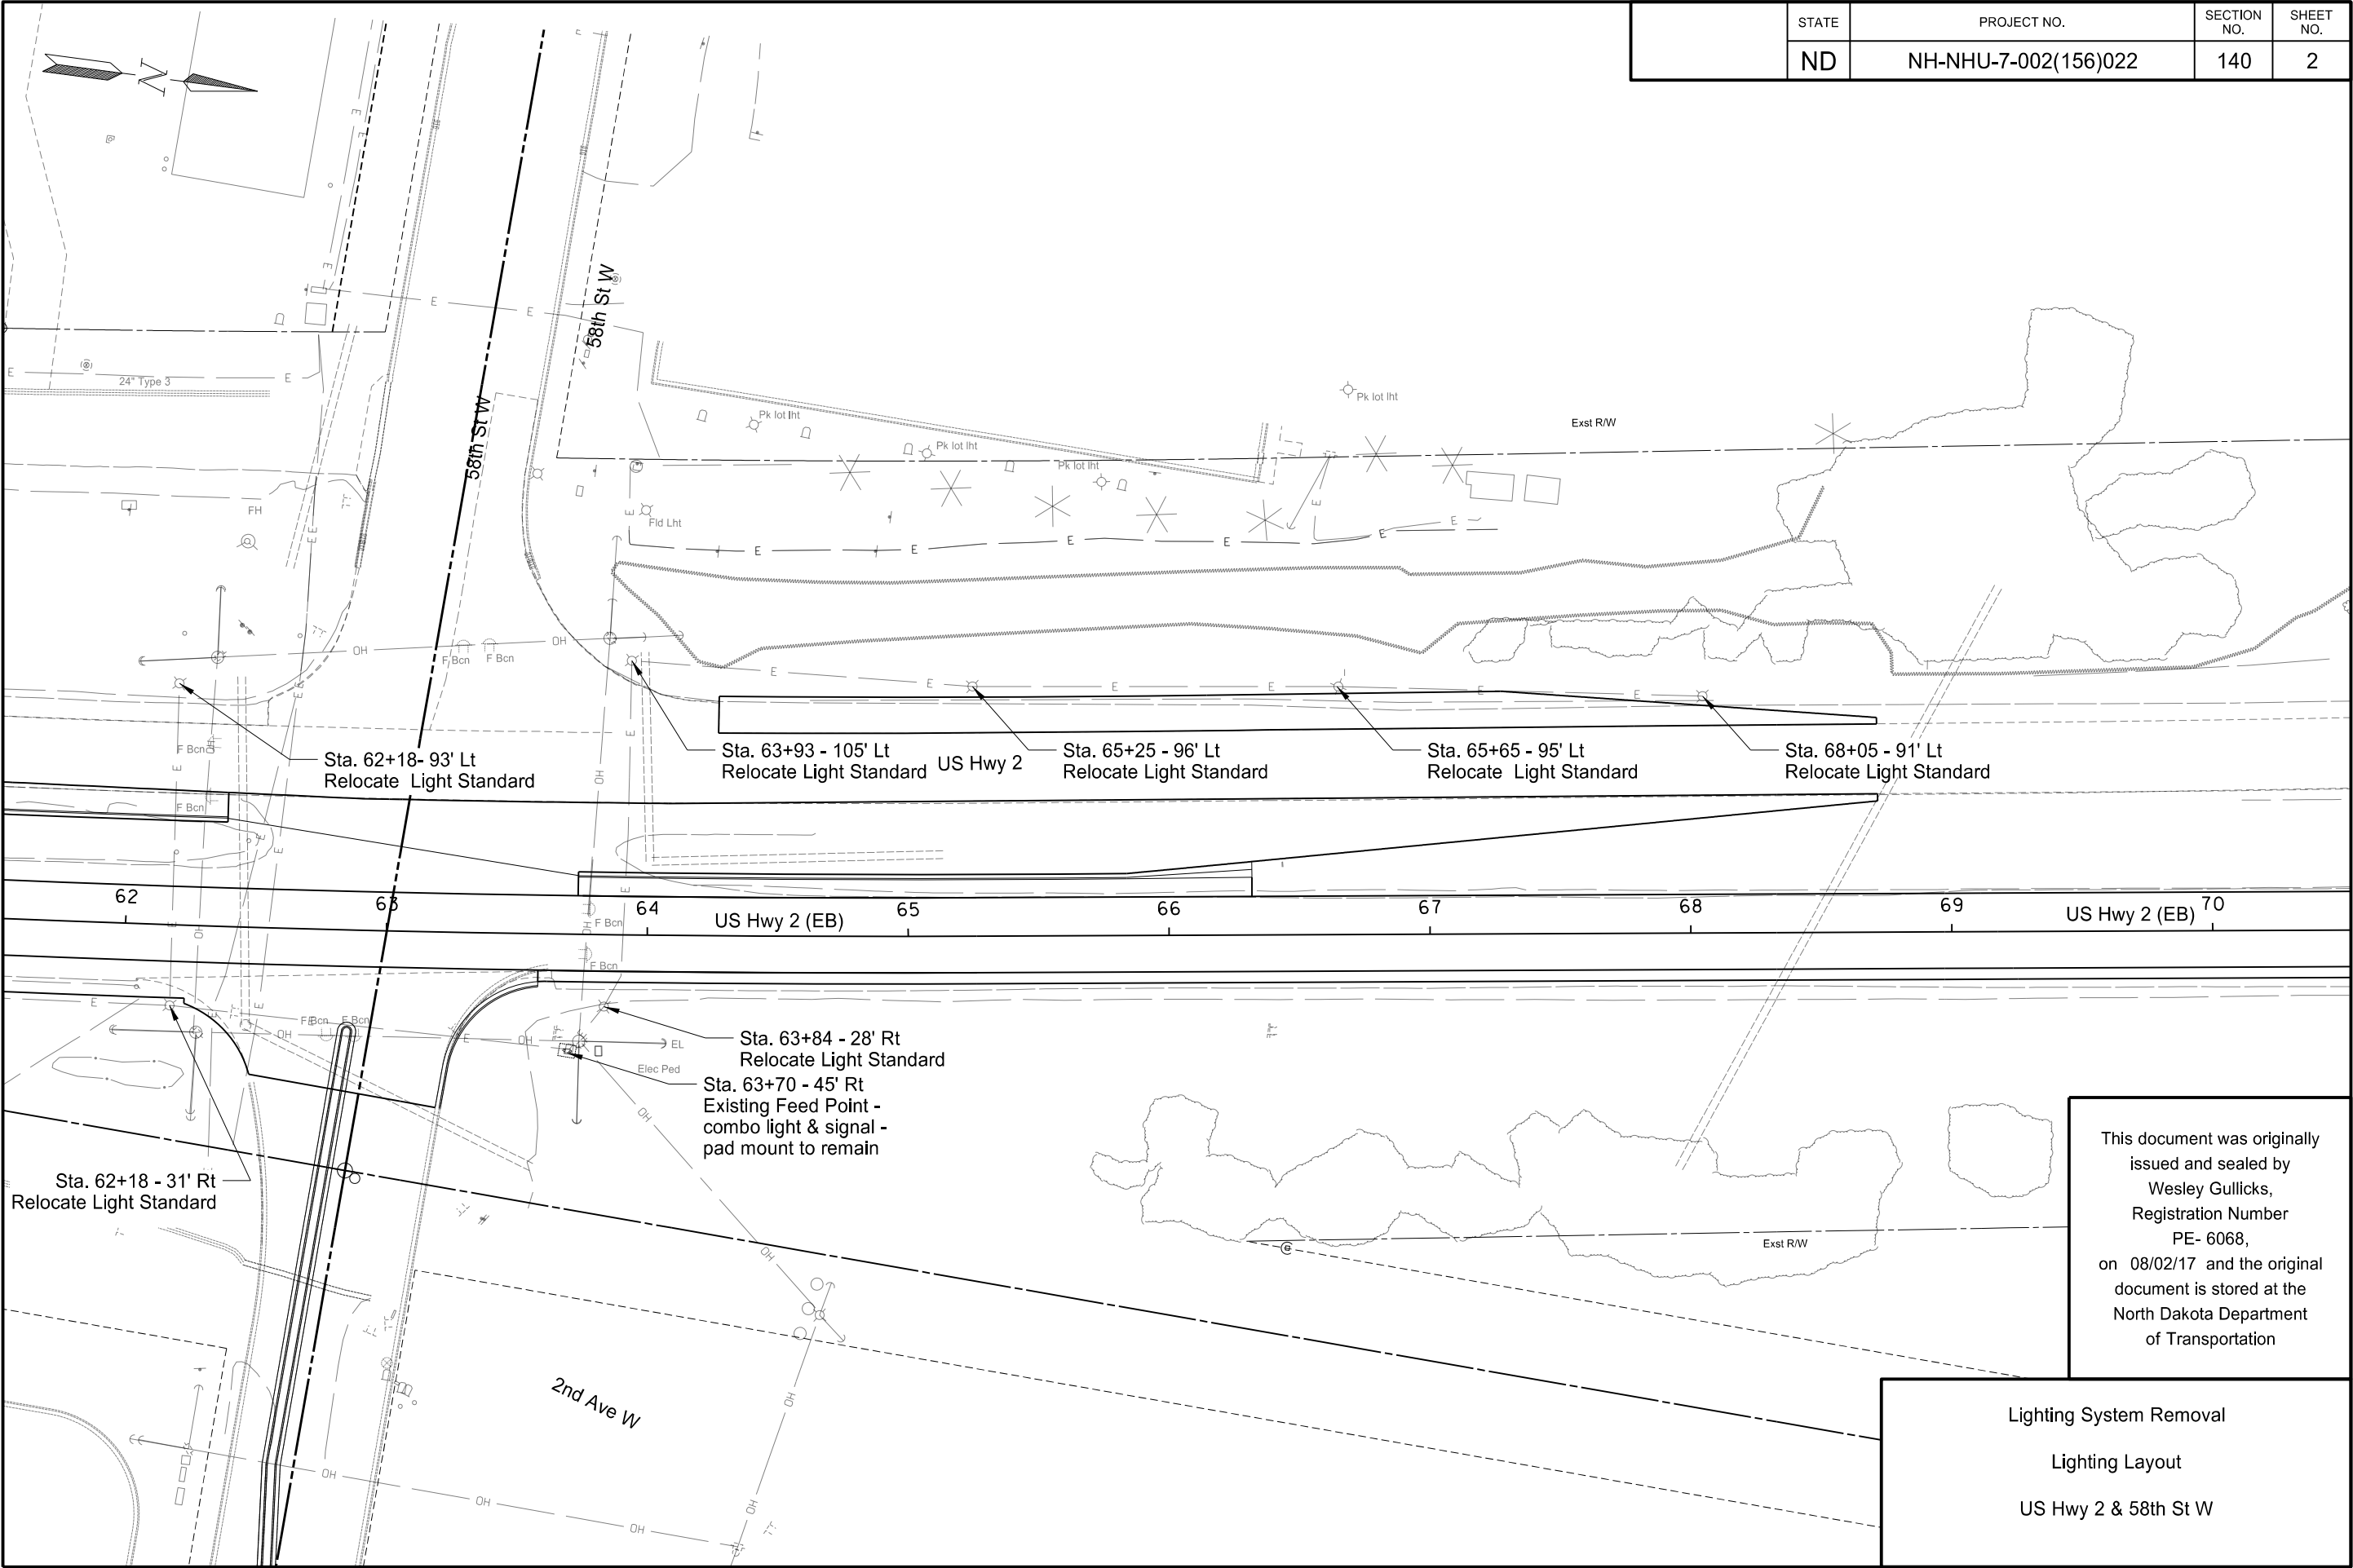


STATE	PROJECT NO.	SECTION NO.	SHEET NO.
ND	NH-NHU-7-002(156)022	140	2

This document was originally issued and sealed by Wesley Gullicks, Registration Number PE- 6068, on 08/02/17 and the original document is stored at the North Dakota Department of Transportation

 Lighting System Removal
Lighting Layout
US Hwy 2 & 58th St W




STATE	PROJECT NO.	SECTION NO.	SHEET NO.
ND	NH-NHU-7-002(156)022	140	3

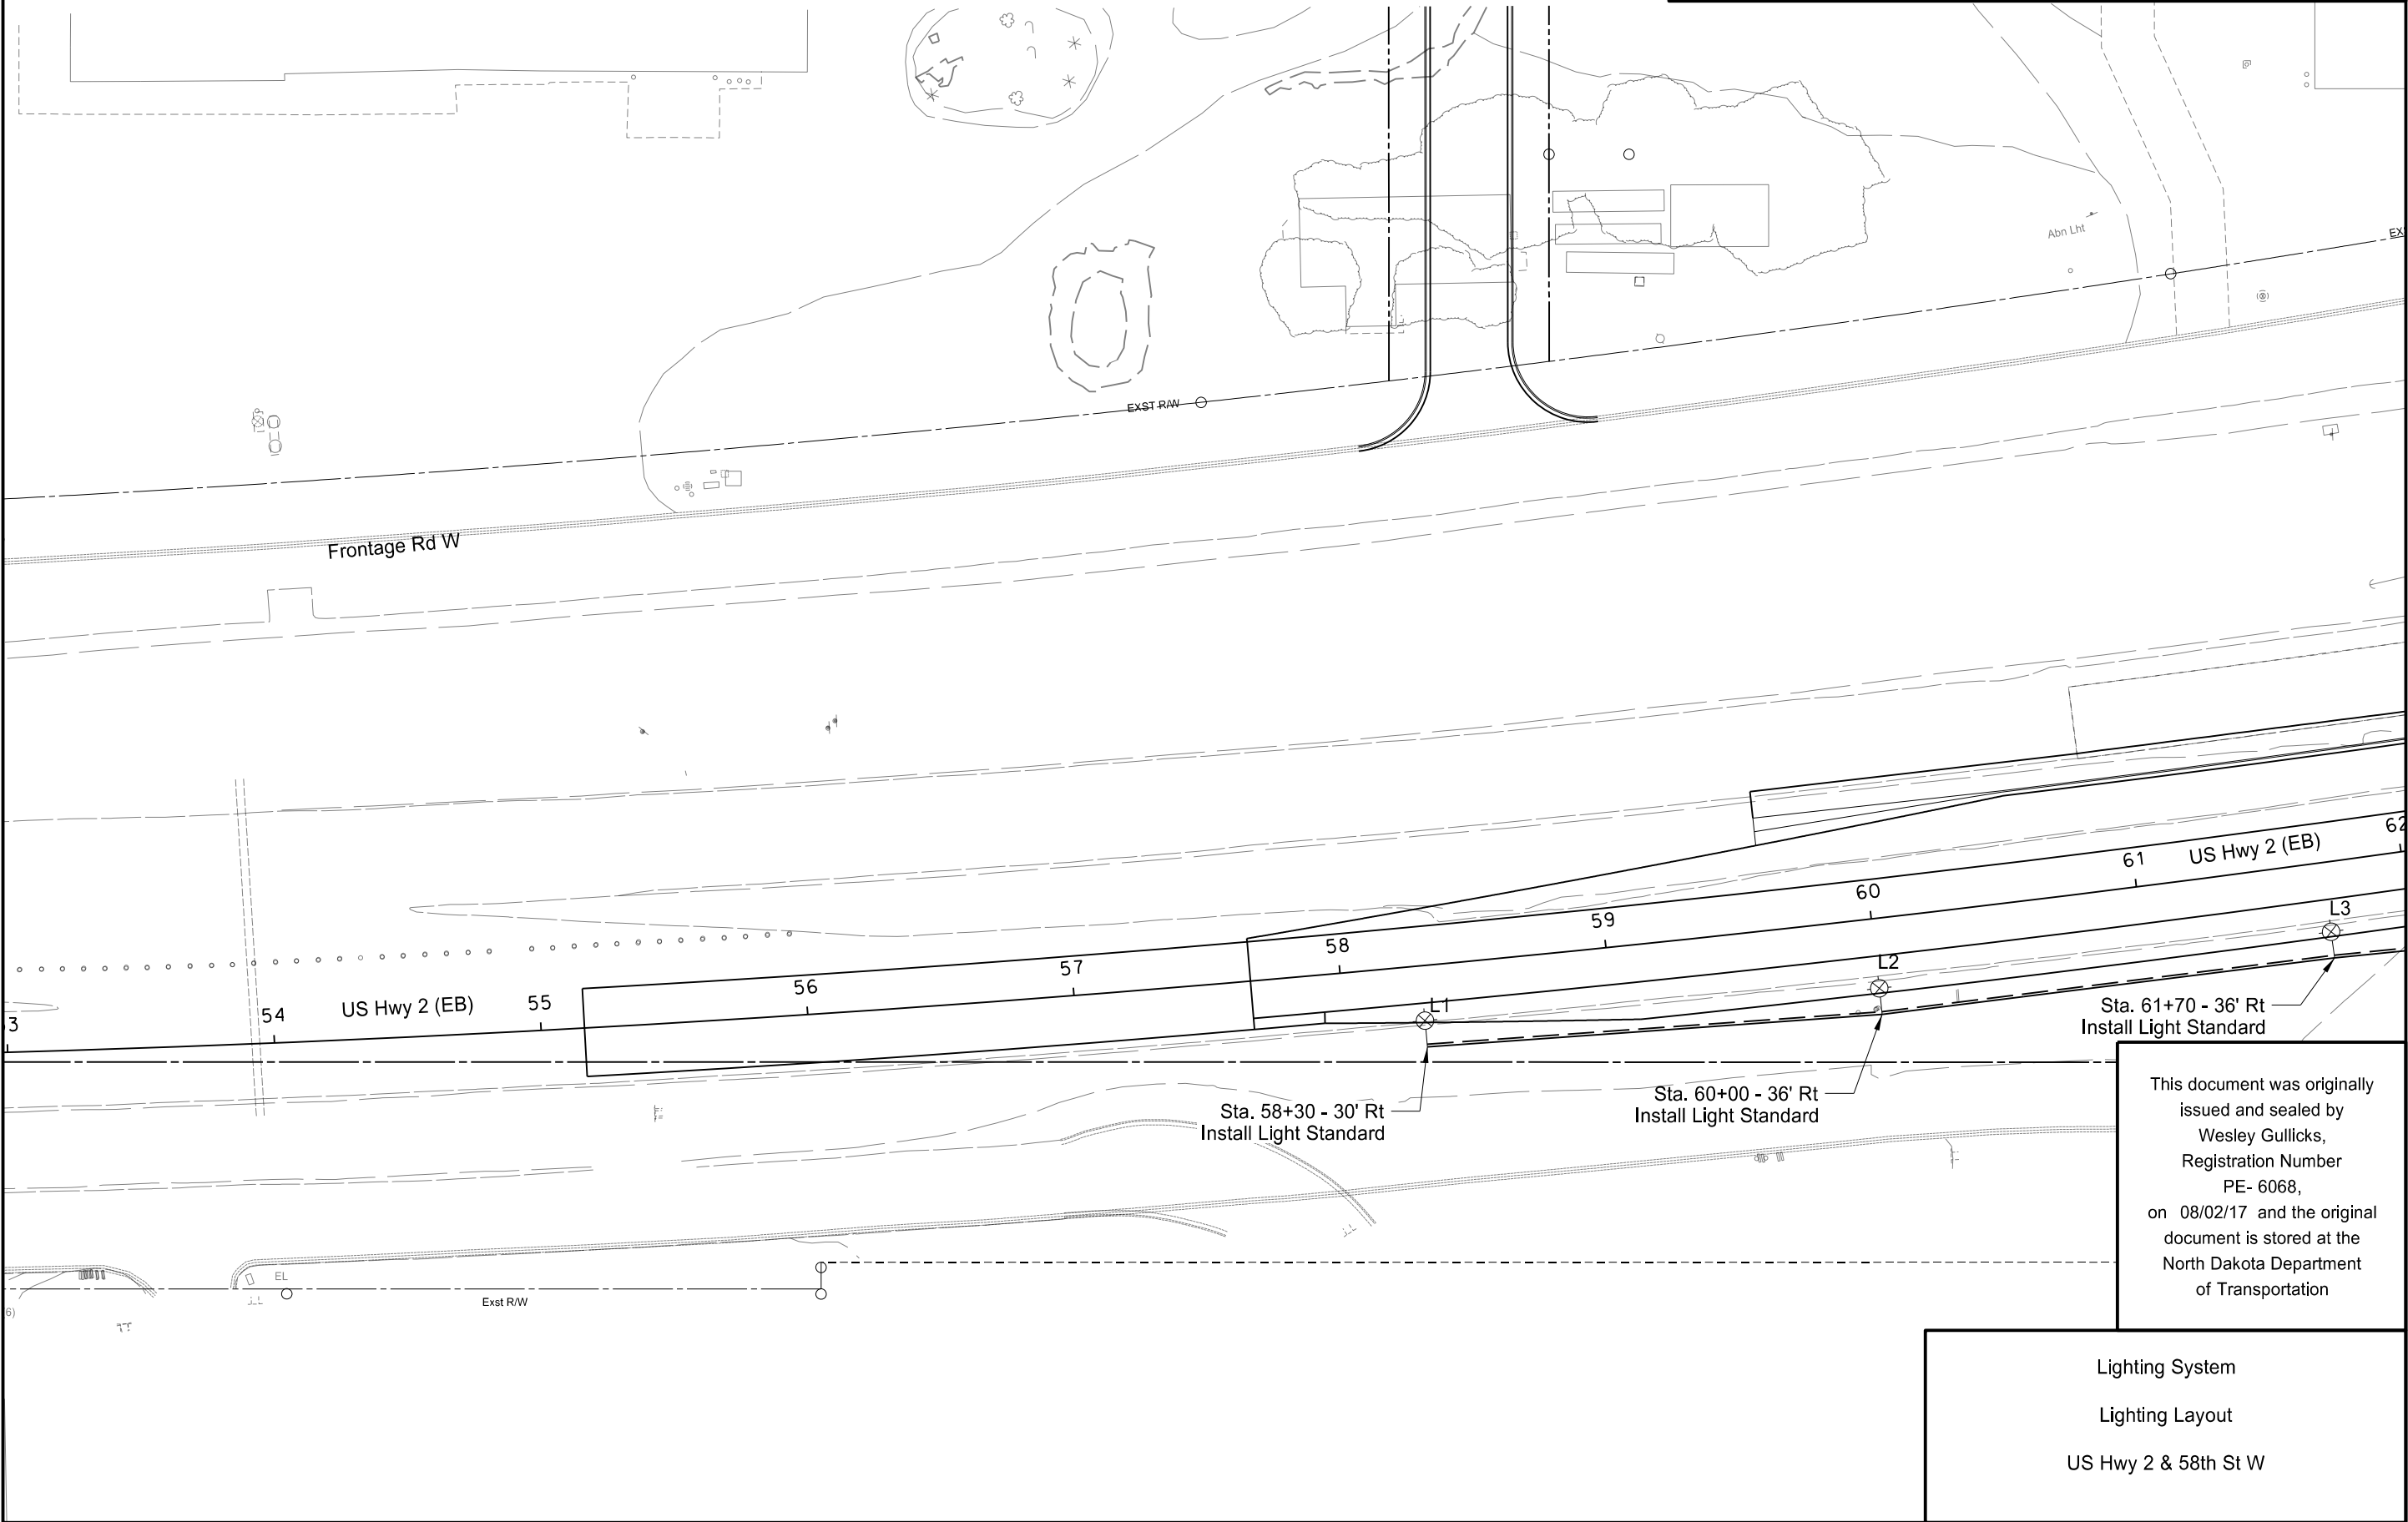

This document was originally issued and sealed by Wesley Gullicks, Registration Number PE- 6068, on 08/02/17 and the original document is stored at the North Dakota Department of Transportation

Lighting System
Lighting Layout
US Hwy 2 & 58th St W

STATE	PROJECT NO.	SECTION NO.	SHEET NO.
ND	NH-NHU-7-002(156)022	140	4

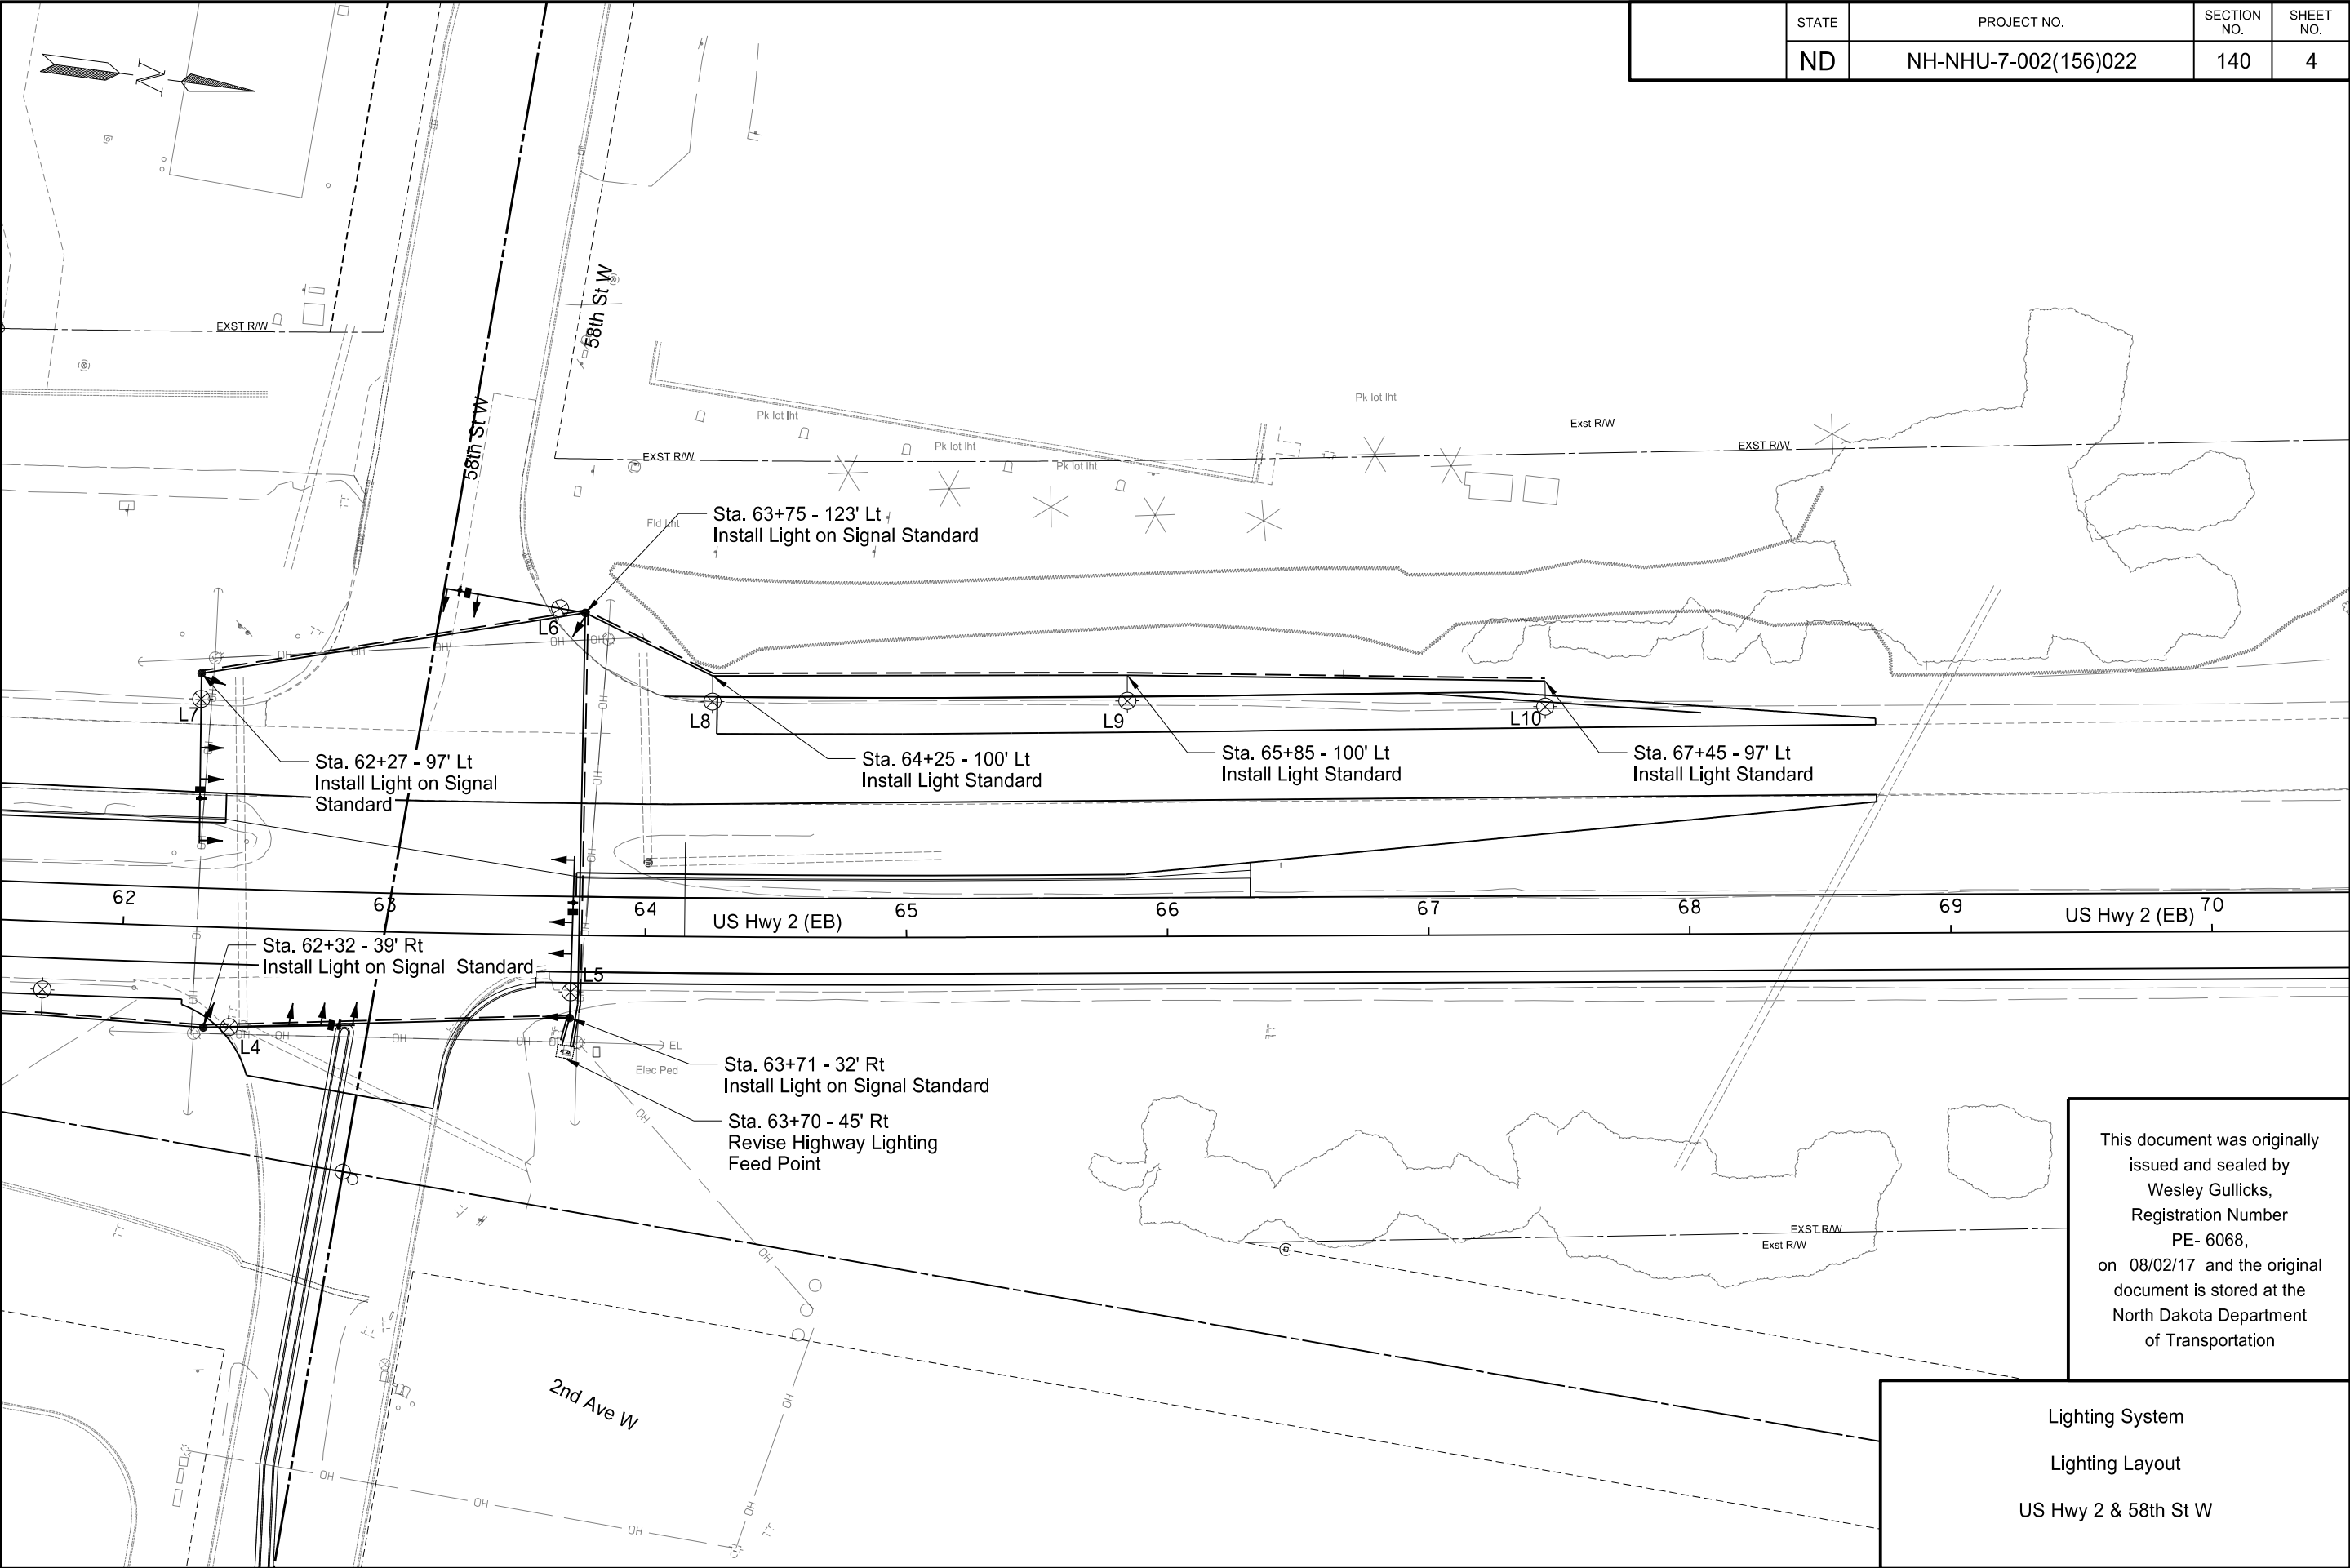

This document was originally issued and sealed by Wesley Gullicks, Registration Number PE- 6068, on 08/02/17 and the original document is stored at the North Dakota Department of Transportation

Lighting System
Lighting Layout
US Hwy 2 & 58th St W

Conduit / Conductor Run Tabulation								
Sta to Sta		Conduit Runs		Cable Trench	Cable Runs			
		Length	Size	LF	LF	Conductor Size, Type & Quantity	LF	Conductor Size, Type & Quantity
58+30 - 30' Rt	60+00 - 36' Rt	170'	2"	--	356'	(2) #6 RHW	178'	(1) #6 THW
60+00 - 36' Rt	61+70 - 36' Rt	170'	2"	--	356'	(2) #6 RHW	178'	(1) #6 THW
61+70 - 36' Rt	62+32 - 39' Rt	62'	2"	--	140'	(2) #6 RHW	70'	(1) #6 THW
62+32 - 39' Rt	63+71 - 32' Rt	140'	2"	--	296'	(2) #6 RHW	148'	(1) #6 THW
63+71 - 32' Rt	63+70 - 45' Rt	13'	2"	--	54'	(2) #6 RHW	27'	(1) #6 THW
63+70 - 45' Rt	63+75 - 123' Lt	169'	2"	--	366'	(2) #6 RHW	183'	(1) #6 THW
63+75 - 123' Lt	62+27 - 97' Lt	150'	2"	--	316'	(2) #6 RHW	158'	(1) #6 THW
63+75 - 123' Lt	64+25 - 100' Lt	54'	2"	--	124'	(2) #6 RHW	62'	(1) #6 THW
64+25 - 100' Lt	65+85 - 100' Lt	160'	2"	--	336'	(2) #6 RHW	168'	(1) #6 THW
65+85 - 100' Lt	67+45 - 97' Lt	160'	2"	--	336'	(2) #6 RHW	168'	(1) #6 THW

Light Standards							
No.	Station	Luminaire	Circuit	IES - Type	Pole Height	Mast Arm	Remarks
L1	58+30 - 30' Rt	22,000 lumen, 3000K LED	1	III	42'	10'	Install new LED Luminaire on Relocated Light Standard. Provide new anchor bolts.
L2	60+00 - 36' Rt	22,000 lumen, 3000K LED	1	III	42'	10'	Install new LED Luminaire on Relocated Light Standard. Provide new anchor bolts.
L3	61+70 - 36' Rt	22,000 lumen, 3000K LED	1	III	42'	10'	Install new LED Luminaire on Relocated Light Standard. Provide new anchor bolts.
L4	62+32 - 39' Rt	22,000 lumen, 3000K LED	1	III	42'	10'	Install new LED Luminaire on Signal Standard
L5	63+71 - 32' Rt	22,000 lumen, 3000K LED	1	III	42'	10'	Install new LED Luminaire on Signal Standard
L6	63+75 - 123' Lt	22,000 lumen, 3000K LED	2	III	42'	10'	Install new LED Luminaire on Signal Standard
L7	62+27 - 97' Lt	22,000 lumen, 3000K LED	2	III	42'	10'	Install new LED Luminaire on Signal Standard
L8	64+25 - 100' Lt	22,000 lumen, 3000K LED	2	III	42'	10'	Install new LED Luminaire on Relocated Light Standard. Provide new anchor bolts.
L9	65+85 - 100' Lt	22,000 lumen, 3000K LED	2	III	42'	10'	Install new LED Luminaire on Relocated Light Standard. Provide new anchor bolts.
L10	67+45 - 97' Lt	22,000 lumen, 3000K LED	2	III	42'	10'	Install new LED Luminaire on Relocated Light Standard. Provide new anchor bolts.


Lighting Quantities							
Description	Concrete Foundation - Highway Lighting	2" Diameter Rigid Conduit	Underground Conductor No6 - Type RHW	Underground Conductor No6 - Type THW	Relocate Light Standard	Revise Highway Lighting Feedpoint	LED Luminaire
Unit	EA	LF	LF	LF	EA	EA	EA
Quantity	6	1248	2680	1340	9	1	10

Light Standard Foundation Table		
Description	Footing Depth "D" 24" & 30" Diameter	Footing Depth "D" 36" & 42" Diameter
42' Pole	6'-0"	5'-0"

This document was originally issued and sealed by Wesley Gullicks, Registration Number PE- 6068, on 08/02/17 and the original document is stored at the North Dakota Department of Transportation

Lighting System
US Hwy 2 and 58th St W Intersection
Lighting Quantities
ND Hwy 2

	STATE	PROJECT NO.	SECTION NO.	SHEET NO.
	ND	NH-NHU-7-002(156)022	140	6

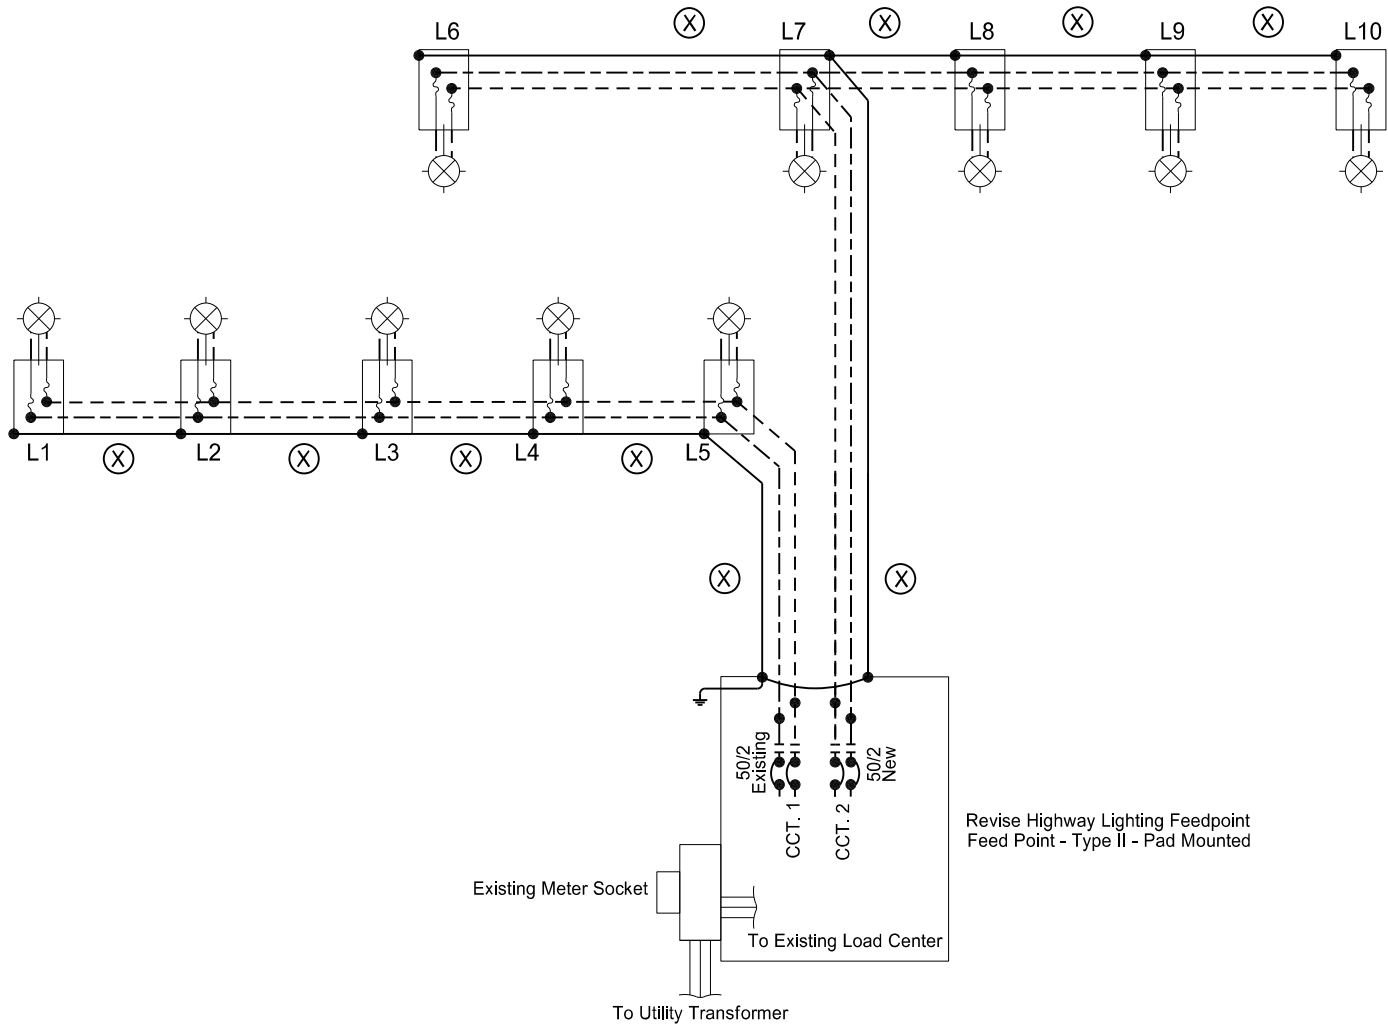

LEGEND

- Phase Conductor
- Phase Conductor
- Ground Conductor
- 2 - #6 RHW & 1 - #6 THW
- LED Luminaire 208 Watt Operating on 240 Volts
- Light Standard with Inline Fuses

This document was originally issued and sealed by Wesley Gullicks, Registration Number PE- 6068, on 08/02/17 and the original document is stored at the North Dakota Department of Transportation

Lighting System
US Hwy 2 and 58th St W Intersection
Lighting Schematic
US Hwy 2

Conduit / Conductor Run Tabulation								
Sta to Sta		Conduit Runs		Cable Trench	Cable Runs			
		Length	Size	LF	LF	Conductor Size, Type & Quantity	LF	Conductor Size, Type & Quantity
113+50 - 26' Rt	115+30 - 32' Rt	180'	2"	--	376'	(2) #6 RHW	188'	(1) #6 THW
115+30 - 32' Rt	117+10 - 32' Rt	180'	2"	--	376'	(2) #6 RHW	188'	(1) #6 THW
117+10 - 32' Rt	118+60 - 32' Rt	150'	2"	--	316'	(2) #6 RHW	158'	(1) #6 THW
118+60 - 32' Rt	120+15 - 26' Rt	156'	2"	--	328'	(2) #6 RHW	164'	(1) #6 THW
118+60 - 32' Rt	118+60 - 123' Rt	91'	2"	--	210'	(2) #6 RHW	105'	(1) #6 THW
118+60 - 123' Rt	118+50 - 112' Lt	235'	2"	--	498'	(2) #6 RHW	249'	(1) #6 THW
118+50 - 112' Lt	119+90 - 114' Lt	140'	2"	--	296'	(2) #6 RHW	148'	(1) #6 THW
119+90 - 114' Lt	121+70 - 113' Lt	180'	2"	--	376'	(2) #6 RHW	188'	(1) #6 THW
121+70 - 113' Lt	123+50 - 113' Lt	180'	2"	--	376'	(2) #6 RHW	188'	(1) #6 THW
123+50 - 113' Lt	125+30 - 113' Lt	180'	2"	--	376'	(2) #6 RHW	188'	(1) #6 THW
118+60-123' Rt	118+55 - 150' Rt	28'	2"	--	144'	(3) #2 RHW	--	--

Light Standards							
No.	Station	Luminaire	Circuit	IES - Type	Pole Height	Mast Arm	Remarks
L1	113+50 - 26' Rt	22,000 lumen, 3000K LED	1	III	42'	10'	
L2	115+30 - 32' Rt	22,000 lumen, 3000K LED	1	III	42'	10'	
L3	117+10 - 32' Rt	22,000 lumen, 3000K LED	1	III	42'	10'	
L4	118+60 - 32' Rt	22,000 lumen, 3000K LED	1	III	42'	10'	
L5	120+15 - 26' Rt	22,000 lumen, 3000K LED	1	III	42'	10'	
L6	118+50 - 112' Lt	22,000 lumen, 3000K LED	2	III	42'	10'	
L7	119+90 - 114' Lt	22,000 lumen, 3000K LED	2	III	42'	10'	
L8	121+70 - 113' Lt	22,000 lumen, 3000K LED	2	III	42'	10'	
L9	123+50 - 113' Lt	22,000 lumen, 3000K LED	2	III	42'	10'	
L10	125+30 - 113' Lt	22,000 lumen, 3000K LED	2	III	42'	10'	


Lighting Quantities									
Description	Concrete Foundation - Highway Lighting	Concrete Foundation - Feed Point - Type B	2" Diameter Rigid Conduit	Underground Conductor No6 - Type RHW	Underground Conductor No6 - Type THW	Underground Conductor No2 - Type RHW	Feed Point - Type II - Pad Mounted	Lt Std 10FT MA 42FT MT HT Breakaway	LED Luminaire
Unit	EA	EA	LF	LF	LF	LF	LF	LF	EA
Quantity	10	1	1700	3528	1764	144	1	10	10

Light Standard Foundation Table		
Description	Footing Depth "D" 24" & 30" Diameter	Footing Depth "D" 36" & 42" Diameter
42' Pole	6'-0"	5'-0"

This document was originally issued and sealed by Wesley Gullicks, Registration Number PE- 6068, on 08/02/17 and the original document is stored at the North Dakota Department of Transportation

Lighting System
US Hwy 2 & 70th St W
Lighting Quantities
ND Hwy 2

	STATE	PROJECT NO.	SECTION NO.	SHEET NO.
	ND	NH-NHU-7-002(156)022	140	10

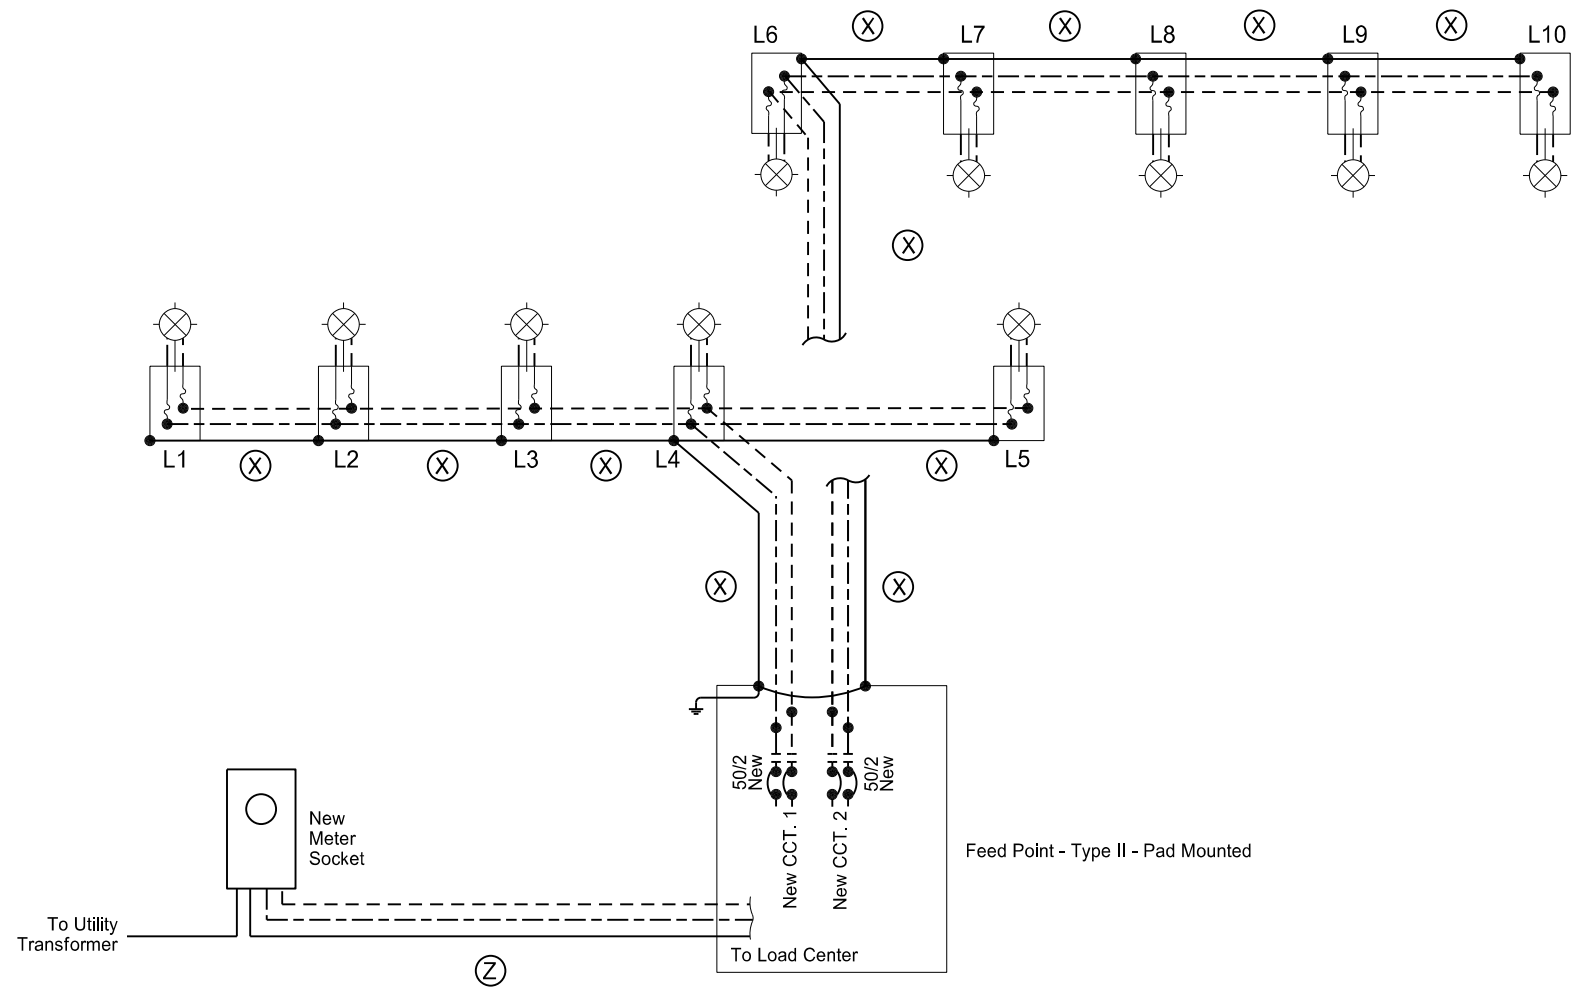


LEGEND


- Phase Conductor
- Phase Conductor
- Ground Conductor
- (X) 2 - #6 RHW & 1 - #6 THW
- (Z) 3 - #2 RHW
- LED Luminaire 208 Watt Operating on 240 Volts
- Light Standard with Inline Fuses

This document was originally issued and sealed by Wesley Gullicks, Registration Number PE- 6068, on 08/02/17 and the original document is stored at the North Dakota Department of Transportation

 Lighting System
US Hwy 2 & 70th St W
Lighting Schematic
US Hwy 2



	STATE	PROJECT NO.	SECTION NO.	SHEET NO.
	ND	NH-NHU-7-002(156)022	140	12

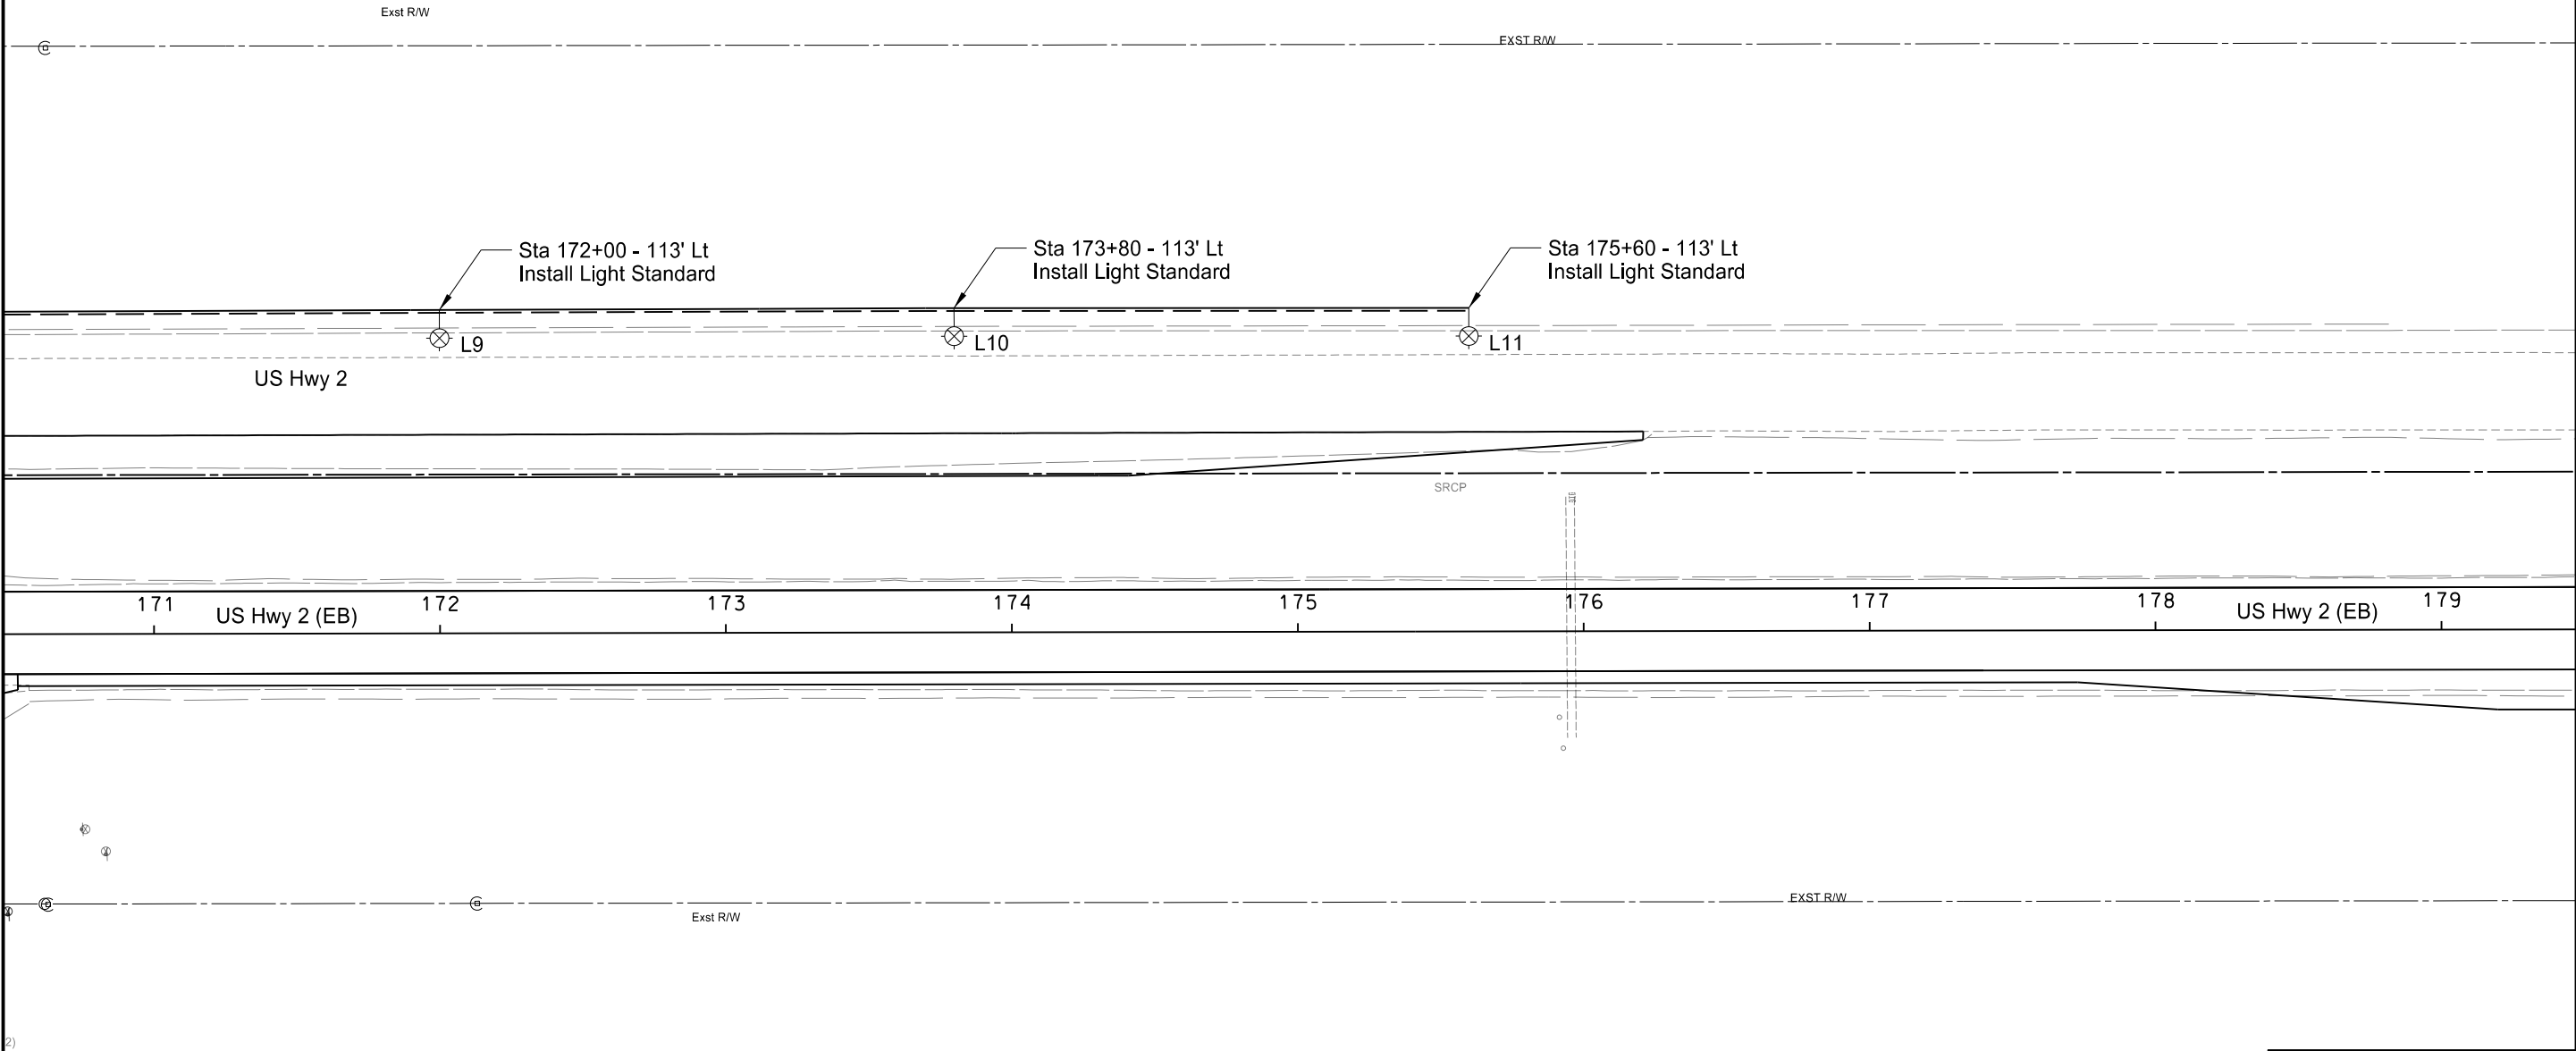

This document was originally issued and sealed by
Wesley Gullicks,
Registration Number
PE- 6068,
on 08/02/17 and the original document is stored at the
North Dakota Department
of Transportation

Lighting System
Lighting Layout
US Hwy 2 & 84th St W

Conduit / Conductor Run Tabulation								
Sta to Sta		Conduit Runs		Cable Trench	Cable Runs			
		Length	Size	LF	LF	Conductor Size, Type & Quantity	LF	Conductor Size, Type & Quantity
163+10 - 26' Rt	164+90 - 33' Rt	180'	2"	--	376'	(2) #6 RHW	188'	(1) #6 THW
164+90 - 33' Rt	166+70 - 36' Rt	180'	2"	--	376'	(2) #6 RHW	188'	(1) #6 THW
166+70 - 36' Rt	168+38 - 36' Rt	168'	2"	--	352'	(2) #6 RHW	176'	(1) #6 THW
168+38 - 36' Rt	169+25 - 45' Rt	78'	2"	--	172'	(2) #6 RHW	86'	(1) #6 THW
169+25 - 45' Rt	169+00 - 45' Rt	15'	2"	--	38'	(2) #6 RHW	19'	(1) #6 THW
169+00 - 45' Rt	169+00 - 91' Rt	46'	2"	--	112'	(2) #6 RHW	56'	(1) #6 THW
169+25 - 45' Rt	170+25 - 45' Rt	100'	2"	--	216'	(2) #6 RHW	108'	(1) #6 THW
169+00 - 91' Rt	169+15 - 128' Lt	229'	2"	--	486'	(2) #6 RHW	243'	(1) #6 THW
169+15 - 128' Lt	170+40 - 113' Lt	130'	2"	--	276'	(2) #6 RHW	138'	(1) #6 THW
170+40 - 113' Lt	172+00 - 113' Lt	160'	2"	--	336'	(2) #6 RHW	168'	(1) #6 THW
172+00 - 113' Lt	173+80 - 113' Lt	180'	2"	--	376'	(2) #6 RHW	188'	(1) #6 THW
173+80 - 113' Lt	175+60 - 113' Lt	180'	2"	--	376'	(2) #6 RHW	188'	(1) #6 THW
168+85 - 91' Rt	169+00 - 91' Rt	15'	2"	--	105'	(3) #2 RHW	--	--

Light Standards							
No.	Station	Luminaire	Circuit	IES - Type	Pole Height	Mast Arm	Remarks
L1	163+10 - 26' Rt	22,000 lumen, 3000K LED	1	III	42'	10'	
L2	164+90 - 33' Rt	22,000 lumen, 3000K LED	1	III	42'	10'	
L3	166+70 - 36' Rt	22,000 lumen, 3000K LED	1	III	42'	10'	
L4	168+38 - 36' Rt	22,000 lumen, 3000K LED	1	III	42'	10'	
L5	169+15 - 45' Rt	22,000 lumen, 3000K LED	1	III	42'	10'	Install LED Luminaire on Signal Standard
L6	170+25 - 45' Rt	22,000 lumen, 3000K LED	1	III	42'	10'	Install LED Luminaire on Signal Standard
L7	169+15 - 128' Lt	22,000 lumen, 3000K LED	2	III	42'	10'	Install LED Luminaire on Signal Standard
L8	170+40 - 113' Lt	22,000 lumen, 3000K LED	2	III	42'	10'	
L9	172+00 - 113' Lt	22,000 lumen, 3000K LED	2	III	42'	10'	
L10	173+80 - 113' Lt	22,000 lumen, 3000K LED	2	III	42'	10'	
L11	175+60 - 113' Lt	22,000 lumen, 3000K LED	2	III	42'	10'	


Light Standard Foundation Table		
Description	Footing Depth "D" 24" & 30" Diameter	Footing Depth "D" 36" & 42" Diameter
42' Pole	6'-0"	5'-0"

Lighting Quantities (*)							
Description	Concrete Foundation - Highway Lighting	2" Diameter Rigid Conduit	Underground Conductor No6 - Type RHW	Underground Conductor No6 - Type THW	Underground Conductor No2 - Type RHW	Lt Std 10FT MA 42FT MT HT Breakaway	LED Luminaire
Unit	EA	LF	LF	LF	LF	EA	EA
Quantity	8	1661	3492	1746	105	8	11

This document was originally issued and sealed by Wesley Gullicks, Registration Number PE- 6068, on 08/02/17 and the original document is stored at the North Dakota Department of Transportation

Lighting System
US Hwy 2 & 84th St W
Lighting Quantities
US Hwy 2

	STATE	PROJECT NO.	SECTION NO.	SHEET NO.
	ND	NH-NHU-7-002(156)022	140	14

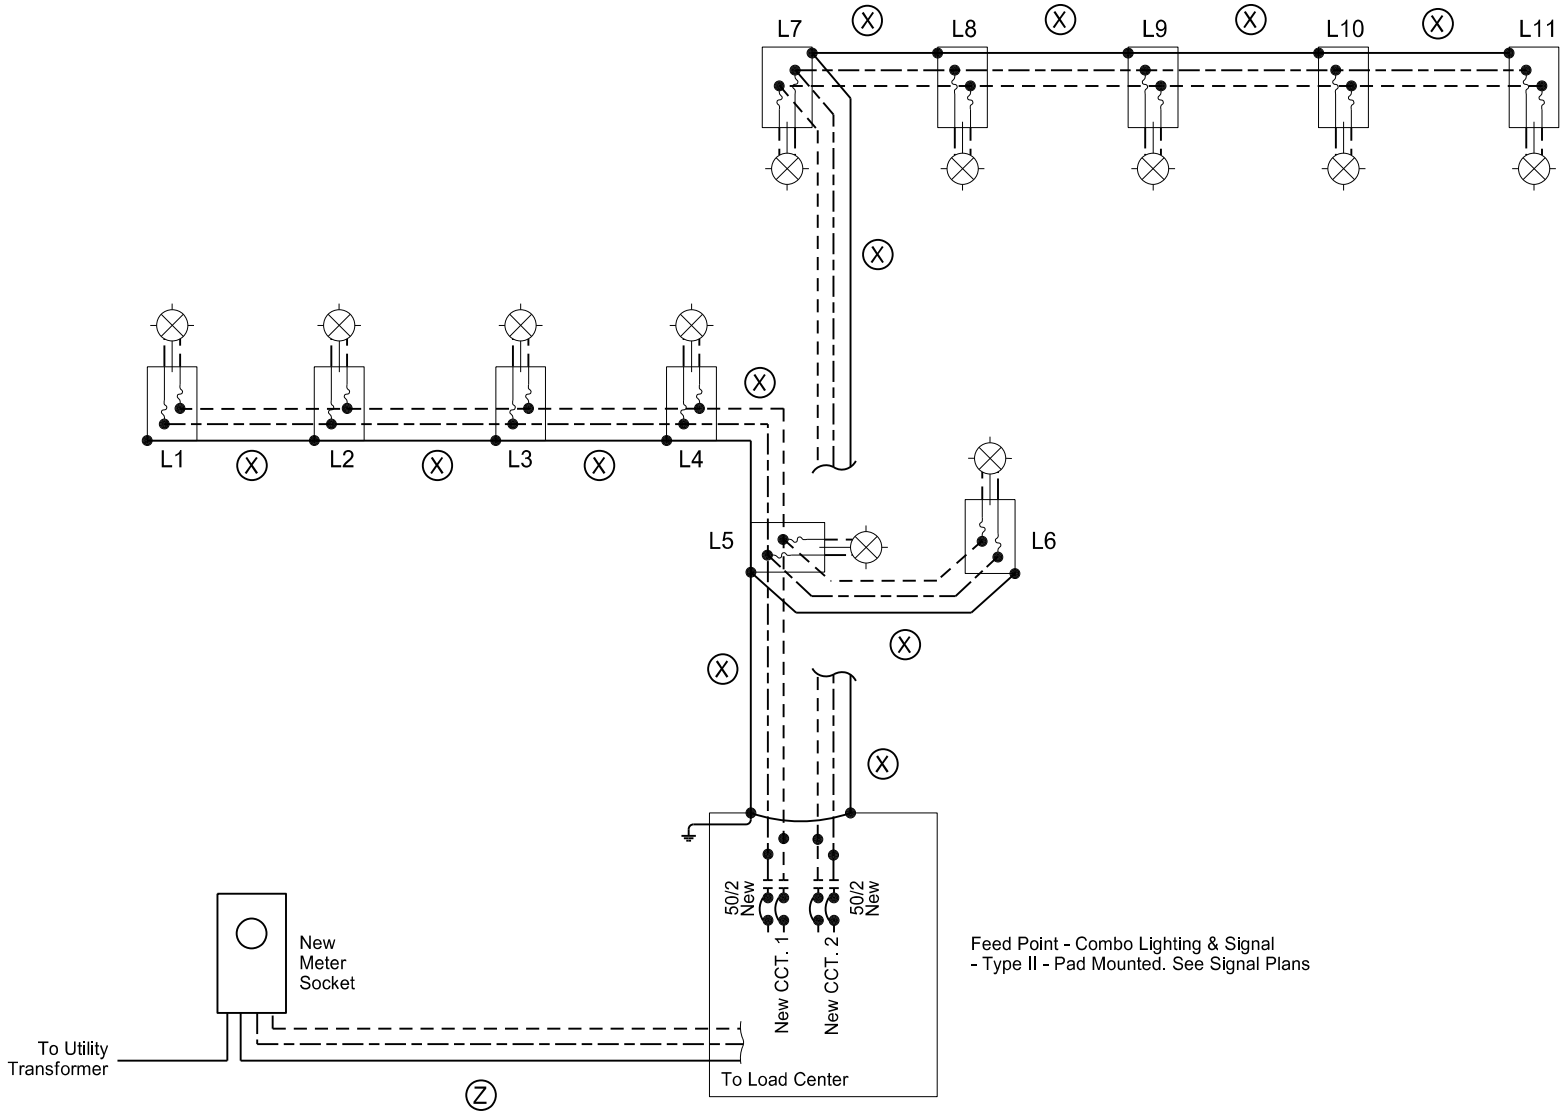


LEGEND

- Phase Conductor
- Phase Conductor
- Ground Conductor
- (X) 2 - #6 RHW & 1 - #6 THW
- (Z) 3 - #2 RHW
- (Light Fixture Symbol) LED Luminaire 208 Watt Operating on 240 Volts
- (Light Standard Symbol) Light Standard with Inline Fuses

This document was originally issued and sealed by Wesley Gullicks, Registration Number PE- 6068, on 08/02/17 and the original document is stored at the North Dakota Department of Transportation

 Lighting System
US Hwy 2 / 84th St W
Lighting Schematic
US Hwy 2



	STATE	PROJECT NO.	SECTION NO.	SHEET NO.
	ND	NH-NHU-7-002(156)022	140	15

EXST R/W

178

179

US Hwy 2 (EB)

180

181

182

183

184

185

US Hwy 2 (EB)

186

Sta 182+40 - 36' Rt
Install Light Standard

L1

Sta 183+70 - 36' Rt

Wells St

 
Well St

This document was originally
issued and sealed by
Wesley Gullicks,
Registration Number
PE- 6068,
on 08/02/17 and the original
document is stored at the
North Dakota Department
of Transportation

Destination Lighting

Lighting Layout

US Hwy 2 & Wells St



	STATE	PROJECT NO.	SECTION NO.	SHEET NO.
	ND	NH-NHU-7-002(156)022	140	16

Exst R/W

186

US Hwy 2 (EB)

187

188

189

190

191

192

193

US Hwy 2 (EB)

194

Sta 186+00 - 36' Rt

Sta 194+00 - 36' Rt

 
Exst R/W

This document was originally issued and sealed by
Wesley Gullicks,
Registration Number
PE- 6068,
on 08/02/17 and the original document is stored at the
North Dakota Department
of Transportation

Destination Lighting

Lighting Layout

US Hwy 2 & Wells St & Energy St



STATE

PROJECT NO.

SECTION NO.

SHEET NO.

ND

NH-NHU-7-002(156)022

140

17

2 ELs

E Mtr

Exst R/W

Sta 195+20 - 114' Lt

Sta 196+40 - 113' Lt
Install Light Standard

L3

194

US Hwy 2 (EB)

195

196

197

198

199

200

201

US Hwy 2 (EB)

202

L2

Sta 195+20 - 36' Rt
Install Light Standard

Sta 195+20 - 93' Rt
Install Feed Point -
Type II - Pad Mounted

Sta 195+65 - 93' Rt
Utility Meter

Energy St

Energy St

Exst R/W

This document was originally
issued and sealed by
Wesley Gullicks,
Registration Number
PE- 6068,
on 08/02/17 and the original
document is stored at the
North Dakota Department
of Transportation

Lighting System

Lighting Layout

US Hwy 2 & Energy St

	STATE	PROJECT NO.	SECTION NO.	SHEET NO.
	ND	NH-NHU-7-002(156)022	140	18

Conduit / Conductor Run Tabulation								
Sta to Sta		Conduit Runs		Cable Trench	Cable Runs			
		Length	Size	LF	LF	Conductor Size, Type & Quantity	LF	Conductor Size, Type & Quantity
182+40 - 36' Rt	183+70 - 36' Rt	130'	2"	--	134'	3 NO. #6 USE	--	--
182+40 - 36' Rt	195+20 - 36' Rt	--	2"	1150'	1150'	3 NO. #6 USE	--	--
195+20 - 36' Rt	195+20 - 93' Rt	--	2"	57'	67'	3 NO. #6 USE	--	--
195+20 - 93' Rt	195+20 - 114' Lt	207'	2"		217'	3 NO. #6 USE	--	--
195+20 - 114' Lt	196+40 - 113' Lt	120'	2"		124'	3 NO. #6 USE	--	--
195+20 - 93' Rt	195+65 - 93' Rt	45'	2"		195'	(3) #2 RHW	--	--

Light Standards							
No.	Station	Luminaire	Circuit	IES - Type	Pole Height	Mast Arm	Remarks
L1	182+40 - 36' Rt	22,000 lumen, 3000K LED	1	III	42'	10'	Wells Street - Install new LED Luminaire on Relocated Light Standard. Provide new anchor bolts.
L2	195+20 - 36' Rt	22,000 lumen, 3000K LED	2	III	42'	10'	Energy Drive - Install new LED Luminaire on Relocated Light Standard. Provide new anchor bolts.
L3	196+40 - 113' Lt	22,000 lumen, 3000K LED	2	III	42'	10'	Energy Drive - Install new LED Luminaire on Relocated Light Standard. Provide new anchor bolts.

Lighting Quantities (*)									Destination Lighting
Description	Concrete Foundation - Highway Lighting	Concrete Foundation - Feed Point - Type B	Cable Trench - Type II	2" Diameter Rigid Conduit	Multiple Underground Cable 3 NO 6 USE	Underground Conductor No2 - Type RHW	Feed Point - Type II - Pad Mounted	LED Luminaire	
Unit	EA	EA	LF	LF	LF	LF	EA	EA	
Quantity	3	1	1207	502	1692	195	1	3	


(*) These Items shall not be bid seperately but shall be included in the item "Destination Lighting"

Light Standard Foundation Table		
Description	Footing Depth "D" 24" & 30" Diameter	Footing Depth "D" 36" & 42" Diameter
42' Pole	6'-0"	5'-0"

This document was originally issued and sealed by
Wesley Gullicks,
Registration Number
PE- 6068,
on 08/02/17 and the original document is stored at the
North Dakota Department
of Transportation

Lighting System
US Hwy 2 / Wells St. & Energy St
Lighting Quantities
US Hwy 2

	STATE	PROJECT NO.	SECTION NO.	SHEET NO.
	ND	NH-NHU-7-002(156)022	140	19

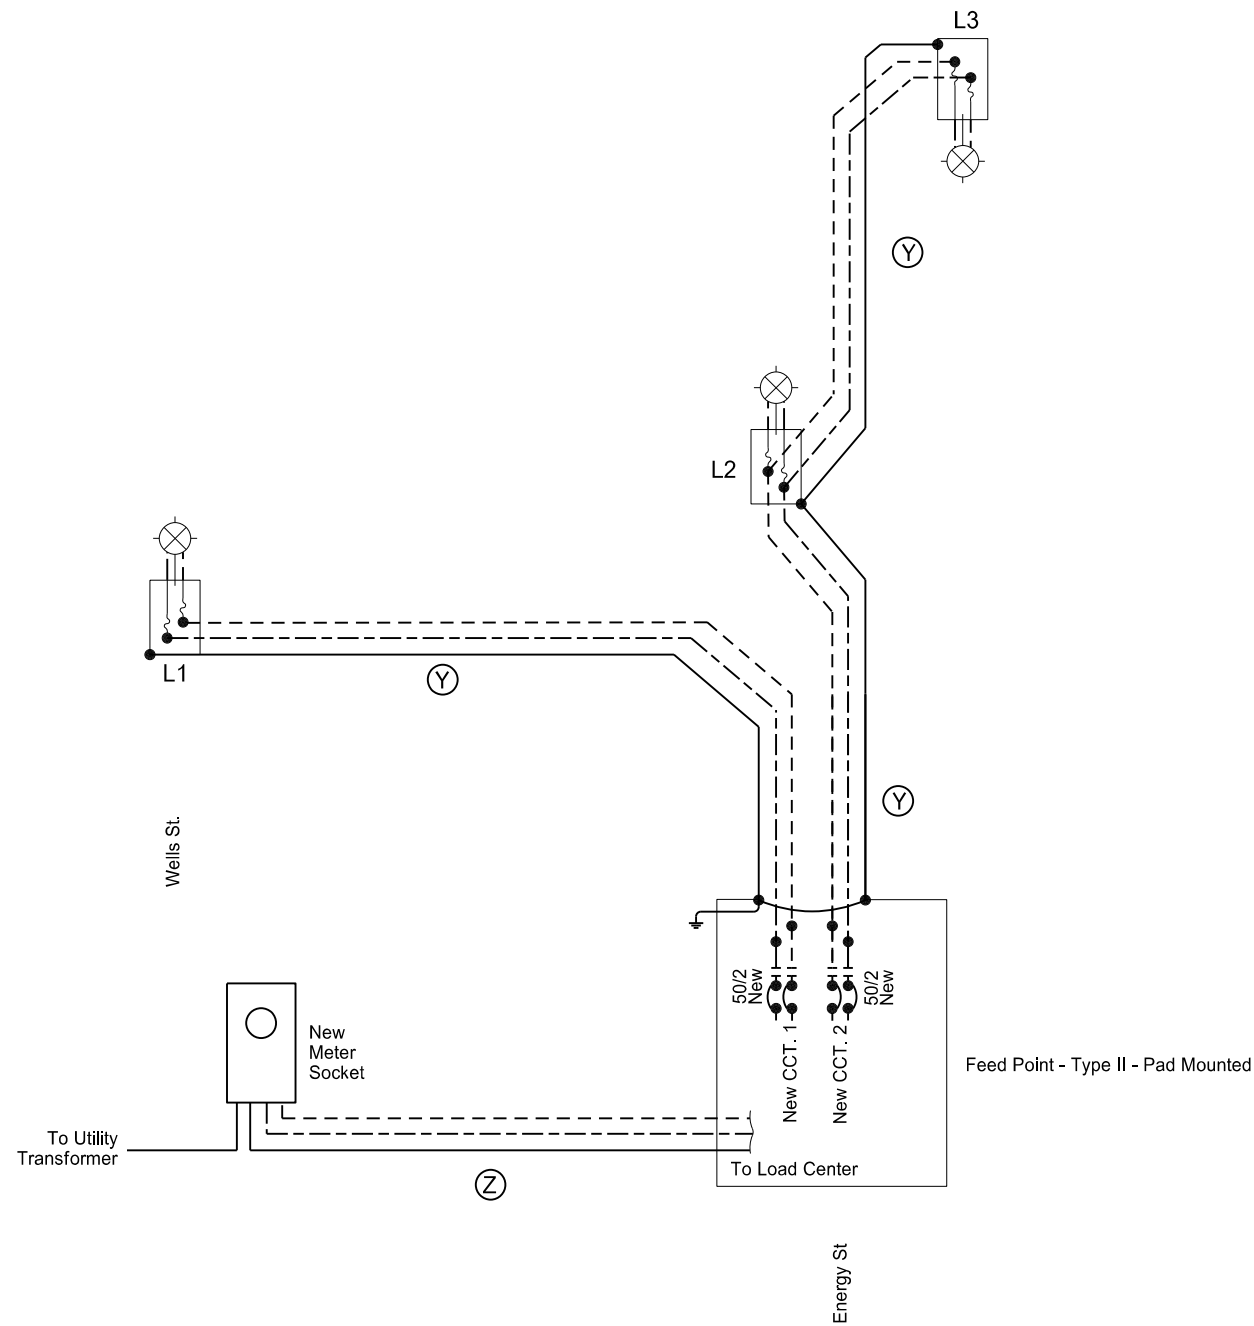


LEGEND


- Phase Conductor
- Phase Conductor
- Ground Conductor
- Ⓨ 3 - #6 USE
- Ⓩ 3 - #2 RHW
- ⊗ LED Luminaire 208 Watt Operating on 240 Volts
- ⊞ Light Standard with Inline Fuses


This document was originally issued and sealed by Wesley Gullicks, Registration Number PE- 6068, on 08/02/17 and the original document is stored at the North Dakota Department of Transportation

 Destination Lighting
US Hwy 2 / Wells St & Energy St
Lighting Schematic
US Hwy 2




	STATE	PROJECT NO.	SECTION NO.	SHEET NO.
	ND	NH-NHU-7-002(156)022	140	20

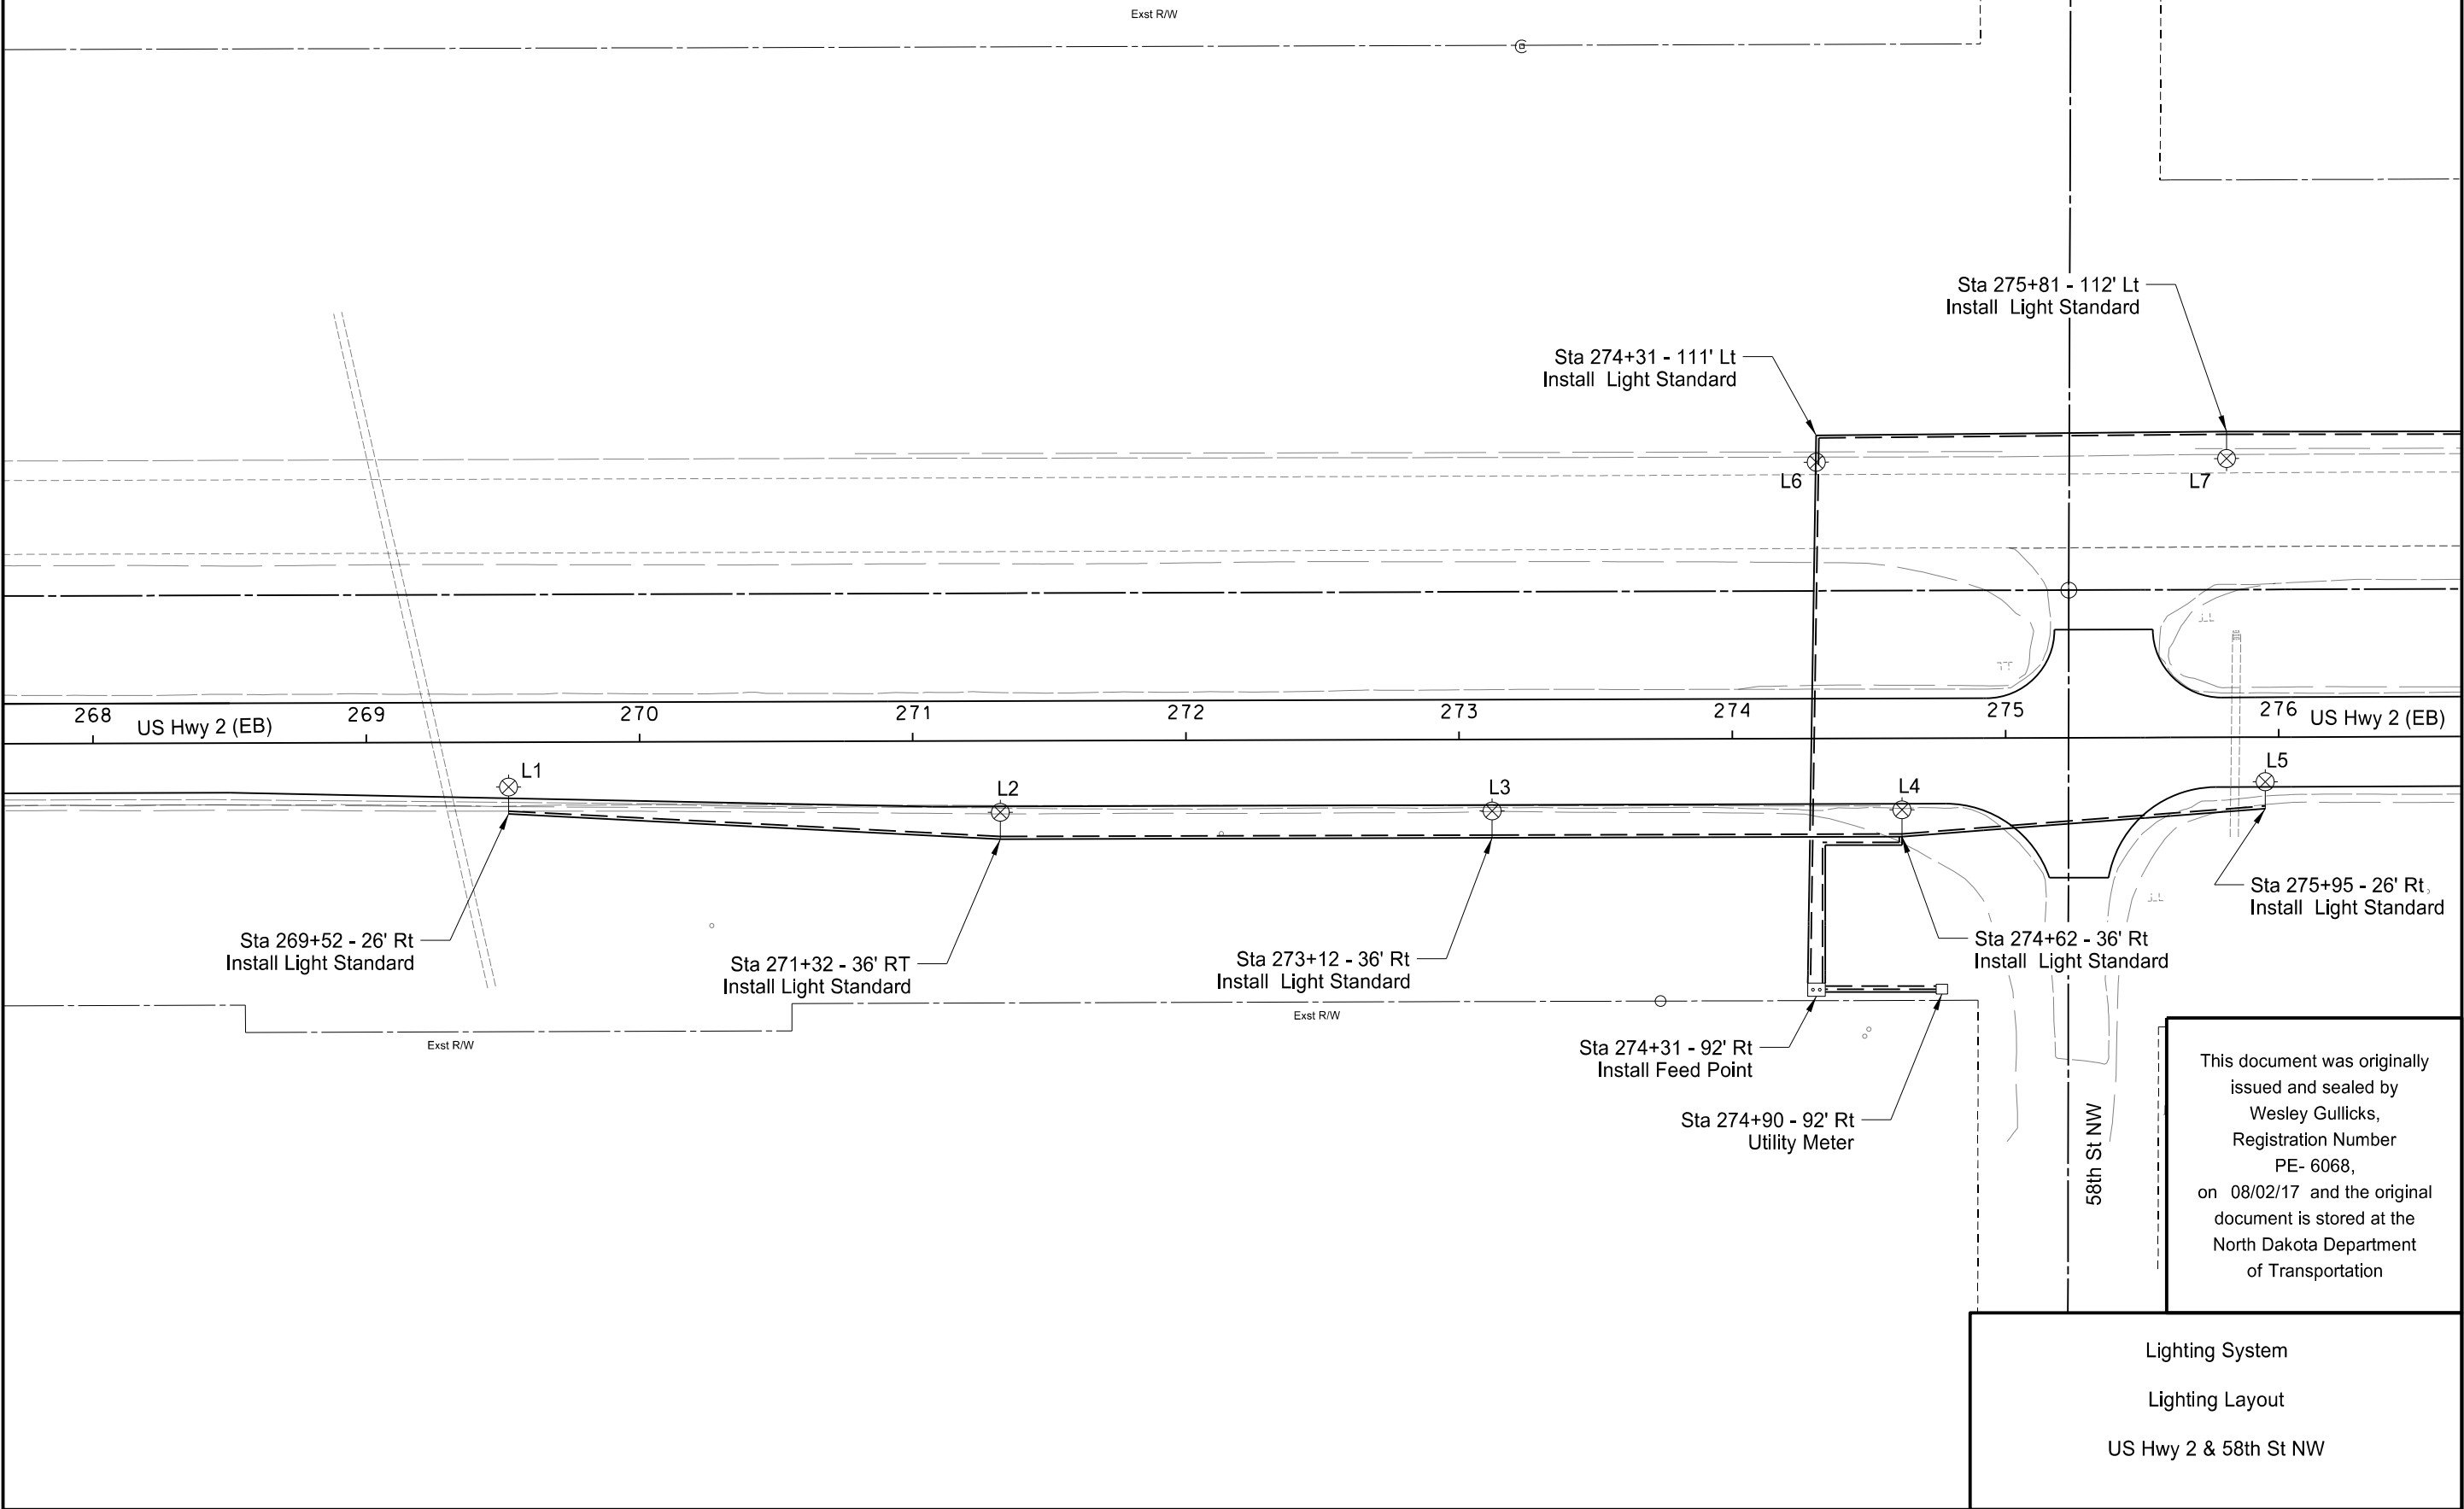

 

	STATE	PROJECT NO.	SECTION NO.	SHEET NO.
	ND	NH-NHU-7-002(156)022	140	21

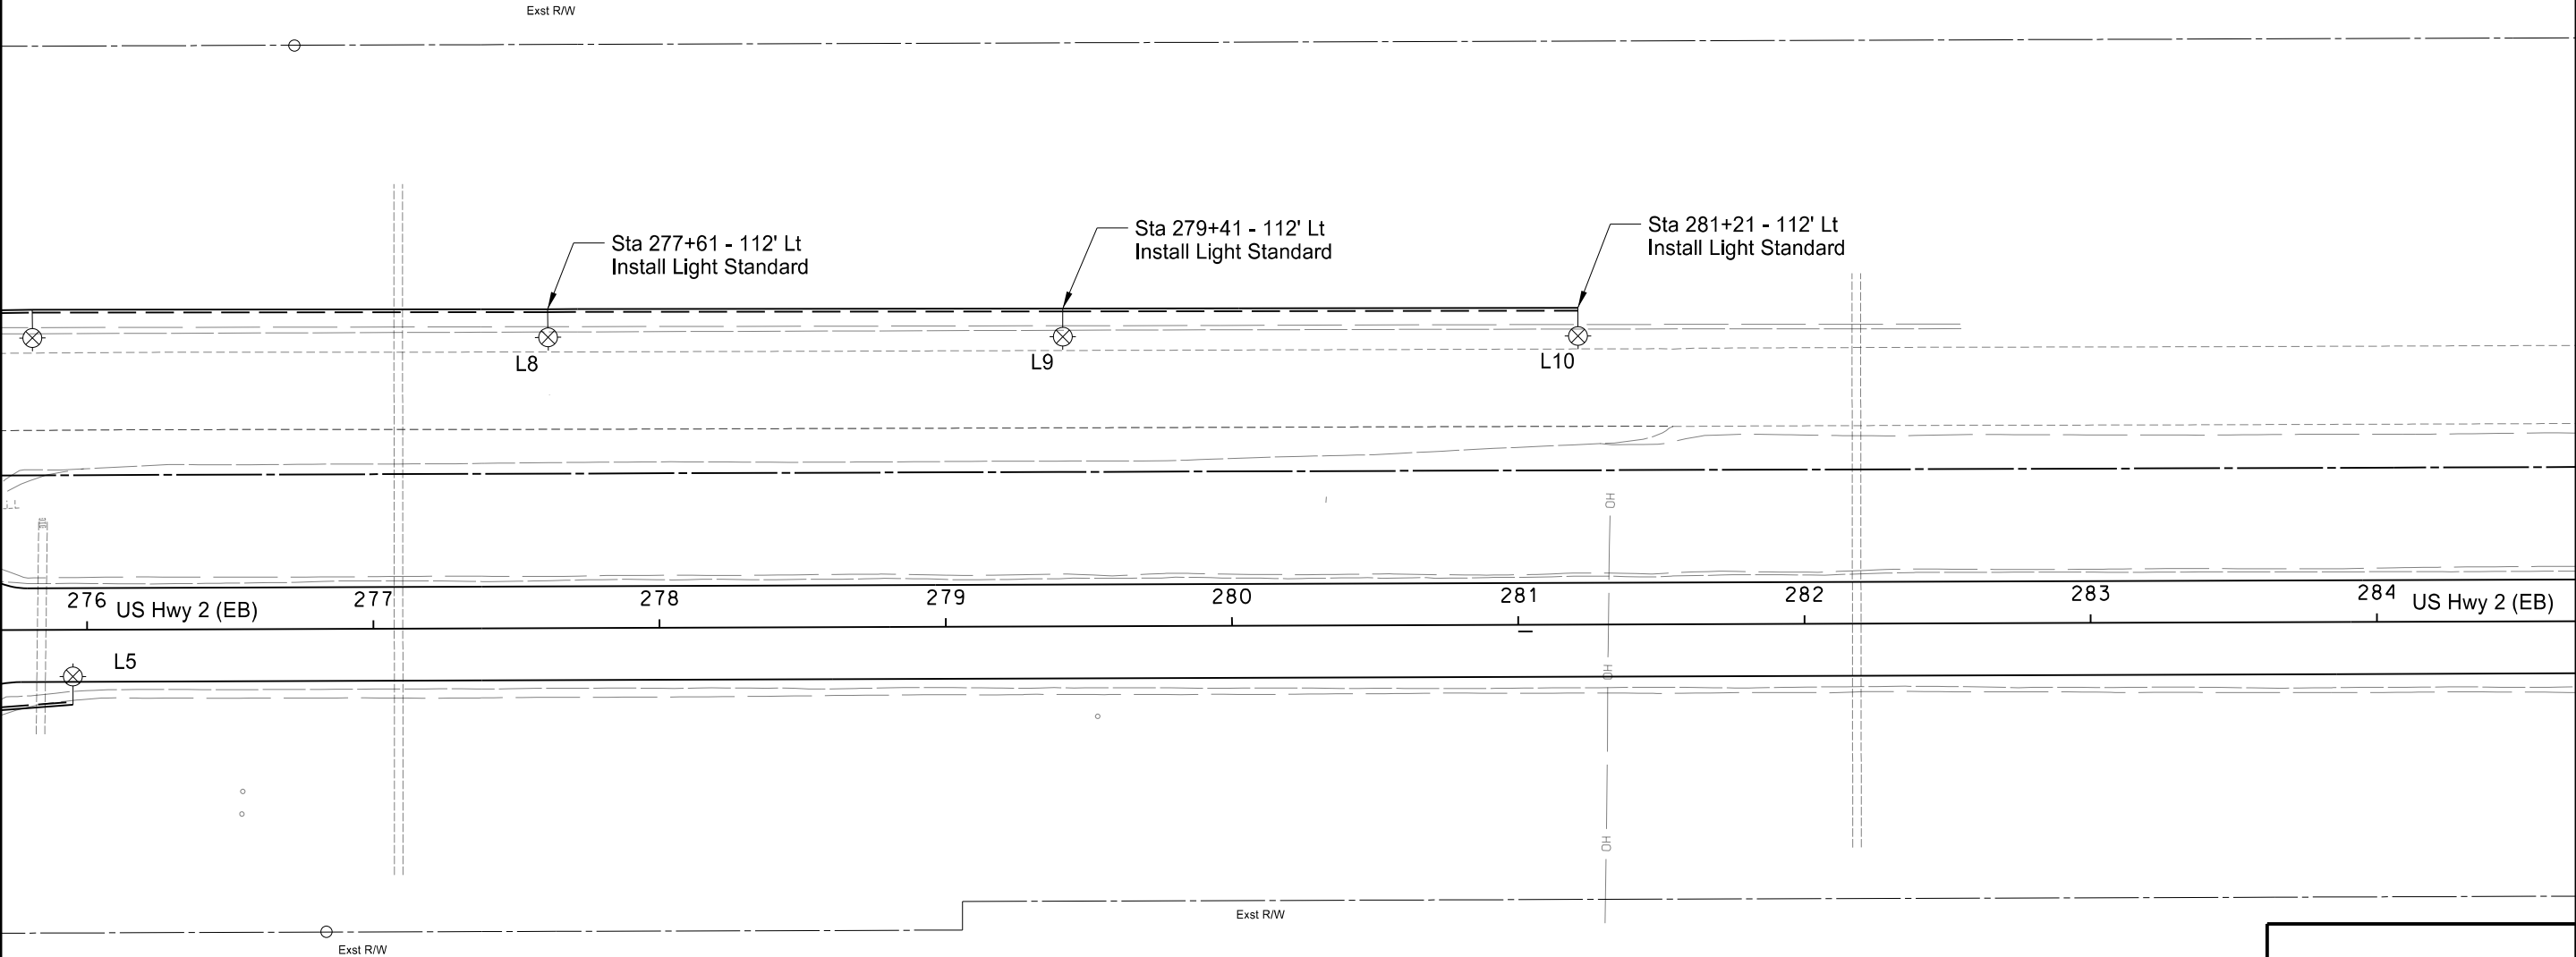

This document was originally issued and sealed by
Wesley Gullicks,
Registration Number
PE- 6068,
on 08/02/17 and the original document is stored at the
North Dakota Department
of Transportation

Lighting System
Lighting Layout
US Hwy 2 & 58th St NW

	STATE	PROJECT NO.	SECTION NO.	SHEET NO.
	ND	NH-NHU-7-002(156)022	140	22

Conduit / Conductor Run Tabulation								
Sta to Sta		Conduit Runs		Cable Trench	Cable Runs			
		Length	Size	LF	LF	Conductor Size, Type & Quantity	LF	Conductor Size, Type & Quantity
269+52 - 26' Rt	271+32 - 36' Rt	180'	2"	--	376'	(2) #6 RHW	188'	(1) #6 THW
271+32 - 36' Rt	273+12 - 36' Rt	180'	2"	--	376'	(2) #6 RHW	188'	(1) #6 THW
273+12 - 36' Rt	274+31 - 36' Rt	119'	2"	--	246'	(2) #6 RHW	123'	(1) #6 THW
274+31 - 36' Rt	274+62 - 36' Rt	62'	(2)2"	--	140'	(2) #6 RHW	70'	(1) #6 THW
274+62 - 36' Rt	275+95 - 26' Rt	135'	2"	--	286'	(2) #6 RHW	143'	(1) #6 THW
274+31 - 36' Rt	274+31 - 92' Rt	56'	2"	--	132'	(2) #6 RHW	66'	(1) #6 THW
274+31 - 92' Rt	274+31 - 111' Lt	203'	2"	--	434'	(2) #6 RHW	217'	(1) #6 THW
274+31 - 111' Lt	275+81 - 112' Lt	150'	2"	--	316'	(2) #6 RHW	158'	(1) #6 THW
275+81 - 112' Lt	277+62 - 112' Lt	180'	2"	--	376'	(2) #6 RHW	188'	(1) #6 THW
277+62 - 112' Lt	279+41 - 112' Lt	180'	2"	--	376'	(2) #6 RHW	188'	(1) #6 THW
279+41 - 112' Lt	281+21 - 112' Lt	180'	2"	--	376'	(2) #6 RHW	188'	(1) #6 THW
274+31 - 92' Rt	274+90 - 92' Rt	59'	2"	--	237'	(3) #2 RHW	--	--

Light Standards							
No.	Station	Luminaire	Circuit	IES - Type	Pole Height	Mast Arm	Remarks
L1	269+52 - 26' Rt	22,000 lumen, 3000K LED	1	III	42'	10'	
L2	271+32 - 36' Rt	22,000 lumen, 3000K LED	1	III	42'	10'	
L3	273+12 - 36' Rt	22,000 lumen, 3000K LED	1	III	42'	10'	
L4	274+62 - 36' Rt	22,000 lumen, 3000K LED	1	III	42'	10'	
L5	275+95 - 26' Rt	22,000 lumen, 3000K LED	1	III	42'	10'	
L6	274+31 - 111' Lt	22,000 lumen, 3000K LED	1	III	42'	10'	
L7	275+81 - 112' Lt	22,000 lumen, 3000K LED	1	III	42'	10'	
L8	277+61 - 112' Lt	22,000 lumen, 3000K LED	1	III	42'	10'	
L9	279+41 - 112' Lt	22,000 lumen, 3000K LED	1	III	42'	10'	
L10	281+21 - 112' Lt	22,000 lumen, 3000K LED	1	III	42'	10'	


Light Standard Foundation Table		
Description	Footing Depth "D" 24" & 30" Diameter	Footing Depth "D" 36" & 42" Diameter
42' Pole	6'-0"	5'-0"

Lighting Quantities									
Description	Concrete Foundation - Highway Lighting	Concrete Foundation - Feed Point - Type B	2" Diameter Rigid Conduit	Underground Conductor No6 - Type RHW	Underground Conductor No6 - Type THW	Underground Conductor No2 - Type RHW	Feed Point - Type II - Pad Mounted	Lt Std 10FT MA 42FT MT HT Breakaway	LED Luminaire
Unit	EA	EA	LF	LF	LF	LF	LF	LF	EA
Quantity	10	1	1684	3434	1717	237	1	10	10

This document was originally issued and sealed by
Wesley Gullicks,
Registration Number
PE- 6068,
on 08/02/17 and the original document is stored at the
North Dakota Department
of Transportation

Lighting System
US Hwy 2 & 58th St NW
Lighting Quantities
US Hwy 2

	STATE	PROJECT NO.	SECTION NO.	SHEET NO.
	ND	NH-NHU-7-002(156)022	140	23

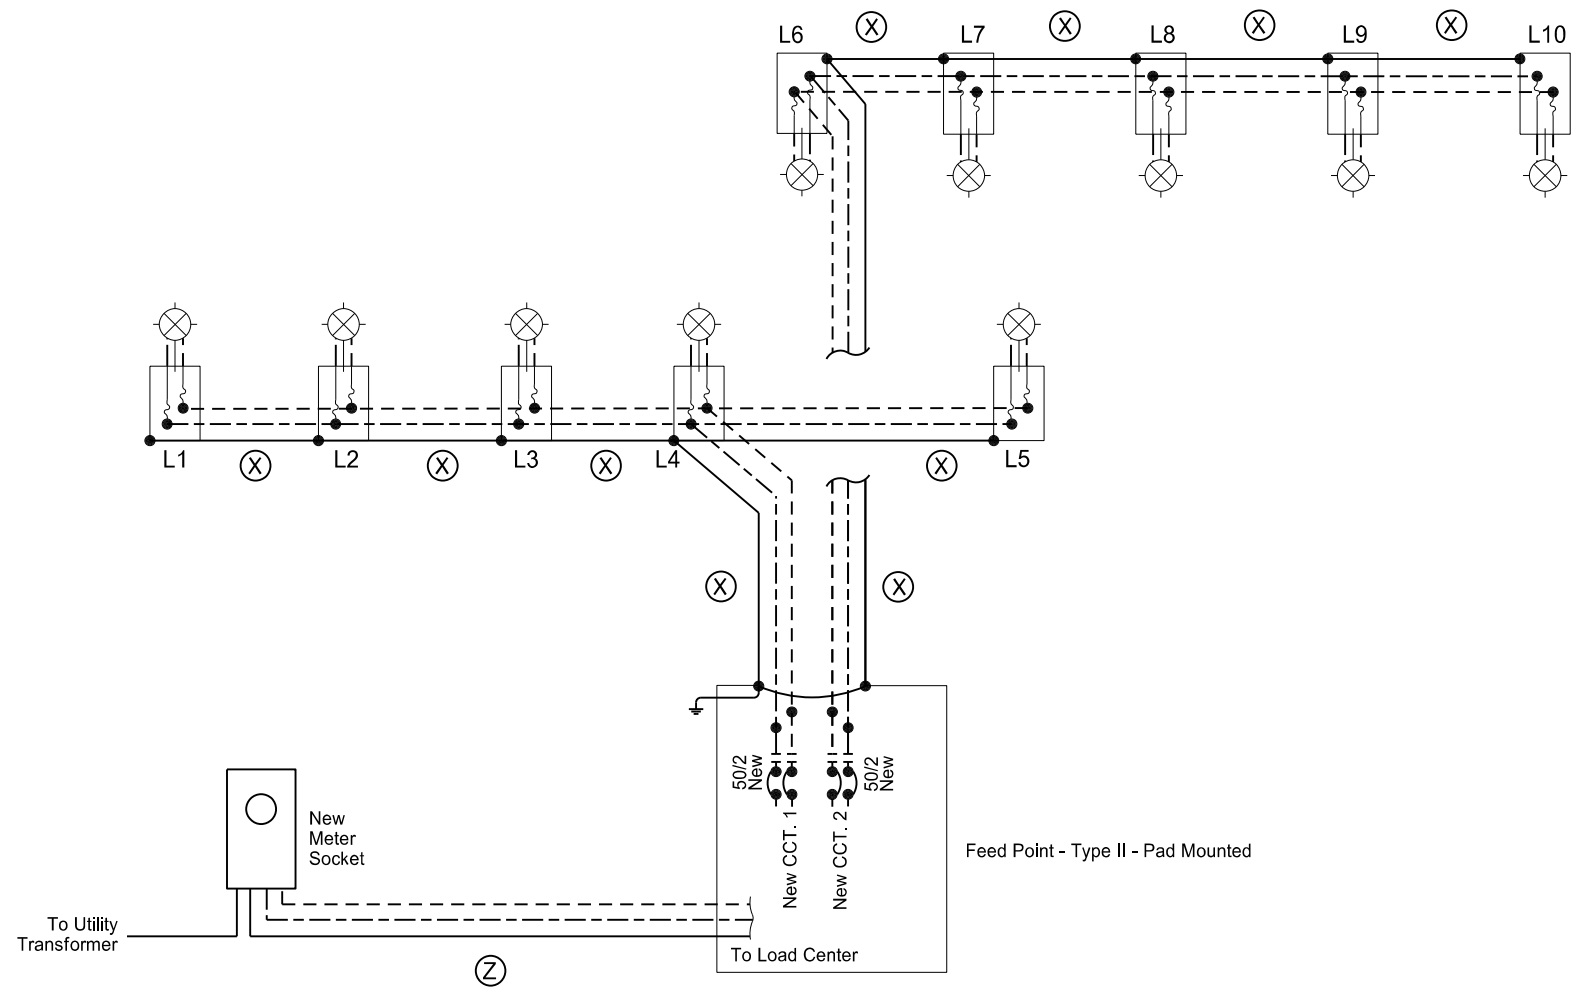




LEGEND

- Phase Conductor
- Phase Conductor
- Ground Conductor
- (X) 2 - #6 RHW & 1 - #6 THW
- (Z) 3 - #2 RHW
- (X) LED Luminaire 208 Watt Operating on 240 Volts
- (X) Light Standard with Inline Fuses

This document was originally issued and sealed by Wesley Gullicks, Registration Number PE- 6068, on 08/02/17 and the original document is stored at the North Dakota Department of Transportation

Lighting System
US Hwy 2 & 58th St NW
Lighting Schematic
US Hwy 2

STATE	PROJECT NO.	SECTION NO.	SHEET NO.
ND	NH-NHU-7-002(156)022	150	1

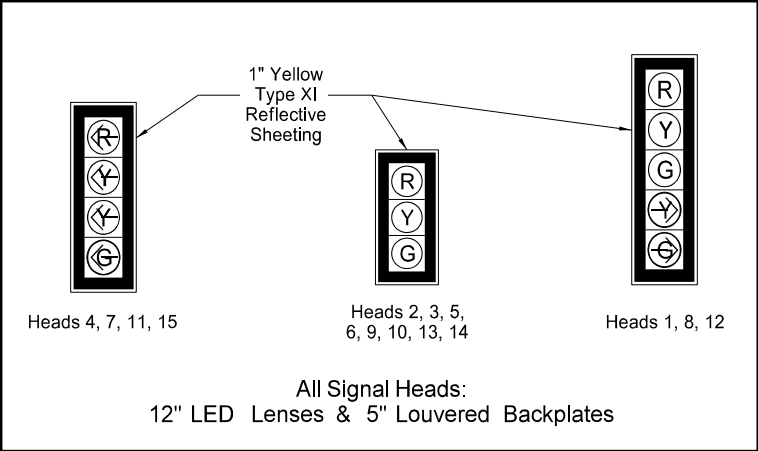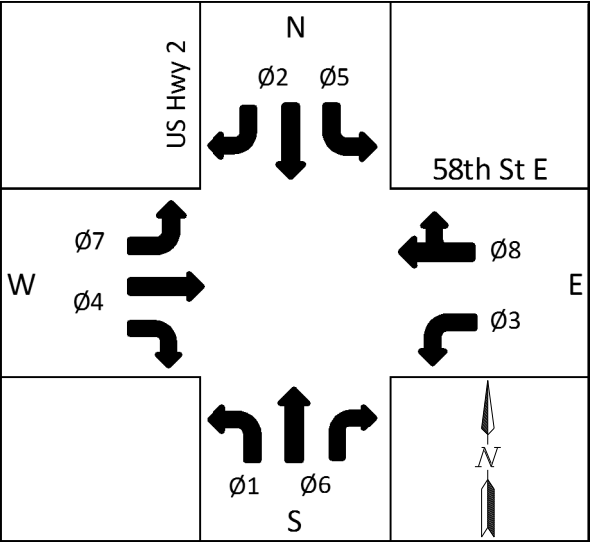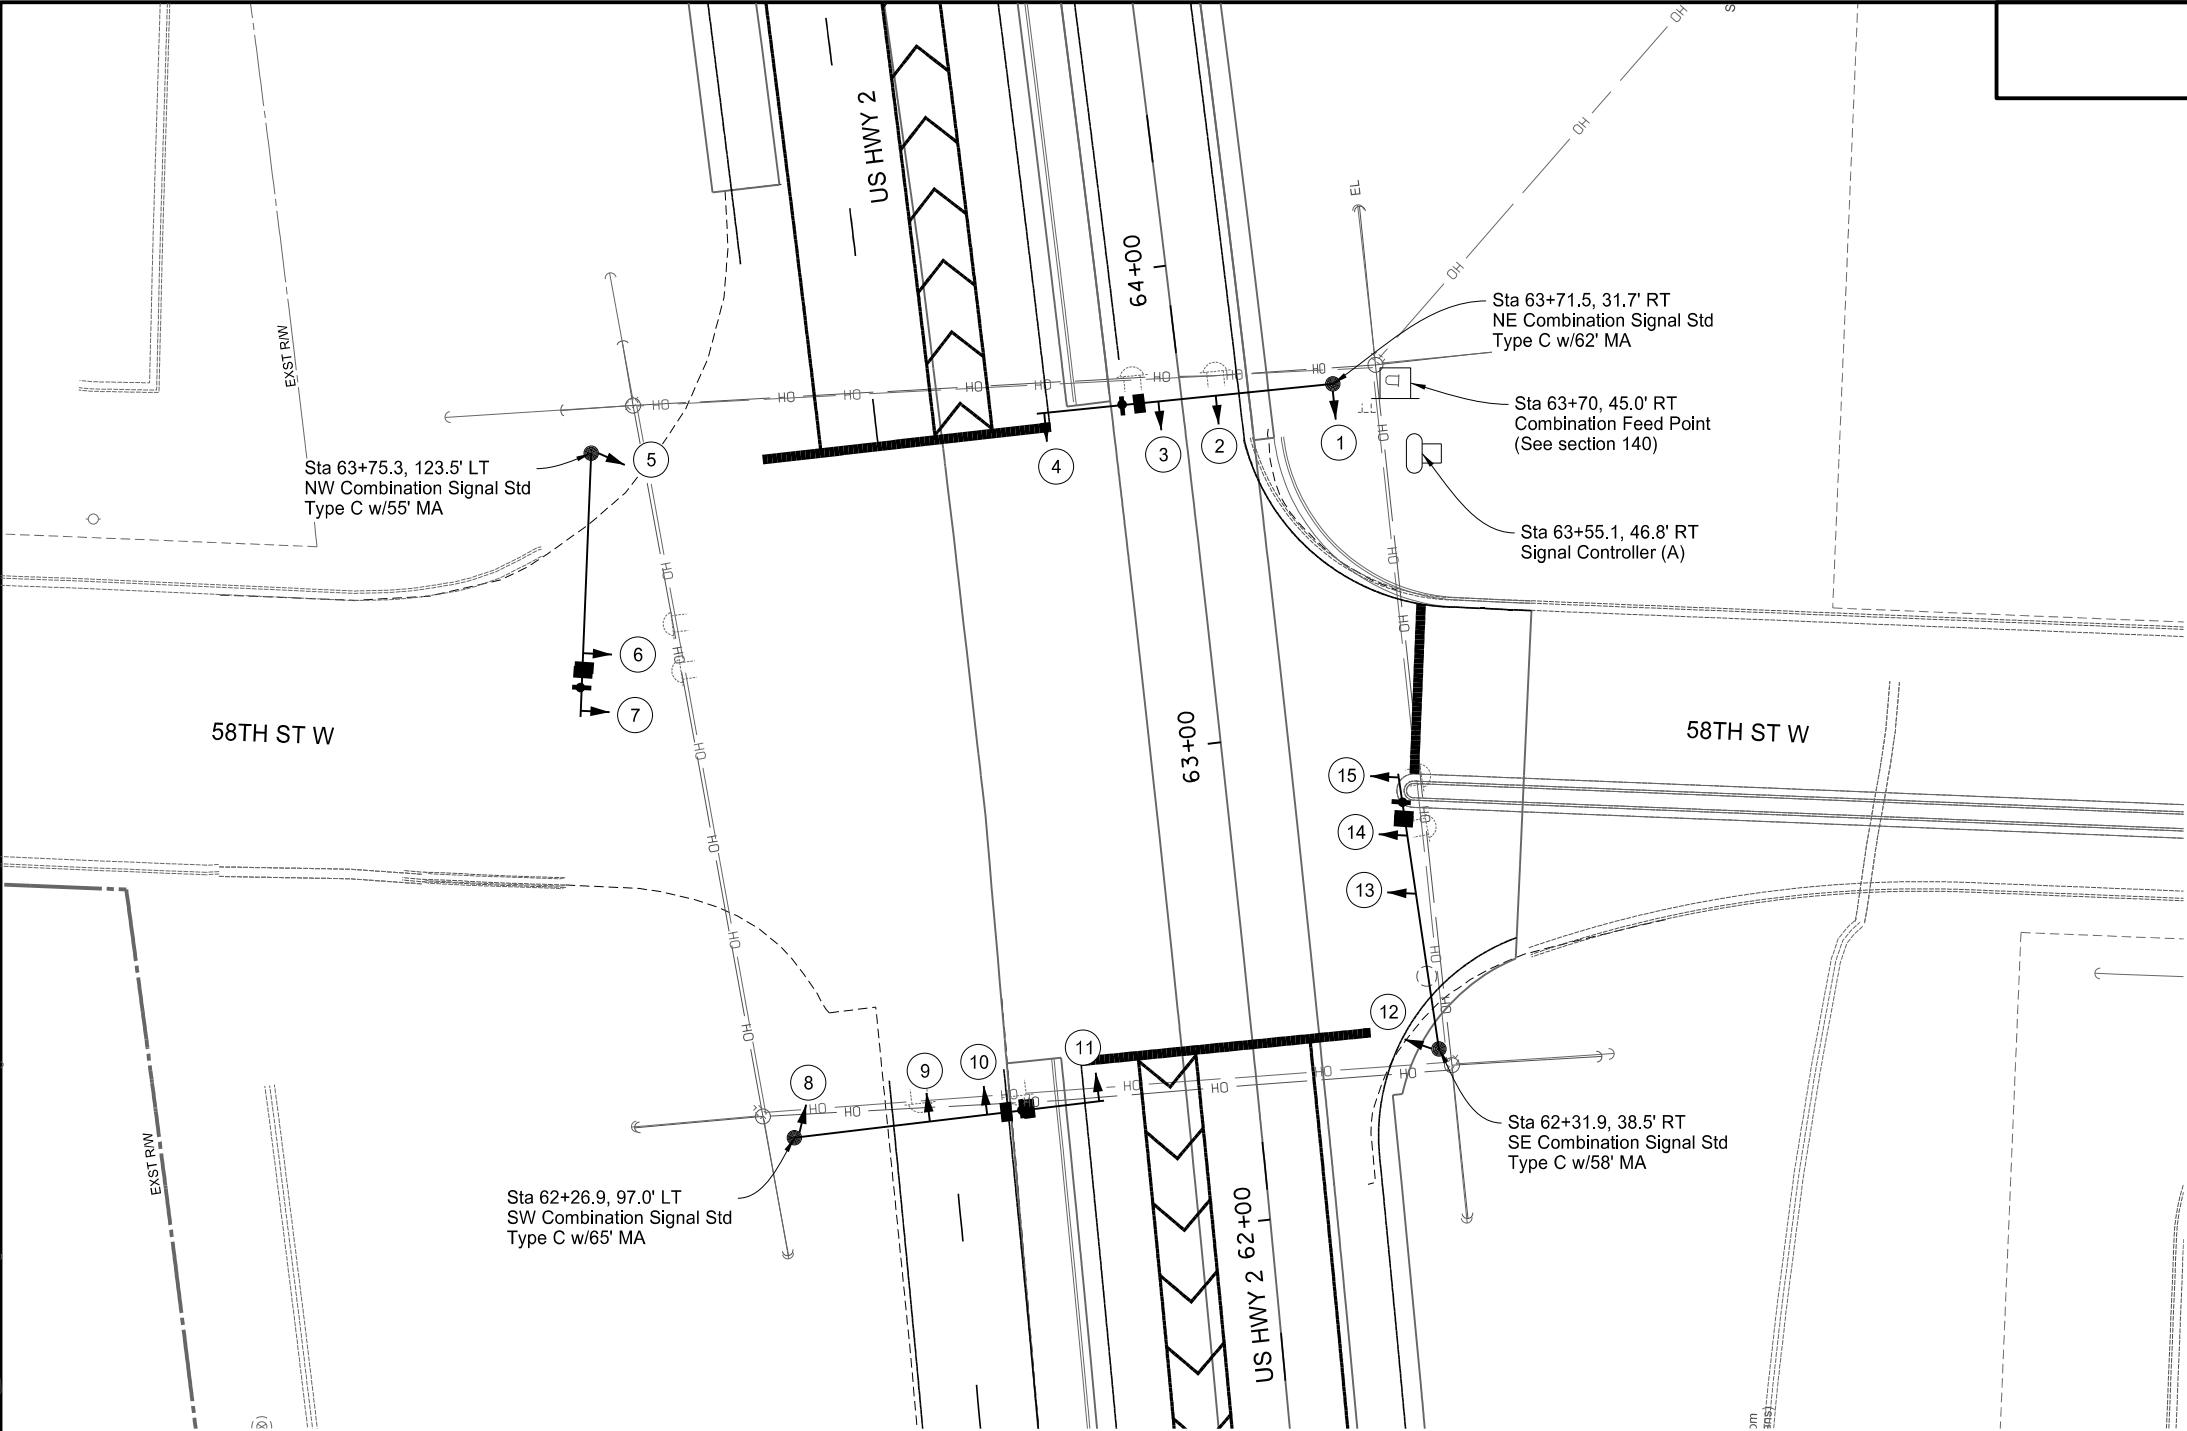

LEGEND

Signal controller

Signal head

EVP Detector

Video Detection Unit

Feed Point

Signal Foundation


(A): Face cabinet door east with hinges on the right side.

This document was originally issued and sealed by Joshua M. Loegering, Registration Number PE- 9139, on 07/28/17 and the original document is stored at the North Dakota Department of Transportation

US Hwy 2

Signal Layout
Intersection of 58th St W
Site 1

STATE	PROJECT NO.	SECTION NO.	SHEET NO.
ND	NH-NHU-7-002(156)022	150	2

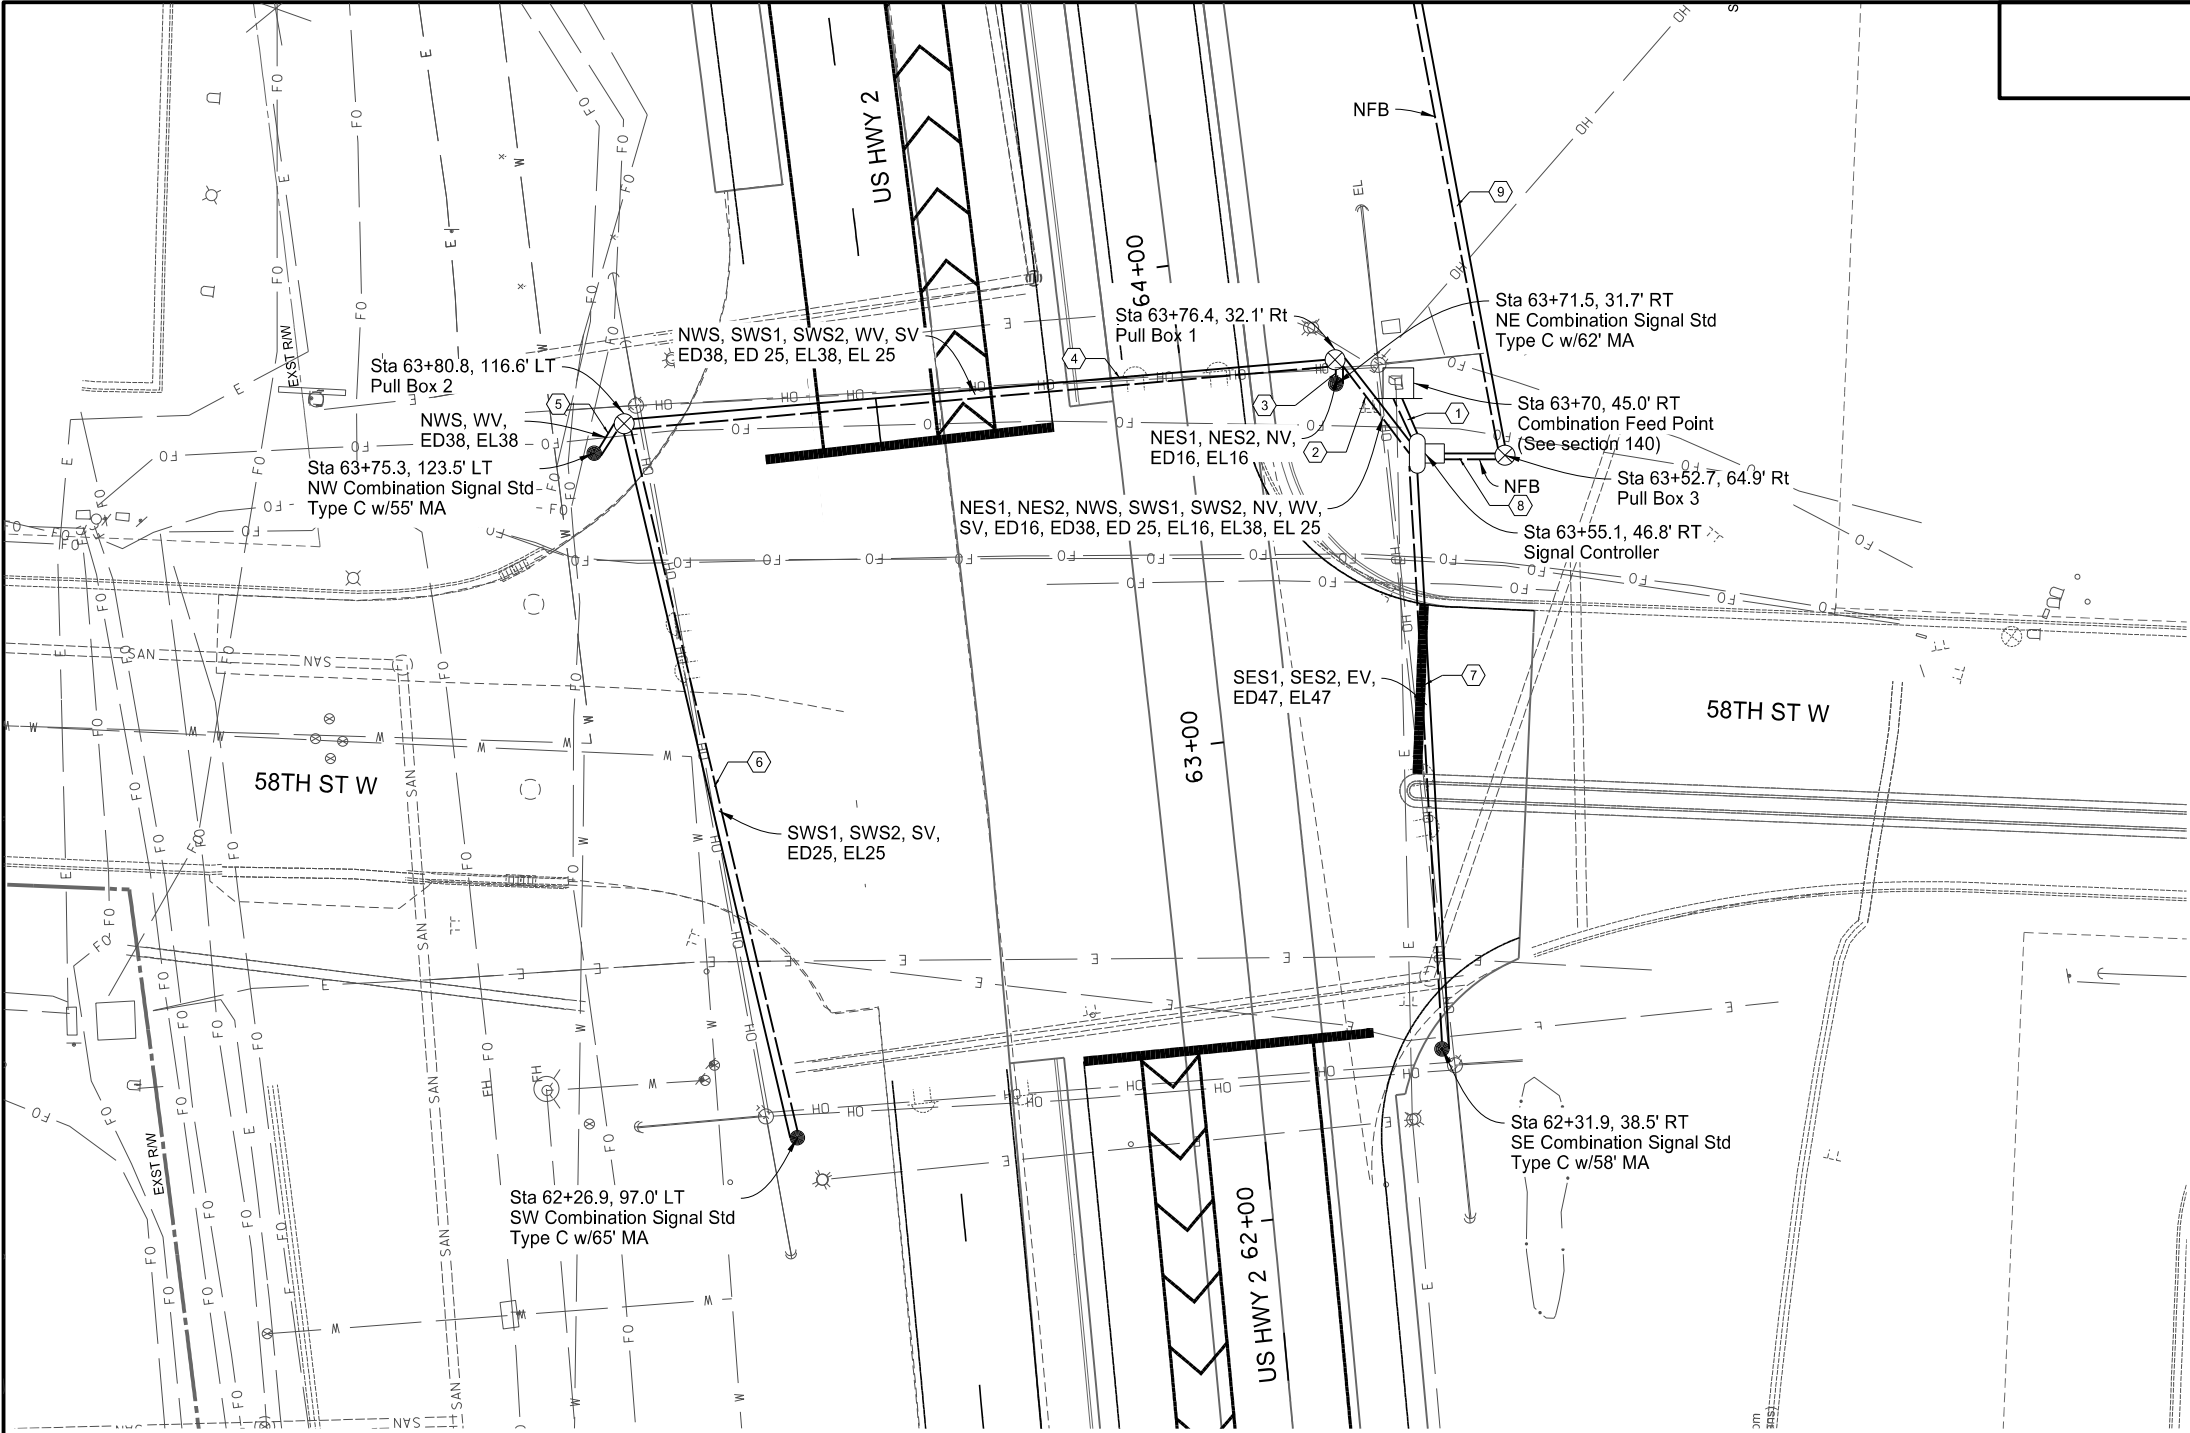

Cable Titles
NES1 = Northeast Combo Signal Standard
NES2 = Northeast Combo Signal Standard
NWS = Northwest Combo Signal Standard
SES1 = Southeast Combo Signal Standard
SES2 = Southeast Combo Signal Standard
SWS1= Southwest Combo Signal Standard
SWS2= Southwest Combo Signal Standard
NFB=North Flashing Beacon
NV = North Video Detection Unit
SV = South Video Detection Unit
EV = East Video Detection Unit
WV = West Video Detection Unit
ED16 = Ø1 + Ø6 EVP Detector
ED25 = Ø2 + Ø5 EVP Detector
ED38 = Ø3 + Ø8 EVP Detector
ED47 = Ø4 + Ø7 EVP Detector
EL16 = Ø1 + Ø6 EVP Light
EL25 = Ø2 + Ø5 EVP Light
EL38 = Ø3 + Ø8 EVP Light
EL47 = Ø4 + Ø7 EVP Light


LEGEND	
	Signal controller
	Cable & Conduit Run
	Pull Box
	Feed Point
	Signal Pole



This document was originally issued and sealed by Joshua M. Loegering, Registration Number PE- 9139, on 07/28/17 and the original document is stored at the North Dakota Department of Transportation

US Hwy 2
Conduit and Conductor Layout
Intersection of 58th St W
Site 1

	STATE	PROJECT NO.	SECTION NO.	SHEET NO.
	ND	NH-NHU-7-002(156)022	150	3

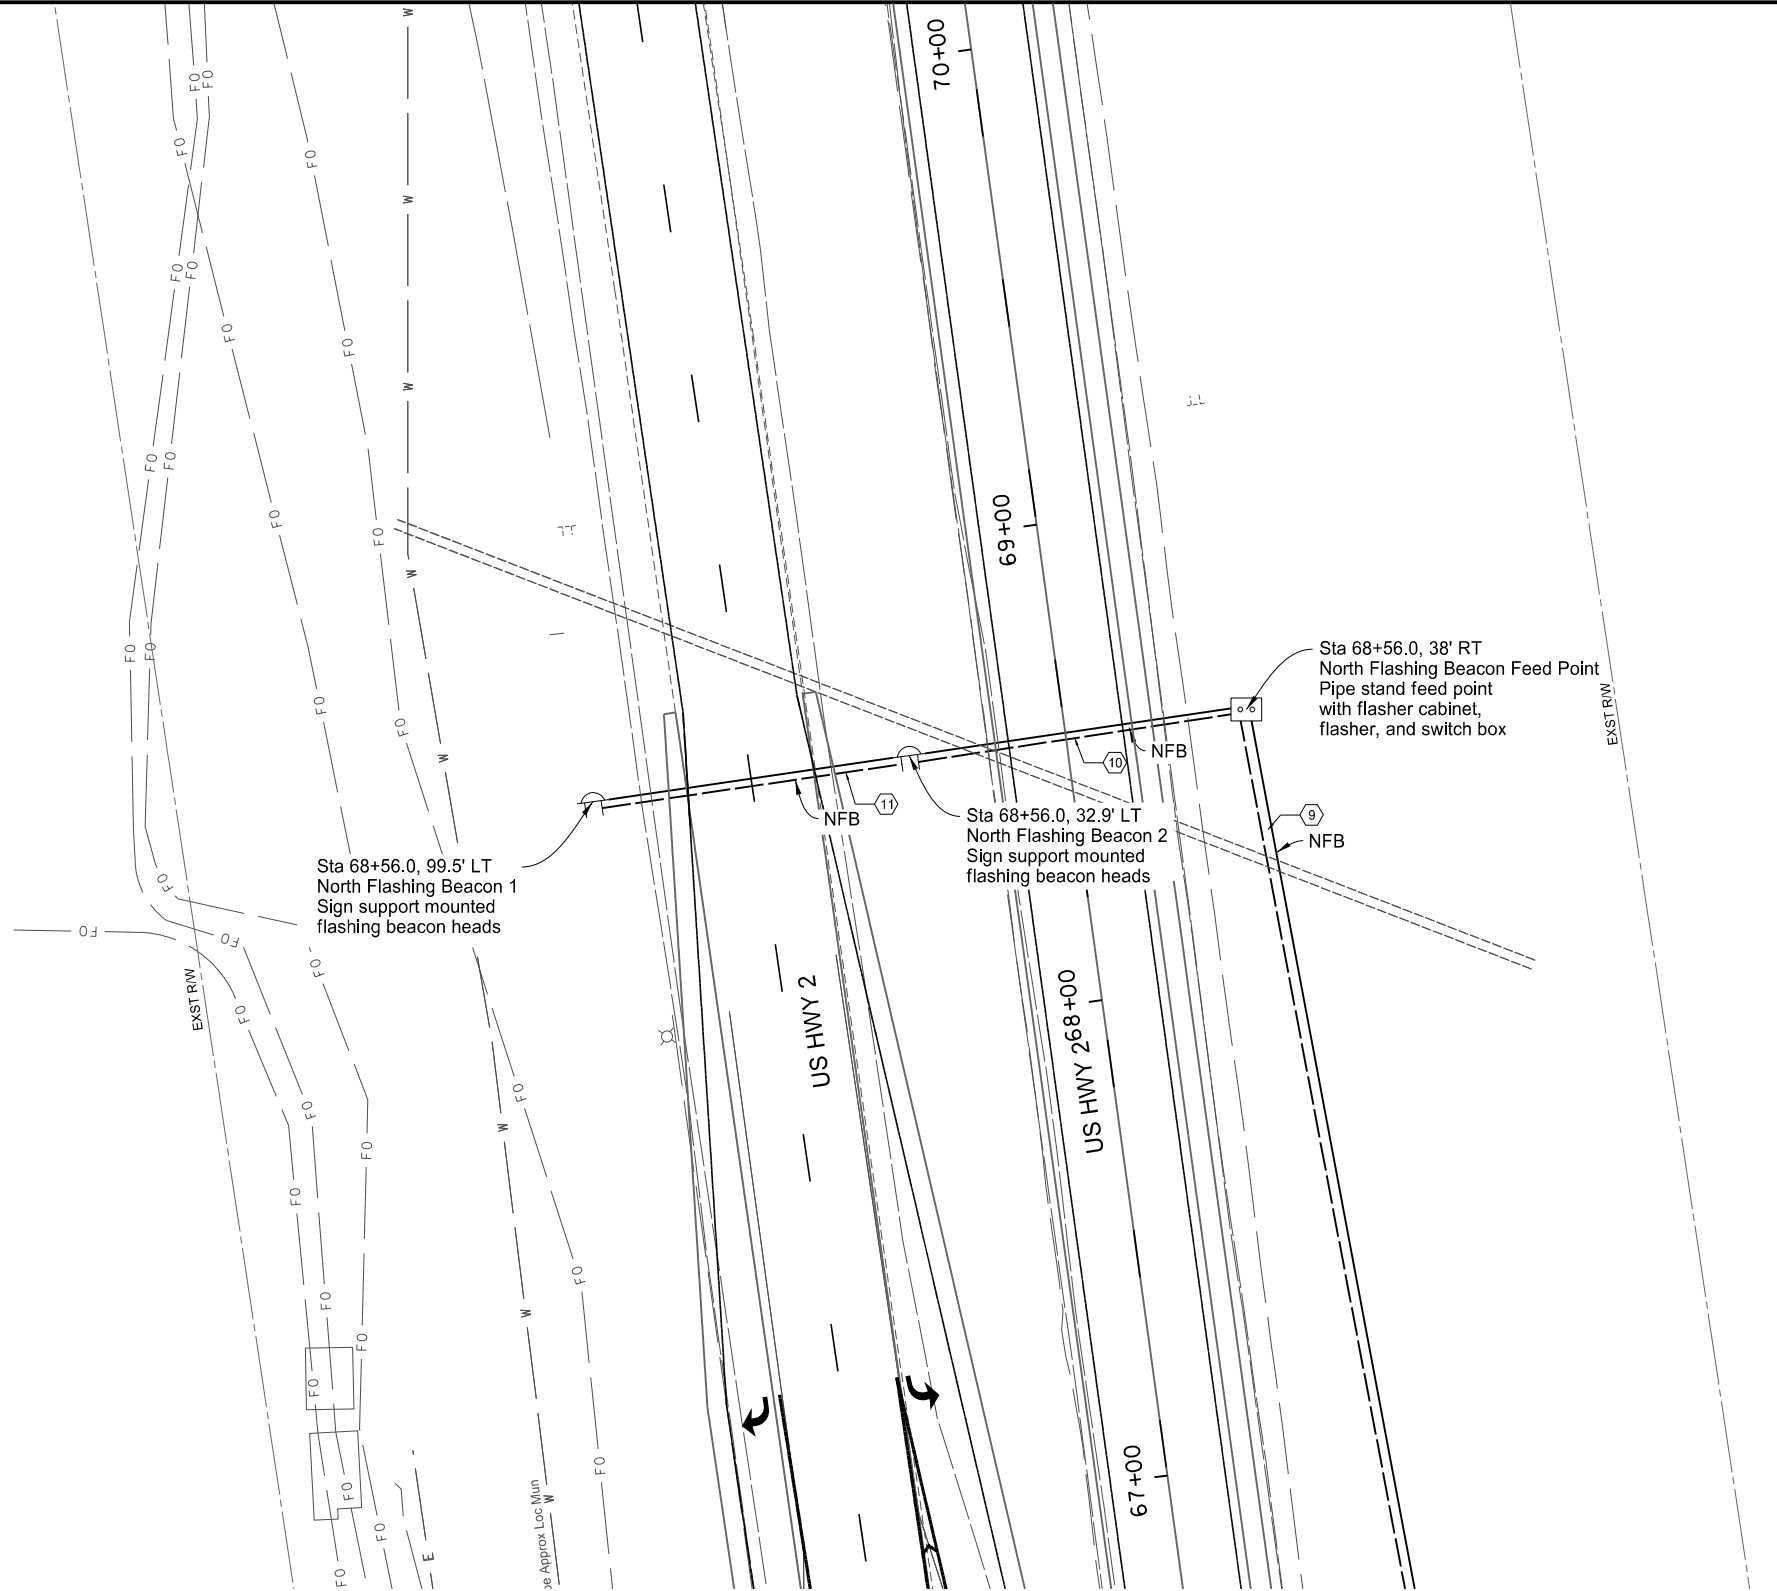

LEGEND


 Pipe Stand Feed Point

 Flashing Beacon



This document was originally issued and sealed by Joshua M. Loegering, Registration Number PE- 9139, on 07/28/17 and the original document is stored at the North Dakota Department of Transportation

US Hwy 2
North Flashing Beacon Layout
Intersection of 58th St W
Site 1

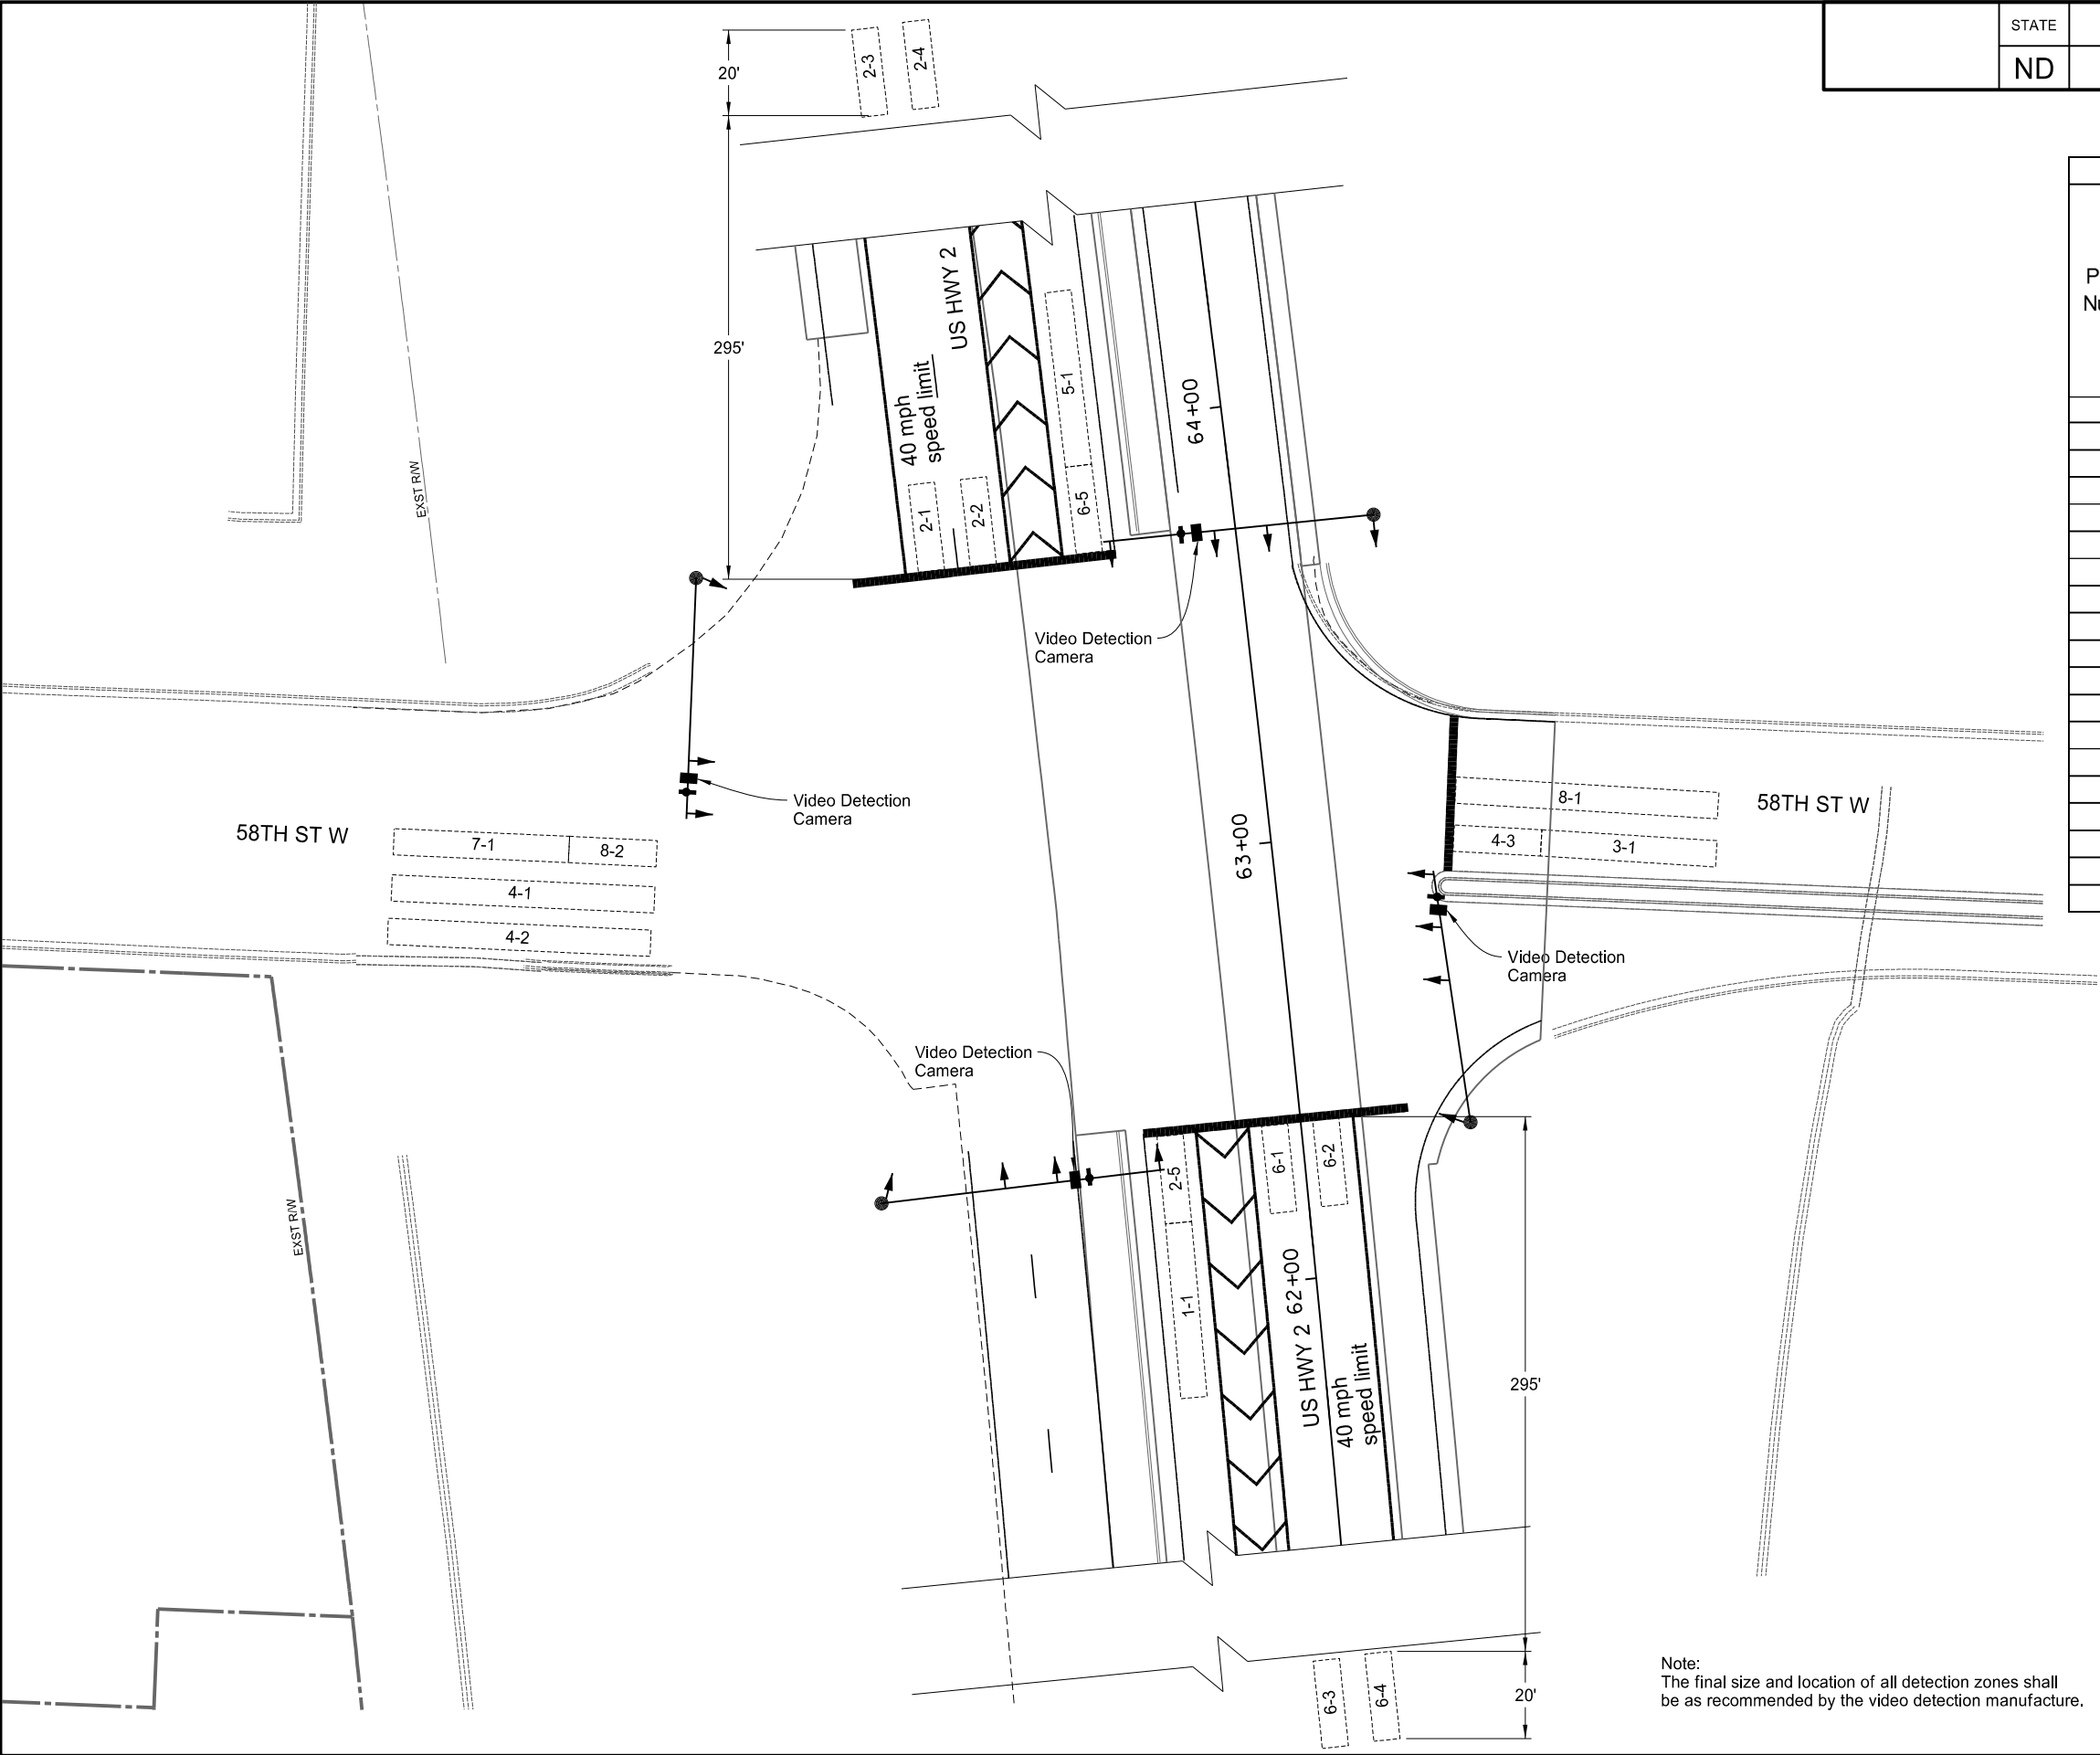

DETECTION ZONE SCHEDULE					
Phase-Number	Distance From Stop Bar (feet)	Length (feet)	Presence/Counting	Passage/Counting	Locking Memory
1-1	20	40	X		X
2-1	0	20		X	X
2-2	0	20		X	X
2-3	295	20		X	X
2-4	295	20		X	X
2-5	0	20	X		X
3-1	20	40	X		X
4-1	0	60	X		X
4-2	0	60	X		X
4-3	0	20	X		X
5-1	20	40	X		X
6-1	0	20		X	X
6-2	0	20		X	X
6-3	295	20		X	X
6-4	295	20		X	X
6-5	0	20	X		X
7-1	20	40	X		X
8-1	0	60	X		X
8-2	0	20	X		X




This document was originally issued and sealed by Joshua M. Loegering, Registration Number PE- 9139, on 07/28/17 and the original document is stored at the North Dakota Department of Transportation

US Hwy 2
Video Detection Zone Layout
Intersection of 58th St W
Site 1

Note:
The final size and location of all detection zones shall be as recommended by the video detection manufacture.

	STATE	PROJECT NO.	SECTION NO.	SHEET NO.
	ND	NH-NHU-7-002(156)022	150	5

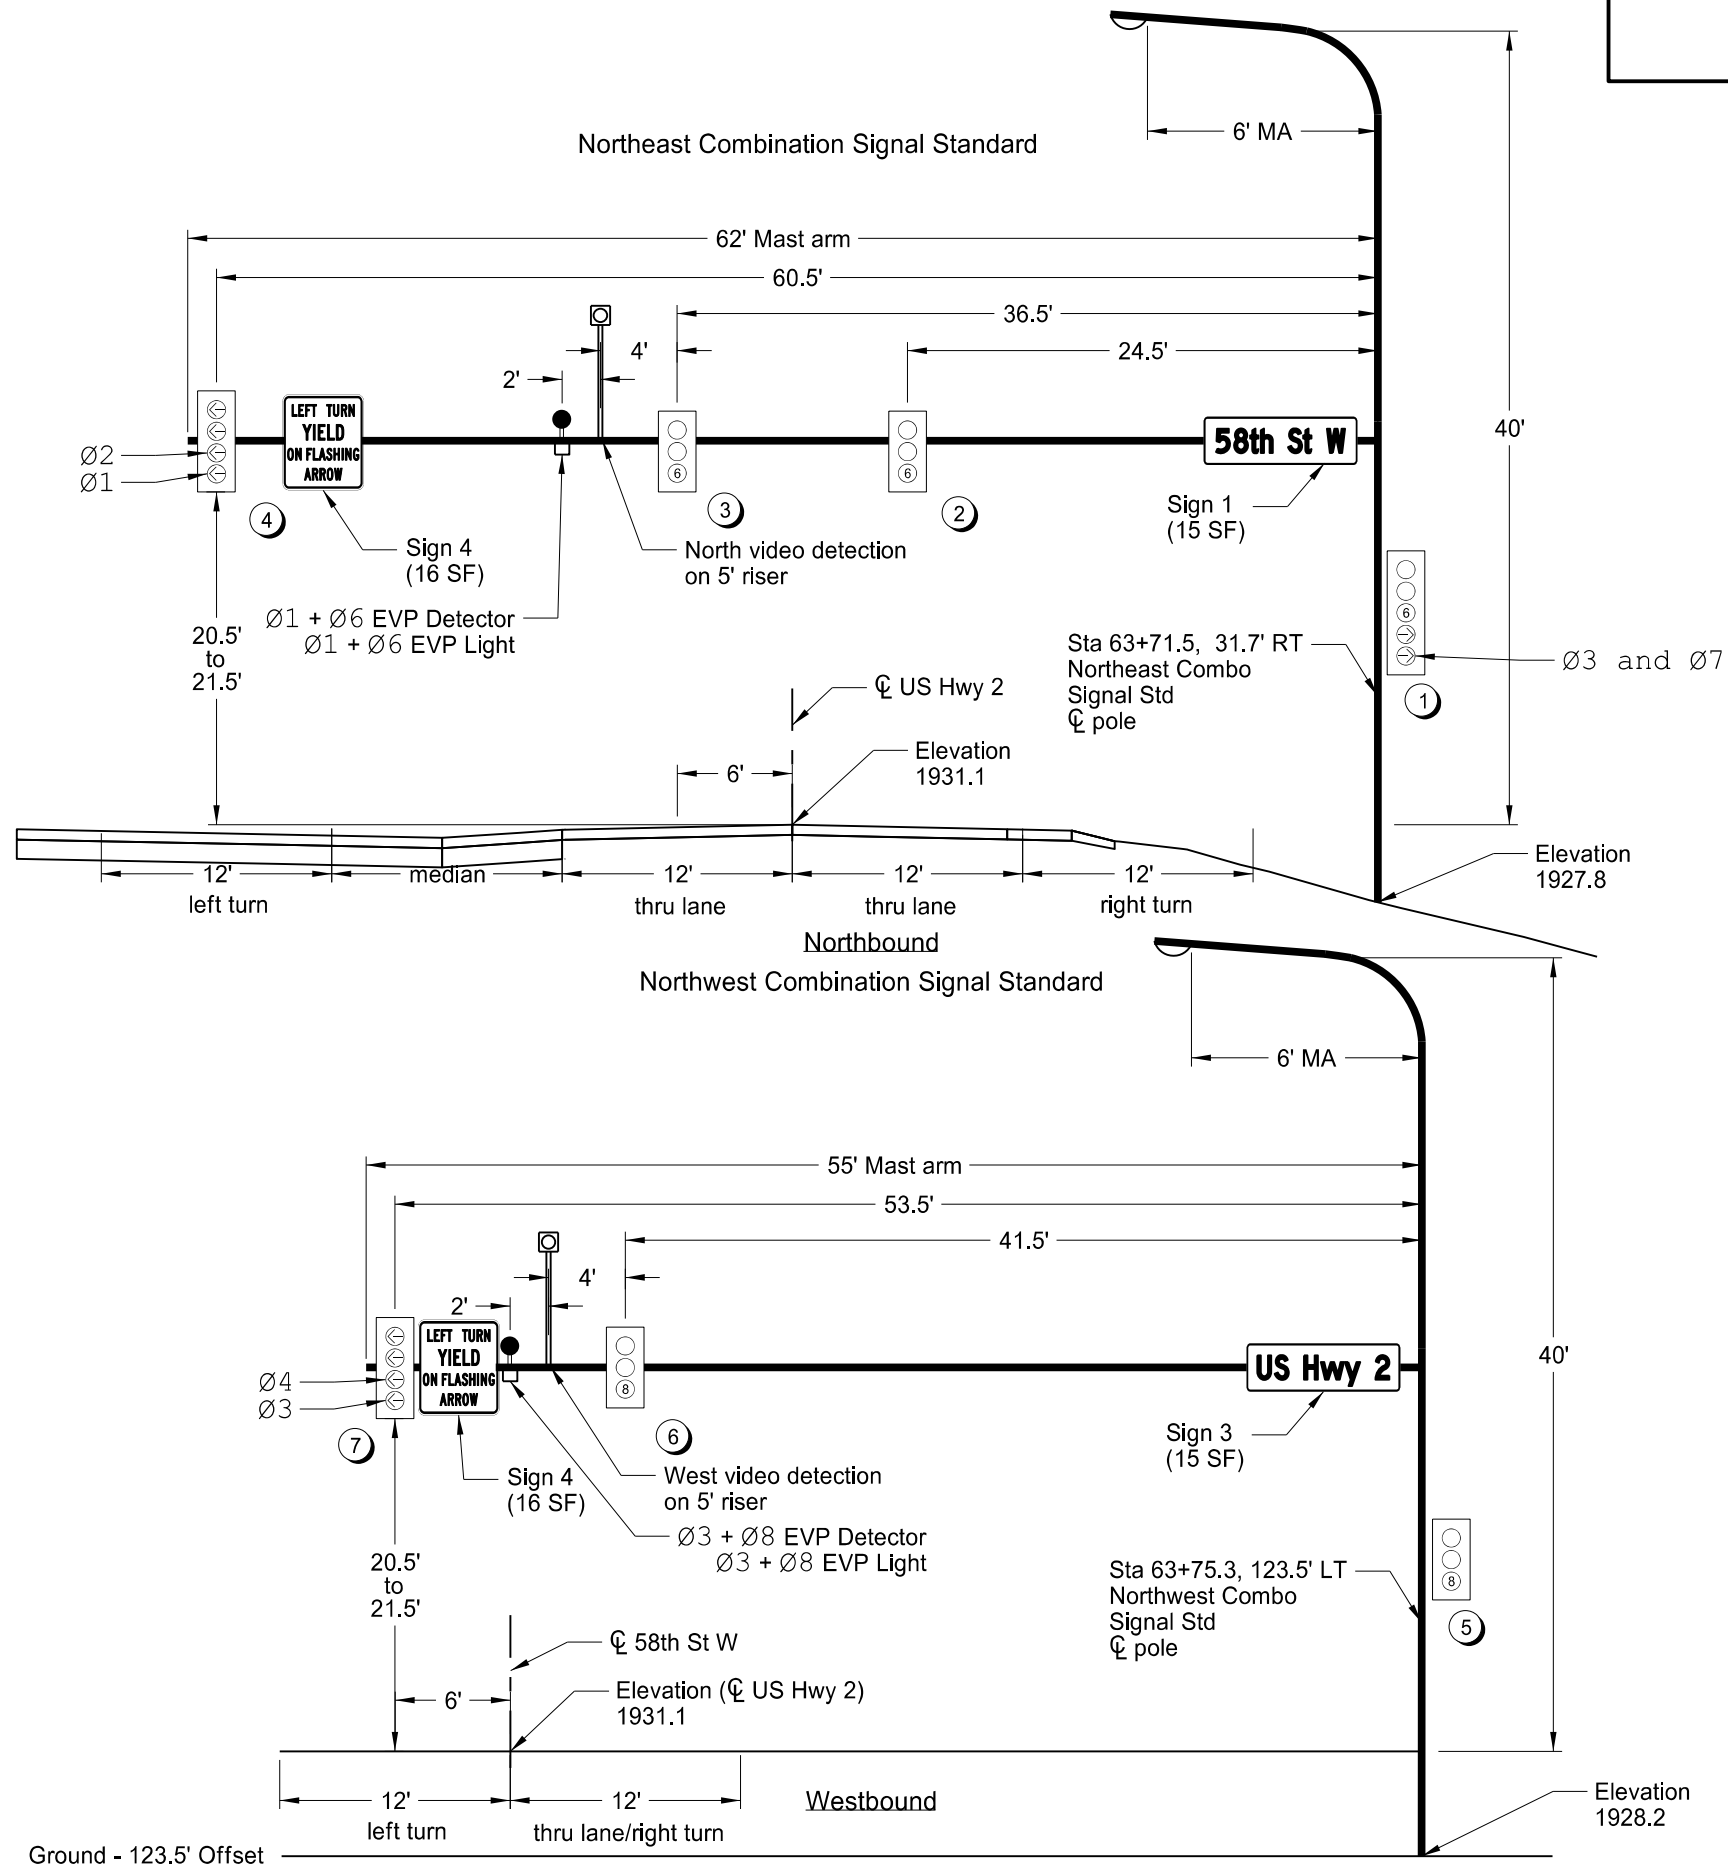

LEGEND

Video Detection Camera

Traffic Signal Head w/ associated phase

Signal Head Number

EVP Light

EVP Detector

This document was originally issued and sealed by Joshua M. Loegering, Registration Number PE- 9139, on 07/28/17 and the original document is stored at the North Dakota Department of Transportation

US Hwy 2

Signal Standards and Head Locations
Intersection of 58th St W
Site 1

Phase 1	Phase 2	Phase 3	Phase 4	Phase 5	Phase 6	Phase 7	Phase 8
NB Left	SB Thru	WB Left	EB Thru	SB Left	NB Thru	EB Left	WB Thru

BASIC INTERVALS (OR FUNCTIONS)

Minimum Green/Initial	5.0	15.0	5.0	10.0	5.0	15.0	5.0	10.0
Minimum Initial with Pedestrian Actuation*								
Passage Time	2.0	5.0	2.0	2.0	2.0	5.0	2.0	2.0
Maximum Green	30.0	60.0	30.0	30.0	30.0	60.0	30.0	30.0
Yellow Change	3.0	3.9	3.0	3.2	3.0	3.9	3.0	3.2
Red Clearance	2.7	1.9	3.0	3.5	2.8	1.9	3.3	3.2
Walk								
Pedestrian Clearance								

EB = Eastbound (58th St W)
WB = Westbound (58th St W)
NB = Northbound (US Hwy 2)
SB = Southbound (US Hwy 2)


VOLUME DENSITY TIMING FUNCTIONS - ONLY APPLICABLE DURING "FREE" (UNCOORDINATED) TIMING PLAN

Minimum Initial		15.0				15.0		
Added Initial per Actuation		1.5				1.5		

Minimum Gap		2.0				2.0		
Time to Reduce to Minimum Gap		18.0				18.0		
Time Before Reduction		30.0				30.0		

OTHER CONTROLLER FUNCTIONS

Recall	No	Minimum	No	No	No	Minimum	No	No
Flashing-Normal & Conflict Monitor	R	Y	R	R	R	Y	R	R
Start Up Phasing	R	G	R	R	R	G	R	R
Emergency Vehicle Pre-emption	x	x	x	x	x	x	x	x
Type of Detector	Presence	Refer to Detector Zone Table						
	Calling							
	Passage							
Locking Memory								
Non-Locking Memory								

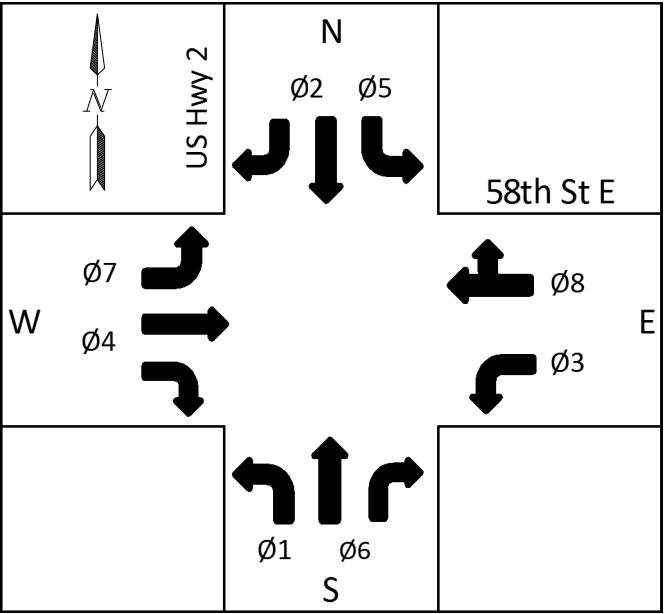

This document was originally issued and sealed by Joshua M. Loegering, Registration Number PE- 9139, on 07/28/17 and the original document is stored at the North Dakota Department of Transportation

US Hwy 2
Controller Settings
Intersection of 58th St W

RUN			CONDUIT		NOTES	CABLE					
#	ITEM		STATION, OFFSET	SIZE (IN)	LF	Origin	Destination	# of Cables	SIZE/TYPE	Total LF	TITLE
1	<i>Origin</i> <i>Destination</i>	Combination Feed Point Traffic Signal Controller	63+70.0, 45.0' RT	2	15	Combination Feed Point Combination Feed Point	Traffic Signal Controller	2	UNDERGROUND CONDUCTOR NO 6-TYPE RHW	68	
			63+55.1, 46.8' RT				Traffic Signal Controller	1	UNDERGROUND CONDUCTOR NO 6-TYPE THW	34	
2	<i>Origin</i> <i>Destination</i>	Traffic Signal Controller Pull Box 1	63+55.1, 46.8' RT	4	30	Traffic Signal Controller Traffic Signal Controller Traffic Signal Controller Traffic Signal Controller Traffic Signal Controller	Pull Box 1	3	12 AWG 12 CONDUCTOR CABLE	135	NES1, NWS, SWS1
			63+76.4, 32.1' RT				Pull Box 1	2	12 AWG 7 CONDUCTOR CABLE	90	NES2, SWS2
							Pull Box 1	3	VIDEO DETECTION CABLE	135	NV, WV, SV
							Pull Box 1	3	EMERGENCY VEHICLE DETECTOR CABLE	135	ED16, ED38, ED25
							Pull Box 1	3	12 AWG 2 CONDUCTOR CABLE	135	EL16, EL38, EL25
3	<i>Origin</i> <i>Destination</i>	Pull Box 1 Northeast Combo Signal Std	63+76.4, 32.1' RT	2	5	Pull Box 1 Pull Box 1 Pull Box 1 Pull Box 1 Pull Box 1	Northeast Combo Signal Std Transformer Base	1	12 AWG 12 CONDUCTOR CABLE	16	NES1
			63+71.5, 31.7' RT				Northeast Combo Signal Std Transformer Base	1	12 AWG 7 CONDUCTOR CABLE	16	NES2
							North Video Detection Unit	1	VIDEO DETECTION CABLE	83	NV
							Northeast Emergency Preemption Detector	1	EMERGENCY VEHICLE DETECTOR CABLE	80	ED16
							Northeast Emergency Preemption Lamp	1	12 AWG 2 CONDUCTOR CABLE	80	EL16
4	<i>Origin</i> <i>Destination</i>	Pull Box 1 Pull Box 2	63+76.4, 32.1' RT	4	150	Pull Box 1 Pull Box 1 Pull Box 1 Pull Box 1 Pull Box 1	Pull Box 2	2	12 AWG 12 CONDUCTOR CABLE	324	NWS, SWS1
			63+80.8, 116.6' LT				Pull Box 2	1	12 AWG 7 CONDUCTOR CABLE	162	SWS2
							Pull Box 2	2	VIDEO DETECTION CABLE	324	WV, SV
							Pull Box 2	2	EMERGENCY VEHICLE DETECTOR CABLE	324	ED38, ED25
							Pull Box 2	2	12 AWG 2 CONDUCTOR CABLE	324	EL38, EL25
5	<i>Origin</i> <i>Destination</i>	Pull Box 2 Northwest Combo Signal Std	63+80.8, 116.6' LT	2	10	Pull Box 2 Pull Box 2 Pull Box 2 Pull Box 2	Northwest Combo Signal Std Transformer Base	1	12 AWG 12 CONDUCTOR CABLE	21	NWS
			63+75.3, 123.5' LT				West Video Detection Unit	1	VIDEO DETECTION CABLE	93	WV
							Northwest Emergency Preemption Detector	1	EMERGENCY VEHICLE DETECTOR CABLE	90	ED38
							Northwest Emergency Preemption Lamp	1	12 AWG 2 CONDUCTOR CABLE	90	EL38
6	<i>Origin</i> <i>Destination</i>	Pull Box 2 Southwest Combo Signal Std	63+80.8, 116.6' LT	4	155	Pull Box 2 Pull Box 2 Pull Box 2 Pull Box 2 Pull Box 2	Southwest Combo Signal Std Transformer Base	1	12 AWG 12 CONDUCTOR CABLE	166	SWS1
			62+26.9, 97.0' LT				Southwest Combo Signal Std Transformer Base	1	12 AWG 7 CONDUCTOR CABLE	166	SWS2
							South Video Detection Unit	1	VIDEO DETECTION CABLE	237	SV
							Southwest Emergency Preemption Detector	1	EMERGENCY VEHICLE DETECTOR CABLE	234	ED25
							Southwest Emergency Preemption Lamp	1	12 AWG 2 CONDUCTOR CABLE	234	EL25
7	<i>Origin</i> <i>Destination</i>	Traffic Signal Controller Southeast Combo Signal Std	63+55.1, 46.8' RT	4	125	Traffic Signal Controller Traffic Signal Controller Traffic Signal Controller Traffic Signal Controller Traffic Signal Controller	Southeast Combo Signal Std Transformer Base	1	12 AWG 12 CONDUCTOR CABLE	139	SES1
			62+31.9, 38.5' RT				Southeast Combo Signal Std Transformer Base	1	12 AWG 7 CONDUCTOR CABLE	139	SES2
							East Video Detection Unit	1	VIDEO DETECTION CABLE	214	EV
							Southeast Emergency Preemption Detector	1	EMERGENCY VEHICLE DETECTOR CABLE	211	ED47
							Southeast Emergency Preemption Lamp	1	12 AWG 2 CONDUCTOR CABLE	211	EL47
8	<i>Origin</i> <i>Destination</i>	Traffic Signal Controller Pull Box 3	63+55.1, 46.8' RT	2	20	Traffic Signal Controller	Pull Box 3	2	12 AWG 7 CONDUCTOR CABLE	70	NFB
			63+52.7, 64.9' RT								
9	<i>Origin</i> <i>Destination</i>	Pull Box 3 North Flashing Beacon Feed Point	63+52.7, 64.9' RT	2	505	Pull Box 3	North Flashing Beacon Feed Point	1	12 AWG 7 CONDUCTOR CABLE	521	NFB
			68+56.0, 38.0' RT								
10	<i>Origin</i> <i>Destination</i>	North Flashing Beacon Feed Point North Flashing Beacon 2	68+56.0, 38.0' RT	2	75	North Flashing Beacon Feed Point	North Flashing Beacon 2	1	12 AWG 7 CONDUCTOR CABLE	100	NFB
			68+56.0, 32.9' LT								
11	<i>Origin</i> <i>Destination</i>	North Flashing Beacon 2 North Flashing Beacon 1	68+56.0, 32.9' LT	2	70	North Flashing Beacon 2	North Flashing Beacon 1	1	12 AWG 7 CONDUCTOR CABLE	100	NFB
			68+56.0, 99.5' LT								





Origin	Destination	# of Cables	SIZE/TYPE	Total LF
Northeast Combo Signal Std Transformer Base	Vehicle Head 1	1	12 AWG 7 CONDUCTOR CABLE	20
	Vehicle Head 2	1	12 AWG 5 CONDUCTOR CABLE	53
	Vehicle Head 3	1	12 AWG 5 CONDUCTOR CABLE	65
	Vehicle Head 4	1	12 AWG 7 CONDUCTOR CABLE	89
Northwest Combo Signal Std Transformer Base	Vehicle Head 5	1	12 AWG 5 CONDUCTOR CABLE	20
	Vehicle Head 6	1	12 AWG 5 CONDUCTOR CABLE	70
	Vehicle Head 7	1	12 AWG 7 CONDUCTOR CABLE	82
Southwest Combo Signal Std Transformer Base	Vehicle Head 8	1	12 AWG 7 CONDUCTOR CABLE	20
	Vehicle Head 9	1	12 AWG 5 CONDUCTOR CABLE	57
	Vehicle Head 10	1	12 AWG 5 CONDUCTOR CABLE	69
	Vehicle Head 11	1	12 AWG 7 CONDUCTOR CABLE	92
Southeast Combo Signal Std Transformer Base	Vehicle Head 12	1	12 AWG 7 CONDUCTOR CABLE	20
	Vehicle Head 13	1	12 AWG 5 CONDUCTOR CABLE	61
	Vehicle Head 14	1	12 AWG 5 CONDUCTOR CABLE	73
	Vehicle Head 15	1	12 AWG 7 CONDUCTOR CABLE	85

Cable Titles
NES1 = Northeast Combo Signal Standard
NES2 = Northeast Combo Signal Standard
NWS = Northwest Combo Signal Standard
SES1 = Southeast Combo Signal Standard
SES2 = Southeast Combo Signal Standard
SWS1= Southwest Combo Signal Standard
SWS2= Southwest Combo Signal Standard
NFB=North Flashing Beacon
NV = North Video Detection Unit
SV = South Video Detection Unit
EV = East Video Detection Unit
WV = West Video Detection Unit
ED16 = Ø1 + Ø6 EVP Detector
ED25 = Ø2 + Ø5 EVP Detector
ED38 = Ø3 + Ø8 EVP Detector
ED47 = Ø4 + Ø7 EVP Detector
EL16 = Ø1 + Ø6 EVP Light
EL25 = Ø2 + Ø5 EVP Light
EL38 = Ø3 + Ø8 EVP Light
EL47 = Ø4 + Ø7 EVP Light

This document was originally issued and sealed by Joshua M. Loegering, Registration Number PE- 9139, on 07/28/17 and the original document is stored at the North Dakota Department of Transportation

US Hwy 2
Cable and Conduit Schedule
Intersection of 58th St W
Site 1

	STATE	PROJECT NO.	SECTION NO.	SHEET NO.
	ND	NH-NHU-7-002(156)022	150	10

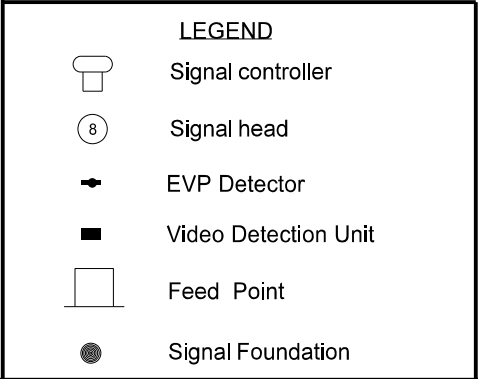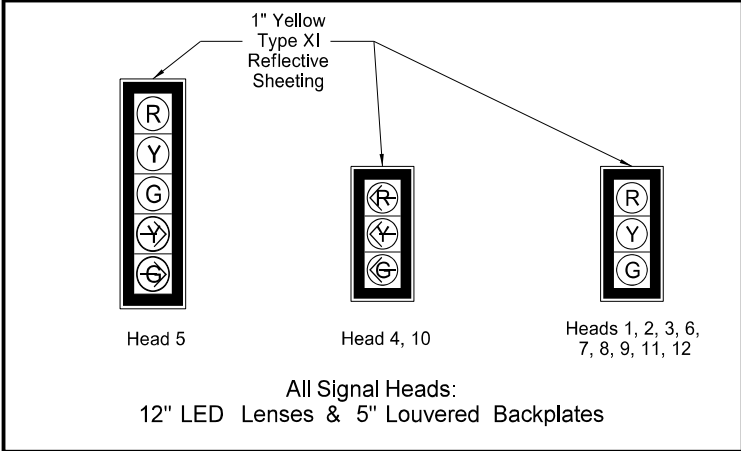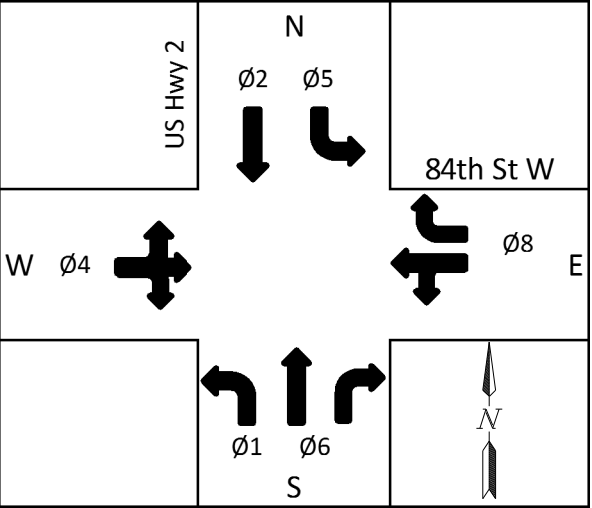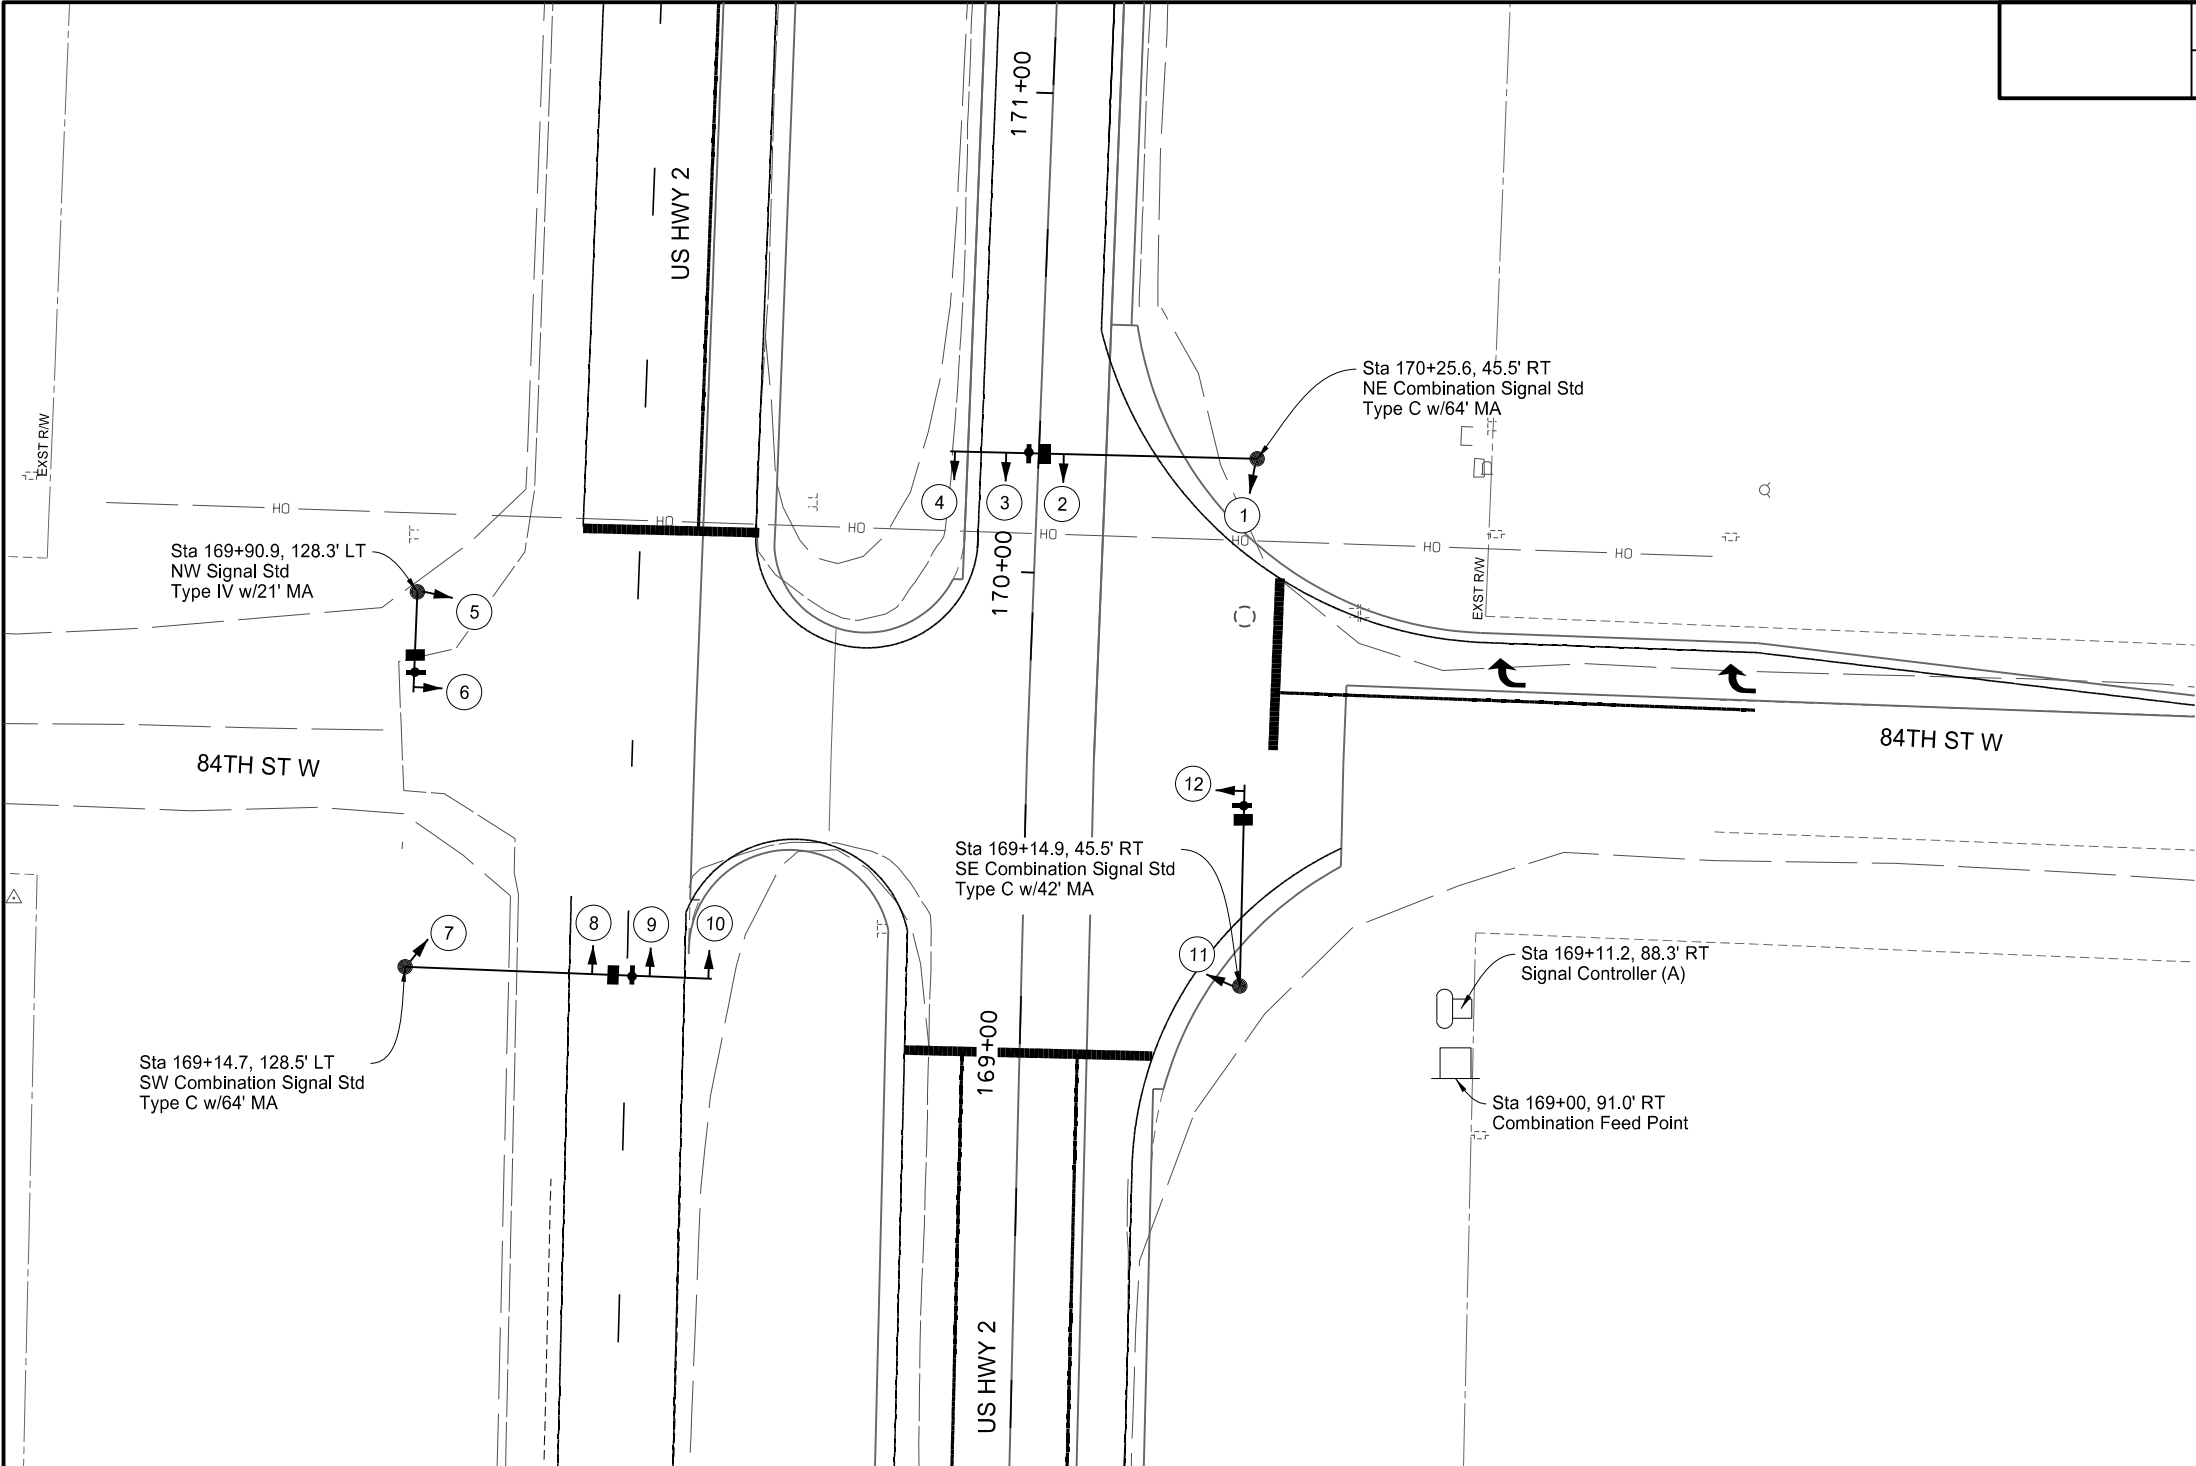



(A): Face cabinet door east with hinges on the right side.

This document was originally issued and sealed by Joshua M. Loegering, Registration Number PE- 9139, on 07/28/17 and the original document is stored at the North Dakota Department of Transportation

US Hwy 2

Signal Layout
Intersection of 84th St W
Site 2

	STATE	PROJECT NO.	SECTION NO.	SHEET NO.
	ND	NH-NHU-7-002(156)022	150	11

 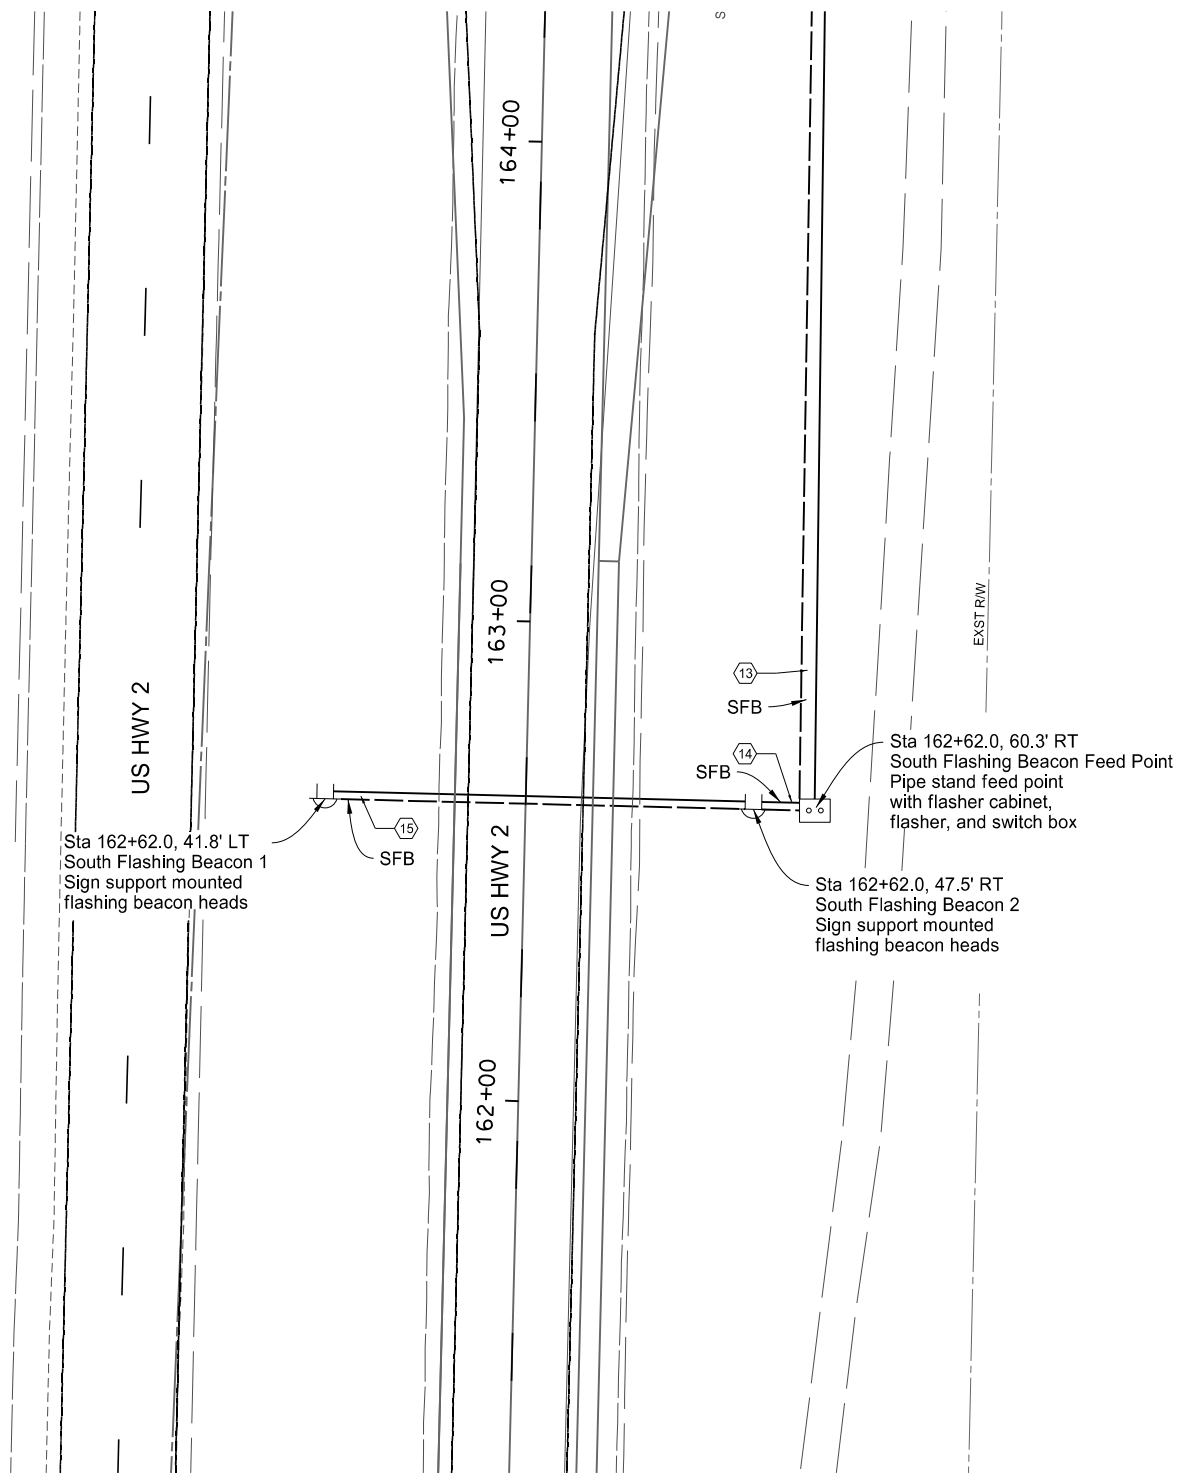

This document was originally
issued and sealed by
Joshua M. Loegering,
Registration Number
PE- 9139,
on 07/28/17 and the original
document is stored at the
North Dakota Department
of Transportation

LEGEND



Pipe Stand Feed Point




Flashing Beacon

US Hwy 2

South Flashing Beacon Layout
Intersection of 84th St W
Site 2

STATE	PROJECT NO.	SECTION NO.	SHEET NO.
ND	NH-NHU-7-002(156)022	150	12

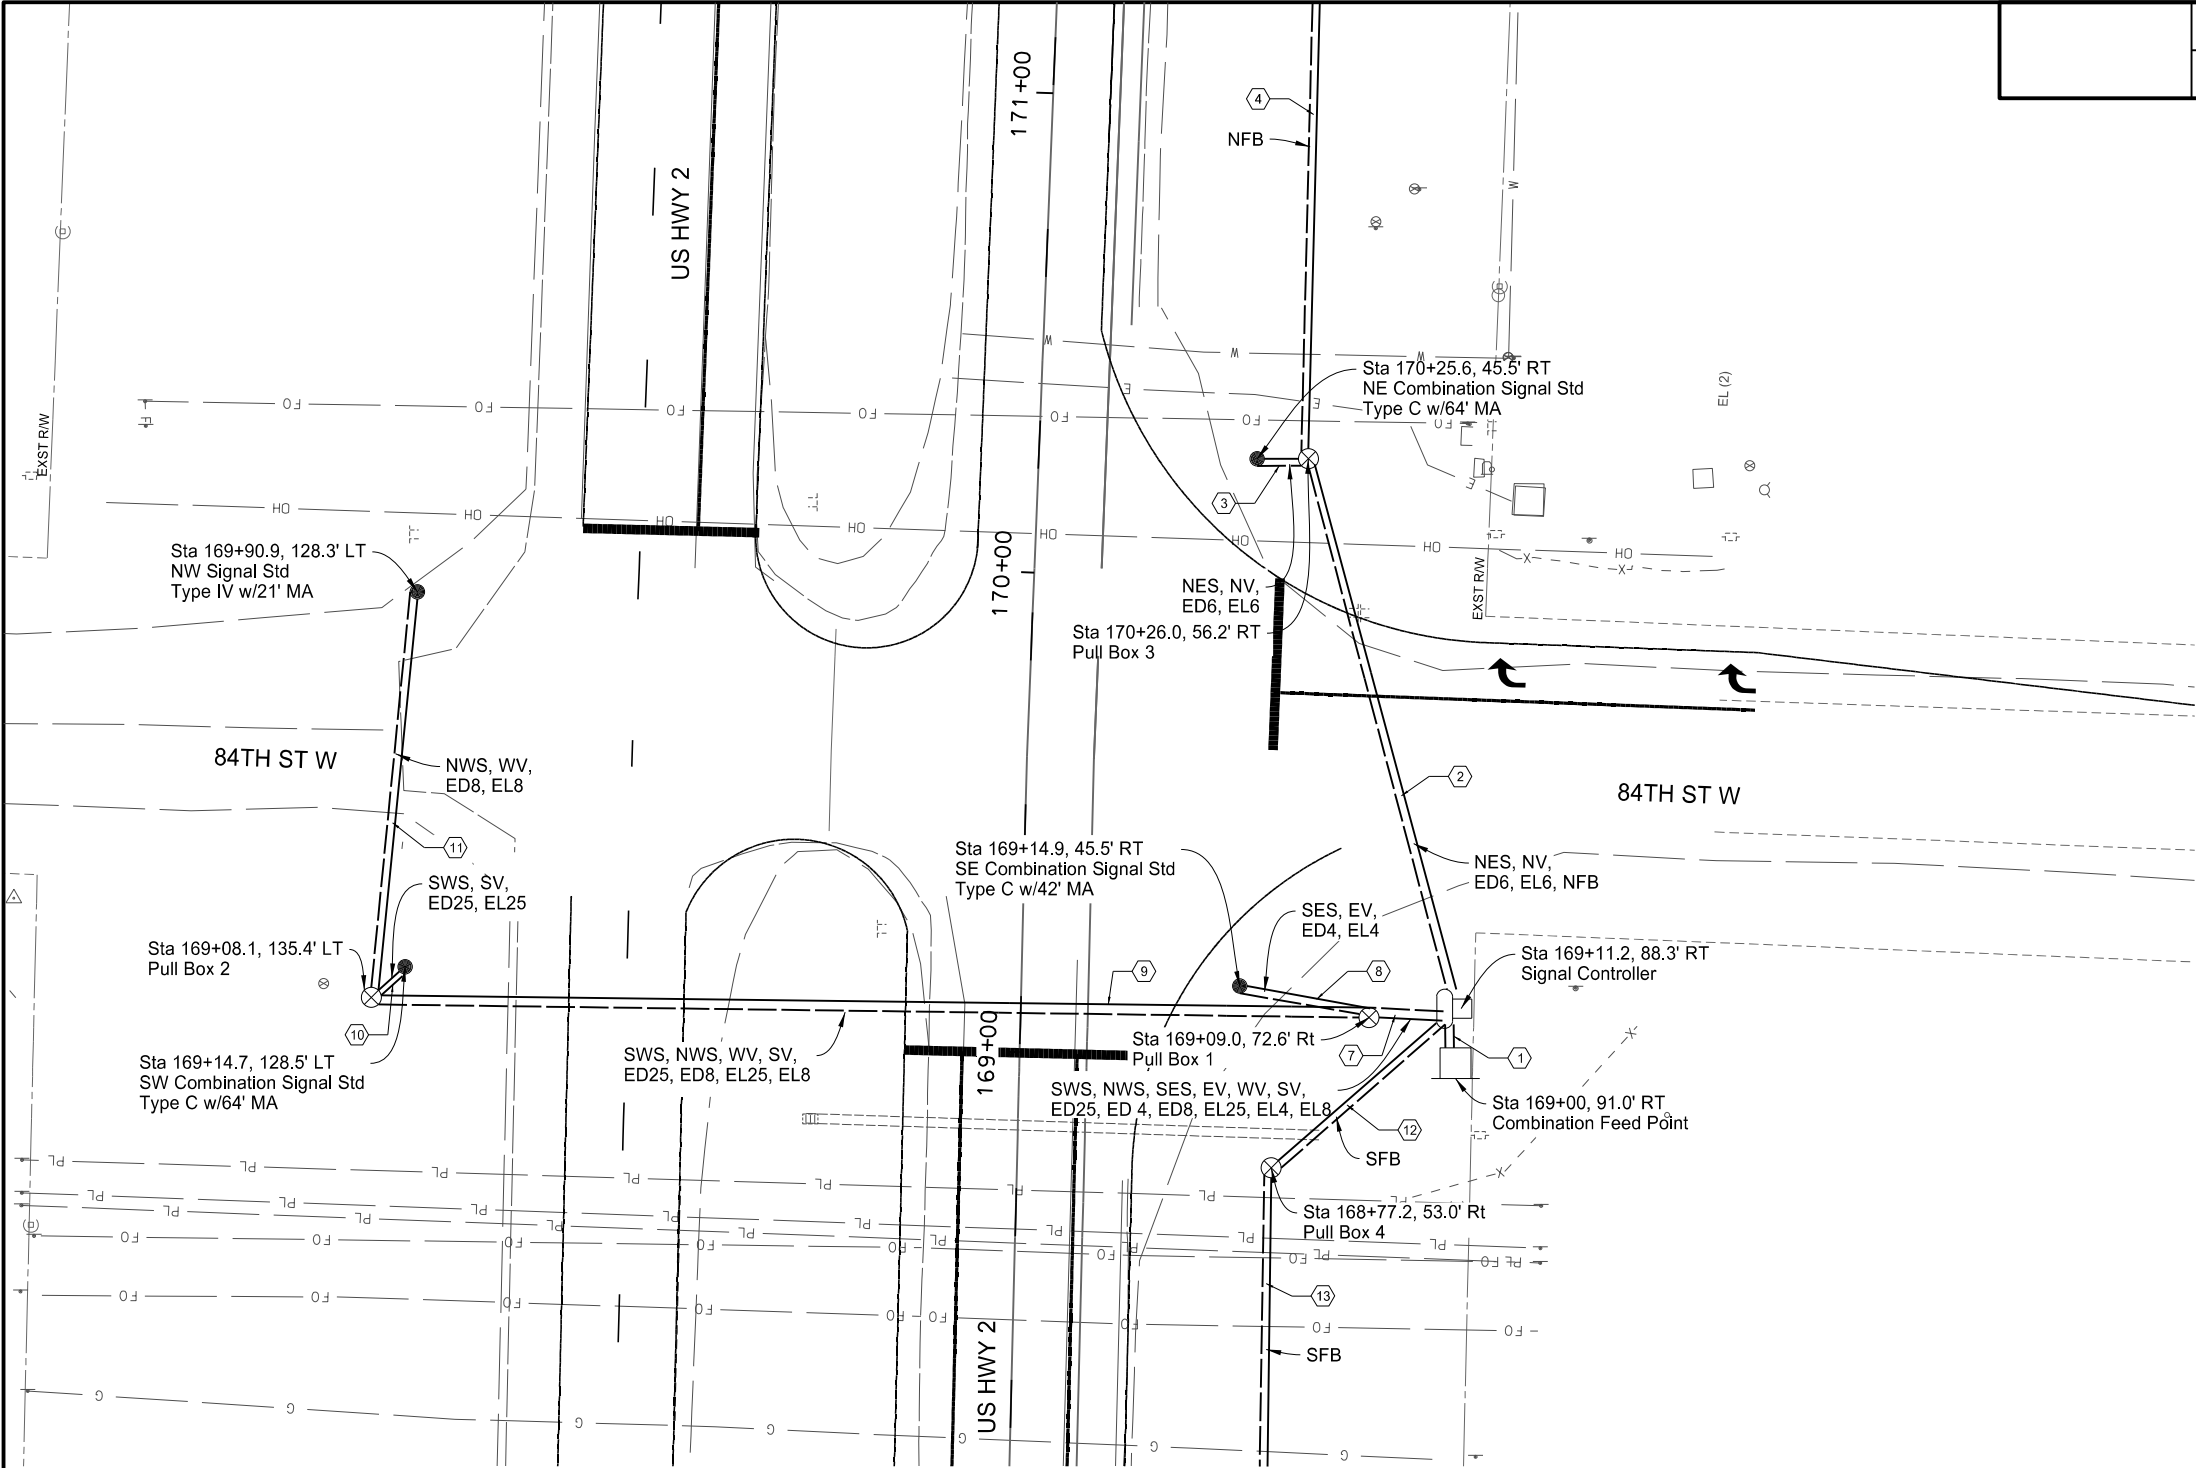

Cable Titles
NES = Northeast Signal Standard
NWS = Northwest Signal Standard
SES = Southeast Signal Standard
SWS = Southwest Signal Standard
NFB=North Flashing Beacon
SFB=South Flashing Beacon
NV = North Video Detection Unit
SV = South Video Detection Unit
EV = East Video Detection Unit
WV = West Video Detection Unit
ED25 = Ø2 + Ø5 EVP Detector
ED4 = Ø4 EVP Detector
ED6 = Ø6 EVP Detector
ED8 = Ø8 EVP Detector
EL25 = Ø2 + Ø5 EVP Light
EL4 = Ø4 EVP Light
EL6 = Ø6 EVP Light
EL8 = Ø8 EVP Light


LEGEND	
	Signal controller
	Cable & Conduit Run
	Pull Box
	Feed Point
	Signal Pole



This document was originally issued and sealed by Joshua M. Loegering, Registration Number PE- 9139, on 07/28/17 and the original document is stored at the North Dakota Department of Transportation

US Hwy 2
Conduit and Conductor Layout
Intersection of 84th St W
Site 2

	STATE	PROJECT NO.	SECTION NO.	SHEET NO.
	ND	NH-NHU-7-002(156)022	150	13

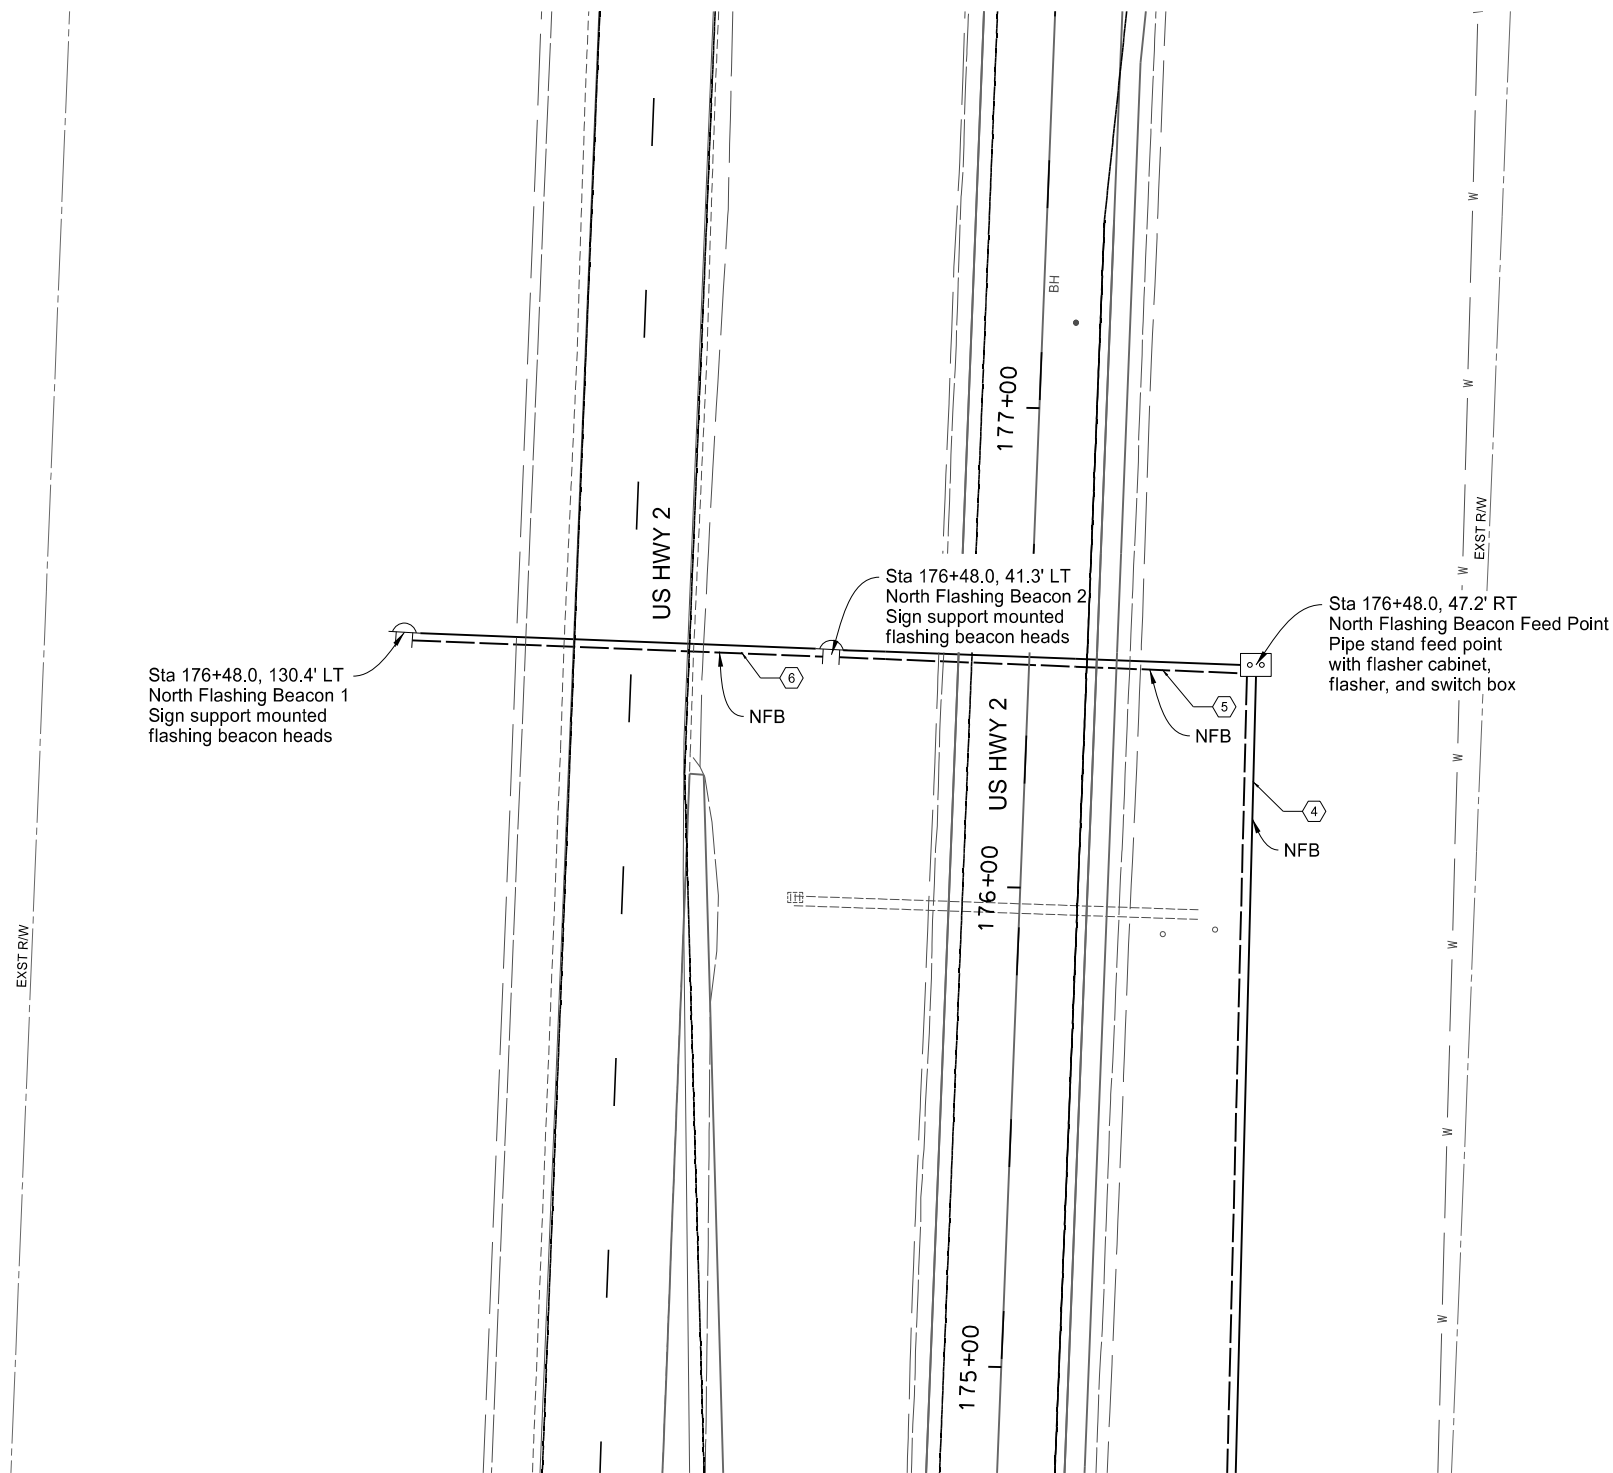


This document was originally issued and sealed by Joshua M. Loegering, Registration Number PE- 9139, on 07/28/17 and the original document is stored at the North Dakota Department of Transportation

LEGEND

-  Pipe Stand Feed Point
-  Flashing Beacon

US Hwy 2

North Flashing Beacon Layout
Intersection of 84th St W
Site 2

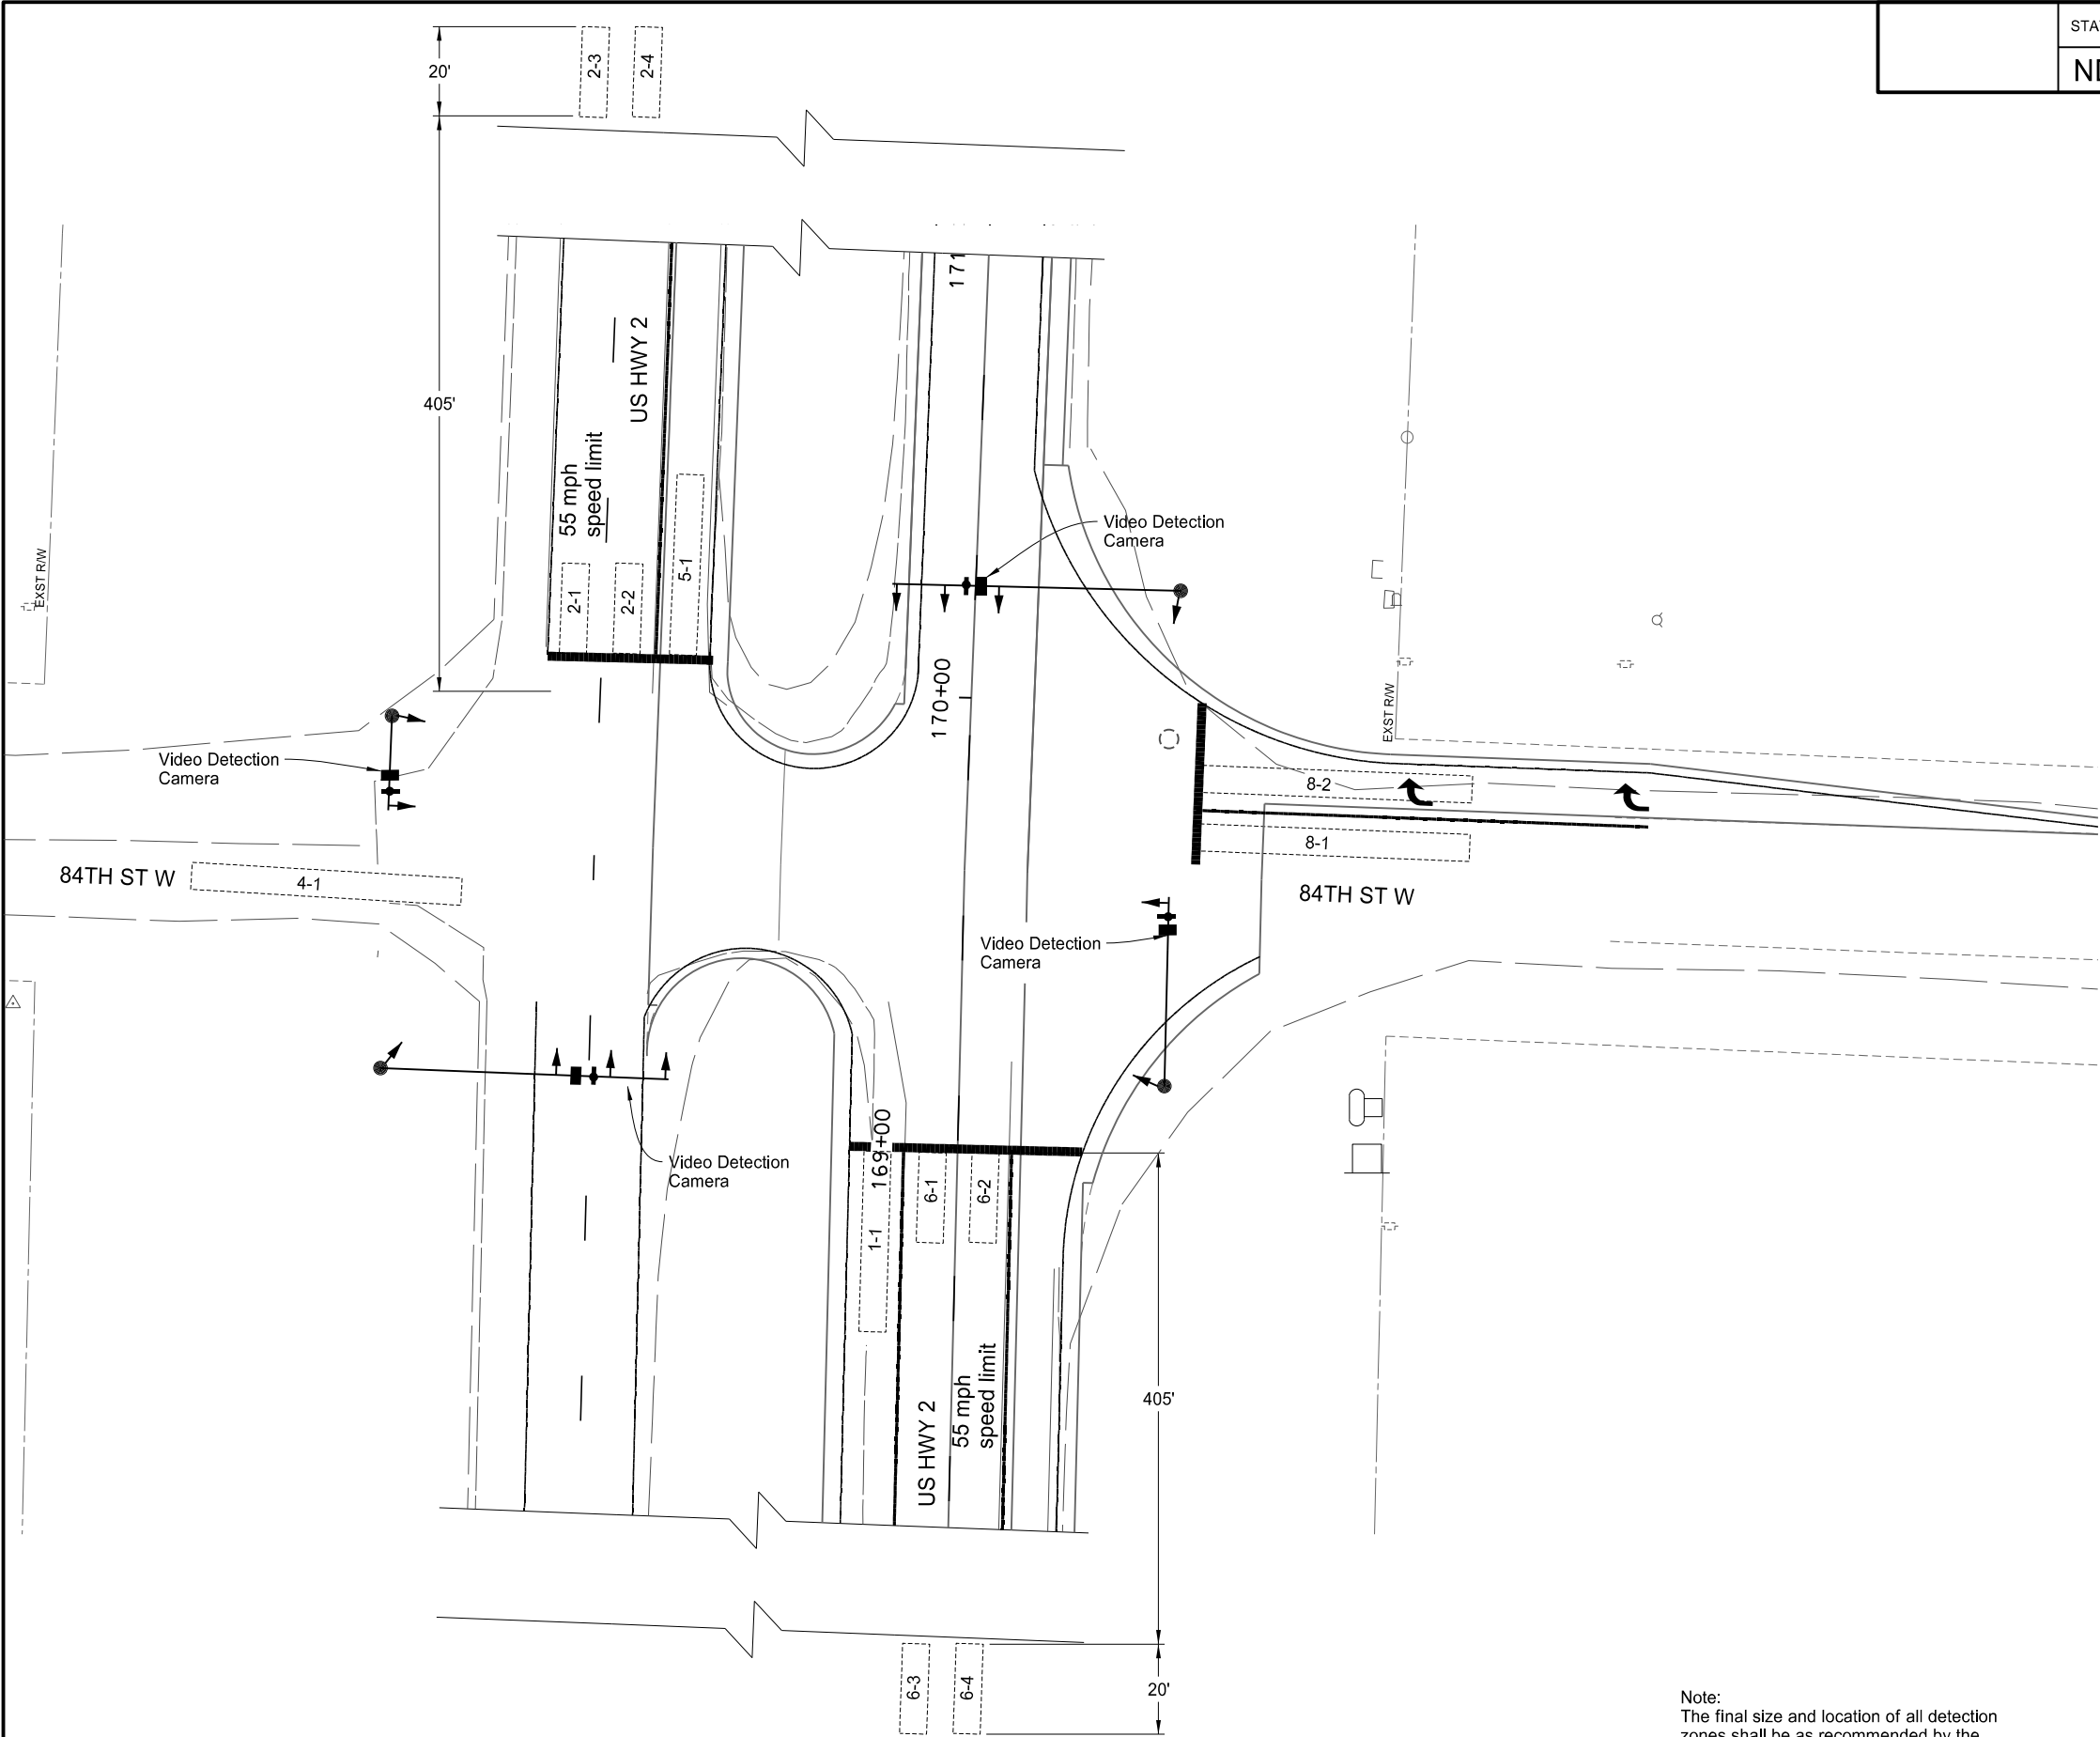

DETECTION ZONE SCHEDULE					
Phase-Number	Distance From Stop Bar (feet)	Length (feet)	Presence/Counting	Passage/Counting	Locking Memory
1-1	0	40	X		X
2-1	0	20		X	X
2-2	0	20		X	X
2-3	405	20		X	X
2-4	405	20		X	X
4-1	0	60	X		X
5-1	0	40	X		X
6-1	0	20		X	X
6-2	0	20		X	X
6-3	405	20		X	X
6-4	405	20		X	X
8-1	0	60	X		X
8-2	0	60	X		X




This document was originally issued and sealed by Joshua M. Loegering, Registration Number PE- 9139, on 07/28/17 and the original document is stored at the North Dakota Department of Transportation

US Hwy 2
Video Detection Zone Layout
Intersection of 84th St W
Site 2

Note:
The final size and location of all detection zones shall be as recommended by the video detection manufacture.

STATE	PROJECT NO.	SECTION NO.	SHEET NO.
ND	NH-NHU-7-002(156)022	150	15

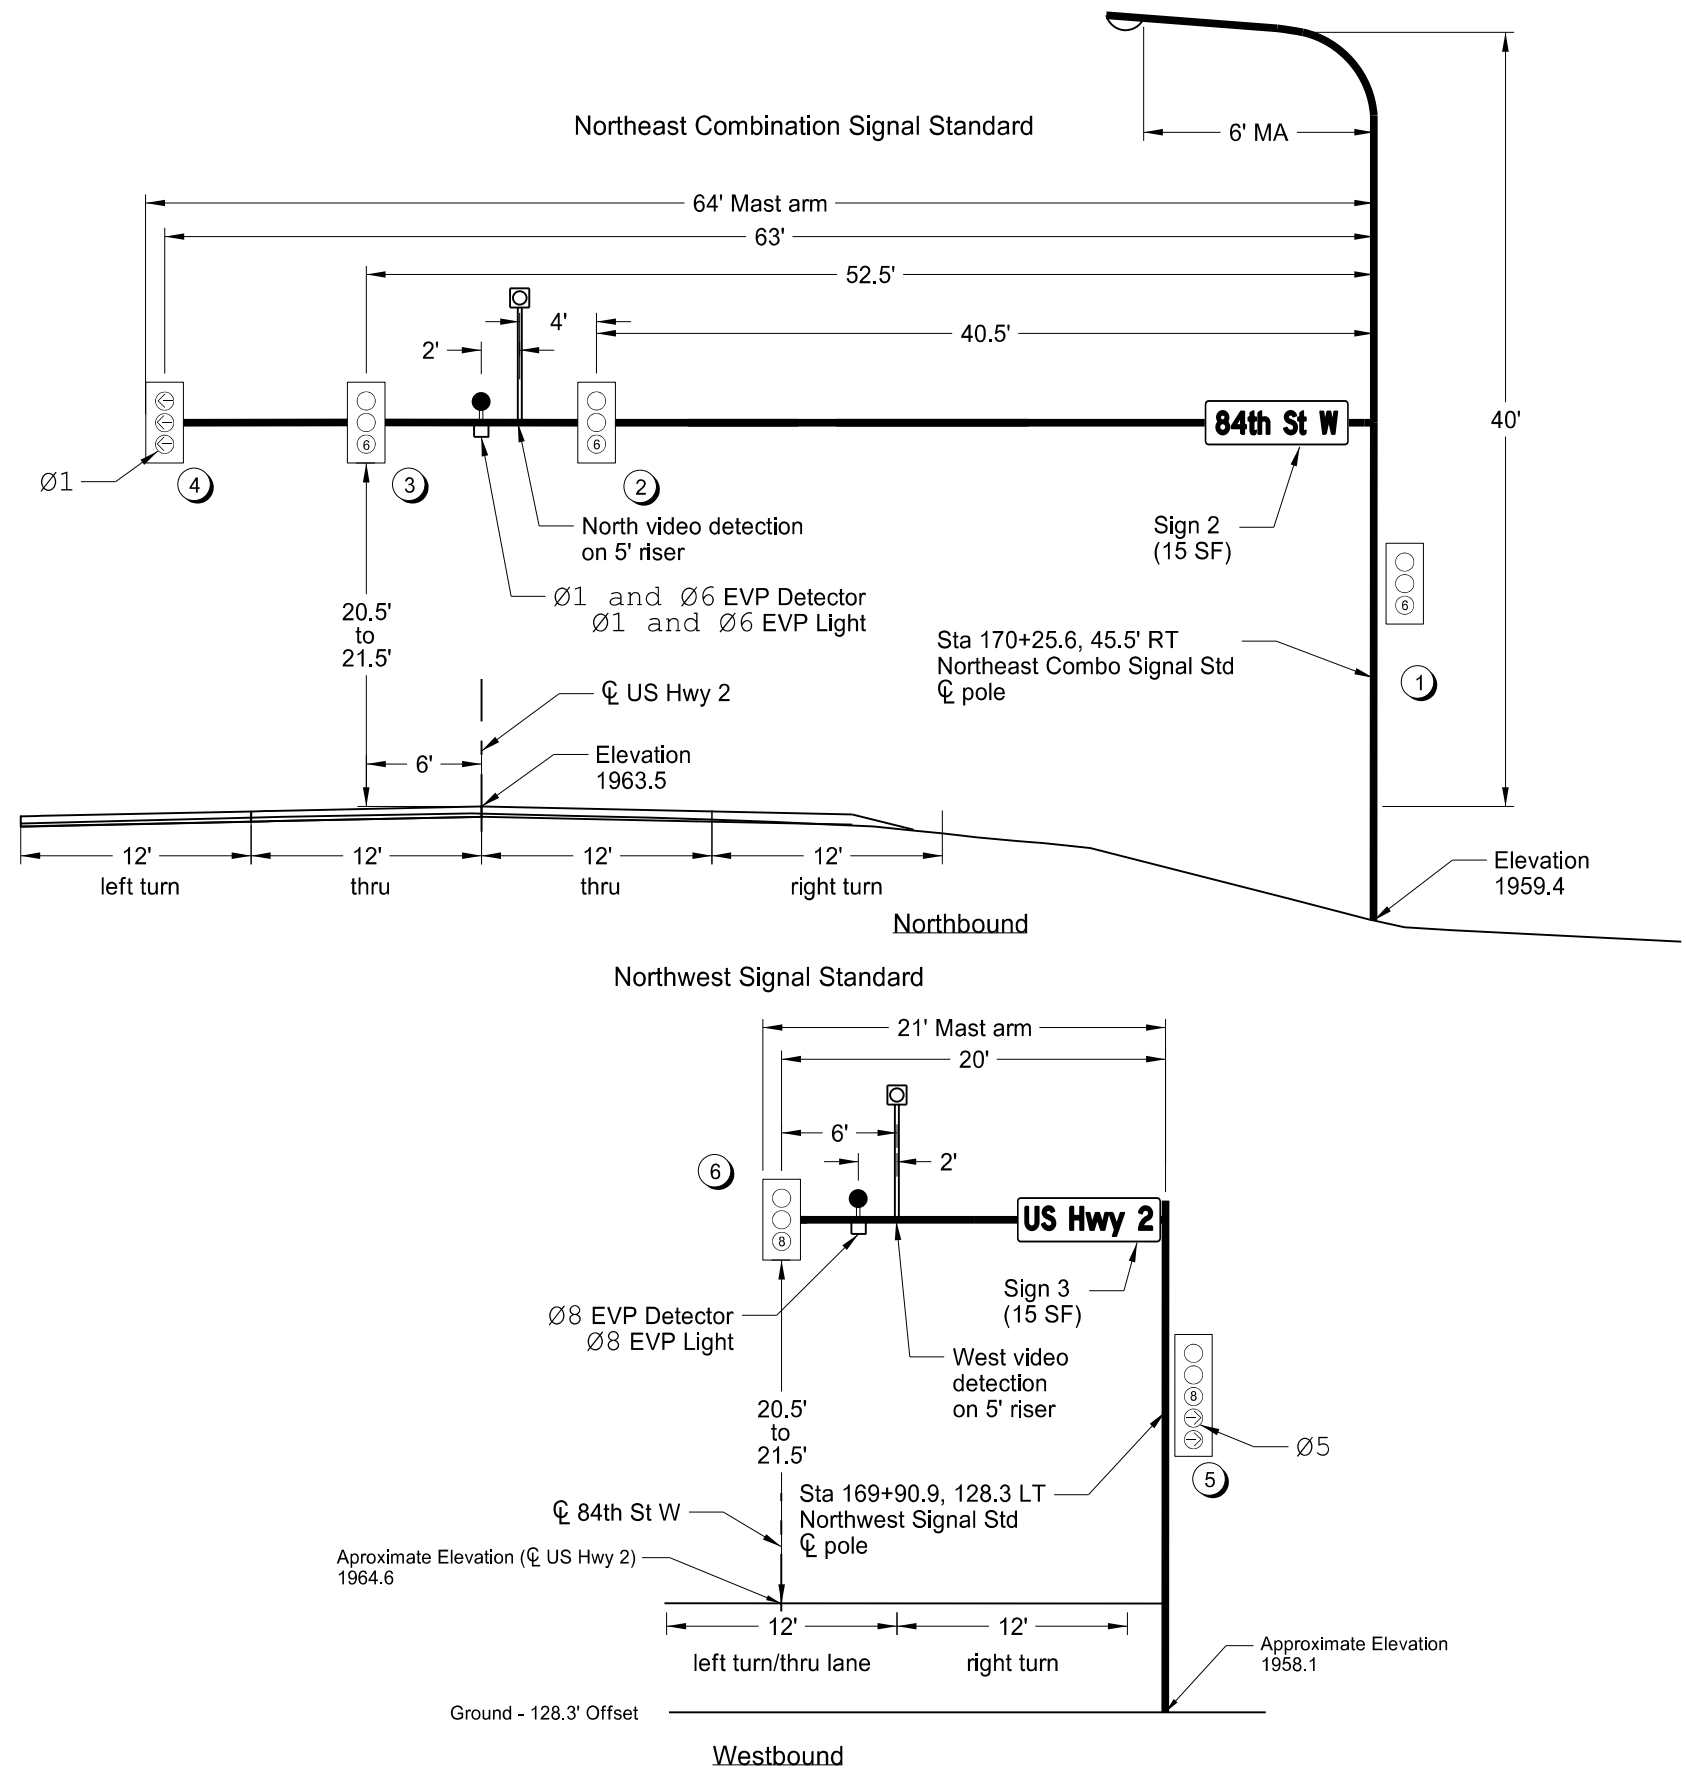

LEGEND



- Video Detection Camera
- Traffic Signal Head w/ associated phase
- Signal Head Number
- EVP Light
- EVP Detector

This document was originally issued and sealed by Joshua M. Loegering, Registration Number PE- 9139, on 07/28/17 and the original document is stored at the North Dakota Department of Transportation

US Hwy 2

Signal Standards and Head Locations
Intersection of 84th St W
Site 2

	STATE	PROJECT NO.	SECTION NO.	SHEET NO.
	ND	NH-NHU-7-002(156)022	150	16

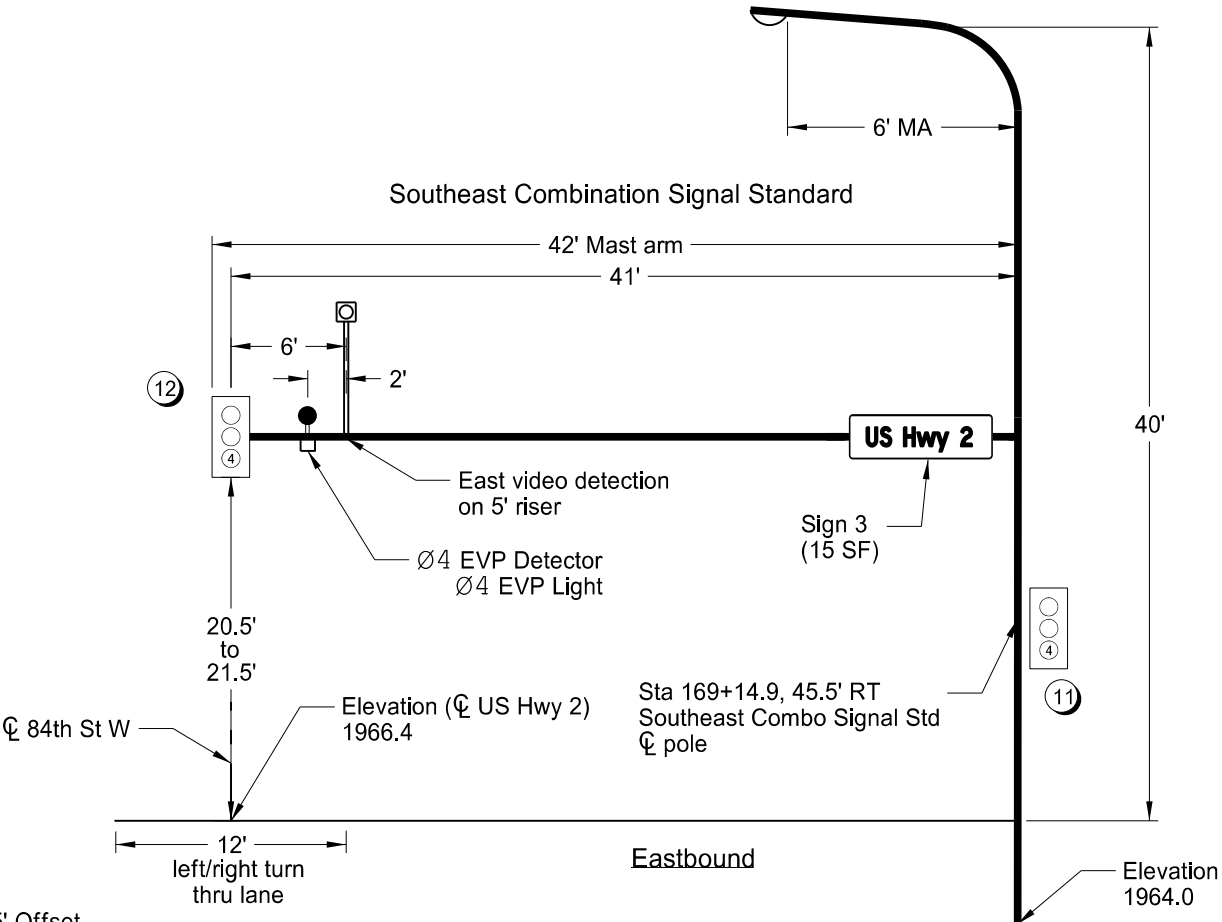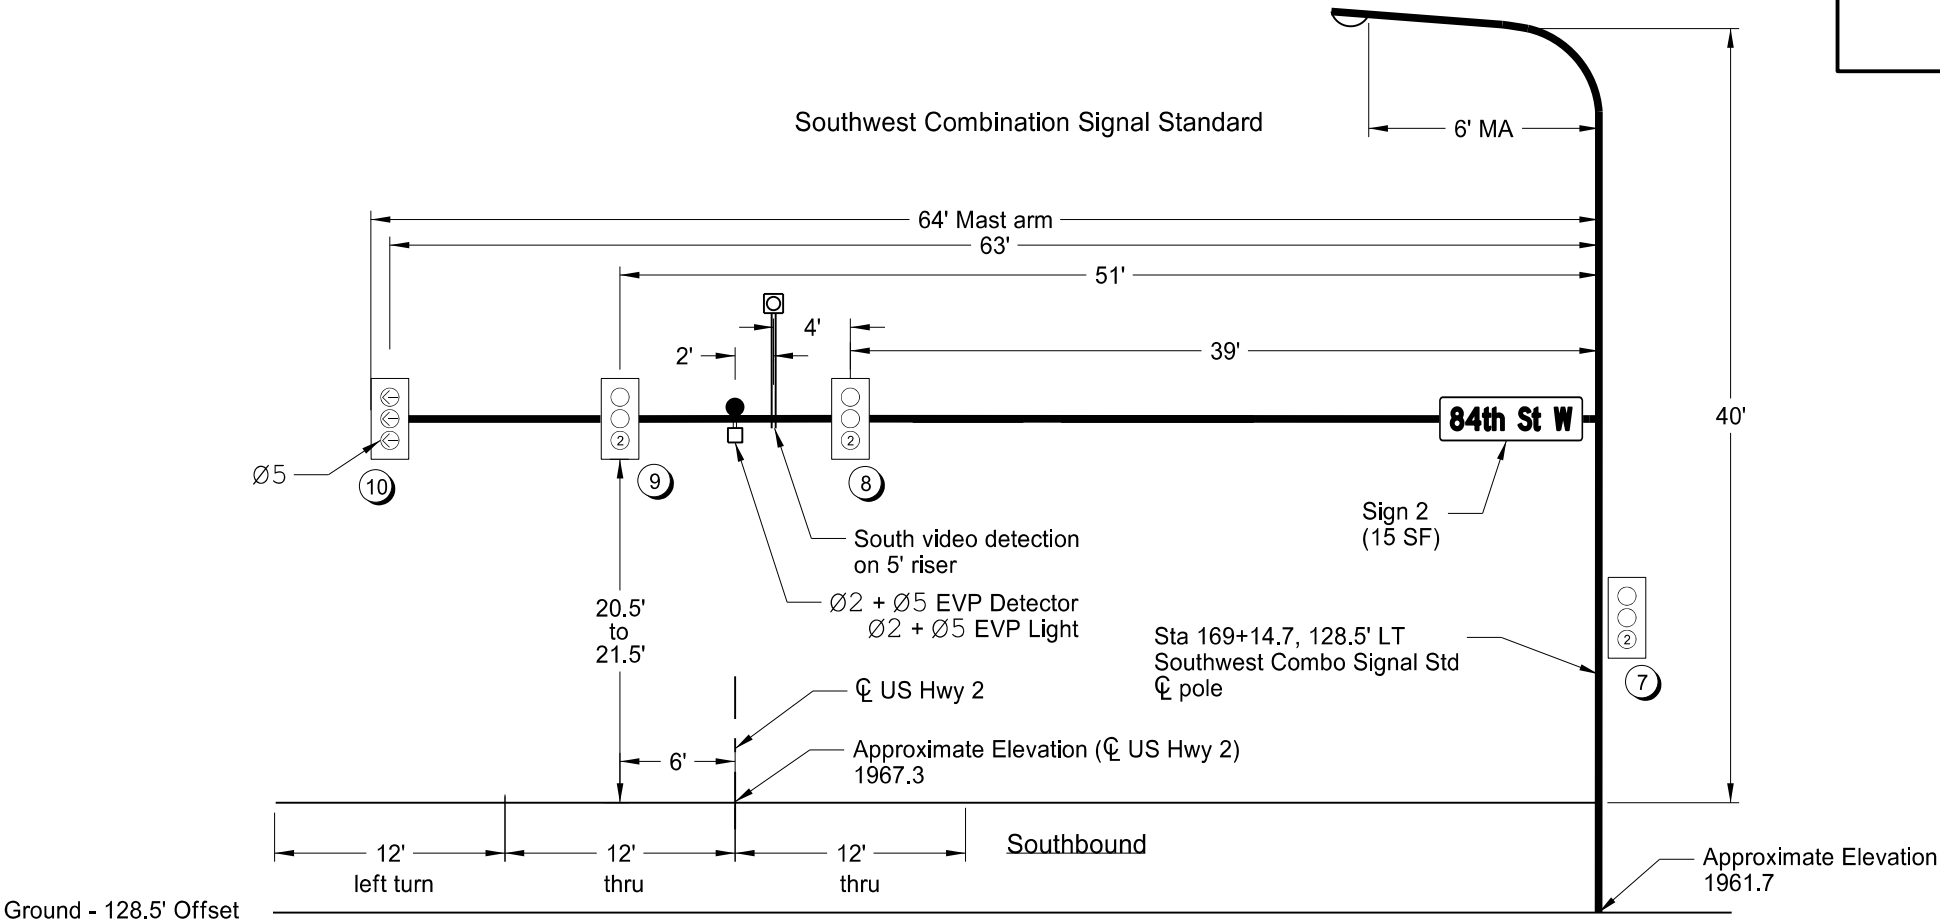

LEGEND

Video Detection Camera

Traffic Signal Head w/ associated phase

Signal Head Number

EVP Light

EVP Detector

This document was originally issued and sealed by Joshua M. Loegering, Registration Number PE- 9139, on 07/28/17 and the original document is stored at the North Dakota Department of Transportation

US Hwy 2

Signal Standards and Head Locations
Intersection of 84th St W
Site 2

Phase 1	Phase 2	Phase 3	Phase 4	Phase 5	Phase 6	Phase 7	Phase 8
NB Left	SB Thru	Future	EB Thru	SB Left	NB Thru	Future	WB Thru

BASIC INTERVALS (OR FUNCTIONS)

Minimum Green/Initial	5.0	15.0		10.0	5.0	15.0		10.0
Minimum Initial with Pedestrian Actuation*								
Passage Time	2.0	5.0		2.0	2.0	5.0		2.0
Maximum Green	30.0	60.0		30.0	30.0	60.0		30.0
Yellow Change	3.0	5.0		3.2	3.0	5.0		3.2
Red Clearance	3.3	1.0		3.5	3.3	1.0		3.8
Walk								
Pedestrian Clearance								

EB = Eastbound (84th St W)
WB = Westbound (84th St W)
NB = Northbound (US Hwy 2)
SB = Southbound (US Hwy 2)


VOLUME DENSITY TIMING FUNCTIONS - ONLY APPLICABLE DURING "FREE" (UNCOORDINATED) TIMING PLAN

Minimum Initial		15.0				15.0		
Added Initial per Actuation		1.5				1.5		

Minimum Gap		2.0				2.0		
Time to Reduce to Minimum Gap		18.0				18.0		
Time Before Reduction		30.0				30.0		

OTHER CONTROLLER FUNCTIONS

Recall	No	Minimum	No	No	No	Minimum	No	No
Flashing-Normal & Conflict Monitor	R	Y	R	R	R	Y	R	R
Start Up Phasing	R	G	R	R	R	G	R	R
Emergency Vehicle Pre-emption	x	x	x	x	x	x	x	x
Type of Detector	Presence	Refer to Detector Zone Table						
	Calling							
	Passage							
Locking Memory								
Non-Locking Memory								

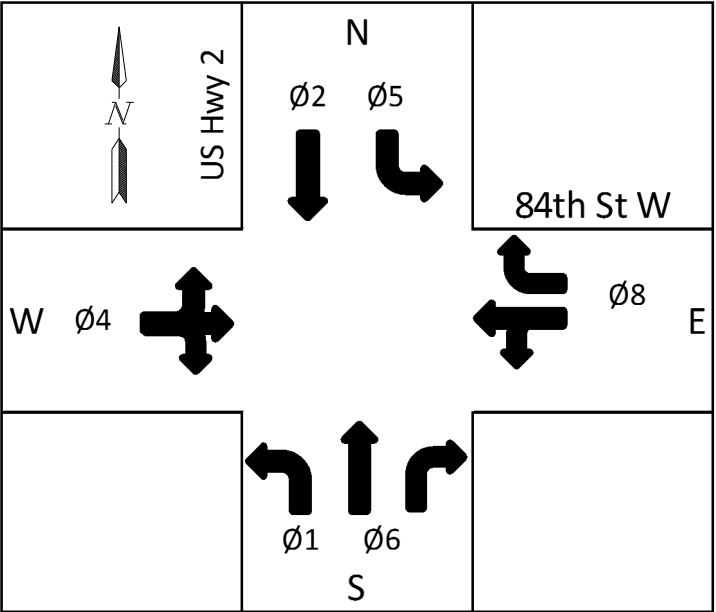

This document was originally issued and sealed by Joshua M. Loegering, Registration Number PE- 9139, on 07/28/17 and the original document is stored at the North Dakota Department of Transportation

US Hwy 2
Controller Settings
Intersection of 84th St W
Site 2

											STATE	PROJECT NO.		SECTION NO.	SHEET NO.
											ND	NH-NHU-7-002(156)022		150	19

SIGNAL CABLE & CONDUIT SCHEDULE														
RUN				CONDUIT		CABLE								
#	ITEM		STATION, OFFSET	SIZE (IN)	LF	NOTES	Origin	Destination	# of Cables	SIZE/TYPE	Total LF	TITLE		
1	Origin	Combination Feed Point	169+00.0, 91.0' RT	2	15		Combination Feed Point	Traffic Signal Controller	2	UNDERGROUND CONDUCTOR NO 6-TYPE RHW	68			
	Destination	Traffic Signal Controller	169+11.2, 88.3' RT				Combination Feed Point	Traffic Signal Controller	1	UNDERGROUND CONDUCTOR NO 6-TYPE THW	34			
2	Origin	Traffic Signal Controller	169+11.2, 88.3' RT	4	120		Traffic Signal Controller	Pull Box 3	1	12 AWG 12 CONDUCTOR CABLE	135	NES		
	Destination	Pull Box 3	170+26.0, 56.2' RT				Traffic Signal Controller	Pull Box 3	1	VIDEO DETECTION CABLE	135	NV		
							Traffic Signal Controller	Pull Box 3	1	EMERGENCY VEHICLE DETECTOR CABLE	135	ED6		
							Traffic Signal Controller	Pull Box 3	1	12 AWG 2 CONDUCTOR CABLE	135	EL6		
							Traffic Signal Controller	Pull Box 3	1	12 AWG 7 CONDUCTOR CABLE	135	NFB		
3	Origin	Pull Box 3	170+26.0, 56.2' RT	2	15		Pull Box 3	Northeast Combo Signal Std Transformer Base	1	12 AWG 12 CONDUCTOR CABLE	26	NES		
	Destination	Northeast Combo Signal Std	170+25.6, 45.5' RT				Pull Box 3	North Video Detection Unit	1	VIDEO DETECTION CABLE	97	NV		
							Pull Box 3	Northeast Emergency Preemption Detector	1	EMERGENCY VEHICLE DETECTOR CABLE	94	ED6		
							Pull Box 3	Northeast Emergency Preemption Lamp	1	12 AWG 2 CONDUCTOR CABLE	94	EL6		
4	Origin	Pull Box 3	170+26.0, 56.2' RT	2	625		Pull Box 3	North Flashing Beacon Feed Point	1	12 AWG 7 CONDUCTOR CABLE	641	NFB		
Destination	North Flashing Beacon Feed Point	176+48.0, 47.2' RT												
5	Origin	North Flashing Beacon Feed Point	176+48.0, 47.2' RT	2	90		North Flashing Beacon Feed Point	North Flashing Beacon 2	1	12 AWG 7 CONDUCTOR CABLE	115	NFB		
Destination	North Flashing Beacon 2	176+48.0, 41.3' LT												
6	Origin	North Flashing Beacon 2	176+48.0, 41.3' LT	2	90		North Flashing Beacon 2	North Flashing Beacon 1	1	12 AWG 7 CONDUCTOR CABLE	120	NFB		
Destination	North Flashing Beacon 1	176+48.0, 130.4' LT												
7	Origin	Traffic Signal Controller	169+11.2, 88.3' RT	4	20		Traffic Signal Controller	Pull Box 1	3	12 AWG 12 CONDUCTOR CABLE	105	SWS, NWS, SES		
	Destination	Pull Box 1	169+09.0, 72.6' RT				Traffic Signal Controller	Pull Box 1	3	VIDEO DETECTION CABLE	105	EV, WV, SV		
							Traffic Signal Controller	Pull Box 1	3	EMERGENCY VEHICLE DETECTOR CABLE	105	ED25, ED4, ED8		
							Traffic Signal Controller	Pull Box 1	3	12 AWG 2 CONDUCTOR CABLE	105	EL25, EL4, EL8		
8	Origin	Pull Box 1	169+09.0, 72.6' RT	2	30		Pull Box 1	Southeast Signal Std Transformer Base	1	12 AWG 12 CONDUCTOR CABLE	41	SES		
	Destination	Southeast Combo Signal Std	169+14.9, 45.5' RT				Pull Box 1	East Video Detection Unit	1	VIDEO DETECTION CABLE	102	EV		
							Pull Box 1	Southeast Emergency Preemption Detector	1	EMERGENCY VEHICLE DETECTOR CABLE	99	ED4		
							Pull Box 1	Southeast Emergency Preemption Lamp	1	12 AWG 2 CONDUCTOR CABLE	99	EL4		
9	Origin	Pull Box 1	169+09.0, 72.6' RT	4	210		Pull Box 1	Pull Box 2	2	12 AWG 12 CONDUCTOR CABLE	444	SWS, NWS		
	Destination	Pull Box 2	169+08.1, 135.4' LT				Pull Box 1	Pull Box 2	2	VIDEO DETECTION CABLE	444	WV, SV		
							Pull Box 1	Pull Box 2	2	EMERGENCY VEHICLE DETECTOR CABLE	444	ED25, ED8		
							Pull Box 1	Pull Box 2	2	12 AWG 2 CONDUCTOR CABLE	444	EL25, EL8		
10	Origin	Pull Box 2	169+08.1, 135.4' LT	2	10		Pull Box 2	Southwest Combo Signal Std Transformer Base	1	12 AWG 12 CONDUCTOR CABLE	21	SWS		
	Destination	Southwest Combo Signal Std	169+14.7, 128.5' LT				Pull Box 2	South Video Detection Unit	1	VIDEO DETECTION CABLE	102	SV		
							Pull Box 2	Southwest Emergency Preemption Detector	1	EMERGENCY VEHICLE DETECTOR CABLE	99	ED25		
							Pull Box 2	Southwest Emergency Preemption Lamp	1	12 AWG 2 CONDUCTOR CABLE	99	EL25		
11	Origin	Pull Box 2	169+08.1, 135.4' LT	4	85		Pull Box 2	Northwest Signal Std Transformer Base	1	12 AWG 12 CONDUCTOR CABLE	96	NES		
	Destination	Northwest Signal Std	169+90.9, 128.3' LT				Pull Box 2	West Video Detection Unit	1	VIDEO DETECTION CABLE	157	WV		
							Pull Box 2	Northwest Emergency Preemption Detector	1	EMERGENCY VEHICLE DETECTOR CABLE	154	ED8		
							Pull Box 2	Northwest Emergency Preemption Lamp	1	12 AWG 2 CONDUCTOR CABLE	154	EL8		
12	Origin	Traffic Signal Controller	169+11.2, 88.3' RT	2	50		Traffic Signal Controller	Pull Box 4	1	12 AWG 7 CONDUCTOR CABLE	65	SFB		
Destination	Pull Box 4	168+77.2, 53.0' RT												
13	Origin	Pull Box 4	168+77.2, 53.0' RT	2	615		Pull Box 4	South Flashing Beacon Feed Point	1	12 AWG 7 CONDUCTOR CABLE	631	SFB		
Destination	South Flashing Beacon Feed Point	162+62.0, 60.3' RT												
14	Origin	South Flashing Beacon Feed Point	162+62.0, 60.3' RT	2	15		South Flashing Beacon Feed Point	South Flashing Beacon 2	1	12 AWG 7 CONDUCTOR CABLE	40	SFB		
Destination	South Flashing Beacon 2	162+62.0, 47.5' RT												
15	Origin	South Flashing Beacon 2	162+62.0, 47.5' RT	2	90		South Flashing Beacon 2	South Flashing Beacon 1	1	12 AWG 7 CONDUCTOR CABLE	120	SFB		
Destination	South Flashing Beacon 1	162+62.0, 41.8' LT												

INTERNAL MAST ARM/STANDARD SIGNAL HEAD CABLE				
Origin	Destination	# of Cables	SIZE/TYPE	Total LF
Northeast Combo Signal Std Transformer Base	Vehicle Head 1	1	12 AWG 5 CONDUCTOR CABLE	20
	Vehicle Head 2	1	12 AWG 5 CONDUCTOR CABLE	69
	Vehicle Head 3	1	12 AWG 5 CONDUCTOR CABLE	81
	Vehicle Head 4	1	12 AWG 5 CONDUCTOR CABLE	91
Northwest Signal Std Transformer Base	Vehicle Head 5	1	12 AWG 7 CONDUCTOR CABLE	20
	Vehicle Head 6	1	12 AWG 5 CONDUCTOR CABLE	48
Southwest Combo Signal Std Transformer Base	Vehicle Head 7	1	12 AWG 5 CONDUCTOR CABLE	20
	Vehicle Head 8	1	12 AWG 5 CONDUCTOR CABLE	67
	Vehicle Head 9	1	12 AWG 5 CONDUCTOR CABLE	79
	Vehicle Head 10	1	12 AWG 5 CONDUCTOR CABLE	91
Southeast Signal Std Transformer Base	Vehicle Head 11	1	12 AWG 5 CONDUCTOR CABLE	20
	Vehicle Head 12	1	12 AWG 5 CONDUCTOR CABLE	69


Cable Titles
NES = Northeast Signal Standard
NWS = Northwest Signal Standard
SES = Southeast Signal Standard
SWS = Southwest Signal Standard
NFB=North Flashing Beacon
SFB=South Flashing Beacon
NV = North Video Detection Unit
SV = South Video Detection Unit
EV = East Video Detection Unit
WV = West Video Detection Unit
ED25 = Ø2 + Ø5 EVP Detector
ED4 = Ø4 EVP Detector
ED6 = Ø6 EVP Detector
ED8 = Ø8 EVP Detector
EL25 = Ø2 + Ø5 EVP Light
EL4 = Ø4 EVP Light
EL6 = Ø6 EVP Light
EL8 = Ø8 EVP Light

This document was originally issued and sealed by Joshua M. Loegering, Registration Number PE- 9139, on 07/28/17 and the original document is stored at the North Dakota Department of Transportation

US Hwy 2

Cable and Conduit Schedule
Intersection of 84th St W
Site 2

STATE	PROJECT NO.	SECTION NO.	SHEET NO.
ND	NH-NHU-7-002(156)022	150	20

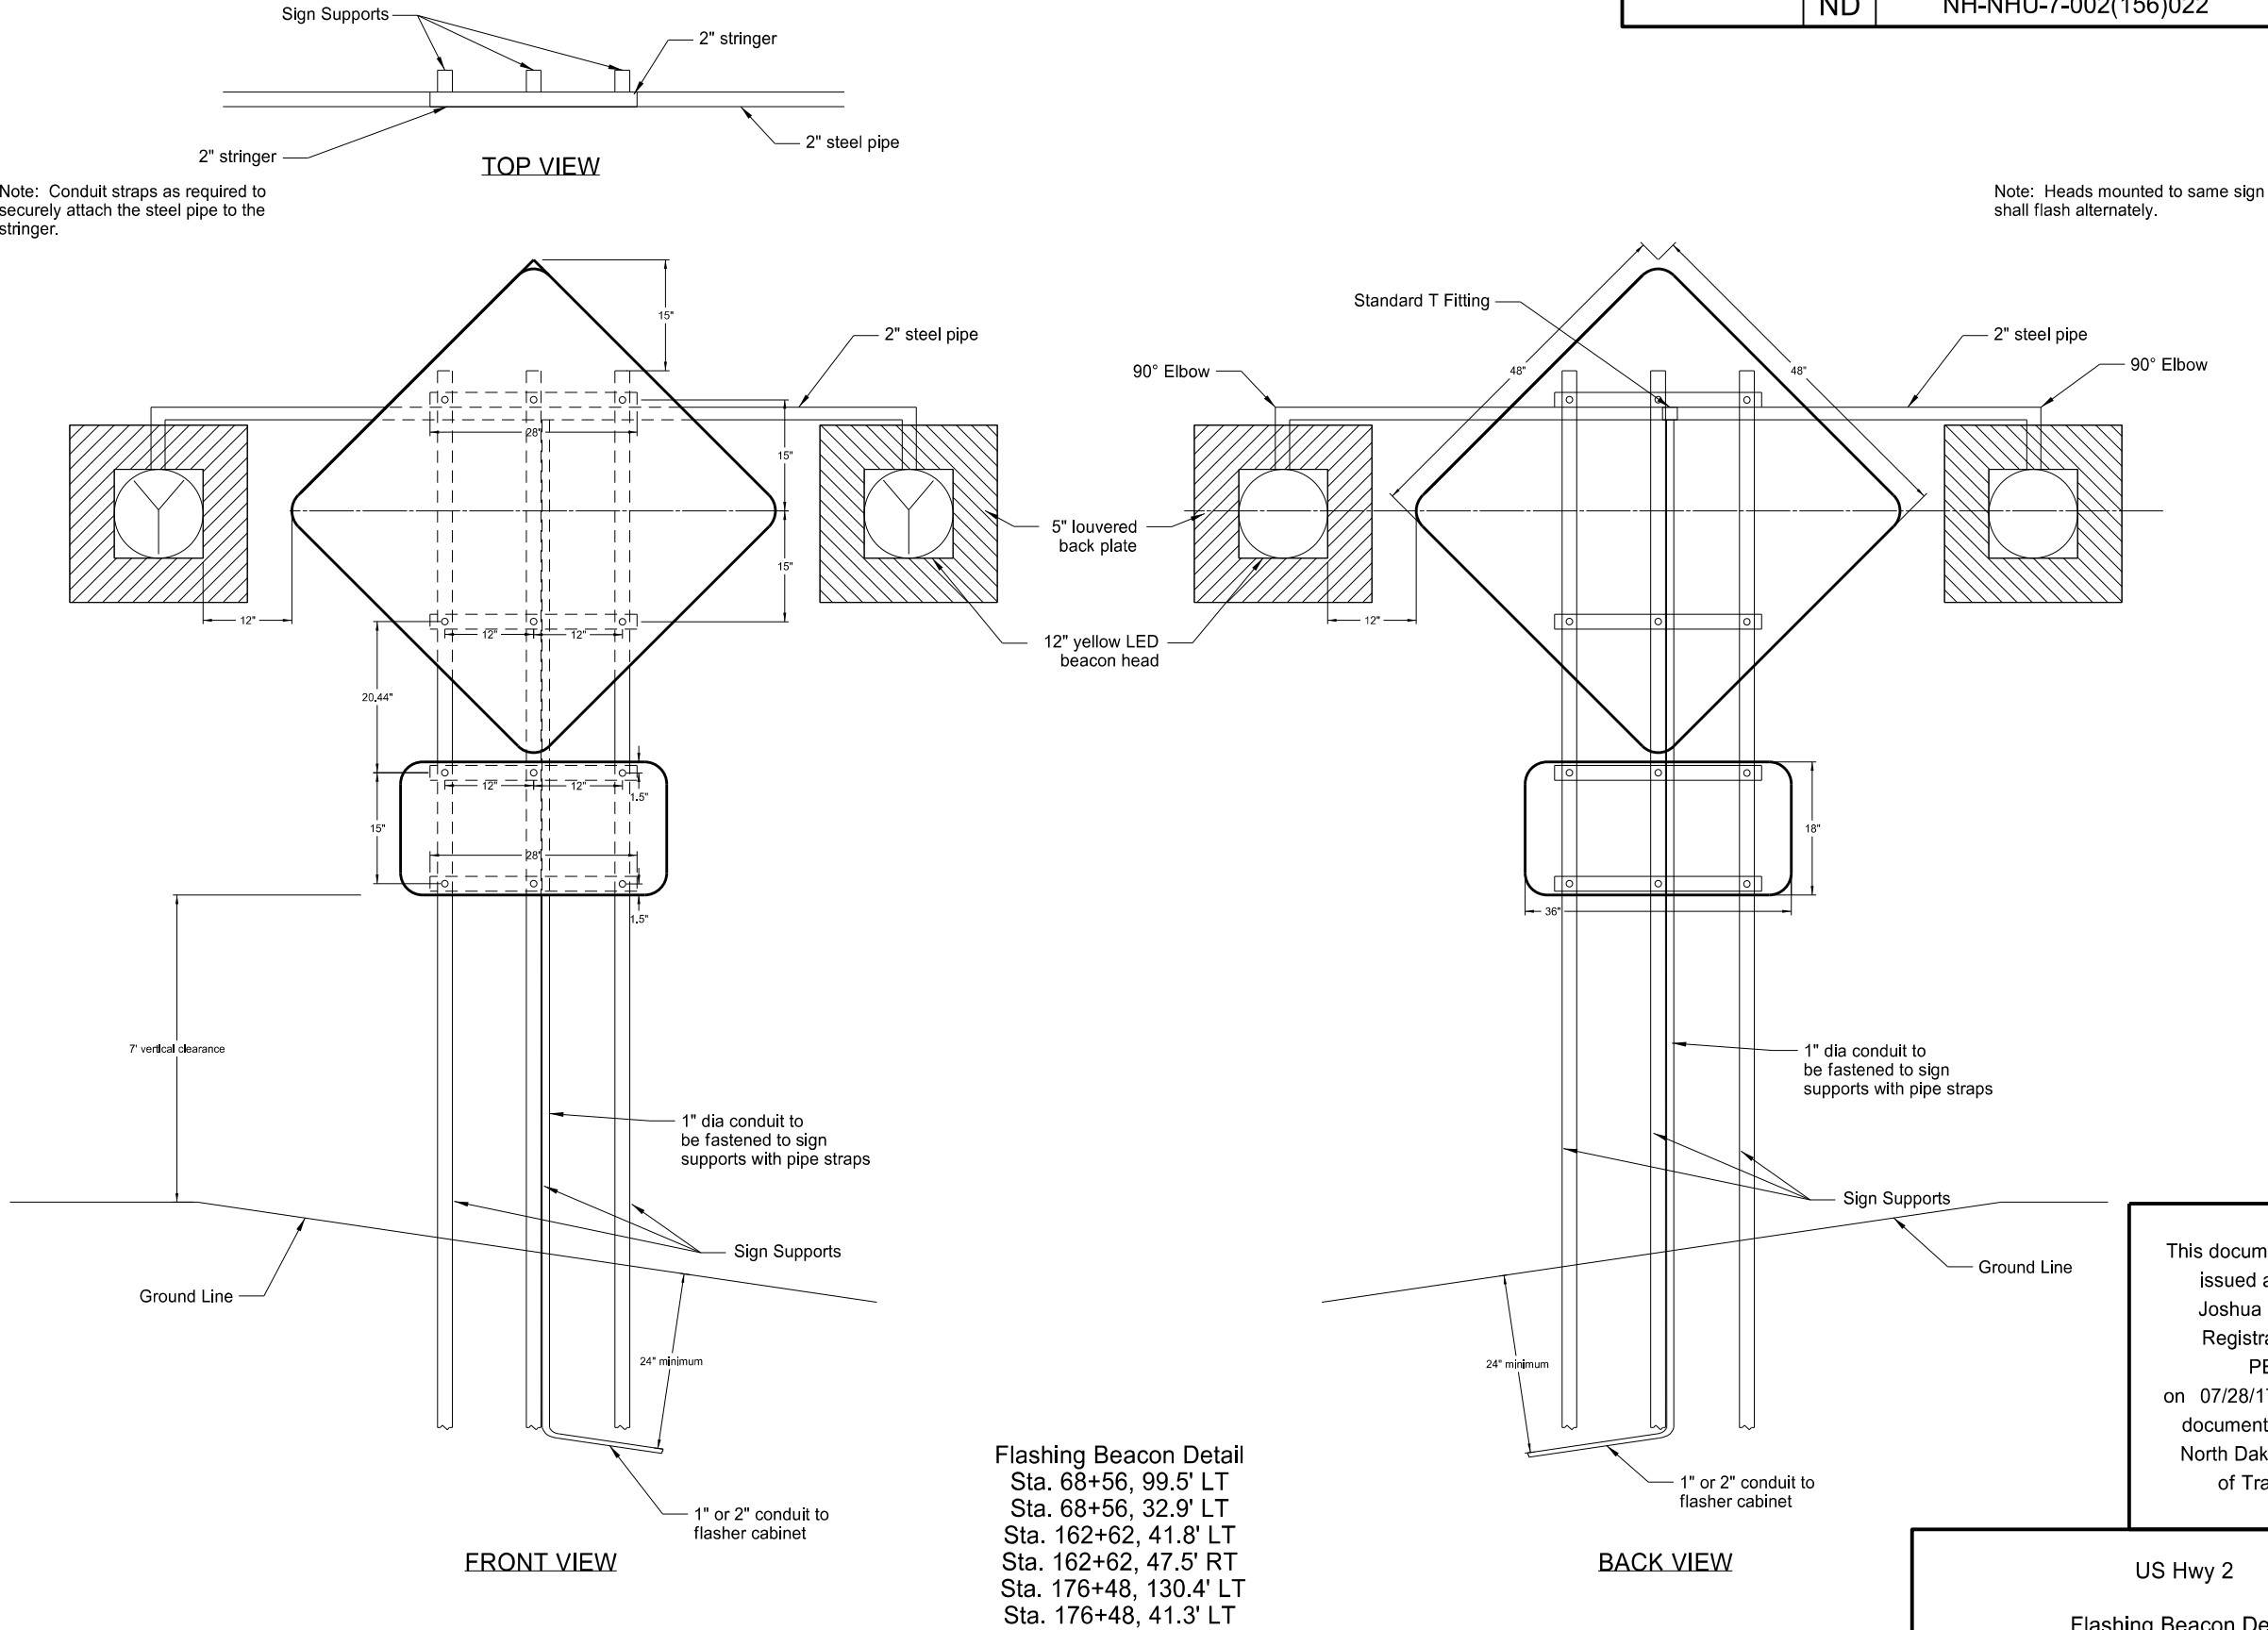


This document was originally issued and sealed by Joshua M. Loegering, Registration Number PE- 9139, on 07/28/17 and the original document is stored at the North Dakota Department of Transportation


US Hwy 2

Flashing Beacon Detail
Site 1 & Site 2

	STATE	PROJECT NO.	SECTION NO.	SHEET NO.
	ND	NH-NHU-7-002(156)022	150	21

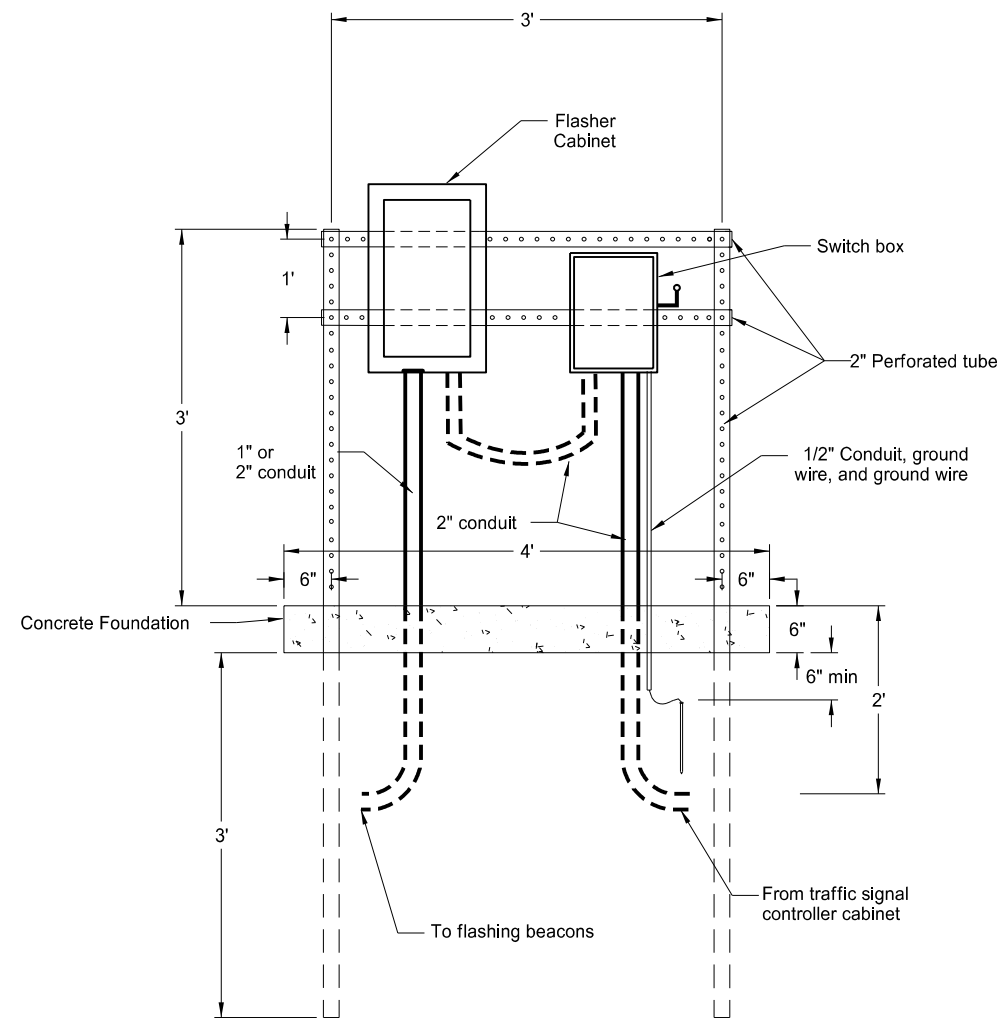

FRONT VIEW

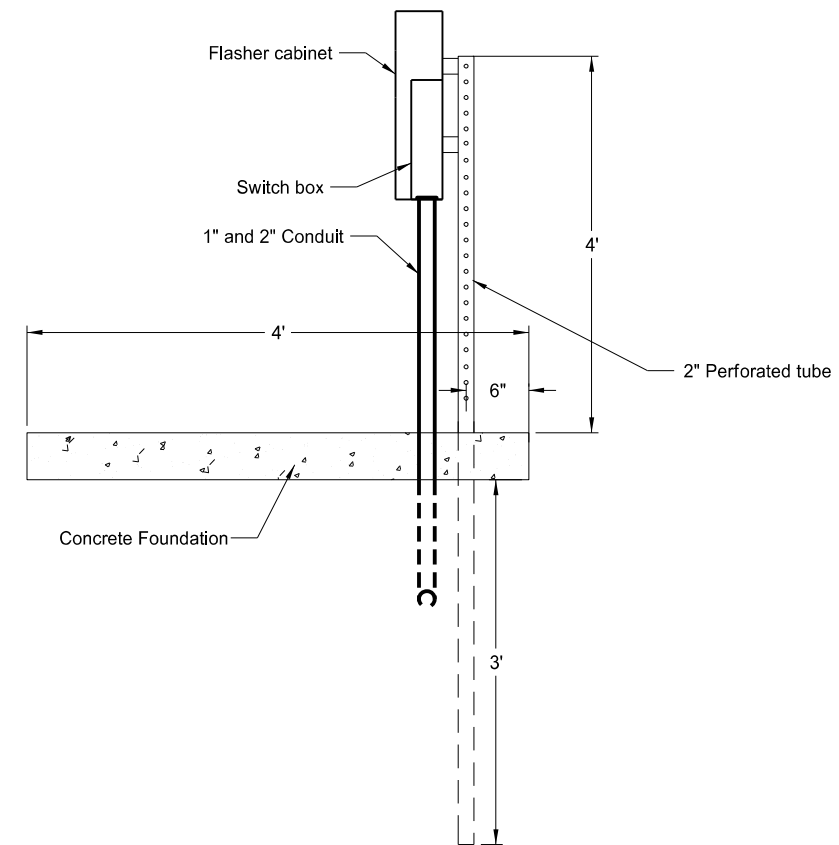

SIDE VIEW

Pipe Stand Feed Point Detail
Sta. 68+56, 38.0' RT
Sta. 162+62, 60.3' RT
Sta. 176+48, 47.2' RT

This document was originally
issued and sealed by
Joshua M. Loegering,
Registration Number
PE- 9139,
on 07/28/17 and the original
document is stored at the
North Dakota Department
of Transportation

US Hwy 2
Flashing Beacon Pipe Stand Feed Point Detail
Site 1 & Site 2

SIGNAL STANDARD FOUNDATION SELECTION TABLE		
Description	Footing Depth "D" 24" & 30" Diameter	Footing Depth "D" 36" & 42" Diameter
<u>Signal Standard</u> Type IV 20' - 25' Signal Mast Arm	12', 12'	11', 11'
<u>Combination 40' Mounting Height</u> 40' - 45' Signal Mast Arm 51' - 55' Signal Mast Arm 56' - 60' Signal Mast Arm 61' - 65' Signal Mast Arm	N/A, N/A N/A, N/A N/A, N/A N/A, N/A	15', 15' 17', 17' 18', 18' 19', 19'

NOTES FOR SIGNAL STANDARD FOUNDATIONS:

1. For Signal Standards, use at minimum the largest of the following scenarios:

- Anchor bolt cage circle diameter plus 12"

- Base plus 6"

- 24"

It is the Contractor's responsibility to determine the foundation diameter and include the corresponding costs for the actual diameter in the corresponding unit price bid "CONCRETE FOUNDATION-TRAFFIC SIGNALS".
2. Provide Class AAE-3 Portland Cement Concrete mixed and proportioned as specified in Section 802.
3. Provide Grade 60 reinforcing steel.
4. The Contractor may use temporary casing to maintain the opening prior to placement of concrete. The casing will be removed prior to curing of the concrete. If casing is used, it will be of sufficient strength to withstand handling and installation procedures. The Contractor will submit a casing material proposal to the Engineer for review two weeks prior to ordering casing material. Include all costs associated with the temporary casing in the corresponding unit price bid "CONCRETE FOUNDATION-TRAFFIC SIGNALS". Permanent casing of the foundation will not be used.
5. Include all costs associated with the construction of the foundation in the corresponding unit price bid "CONCRETE FOUNDATION-TRAFFIC SIGNALS". This includes but is not limited to excavation, concrete, reinforcing steel, anchor bolts and ground rod.
6. See Standard Drawing D-770-1 for additional foundation information.
7. Signal Standards will have a minimum of 6 anchor bolts.

This document was originally issued and sealed by
Mathew L. Isley,
Registration Number
PE-10095,
on 07/28/17 and the original document is stored at the
North Dakota Department
of Transportation

US Hwy 2
Signal Concrete Foundations

	STATE	PROJECT NO.	SECTION NO.	SHEET NO.
	ND	NH-NHU-7-002(156)022	150	23

SPEC	CODE	ITEM DESCRIPTION	UNIT	TRAFFIC SIGNAL SYSTEM - SITE 1	TRAFFIC SIGNAL SYSTEM - SITE 2	TOTAL
772	0020	CONCRETE FOUNDATION-TRAFFIC SIGNALS	EA	4	4	8
772	0100	PULLBOX	EA	3	4	7
772	0240	2IN DIAMETER RIGID CONDUIT	LF	700	1,645	2,345
772	0290	4IN DIAMETER RIGID CONDUIT	LF	460	435	895
772	0300	UNDERGROUND CONDUCTOR NO6-TYPE RHW	LF	68	68	136
772	0310	UNDERGROUND CONDUCTOR NO6-TYPE THW	LF	34	34	68
772	0375	EMERGENCY VEHICLE DETECTOR CABLE	LF	1,074	1,130	2,204
772	0400	NO12 AWG 2 CONDUCTOR CABLE	LF	1,074	1,130	2,204
772	0403	NO12 AWG 5 CONDUCTOR CABLE	LF	468	574	1,042
772	0405	NO12 AWG 7 CONDUCTOR CABLE	LF	1,772	1,887	3,659
772	0410	NO12 AWG 12 CONDUCTOR CABLE	LF	801	868	1,669
772	0520	FEED POINT-FLASHING BEACON	EA	1	2	3
772	0621	TYPE IV SIGNAL STD 21FT MA	EA	-	1	1
772	1122	COMBO 42FT MA SIG & LT STD-TYPE C	EA	-	1	1
772	1252	COMBO 55FT MA SIG & LT STD-TYPE C	EA	1	-	1
772	1282	COMBO 58FT MA SIG & LT STD-TYPE C	EA	1	-	1
772	1297	COMBO 62FT MA SIG & LT STD-TYPE C	EA	1	-	1
772	1299	COMBO 64FT MA SIG & LT STD-TYPE C	EA	-	2	1
772	1399	COMBO 65FT MA SIG & LT STD-TYPE C	EA	1	-	1
772	1810	1-WAY 3 SEC HEAD W/12IN LENS-POST MTD	EA	1	3	4
772	1812	1-WAY 3 SEC HEAD W/12IN LENS-MA MTD	EA	7	8	15
772	1822	1-WAY 4 SEC HEAD W/12IN LENS-MA MTD	EA	4	-	4
772	1830	1-WAY 5 SEC HEAD W/12IN LENS-POST MTD	EA	3	1	3
772	1900	12IN SIGNAL HEAD	EA	4	8	12
772	2110	FLASHING BEACON-POST MOUNTED	EA	2	4	6
772	2260	VIDEO DETECTION CABLE	LF	1,086	1,142	2,228
772	2265	VIDEO DETECTION SYSTEM ¹	EA	1	1	2
772	2350	CONTROLLER TYPE 1 ²	EA	1	1	2
772	2556	BATTERY BACKUP SYSTEM	EA	1	1	2
772	2610	EMERGENCY VEHICLE PRE-EMPTION UNIT ³	EA	4	4	8

¹Includes resetting cameras, video monitor, access point and all other equipment required for a fully operational video detection system.

²Includes cabinet, working slab, conflict monitor, load switches, flashers, bus interface units and all other equipment required as reset or new for a fully operational traffic signal and flashing beacon controller.

³Includes resetting detectors, lights and all other equipment required for a fully operation preemption system.

772	9811	TRAFFIC SIGNAL SYSTEM - SITE 1	EA	1
772	9812	TRAFFIC SIGNAL SYSTEM - SITE 2	EA	1

Items shown above are for informational purposes, contractor shall provide all labor and equipment necessary for the signal system to be fully operational as shown in the plans.

Items shall be included in the corresponding price bid
"TRAFFIC SIGNAL SYSTEM - SITE _"

SPEC	CODE	BID ITEM	QTY	UNIT
772	9811	TRAFFIC SIGNAL SYSTEM - SITE 1		
Intersection of US Hwy 2 & 58th St W			1	EA
772	9812	TRAFFIC SIGNAL SYSTEM - SITE 2		
Intersection of US Hwy 2 & 84th St W			1	EA

This document was originally issued and sealed by Joshua M. Loegering, Registration Number PE- 9139, on 07/28/17 and the original document is stored at the North Dakota Department of Transportation

US Hwy 2
Traffic Signal Estimate of Quantities
Site 1 & Site 2

RUN	ITEM	STATION OFFSET	CONDUIT RUN		CABLE RUN		CABLE #
			TOTAL LF	SIZE (IN)	TOTAL LF	SIZE / TYPE	
1	NE Signal to Pull Box 9	236+56.8, 49.0' RT	9	Existing	9	12 AWG 5 Conductor Cable	1
2	Pull Box 9 to Pull Box 8	236+49.5, 54.5' RT	184	Existing	184	12 AWG 5 Conductor Cable	1
3	Pull Box 8 to Wood Pole 1	236+44.9, 129.1' LT	8	2"	8	12 AWG 5 Conductor Cable	1
4	Wood Pole 1 to Wood Pole 2	236+52.3, 135.7' LT			88	12 AWG 5 Conductor Cable	1
		236+57.4, 49.2' LT					

5 No. 12 AWG	
HEAD	CABLE
30, 31, 32	1

Bag Heads	
Phase	Head Number
1	11, 13
2	2
3	8
5	1, 23
6	14, 15, 17
7	20

SPEC CODE BID ITEM QTY UNIT

772 2810 TEMPORARY TRAFFIC SIGNALS
Intersection of US Hwy 2 & Co Hwy 6
Modification of US Hwy 2 & 58th St W (See plan note 772-P16) 1 EA

DETECTION ZONE SCHEDULE						
Phase-Number	Distance From Stop Bar (feet)	Length (feet)	Presence/Counting	Passage/Counting	Counting	Non-Locking Memory
1-1	0	60	X			X
2-1	0	10		X		X
2-2	0	10		X		X
2-3	0	20			X	
2-4	0	10			X	
2-5	0	10			X	
3-1	0	60	X			X
3-2	0	60				
4-1	0	60		X		X
4-2	0	60		X		X
4-3	0	20			X	
4-4	0	20	X			X
4-5	0	20	X			X
5-1	0	40	X			X
6-1	0	20		X		X
6-2	0	20		X		X
6-3	0	20			X	
6-4	0	20			X	
6-5	0	20			X	
6-6	0	20		X		X
6-7	0	20	X			X
7-1	0	60	X			X
7-2	0	60	X			X
8-1	0	60		X		X
8-2	0	20		X		X
8-3	0	20			X	
8-4	0	20	X			X
8-5	0	20	X			X

Phase	Non-Conflicting Phase Allowed to Time Concurrently
1	N/A
2	N/A
3	7 or 8
4	7 or 8
5	N/A
6	N/A
7	3 or 4
8	3 or 4

Note: Program Phases 2 and 6 as split phases

ITEM DESCRIPTION	UNIT	TOTAL
40' Wood Pole with Guy Wires	EA	2
12 AWG 5 Conductor Cable	LF	329
Underground 2" Dia Rigid Conduit	LF	8
Pole Mtd. 2.5" Dia Rigid Conduit	LF	40
1/2" Span Wire - 7 Strand Steel	LF	88
1/2" Stability Wire - 7 Strand Steel	LF	88
Cable Hangers	LS	1
Mounting Hardware	EA	2
3 Section Head with 12" Lenses	EA	3

Items shown above are for informational purposes. Contractor shall provide all labor and equipment necessary for the temporary signal system to be fully operational as shown in the plans. Items shall be included in the corresponding price bid for "Temporary Traffic Signals."

This document was originally issued and sealed by Joshua M. Loegering, Registration Number PE- 9139, on 07/28/17 and the original document is stored at the North Dakota Department of Transportation

US Hwy 2
Construction Signal Phasing
Cable & Conduit Schedule
Intersection of Co Hwy 6
Site 3

	STATE	PROJECT NO.	SECTION NO.	SHEET NO.
	ND	NH-NHU-7-002(156)022	180	1



NORTH DAKOTA DEPARTMENT OF TRANSPORTATION

LOCATION OF PIT IN SECTION

TEST HOLE PLAT

Location: SE1/4 10-24-59 County: Richland, MT

Ownership: Prewitt Land & Livestock

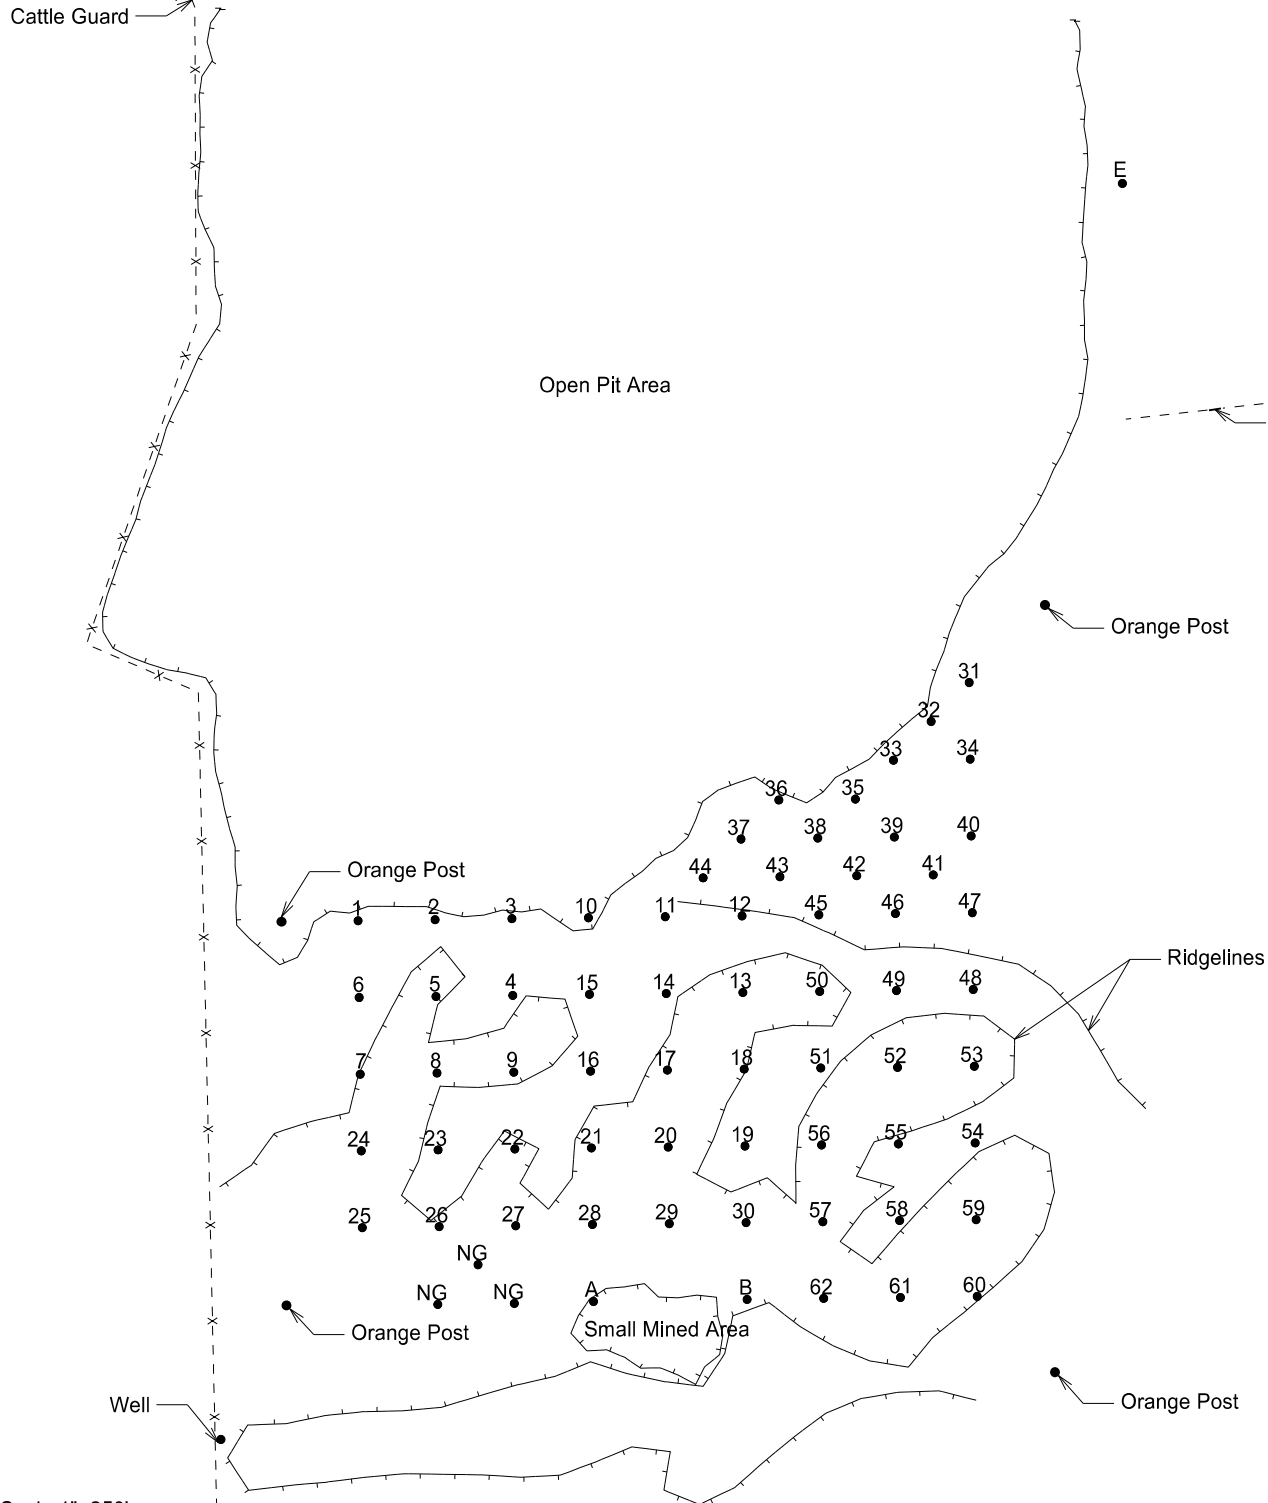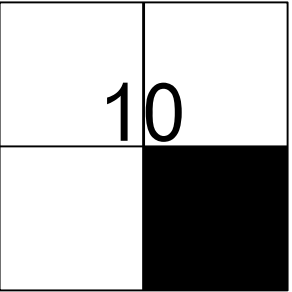

Area "A" consists of test holes 1-9
Area "B" consists of test holes 10-18
Area "C" consists of test holes 19-30
Area "D" consists of test holes 31-44
Area "E" consists of test holes 45-53
Area "F" consists of test holes 54-62
Test Holes A-E are for Information only

Legend
gr = gravel
Fgr = fine gravel
CGr = coarse gravel
sd = sand
FS = fine sand
CS = coarse sand
sh = shale
SiCl = silt clay
rk = rock
FeO = iron oxide
CoS = coal slack
NG = no gravel
DM = disturbed material
WL = water line

Scale 1"=250'

																								STATE	PROJECT NO.		SECTION NO.	SHEET NO.				
																								ND	NH-NHU-7-002(156)022		180	2				
PIT LOGGING BY TEST HOLES								PIT LOGGING BY TEST HOLES								PIT LOGGING BY TEST HOLES								PIT LOGGING BY TEST HOLES								
Test Hole No.	Depth of Stripping (Ft)	Depth of Material (Ft)	% Retained on 1½" Screen	% Retained on ¾" Screen	% Retained on 3/8" Screen	% Retained on #4 Screen	Bottom of Test Hole	Test Hole No.	Depth of Stripping (Ft)	Depth of Material (Ft)	% Retained on 1½" Screen	% Retained on ¾" Screen	% Retained on 3/8" Screen	% Retained on #4 Screen	Bottom of Test Hole	Test Hole No.	Depth of Stripping (Ft)	Depth of Material (Ft)	% Retained on 1½" Screen	% Retained on ¾" Screen	% Retained on 3/8" Screen	% Retained on #4 Screen	Bottom of Test Hole	Test Hole No.	Depth of Stripping (Ft)	Depth of Material (Ft)	% Retained on 1½" Screen	% Retained on ¾" Screen	% Retained on 3/8" Screen	% Retained on #4 Screen		
1	0.5	6.0 gr	0	15	38	55	+	10	0.5	1.0 FS	1	19	36	47	+	17	0.5	0.5 gr Si Cl	0	12	34	48	+	24	1.0	1.0 Fgr Si Cl	0	4	19	30	Si Cl	
		0.5 sd								3.5 gr								1.0 sd								1.5 Fgr						
		4.0 gr								1.0 FS								1.0 sd Si Cl								0.5 sd						
		1.0 Fgr								4.0 gr								1.0 gr								1.0 gr Si Cl						
		6.0 gr								1.0 Si Cl								1.0 Fgr						25	0.5	2.5 gr	1	19	40	52	Si Cl	
		2.0 gr Si Cl								2.0 gr								1.0 gr						26	1.0	1.0 gr Si Cl	0	13	35	48	Si Cl	
2	2.0	3.0 gr	1	16	37	53	+			3.0 FS								1.0 sd								2.0 gr						
		1.0 FS								4.0 gr								6.0 gr								1.0 sd						
		1.0 sd						11	2.0	11.5 gr	0	13	31	46	+			2.0 gr Si Cl								3.0 gr						
		13.0 gr								0.5 sd								1.0 Fgr								0.5 gr Si Cl						
3	1.0	4.0 gr	1	16	35	51	+			3.0 gr								2.0 gr						27	5.0	1.0 sd	0	9	24	35	Si Cl	
		2.0 sd								1.0 sd								1.0 gr Co S								2.0 gr						
		1.0 FS								2.0 gr								1.0 gr								1.0 FS						
		12.0 gr						12	1.0	2.0 sd	0	14	30	41	+	18	0.5	1.5 gr Si Cl	0	15	28	37	+			2.0 sd						
4	2.0	1.0 Fgr Si Cl	0	13	37	53	+			1.5 Fgr								4.0 gr						28	3.0	1.0 Fgr Si Cl	0	8	24	42	Si Cl	
		2.0 gr								3.0 gr								0.5 Si Cl								1.0 gr Si Cl						
		1.0 Fgr Si Cl								1.0 FS								2.5 FS						29	2.5	1.5 gr Si Cl	1	24	43	54	Si Cl	
		11.0 gr								3.0 gr								1.0 gr								1.5 gr						
		1.0 gr Co S								1.0 FS								2.0 sd								3.5 gr Si Cl						
		2.0 gr								4.5 gr								1.0 FS Co S						30	0.5	12.5 gr	1	13	39	56	Si Cl	
5	0.5	2.5 gr	1	17	40	55	Si Cl			3.0 FS								2.0 gr						31	2.0	8.0 gr	1	17	38	51	Si Cl	
		1.0 FS						13	0.5	2.5 gr	0	10	29	42	+			3.0 FS								1.0 FS						
		8.0 gr								2.0 sd								2.0 gr								1.0 gr Si Cl						
		2.0 FS								1.0 gr						19	4.0	3.0 sd	0	17	35	44	+			4.5 gr						
		5.0 gr								0.5 Fgr								13.0 gr						32	0.5	0.5 gr Si Cl	0	12	32	47	Si Cl	
6	0.5	0.5 Fgr Si Cl	0	11	33	48	Si Cl			1.0 gr						20	2.0	1.0 sd Si Cl	0	16	36	48	Si Cl			8.0 gr						
		9.0 gr								1.5 sd								8.0 gr								1.0 Fgr						
		1.0 sd Si Cl								1.0 Fgr						21	1.5	0.5 Fgr Si Cl	0	12	30	45	Si Cl			2.0 FS						
		0.5 sd								6.5 gr								2.5 gr								5.0 gr						
		0.5 Fgr								0.5 sd								0.5 sd								1.0 gr Si Cl						
		3.0 gr								1.0 Fgr								1.0 gr						33	3.0	5.0 gr	0	12	26	36	+	
		3.0 gr Si Cl								2.0 gr								1.0 sd								1.0 sd						
7	0.5	4.0 gr	1	15	36	50	Si Cl	14	2.0	2.0 sd	1	16	35	47	+			2.0 gr								1.0 gr						
		0.5 FS								14.0 gr								1.0 sd								1.5 sd						
		1.5 gr								1.0 sd								4.0 gr								2.5 gr						
		2.5 FS								1.0 Fgr								2.0 gr Si Cl								1.0 gr Si Cl						
		4.5 gr						15	2.0	0.5 sd Si Cl	0	16	39	55	+	22	1.5	0.5 Fgr Si Cl	0	17	38	52	Si Cl			1.0 gr						
8	1.0	1.0 gr Si Cl	0	10	31	45	Si Cl			0.5 Fgr								9.0 gr								4.0 sd						
		2.0 gr								17.0 gr								1.0 Fgr														
		1.0 gr Co S						16	0.5	2.5 gr Si Cl	1	15	30	39	+			3.0 gr														
		1.0 gr								4.0 gr								1.0 gr Si Cl										RANGE 59 TWP 24 SEC SE1/4 10				
		1.0 sd								6.0 FS						23	0.5	1.5 gr Si Cl	1	19	41	53	Si Cl					COUNTY Richland MT Oct-15				
		4.0 gr								4.0 gr								8.0 gr										PROSPECTED BY Volk/Nelson				
		1.0 gr Si Cl								1.5 gr Si Cl								0.5 FS										INSPECTED & APPROVED Jeffrey Swank Oct-15				
9	0.5	1.5 gr Si Cl	2	24	44	55	+			1.5 gr								0.5 gr														
		13.0 gr																2.0 sd														
		1.0 FS																3.0 gr														
		4.0 gr																														

[illegible]

[illegible]