JOB # 10 NORTH DAKOTA DEPARTMENT OF TRANSPORTATION

OF TRANSPORTATION

GOVERNING SPE

IM-NHU-5-094(132)903

Stark County
Interstate 94 Business Loop from
Interstate 94 to 8th Street
Shared Use Path, Bridge, and Lighting

STATE PROJECT NO. PCN SECTION NO. ND IM-NHU-5-094(132)903 22219 1

GOVERNING SPECIFICATIONS:

2014 Standard Specifications adopted by the North Dakota Department of Transportation and the Supplemental Specifications effective on the date the project is advertised.

PROJECT NUMBER \ DESCRIPTION

NET MILES

GROSS MILES


SHEET NO.

1

IM-NHU-5-094(132)903

0.554

0.554

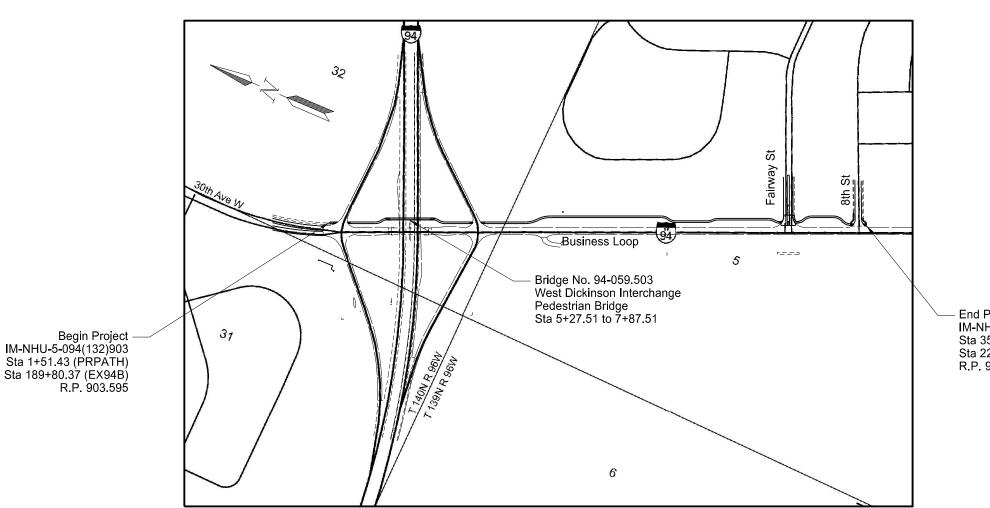

Legal Descriptions Sec 32 T140N R96W Sec 05 T139N R96W

- End Project IM-NHU-5-094(132)903 Sta 35+56.95 (PRPATH) Sta 223+36.23 (EX94B) R.P. 904.149

MC KENZIE

MC LEAN

MC LEAN

MC LEAN

MORTON

BOWMAN

ADAMS

BOTTINEAU

OLIVER

BOTTINEAU

OLIVER

DUNN

MERCER

MORTON

BOWMAN

ADAMS

SIOUX

CAVALIER

REDDY

MALSH

WALSH

BENSON

FORKS

FOSTER

STUTSMAN

BARNES

CASS

BOWMAN

ADAMS

SIOUX

BOWMAN

ADAMS

SIOUX

DICKEY

WARGEN

CAVALIER

REDDY

TRAILL

TRAILL

DICKEY

MORTON

BOWMAN

ADAMS

SIOUX

DICKEY

MORTON

BOWMAN

ADAMS

ND DEPARTMENT OF TRANSPORTATION OFFICE OF PROJECT DEVELOPMENT

Chad M. Orn /s/

1/23/2020

This document was originally issued and sealed by Ryan Schuehle, Registration Number PE- 10772, on 1/14/2020 and the original document is stored at the North Dakota Department of Transportation

SRF CONSULTING GROUP INC.

DESIGNER Steve McHenry DESIGNER Ryan Rykowsky

DESIGNER Devin Power STATE COUNTY MAP

TABLE OF CONTENTS

STATE	PROJECT NO.	SECTION NO.	SHEET NO.
ND	IM-NHU-5-094(132)903	2	1

PLAN SECTIONS

		0_0
Section	Page(s)	Description
1	1	Title Sheet
2	1 - 2	Table of Contents
4	1 - 2	Scope of Work
6	1 - 3	Notes
6	4	Environmental Notes
8	1 - 2	Quantities
10	1	Basis of Estimate
11	1 - 2	Earthwork Summary and Mass Diagram
20	1 - 17	General Details
30	1 - 3	Typical Sections
40	1 - 3	Removals
50	1	Inlet and Manhole Summary
51	1	Allowable Pipe List
60	1 - 6	Plan & Profile
75	1 - 4	Wetland Impacts
76	1 - 3	Temporary Erosion Control
77	1 - 3	Permanent Erosion Control
80	1 - 3	Cross Slope Layout
81	1 - 3	Survey Coordinate and Curve Data
82	1 - 3	Survey Data Layouts
90	1 - 3	Paving Layouts
100	1 - 3	Work Zone Traffic Control
110	1 - 7	Signing
130	1 - 8	Guardrail
140	1 - 6	Lighting
170	1 - 20	Bridge
175	1 - 3	Soil Boring Logs
200	1 - 79	Cross Sections

SPECIAL PROVISIONS

Number	Description
SP 003(14)	Temporary Erosion and Sediment Best Management Practices
SP 004(14)	Federal Migratory Bird Treaty Act
SP 1024(14)	Painting Over Galvanized Steel
SP 1025(14)	Utility Coordination
SP 1026(14)	Commercial Grade Asphalt
SP 1039(14)	Drilled Shaft Foundations for Highway Lighting and Signals
SP 1040(14)	Conditions of Contract Award
SP 5332(14)	Permits and Environmental Considerations

2/6/2020 2:35:47 PM rschuehle


TABLE OF CONTENTS
LIST OF STANDARD DRAWINGS


STATE	PROJECT NO.	SECTION NO.	SHEET NO.
ND	IM-NHU-5-094(132)903	2	2

Number	Description
D-101-1, 2,3	NDDOT Abbreviations
D-101-10	NDDOT Utility Company and Organization Abbreviations
D-101-20, 21	Line Styles
D-101-30, 31,32	Symbols
D-101-40	Cross Section Legend
D-255-1	Bridge Approach Slab Drainage Detail
D-258-1	Standard Slope Protection Under Bridges
D-261-1	Erosion Control - Fiber Roll Placement Details
D-622-1	Pile Splice Details
D-704-1	Attenuation Device
D-704-7	Breakaway Systems For Construction Zone Signs - Perforated Tube
D-704-8	Breakaway Systems For Construction Zone Signs - U-Channel Post
D-704-9	Construction Sign Details - Terminal And Guide Signs
D-704-10	Construction Sign Details - Regulatory Signs
D-704-13	Barricade And Channelizing Device Details
D-704-14	Construction Sign Punching And Mounting Details
D-704-22	Construction Truck And Temporary Detour Layouts
D-704-23	Short Term Urban Detour And Lane Closure On A Divided Highway Layouts
D-704-24	Shoulder Closures And Bridge Painting Layouts
D-704-25	Lane Closures On Urban Streets Layouts
D-704-35	Sign Layout For One Lane Closure - Interstate System
D-704-51	Portable Precast Concrete Median Barrier (Temporary Usage)
D-704-52	Interstate Road Closure Using Ramps - Closure for Less Than One Day - and Crossroad is not Closed
D-704-58	Divided Highway Operation for Overhead Structure, Pier, and Footing Replacement
D-708-6	Erosion And Siltation Controls - Median Or Ditch Inlet Protection
D-714-1	Reinforced Concrete Pipe Culverts And End Sections (Round Pipe)
D-714-18	Edgedrain Details
D-714-22	Concrete Pipe, Cattle Pass, or Precast Concrete Box Culvert Ties
D-714-27	Pipe Installation Detail for Longitudinal Mainline Pipe or Pipe Not Under the Roadway
D-722-2	Inlet - Type 2
D-722-5	Manhole Details
D-748-1	Curb & Gutter And Valley Gutter
D-750-2	Sidewalk
D-750-3	Curb Ramp Details
D-754-1	Pipe Or W-Shape Assembly Details
D-754-2	Breakaway Coupler System For Standard Pipe - Stub Post
D-754-3	Breakaway System for Standard Pipe - Stub Post
D-754-4	Multi-Directional Breakaway System for Standard Pipe - Stub Post
D-754-5	Foundation Data For Steel Supports
D-754-6	Hinge Plate, Fuse Plate, And Foundation Details For Standard Pipe
D-754-7	Pipe Support And Sign Mounting Details
D-754-12	Breakaway Coupler System - Structural Details For W-Shape Supports
D-754-13	Breakaway System Structural Details For W-Shape Supports
D-754-14	Wind Beams And Anchor Plates For W-Shape Supports

Number	Description
D-754-24	Mounting Details Perforated Tube
D-754-24A	Breakaway Coupler System For Perforated Tubes
D-754-25	Mounting Details Perforated Tube
D-754-28	Sign Punching, Stringer, and Support Location Details Regulatory, Warning and Guide Signs
D-754-46	Punching, Stringer, and Support Location Details for Regulatory, Warning and Guide Bike Route Signs
D-754-48	Sign Punching, Stringer And Support Location Details For Variable Length Signs
D-754-83	Object Markers - Culverts
D-754-87	Sign Punching, Stringer And Support Location Details For Street Name Signs And 911 Signs
D-770-1	Concrete Foundations (Traffic Signals & Highway Lighting)
D-770-2	Feed Points (Roadway Lighting)
D-770-3	Pull Box Details
D-770-4	Lighting And Signal Details
D-770-5	Light Standard Details
D-900-1	Bridge Bench Marks

1/17/2020 10:39:44 AM rschuehle

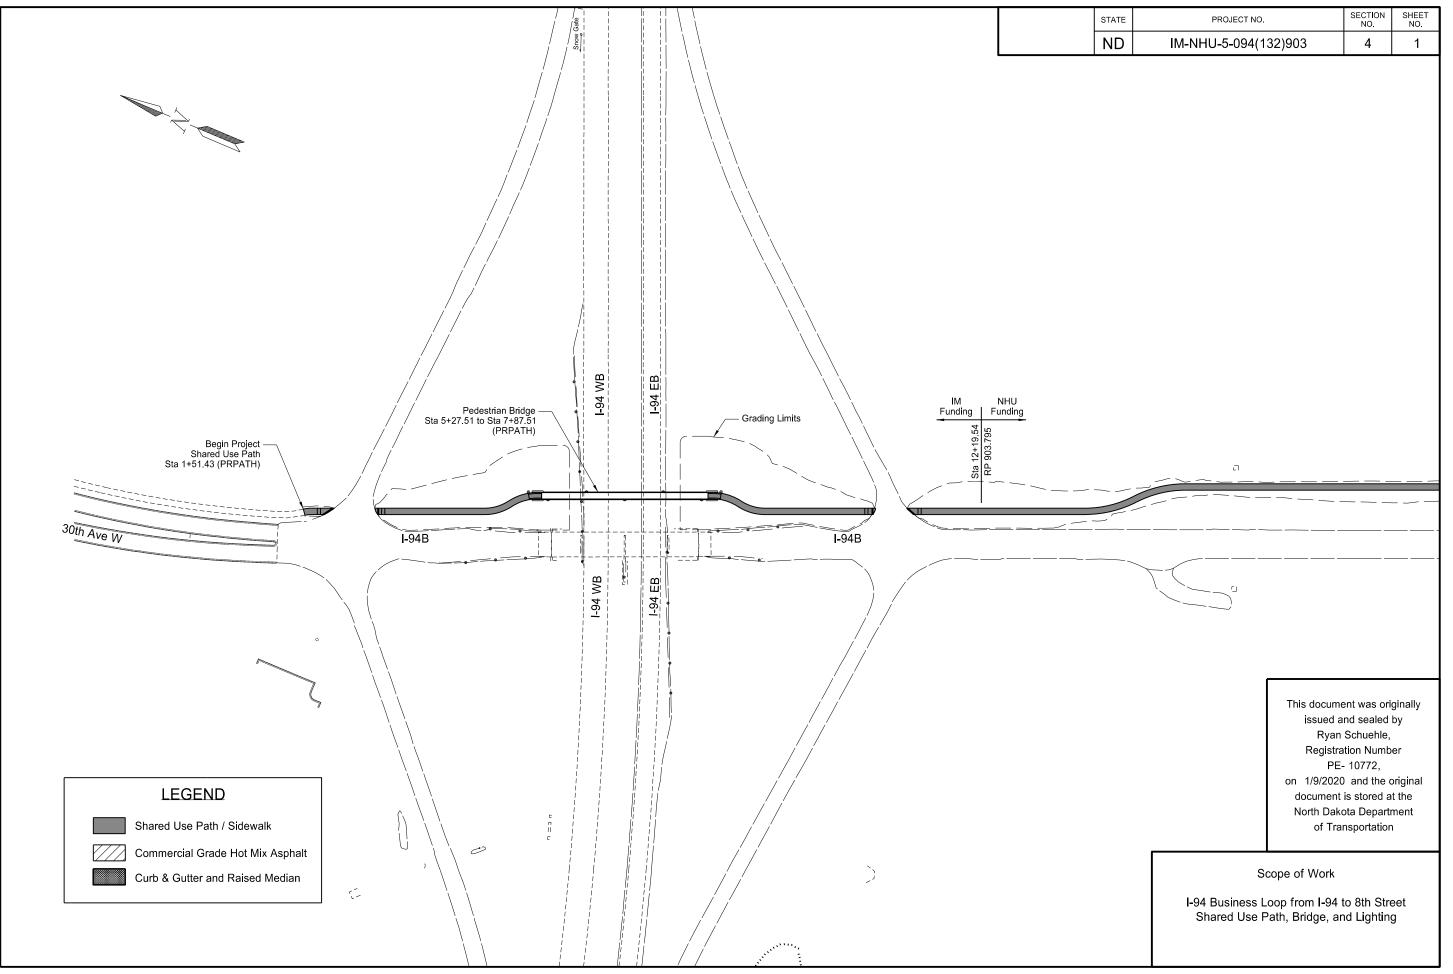

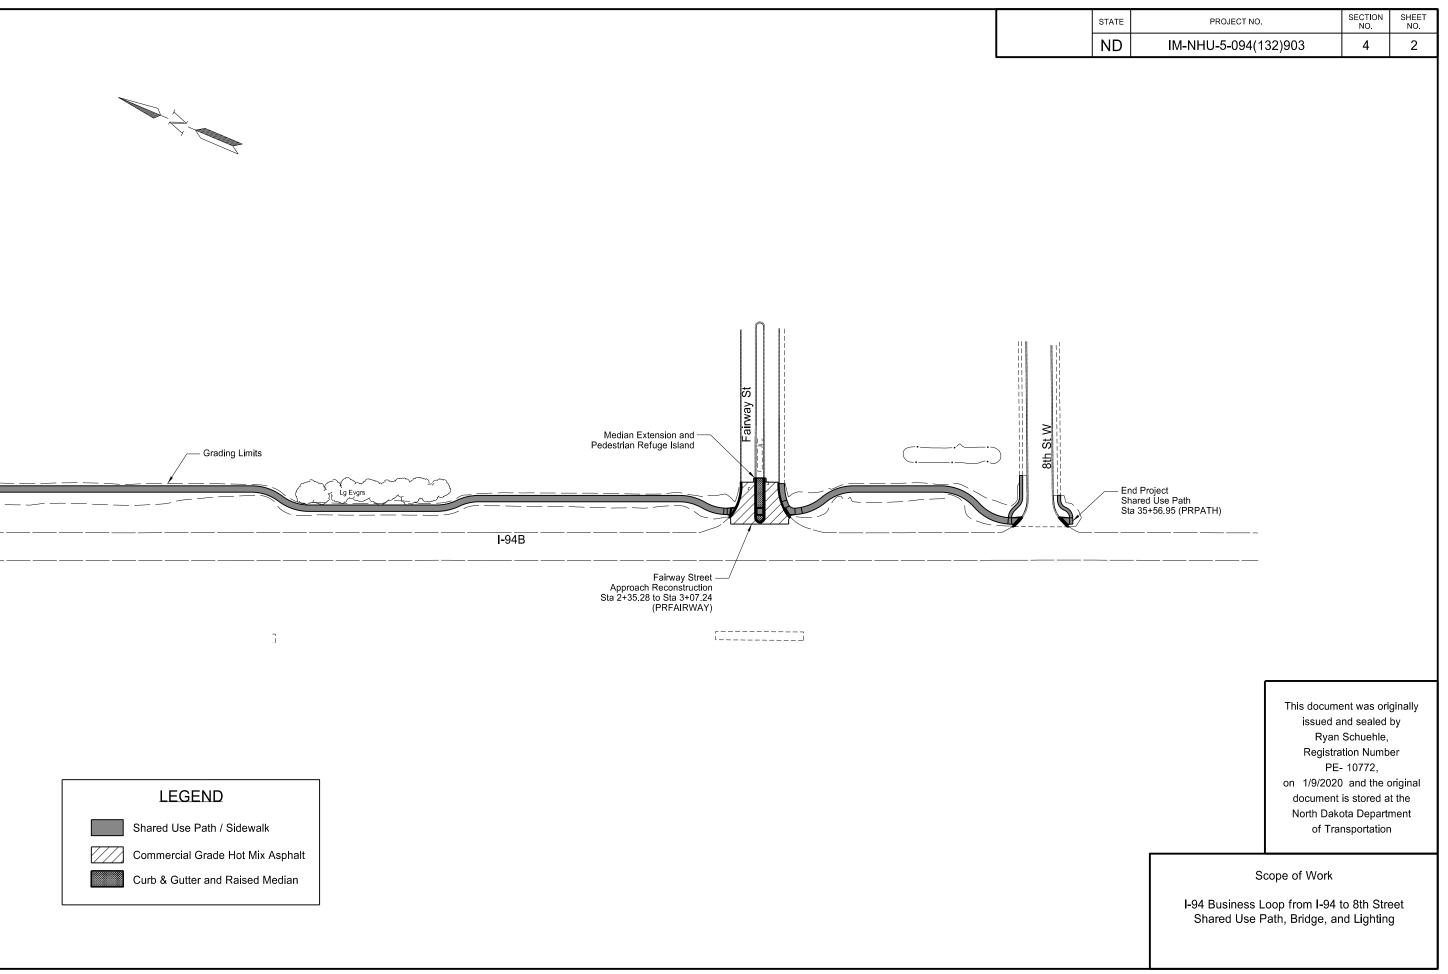

NOTES

STATE	PROJECT NO.	SECTION NO.	SHEET NO.
ND	IM-NHU-5-094(132)903	6	1

GENERAL NOTES

100-P01 COORDINATION OF PROJECTS: There are other projects in the vicinity of this project under contract during the 2020 construction season.

Project 201914 is a City of Dickinson project and is located at Fairway Street west of the I-94 Business loop. The project will consist of the installation of water, sewer, and streets west of the business loop and will include boring to the east side of the business loop to connect to existing watermain.

Contact:

Craig Kubas

Dickinson City Engineer

Phone: 701-456-7715

Email: Craig.Kubas@dickinsongov.com

Project NHU-5-094(136)903 is a North Dakota Department of Transportation Project along I-94. The project will consist of Microsurfacing.

- 105-200 UTILITY COORDINATION: A utility coordination meeting is required.
- 107-P01 TREE PRECAUTIONS: Use care when working near trees. Protect the tree and the root zone during construction.
 - 1. Minimize equipment use near trees. Use common access points when possible.
 - 2. Bore when possible.
 - 3. Roots over 4" diameter that are cut will require an inspection by a Forestry Department Arborist or other designated representative.
 - 4. Cut, clean, and backfill exposed tree roots as quickly as possible to avoid drying out.
 - 5. Avoid unnecessary grading.
 - 6. Provide an ISA Certified Arborist to perform pruning.
 - 7. Contact the City Forestry Department if there is a physical impact to any tree not designated for removal. The City Forestry Department will determine the extent of the impact. Mitigate any impacts identified to the extent detailed by the City Forestry Department at no cost to the NDDOT.
- 201-P01 CLEARING AND GRUBBING: There are approximately 11 trees to be removed as shown in section 40. The 5 trees denoted as "To Be Removed by Other" will be salvaged by the City of Dickinson. Salvage work is estimated to be completed by the City of Dickinson prior to April 30th pending weather limitations. The remaining 6 trees will be removed by the contractor. It is the Contractor's responsibility to assess the work required for removal. Include all costs for labor, equipment, removal, and disposal of trees in the unit bid price for "CLEARING AND GRUBBING".

202-P01 REMOVAL OF PAVEMENT: Removal of pavement consists of removing median paving, sidewalks, bituminous pavement, concrete pavement, and aggregate base.

Existing pavement thicknesses are averaged based on old sets of plans and maintenance data.

- Pavement removals: 5" pavement / 8" aggregate base (Fairway Street)
- Sidewalk removals: 4" concrete / 4" aggregate base (I-94 Business Loop)
- Median pavement: 4" concrete / 12" aggregate base (Fairway Street)
- 203-010 SHRINKAGE: 25 percent additional volume is included for shrinkage in earth embankment.
- 203-385 AVERAGE HAUL: No average haul has been computed for this project.
- 203-P01 COMMON EXCAVATION TYPE A: Excavated material, removed within the right-ofway, to construct the proposed street and sidewalk improvements can be used as proposed embankment if the material is suitable.

Excavated material that is suitable for embankment construction may be stockpiled within existing right-of-way. Stockpiling of material on new pavement and sidewalk is not allowed.

Plan quantity will be used as the measurement for payment for "Common Excavation-Type A". Include all costs for excavation, haul, temporary and final placement, stockpile erosion control & stormwater management, and compaction of embankment material within the right-of-way in the contract unit price for "Common Excavation – Type A".

- 203-P02 CONTRACTOR FURNISHED BORROW: Obtain the proper clearance for contractor furnished borrow. A number of potential material sources are identified as borrow clues, these sites are:
 - Clue A: Section 32, T140N, R96W, Quarter Section SW ¼ The south backslope of the I-94 EB on-ramp within NDDOT ROW contains available borrow. Contact Dickinson District Engineer Rob Rayhorn at 701-227-6511.
 - Clue B: Section 27, T139N, R96W, Quarter Section NW ¼ the Stark County Fairgrounds is interested in having a hill cut down. Contact Lisa Heiser at 701-290-0293.

Earth moving equipment (scraper hauled dirt) will not be allowed on the highway pavement.

This document was originally issued and sealed by Ryan Schuehle, Registration Number PE-10772, on 1/17/2020 and the original document is stored at the North Dakota Department of Transportation.

NOTES

STATE	PROJECT NO.	SECTION NO.	SHEET NO.
ND	IM-NHU-5-094(132)903	6	2

- 203-P03 EMBANKMENT MATERIAL: All embankment material must be comprised of less than 45% particles smaller than 0.02 millimeters as determined by AASHTO T88 and a Liquid Limit less than 45 as determined by AASHTO T89. When a material is found that meets the above testing requirements, a sample of the proposed material will be collected by the Engineer and sent to the NDDOT Materials & Research Division, 300 Airport Road Bismarck, ND for final acceptance. Results from the tests will be completed within 7 working days from material delivery date. Complete the above tests and final acceptance procedure each time a compaction curve is required.
- 203-P04 EMBANKMENT MATERIAL: Embankment material from Sta 3+00 to 9+50 must be in place a minimum of 95 days prior to paving the shared use path. This time may be reduced as directed by the Engineer if the settlement plates show that settlement has finished prior to the end of the estimated 95 days.
- 704-200 PRECAST CONCRETE MEDIAN BARRIERS STATE FURNISHED: Obtain 112 barriers from the NDDOT Maintenance Yard in Belfield. Return barriers to the NDDOT Maintenance Yard in Belfield.

Install any missing markers on the barriers before traffic use. Include the cost of the markers in the contract unit price for "Precast Concrete Median Barrier – State Furnished".

Some 4 inch x 4 inch boards are available at the return location. Provide any additional 4 inch x 4 inch boards necessary to stack barriers. The boards will become property of the Department. Include the cost for boards in the contract unit price for "Precast Concrete Median Barrier - State Furnished".

704-P01 TRAFFIC CONTROL DEVICES: The traffic control devices list has been developed using the following layouts on the Standard Drawing for traffic control.

D-704-22, Type K and Type L for construction trucks hauling material.

D-704-23, Detour Layout

D-704-24, Type R, Shoulder closure on NB I-94 Business loop from 8th St W to I-94 WB off ramp.

D-704-25, Type W Work beyond the driving lane for installation of curb ramps at the I-94 On and Off ramps and 8th St W

D704-25, Type X Lane closures at intersections for crosswalk pavement markings D-704-35, One lane closure for temporary widening of aggregate base and placing and removing precast concrete jersey barriers.

D-704-52, Interstate road closure using ramps

D-704-58, Structure median pier construction.

- 704-P02 DETOUR: The new structure at Exit 59 will require placing new beams over Interstate 94 traffic. Detour traffic in accordance with Standard Drawing D-704-52 when these activities are taking place. Use flagger control at ramp intersections during this operation. These described detours are permitted as follows:
 - One day for setting bridge beams over WB I-94 detour WB I-94 traffic only.
 - One day for setting bridge beams over EB I-94 detour EB I-94 traffic only.

The one day detours will only be permitted during nighttime hours from 8:00 pm to 6:00 am. Prior to closing Interstate 94, notify the Dickinson District 48 hours in advance of implementing the detour route.

- 704-P03 DETOUR: The traffic detour outlined on sheet 100-2 for the Fairway Street reconstruction will not exceed a duration of 21 calendar days. Days are counted from when detour signage and construction traffic control devices are installed until the work is completed and the signage and devices removed and traffic can return freely. All bituminous paving, median paving, curb and gutter, sidewalk, storm sewer, and other items necessary to allow normal traffic operation to resume on Fairway Street must be completed within the 21 calendar days.
- 708-P01 INLET PROTECTION: All costs associated with furnishing, preparation of inlet and protection device, installing, maintaining, disposal of sediment and removal are included in the cost for INLET PROTECTION-SPECIAL. Use Dandy Curb Sack, EconoCurb, Frye Flow, Flexstorm Catch-It, or approved equal.
- 714-P01 CONNECT TO EXISTING PIPE: Connect existing pipe to proposed structure. The existing pipe material and size shown in Section 60 of the plan set is based on record drawings and field data. No additional compensation will be paid for the pipe connection if the existing pipe encountered is different than material and size shown. Included all costs to perform this work in the contract unit price for "Manhole 54IN".
- 722-P01 INLETS AND MANHOLES: Inlets and manholes were designed with a minimum 4-foot riser height. Fill the bottom of each drainage structure with concrete, up to the lowest invert elevation.

Concrete manhole at Sta 30+89 will require a concrete collar per detail on sheet 20-12. Include all costs for labor, materials, and equipment needed to install concrete collar in the contract unit price for "Manhole 54IN".

750-P01 CURB RAMPS AND LANDINGS: Ensure that all curb ramps and landings meet current design standards. Curb ramps and landings cannot be placed until after concrete curb & gutter has been completed.

The concrete landings, as designated in Section 20 detail sheets and labeled "D", must be installed first prior to adjacent curb ramps and/or sidewalks allowing for a minimum of 24 hours of cure time.

This document was originally issued and sealed by Ryan Schuehle, Registration Number PE-10772, on 1/17/2020 and the original document is stored at the North Dakota Department of Transportation.

NOTES

STATE	PROJECT NO.	SECTION NO.	SHEET NO.
ND	IM-NHU-5-094(132)903	6	3

764-P01 REMOVE ATTENUATING CRASH CUSHION TL-3: Removal of the existing attenuating crash cushion includes removal of the crash cushion and the underlying concrete base. Deliver the removed attenuating crash cushion to the Dickinson District Yard.

Include all costs to remove the existing concrete bases in the contract unit price bid for the item "Remove Attenuating Crash Cushion TL-3".

764-P02 ATTENUATING CRASH CUSHION TL-3: Install a 24" wide QuadGuard M10 crash cushion at the end of the reinforced concrete transition wall protecting the pier of Bridge No. 94-059.503.

Install the crash cushion on a concrete pad in accordance with the crash cushion manufacturer's recommendations, with transition panels on both sides of the unit, and a Type XI yellow retroreflective sheeting on the nose, as shown in the plans.

Include all costs for supplying and installing the concrete slab, transition panels, and retroreflective sheeting in the contract unit price bid for "Attenuating Crash Cushion TL-3."

- 770-P01 CONCRETE FOUNDATION HIGHWAY LIGHTING: Provide light standard foundations 24" in diameter and 6' deep, and according to D-770-1. Bolt circle and projection to be verified with manufacturer specifications. Include spare conduit and cap end at all foundations located at the end of a circuit.
- 770-P02 ORNAMENTAL LIGHT STANDARD 10FT MT HT: Provide light standard, 10' extruded aluminum 5" pole with 17" round base, paint finish black. Duct seal all conduit stubs in concrete foundations. See table below in note 770-P04.
- 770-P03 ORNAMENTAL LIGHT STANDARD: Provide light standard, 30' round tapered steel pole with 8' bolt-on mast arm, 2-3/8" OD slipfitter, paint finish black. Duct seal all conduit stubs in concrete foundations. See table below in note 770-P04.
- 770-P04 LED LUMINAIRE: Provide LED luminaires along the trail as shown in the table below and according to the plans. Use the luminaire listed or approved equal.

LED Luminaire	Catalog Number	Pole
AEL American Revolution	247L P45 AS 40K R2 AY NR - Luminaire	10'
Holophane Wadsworth	WDA 10 L5J SL17 P07 ABG BK - Pole	
AEL Autobahn ATB2	ATB2 60BLEDE10 MVOLT R2 NR - Luminaire	30′
Millerbernd	RJAC8-320 - Pole	30

The lighting system was designed using these values:

Roadway Classification	Pedestrian and Bicycle Way
Average Maintained Illuminance	2.0 foot-candles
Illuminance Uniformity Ratio	3.0:1
Light Loss Factor	0.9

Include all cost associated with the LED lighting system in the contract unit price for "LED Luminaire".

- 902-P01 SETTLEMENT PLATE: The Engineer will establish the elevation of the settlement plates via a level loop starting from a benchmark location. The benchmark will be established prior to construction of the embankment and located in an area unaffected by construction activities.
- 902-P02 SETTLEMENT PLATE: The Engineer will survey the settlement plates and fill height (as applicable) according to the following intervals:
 - i. Immediately after settlement plate installation
 - ii. After every new pipe section is placed
 - iii. Every three days during fill operations
 - v. After completion of embankment, weekly until project completion

This document was originally issued and sealed by Ryan Schuehle, Registration Number PE-10772, on 1/17/2020 and the original document is stored at the North Dakota Department of Transportation.

ENVIRONMENTAL NOTES

 STATE
 PROJECT NO.
 SECTION NO.
 SHEET NO.

 ND
 IM-NHU-5-094(132)903
 6
 4

ENVIRONMENTAL NOTES (EN): The North Dakota Department of Transportation and the Federal Highway Administration have made environmental commitments to secure approval of this project. The following environmental notes are requirements to comply with these commitments:

<u>EN-1 TEMPORARY WETLAND IMPACT:</u> Temporary impact areas within wetlands and or other waters are incorporated into the plans for this project. Remove temporary fill placed and sedimentation in wetlands or other waters. Restore these wetlands to preconstruction contours.

This document was originally issued and sealed by Ryan Schuehle, Registration Number PE-10772, on 01/09/2020 and the original document is stored at the North Dakota Department of Transportation.

Estimated Quantities

STATE	PROJECT NO.	SECTION NO.	SHEET NO.
ND	IM-NHU-5-094(132)903	8	1

SPEC	CODE	ITEM DESCRIPTION	UNIT	IM Funding	NHU Funding	TOTAL
103	0100	CONTRACT BOND	L SUM	0.78	0.22	1
201	0330	CLEARING & GRUBBING	L SUM	0.78	0.22	1
202	0101	REMOVAL OF CONCRETE	EA	1		1
202	0114	REMOVAL OF CONCRETE PAVEMENT	SY	21	12	33
202	0130	REMOVAL OF CURB & GUTTER	LF		58	58
202	0132	REMOVAL OF BITUMINOUS SURFACING	SY	3	532	535
202	0169	REMOVAL OF END SECTION-ALL TYPES & SIZES	EA		1	1
203	0101	COMMON EXCAVATION-TYPE A	CY	14	137	151
203	0109	TOPSOIL	CY	1190	1206	2396
203	0140	BORROW-EXCAVATION	CY	15075	3903	18978
210	0099	CLASS 1 EXCAVATION	L SUM	1		1
210	0201	FOUNDATION PREPARATION	EA	1		1
216	0100	WATER	M GAL	169	68	237
251	0100	SEEDING CLASS I	ACRE	1.5	1.5	3
251	2000	TEMPORARY COVER CROP	ACRE	1.6	1.5	3.1
253	0201	HYDRAULIC MULCH	ACRE	3.1	3	6.1
255	0102	ECB TYPE 2	SY	4207	876	5083
258	0100	CONCRETE SLOPE PROTECTION	SY	154		154
261	0112	FIBER ROLLS 12IN	LF	5107	2522	7629
261	0113	REMOVE FIBER ROLLS 12IN	LF	3508	1532	5040
302	0120	AGGREGATE BASE COURSE CL 5	TON	180	883	1063
430	0500	COMMERCIAL GRADE HOT MIX ASPHALT	TON		114	114
602	0130	CLASS AAE-3 CONCRETE	CY	231.8		231.8
602	1130	CLASS AE-3 CONCRETE	CY	89.6		89.6
602	1250	PENETRATING WATER REPELLENT TREATMENT	SY	496		496
604	9920	PRESTRESSED I-BEAM-63IN	LF	512		512
612	0115	REINFORCING STEEL-GRADE 60	LBS	19947		19947
612	0116	REINFORCING STEEL-GRADE 60-EPOXY COATED	LBS	28916		28916
622	0060	STEEL PILING HP 14 X 73	LF	150		150
622	0070	STEEL PILING HP 14 X 102	LF	90		90
624	0123	PEDESTRIAN RAILING	LF	578.7		578.7
702	0100	MOBILIZATION	L SUM	0.78	0.22	1
704	0100	FLAGGING	MHR	328		328
704	1000	TRAFFIC CONTROL SIGNS	UNIT	2886	936	3822
704	1045	ATTENUATION DEVICE-TYPE B-75	EA	2		2
704	1052	TYPE III BARRICADE	EA	4	12	16
704	1060	DELINEATOR DRUMS	EA	79		79
704	1065	TRAFFIC CONES	EA	44		44
704	1067	TUBULAR MARKERS	EA	64		64
704	1087	SEQUENCING ARROW PANEL-TYPE C	EA	1		1
704	1500	OBLITERATION OF PAVEMENT MARKING	SF	162		162
704	3510	PRECAST CONCRETE MED BARRIER-STATE FURNISHED	EA	112		112
708	1540	INLET PROTECTION - SPECIAL	EA		4	4
708	1541	REMOVE INLET PROTECTION - SPECIAL	EA		4	4
714	0310	PIPE CONC REINF 18IN CL III	LF	4		4
714	0820	PIPE CONC REINF 30IN CL III	LF	·	70	70
714	0905	PIPE CONC REINF 36IN CL III	LF		42	42
						·-

Estimated Quantities

STATE	STATE PROJECT NO.		SHEET NO.
ND	IM-NHU-5-094(132)903	8	2

SPEC	CODE	ITEM DESCRIPTION		UNIT	IM Funding	NHU Funding	TOTAL
714	4097	PIPE CONDUIT 15IN-STORM DRAIN		LF		26	
714	7000	PIPE PVC 8IN DRAIN		LF		8	8
714	9660	REMOVE & RELAY END SECTION-ALL TYPE & SIZES		EA	1	4	5
722	0100	MANHOLE 48IN		EA		1	1
722	0107	MANHOLE 54IN		EA		1	1
722	1100	MANHOLE RISER 48IN		LF		4	4
722	1106	MANHOLE RISER 54IN		LF		4.8	4.8
722	3510	INLET-TYPE 2		EA		1	1
722	6140	ADJUST GATE VALVE BOX		EA	1	2	3
722	6200	ADJUST MANHOLE		EA	2	4	6
748	0140	CURB & GUTTER-TYPE I		LF		366	366
750	0100	SIDEWALK CONCRETE		SY	131	197	328
750	0200	CONCRETE MEDIAN PAVING		SY		67	67
750	0210	CONCRETE MEDIAN NOSE PAVING		SY		9	9
750	2115	DETECTABLE WARNING PANELS		SF	88	124	212
754	0110	FLAT SHEET FOR SIGNS-TYPE XI REFL SHEETING		SF	35.6	5.2	40.8
754	0206	STEEL GALV POSTS-TELESCOPING PERFORATED TUBE		LF	100.8	16.2	117
754	0210	GALV STEEL POST-STANDARD PIPE		LF	35.2		35.2
754	0214	GALV STEEL POSTS-W-SHAPE POSTS(TWO OR MORE)		LF		57.5	57.5
754	0592	RESET SIGN PANEL		EA	6	3	9
754	0593	RESET SIGN SUPPORT		EA	6	1	7
754	0805	OBJECT MARKERS - CULVERTS		EA	1	5	6
754	1100	CLASS AE CONCRETE-SIGN FOUNDATIONS		CY	0.7		0.7
754	1104	REMOVE SIGN FOUNDATION		EA	3	2	5
762	1309	PREFORMED PATTERNED PVMT MK 8IN LINE-GROOVED		LF		35	35
762	1325	PREFORMED PATTERNED PVMT MK 24IN LINE-GROOVED		LF	312	307	619
764	9011	ATTENUATING CRASH CUSHION TL-3		EA	1		1
764	9035	REMOVE ATTENUATING CRASH CUSHION TL-3		EA	1		1
770	0001	LIGHTING SYSTEM		EA	0.78	0.22	1
900	0100	SETTLEMENT PLATE		EA	2		2
930	3000	BRIDGE BENCH MARKS		SET	1		1
930	7012	ROADWAY CANOPY		L SUM	1		1
930	8600	ELASTOMERIC BEARING PAD		SF	16		16
930	9537	ABUTMENT UNDERDRAIN SYSTEM		EA	2		2
430	0500	COMMERCIAL GRADE HOT MIX ASPHALT	Bid Option - 1	TON	147	558	705
750	0105	SIDEWALK CONCRETE BIKEWAY	Bid Option - 2	SY	615	2349	2964

BASIS OF ESTIMATE

STATE	PROJECT NO.	SECTION NO.	SHEET NO.	
ND	IM-NHU-5-094(132)903	10	1	

Water 25 MGal/Mile for Dust Palliative 20 Gal/Ton for Aggregates 10 Gal/CY for Embankment

Paving

Aggregate Base @ 1.875 Ton/CY Bituminous @ 2 Ton/CY

Obliteration of Pavement Marking

WB I-94 Off Ramp					
Location - Type	Basis	Length Quar		ntity	
White 24 IN Line	Stop Bars 2 SF/LF	81	LF	162	SF
		TO	TAL	162	SF

This document was originally issued and sealed by Ryan Schuehle, Registration Number PE-10772, on 01/09/2020 and the original document is stored at the North Dakota Department of Transportation.

Deadway	Common Excavation - Type A	Embankment*	Balance	
Roadway	СҮ	CY	CY	
	A	В	C = A - E	
Shared Use Path	146	16642	-16496	
Fairway Steet	5	37	-32	
8th Street	0	59	-59	
North Bridge Inslope	0	1110	-1110	
South Bridge Inslope	0	1039	-1039	
I-94 Median Pier Protection Embankment	0	140	-140	
Standard Drawing D-704-58 Temporary Embankment**	0	102	-102	
Totals	151	19129	-18978	

^{*25%} additional volume is included for shrinkage in earth embankment.

STATE	PROJECT NO.	SECTION NO.	SHEET NO.
ND	IM-NHU-5-094(132)903	11	1


203	0101	Common Excavation - Type A		
		(IM)		14 CY
		(NHU)		137 CY
			Total	151 CY
203	0140	Borrow-Excavation		
		(IM)		15075 CY
		(NHU)		3903 CY
			Total	18978 CY

This document was originally issued and sealed by Ryan Schuehle, Registration Number PE-10772 on 1/9/2020 and the original document is stored at the North Dakota Department of Transportation

Earthwork Summary

^{**}Removal of temporary embankment incidental to "Borrow-Excavation". Temporary embankment quantity is excluded from the mass diagram.

STATE	PROJECT NO.	SECTION NO.	SHEET NO.
ND	IM-NHU-5-094(132)903	11	2

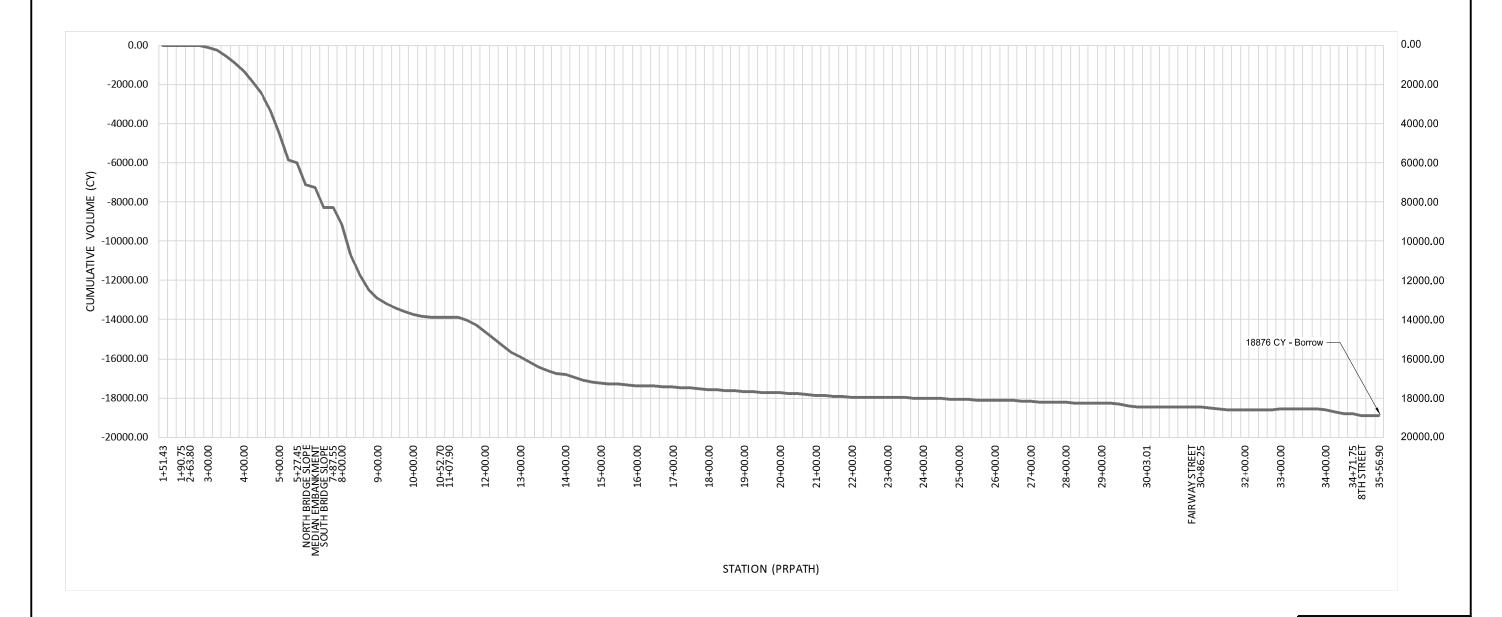


Common Excavation - Type A	Embankment	Temporary Embankment	Borrow-Excavation
CY	CY	CY	CY
Α	В	CY	D = A - B -C
151	19129	102	18876


This document was originally issued and sealed by Ryan Schuehle, Registration Number PE-10772 on 1/9/2020 and the original document is stored at the North Dakota Department of Transportation


Earthwork Mass Diagram


I-94 Business Loop from I-94 to 8th Street Shared Use Path, Bridge, and Lighting

1/9/2020

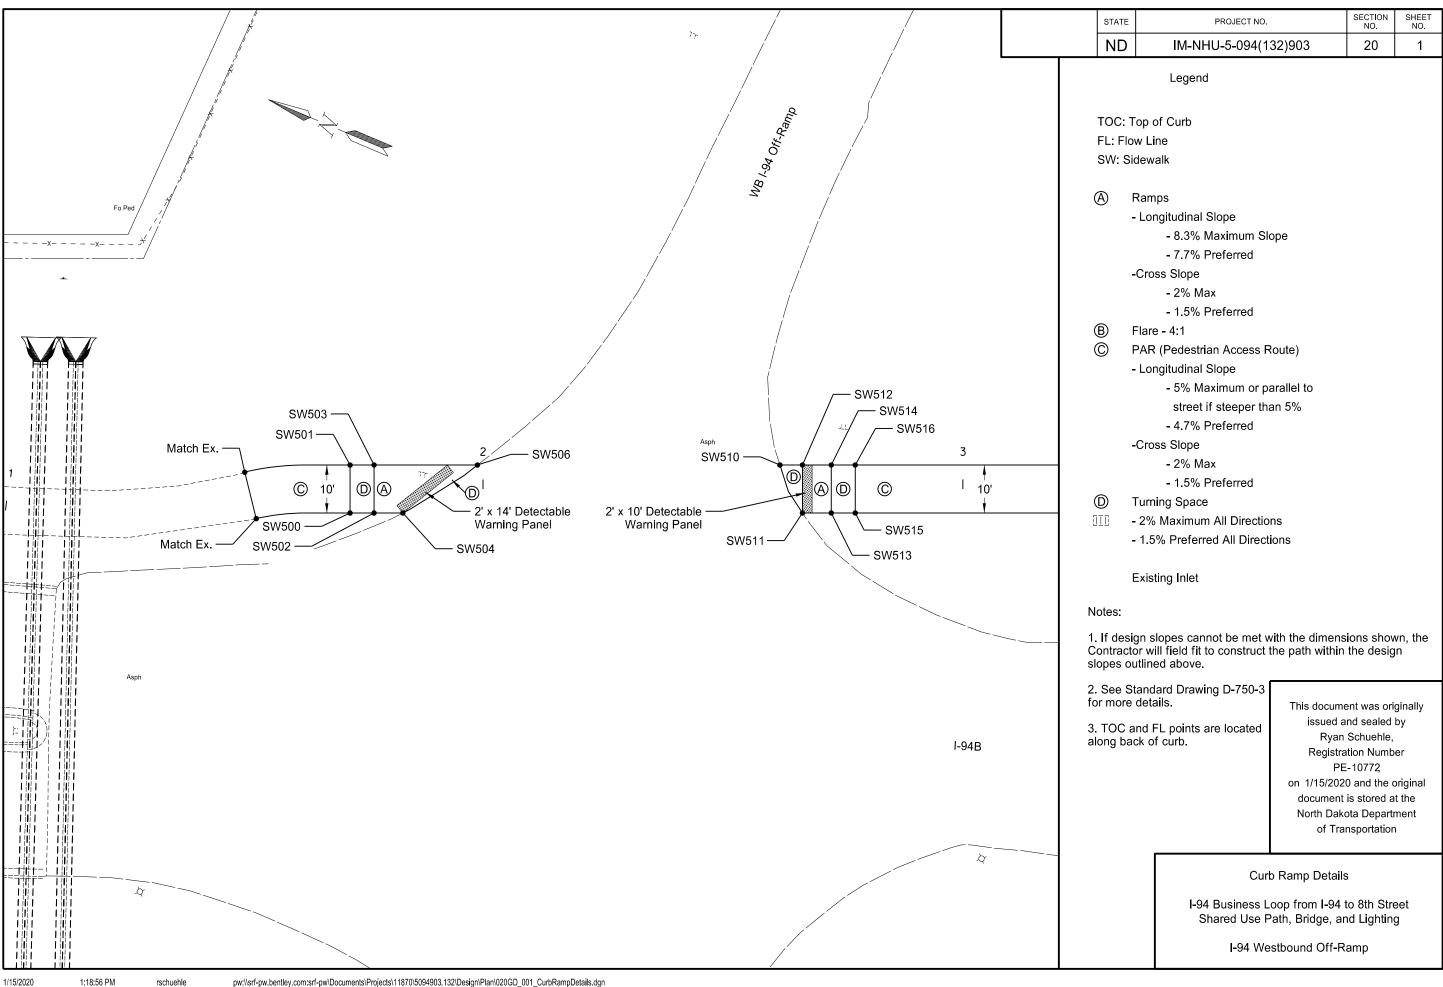

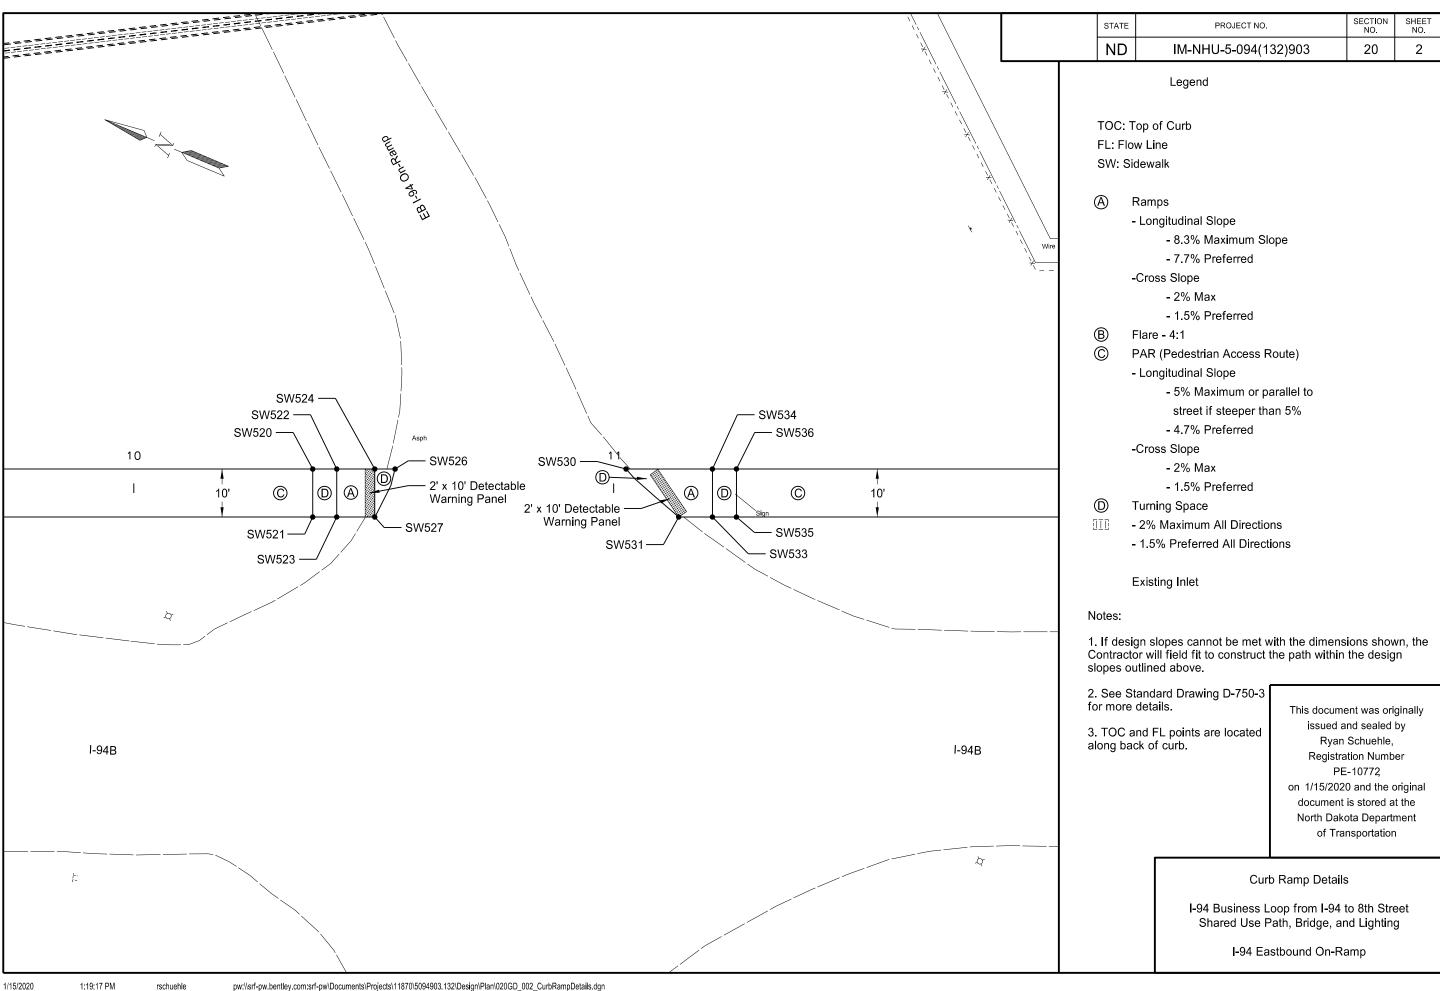

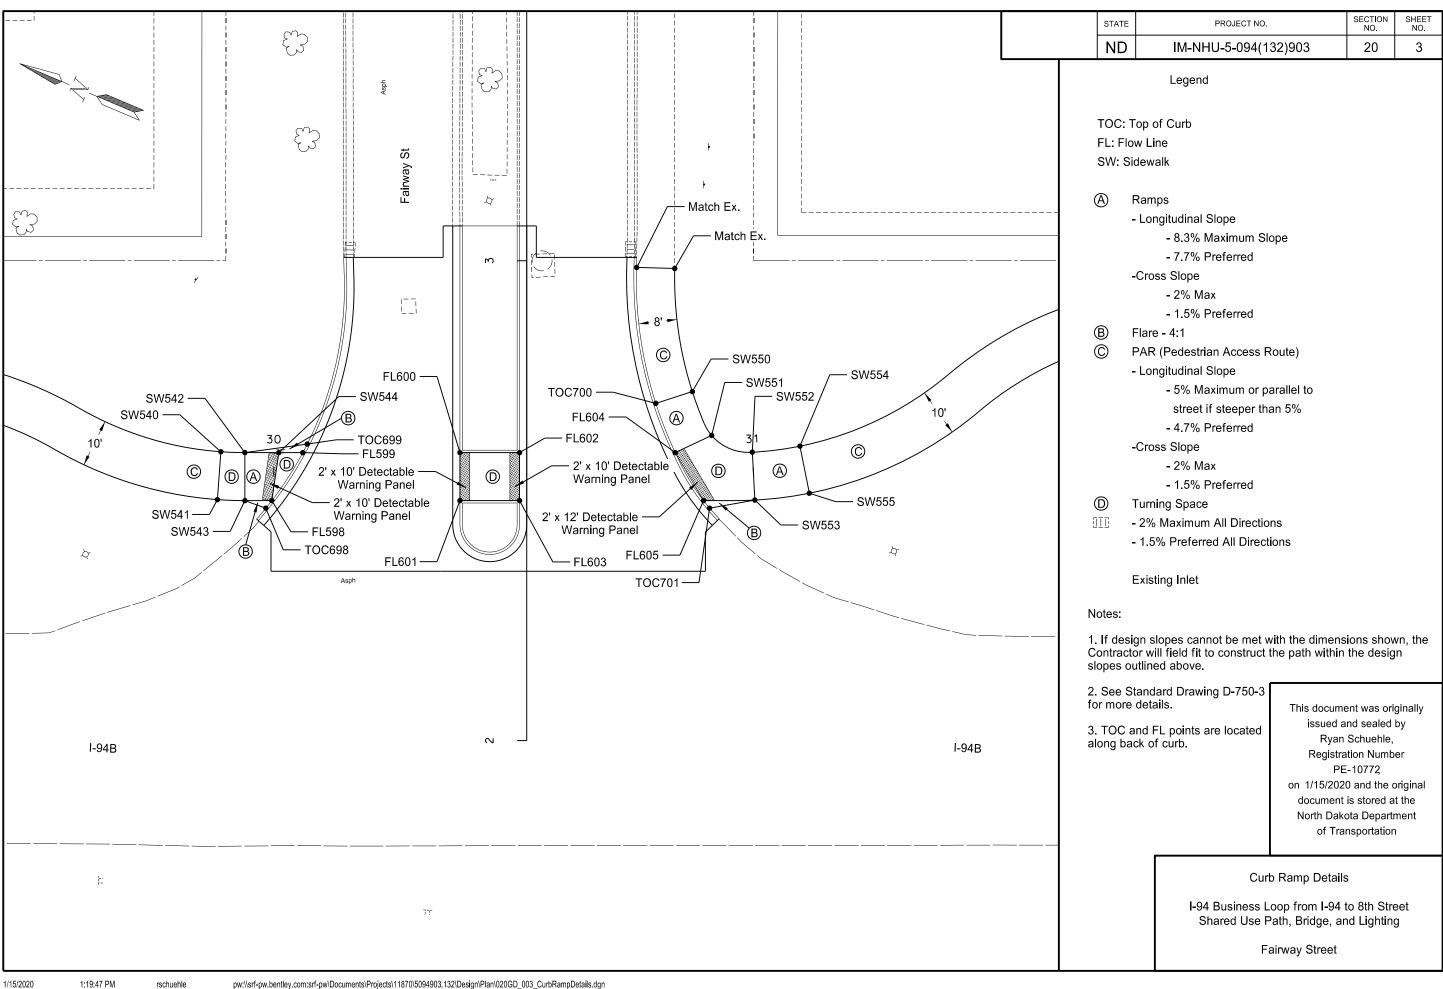

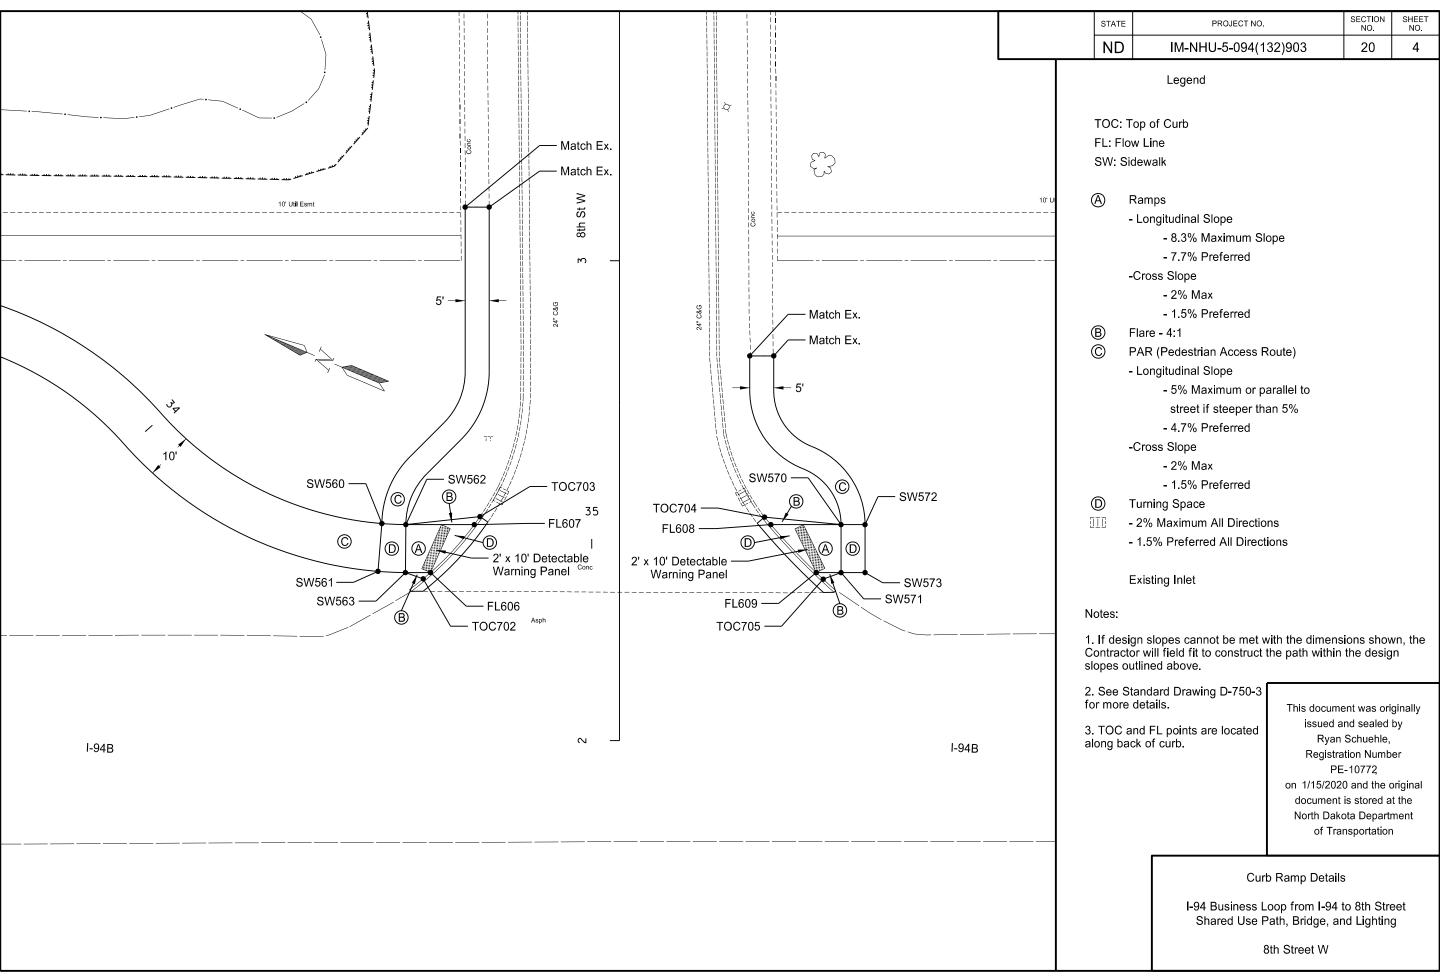

STATE PROJECT NO.		SECTION NO.	SHEET NO.
ND	IM-NHU-5-094(132)903	20	5

	Flow	Line		
Point	Northing	hing Easting		
FL598	453458.00	1387109.49	2456.65	
FL599	453455.95	1387121.22	2456.58	
FL600	453425.80	1387134.01	2457.11	
FL601	453421.90	1387124.80	2457.14	
FL602	453414.36	1387138.86	2457.11	
FL603	453410.45	1387129.66	2457.14	
FL604	453384.49	1387151.54	2456.25	
FL605	453375.17	1387144.62	2456.34	
FL606	453043.36	1387269.06	2456.30	
FL607	453038.86	1387281.83	2456.34	
FL608	452981.96	1387305.97	2456.34	
FL609	452969.35	1387300.45	2456.41	

	0.00	ewalk	
Point	Northing	Easting	Elevation
SW500	456033.91	1386013.67	2479.43
SW501	456037.82	1386022.88	2479.63
SW502	456029.31	1386015.63	2479.43
SW503	456033.21	1386024.83	2479.63
SW504	456023.78	1386017.97	2479.00
SW506	456013.39	1386033.24	2479.24
SW510	455955.35	1386057.86	2479.98
SW511	455947.12	1386050.49	2480.20
SW512	455951.02	1386059.69	2480.07
SW513	455941.59	1386052.83	2480.50
SW514	455945.50	1386062.04	2480.30
SW515	455936.99	1386054.78	2480.50
SW516	455940.90	1386063.99	2480.30
SW520	455250.21	1386356.94	2483.71
SW521	455246.31	1386347.73	2483.91
SW522	455245.61	1386358.89	2483.71
SW523	455241.70	1386349.68	2483.91
SW524	455238.21	1386361.98	2483.36
SW526	455234,41	1386363.64	2483.28
SW527	455234.41	1386352.78	2483.56
SW530	455190.10	1386382.43	2482.72
SW531	455176.10	1386377.51	2482.51
SW533	455169.62	1386380,26	2482.58
SW534	455173.53	1386389.46	2482.78
SW535	455165.02	1386382.21	2482.58
SW536	455168.92	1386391.41	2482.78
SW540	453471.73	1387114.73	2456.90
SW541	453468.50	1387105.26	2456.70
SW542	453467.06	1387116.51	2456.90
SW543	453463.15	1387107.30	2456.70
SW544	453460.55	1387119.27	2456.68
SW550	453386.17	1387164.64	2456.82
SW551	453378.90	1387157.80	2456.41
SW552	453369.75	1387157.89	2456.65
SW553	453365.36	1387148.90	2456.45
SW554	453361.10	1387162.92	2456.65
SW555	453355.46	1387154.66	2456.45
SW560	453056.69	1387274.52	2456.90
SW561	453053.54	1387265.03	2456.70
SW562	453052.00	1387276.26	2456.90
SW563	453048.18	1387267.02	2456.70
SW570	452968.50	1387311.68	2456.70
SW571	452964.60	1387302.47	2456.50
SW572	452963.90	1387313.63	2456.70
SVV3/Z I			


Sidewalk

	Top of Curb								
Point	Northing	Easting	Elevation						
TOC698	453458.52	1387107.57	2456.99						
TOC699	453455.79	1387123.22	2457.05						
TOC700	453392.23	1387159.41	2456.66						
TOC701	453373.39	1387143.68	2456.72						
TOC702	453044.25	1387267.27	2456.84						
TOC703	453038.43	1387283.82	2456.81						
TOC704	452983.80	1387306.90	2456.78						
TOC705	452967.48	1387299.76	2456.85						


Points SW505, SW507-SW509, SW517-SW519, SW525, SW528, SW529, SW532, SW537-SW539, SW545-SW549, SW556-SW559, and SW564-SW569 are not used.

This document was originally issued and sealed by Ryan Schuehle, Registration Number PE-10772 on 1/9/2020 and the original document is stored at the North Dakota Department of Transportation

Curb Ramp Points

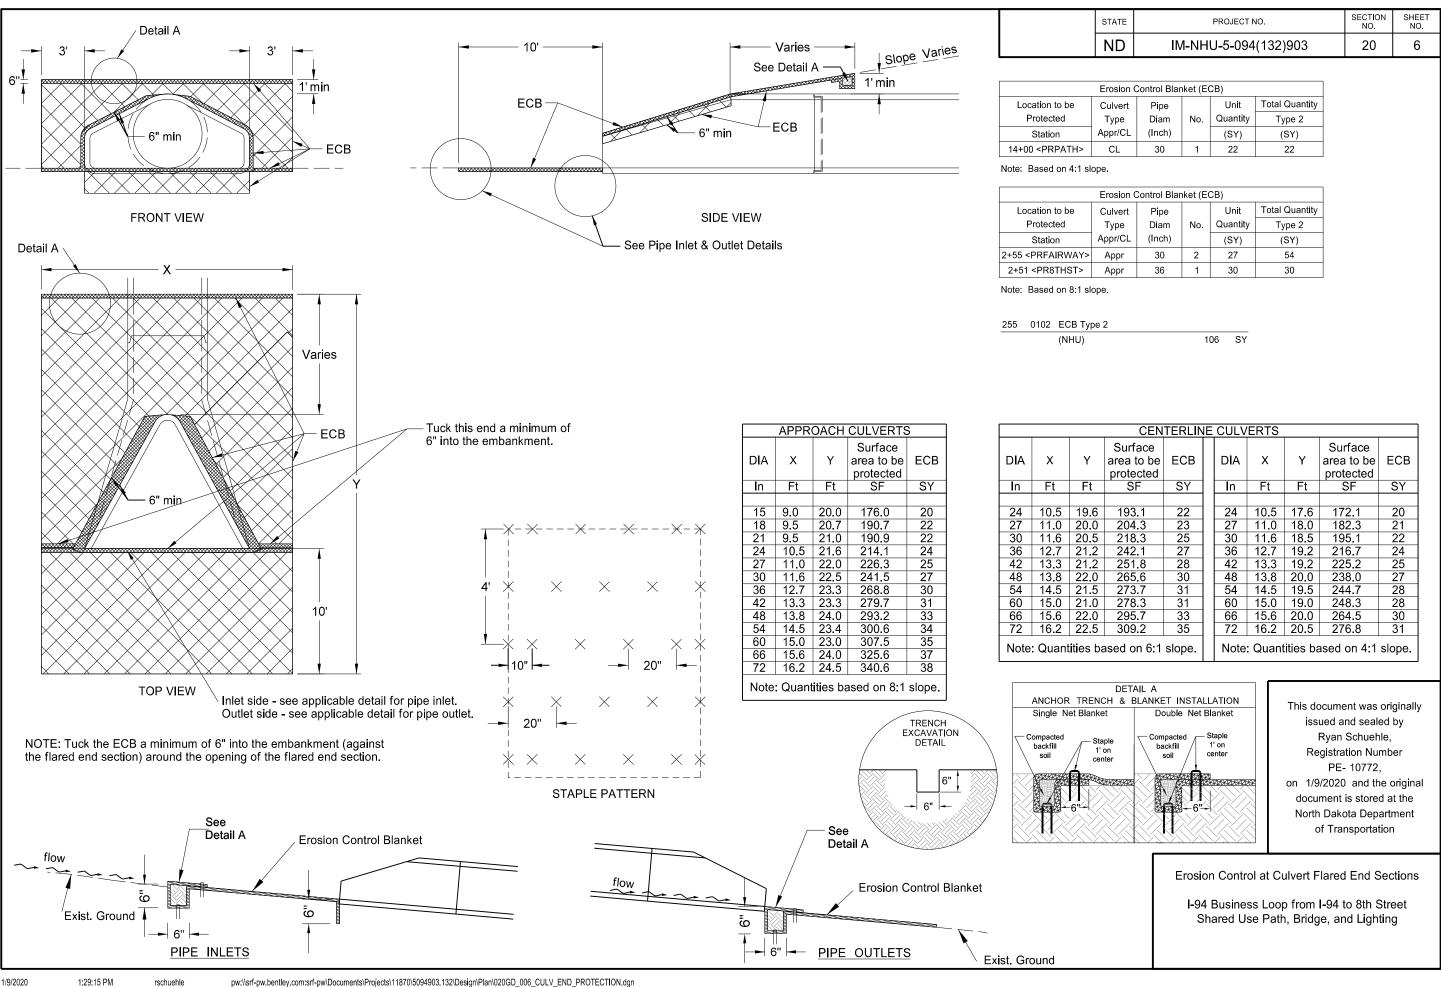

	STATE	PROJECT NO.	SECTION NO.	SHEET NO.
	ND	IM-NHU-5-094(132)903	20	7

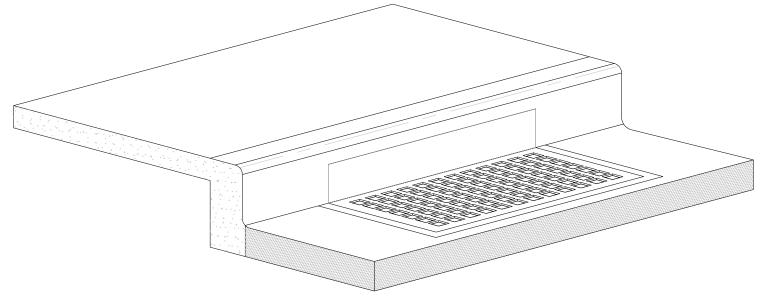


Inlet Protection Device

Installation Notes:

- 1. Place device tightly against drain opening and cover entire grate. Extend the device at least 2 inches past the grate toward the street.
- 2. Overlap the segments at longer openings.
- 3. Anchor the device so that water cannot flow behind it.

General Notes:

1. Remove material that falls into the inlet during maintenance or removal of the device.

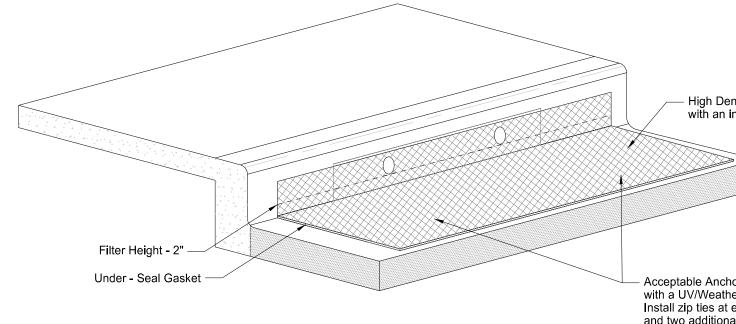

- High Density Polyethylene (HDPE) high flow jacket filter (8,000 opening per SY) with an integrated 425 um (micron meter) fine filter particle mesh


on 1/9/2020 and the original - Acceptable Anchor Method: Fasten to inlet casting grate with a UV/Weather Resistant Plastic Cable Zip Ties - 16 to 24 in. Install zip ties at each corner of the inlet near the perimeter and two additional zip ties near the middle of the casting. document is stored at the North Dakota Department Punch hole through filter and run cable tie downward around grate and back up to fasten.


Inlet Protection Device

This document was originally issued and sealed by Ryan Schuehle, Registration Number

PE-10772


of Transportation

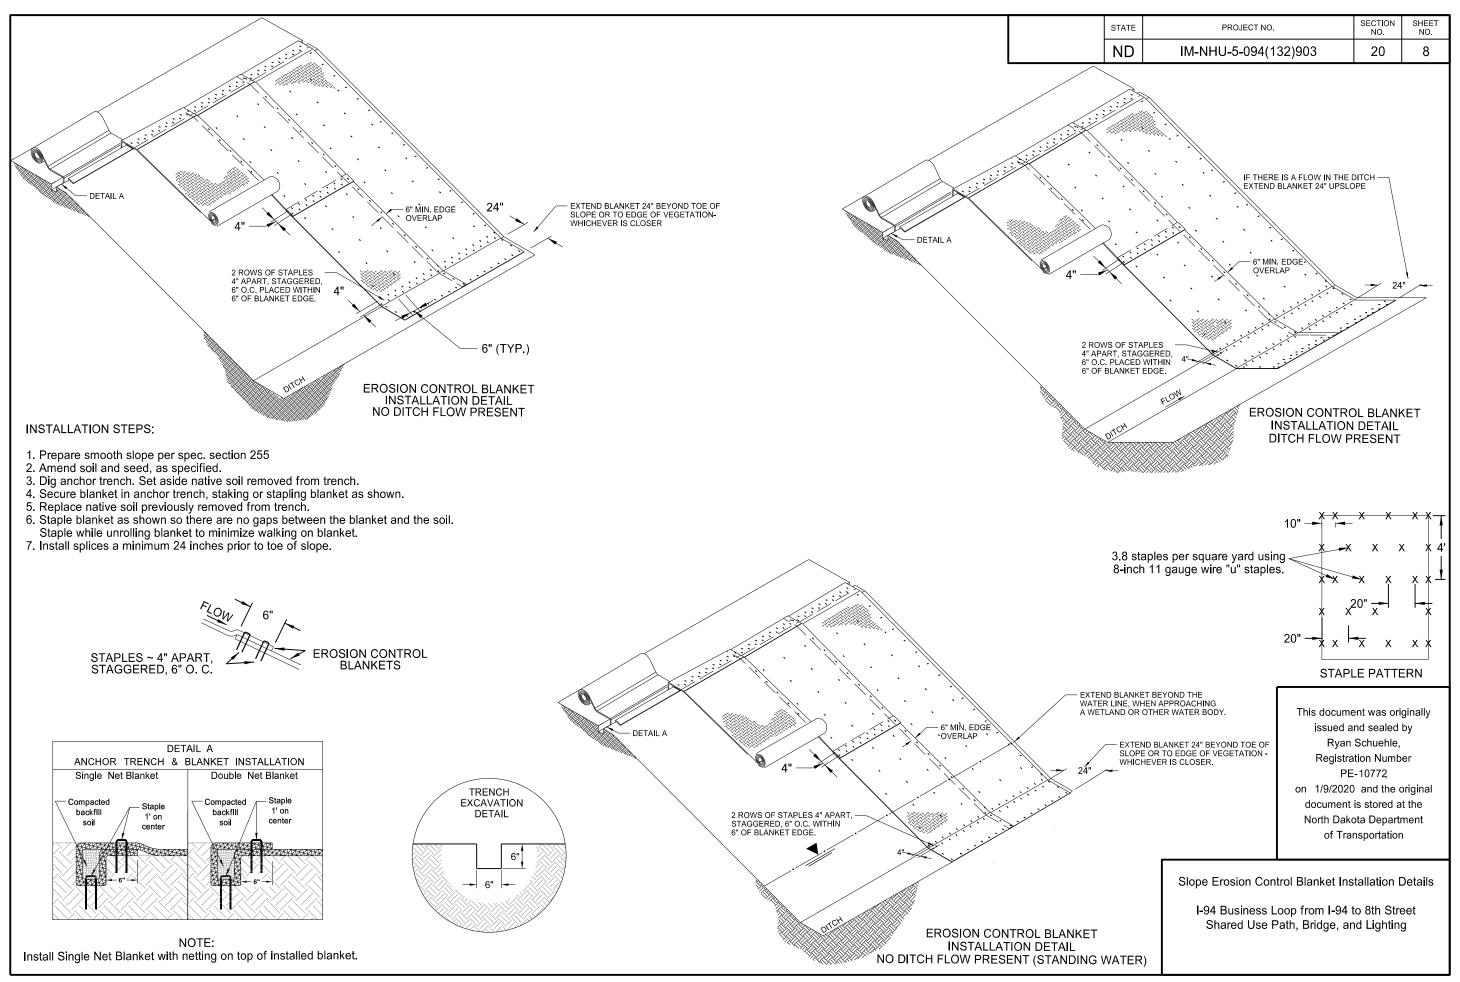

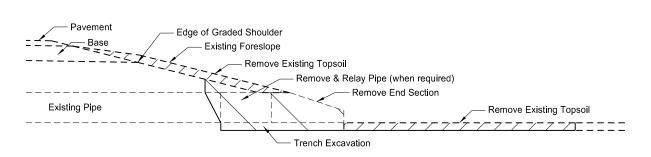


Removal Section

Cross Section View

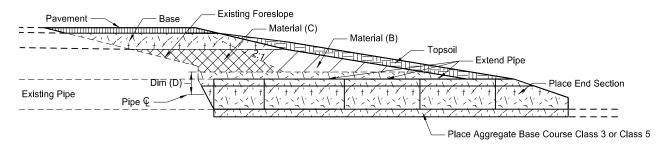



Proposed Section

Cross Section View

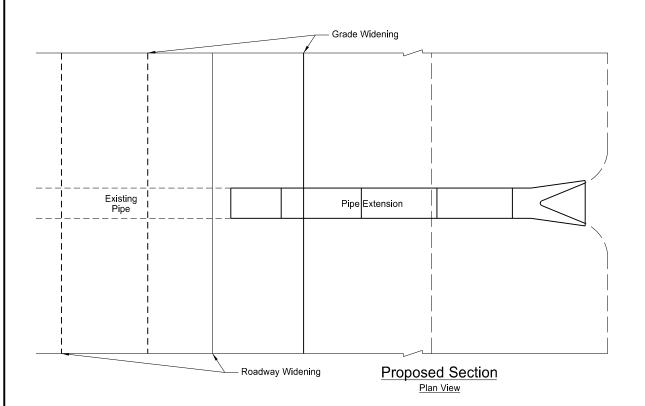



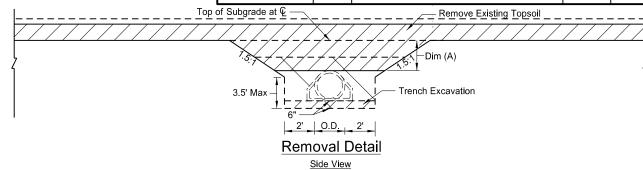

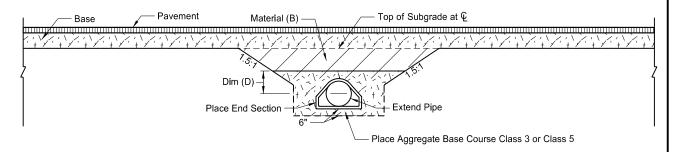

Backfill Detail

Side View (Topsoil not shown)

- 2) Remove & Relay Pipe All Types & Sizes (when required)
 3) Remove & Reset End Section or
 Remove End Section and Place New End Section
- 4) Borrow Excavation or Common Excavation
- 5) Topsoil
- 6) Seeding
- 7) Mulching

- *Included in Pipe Pay Item
 1) Pipe
 2) Trench excavation
 3) Aggregate Base Course Class 3 or Class 5


Dim (A)<=4 Feet Material (B) Material (C) Backfill Dimension Dim (D) Concrete Embank or Aggr Aggregate Embank or Aggr Aggregate

	Dim (A)>4	Backfill Dimension	
Pipe Materials	Material (B)	Material (C)	Dim (D)
Concrete	Embankment	Embankment	0.5 O.D.
Metal	Embankment	Embankment	0.5 O.D.+1 Foot


- NOTES:
 1. Embankment may be either Borrow Excavation or Common Excavation
- 2. Aggregate may be either Class 3 or Class 5 Aggregate Base Course.


This document was originally issued and sealed by Devin S Power, Registration Number PE-28149, on 1/9/2020 and the original document is stored at the North Dakota Department of Transportation


Mainline Widening CL Pipe Extension Detail

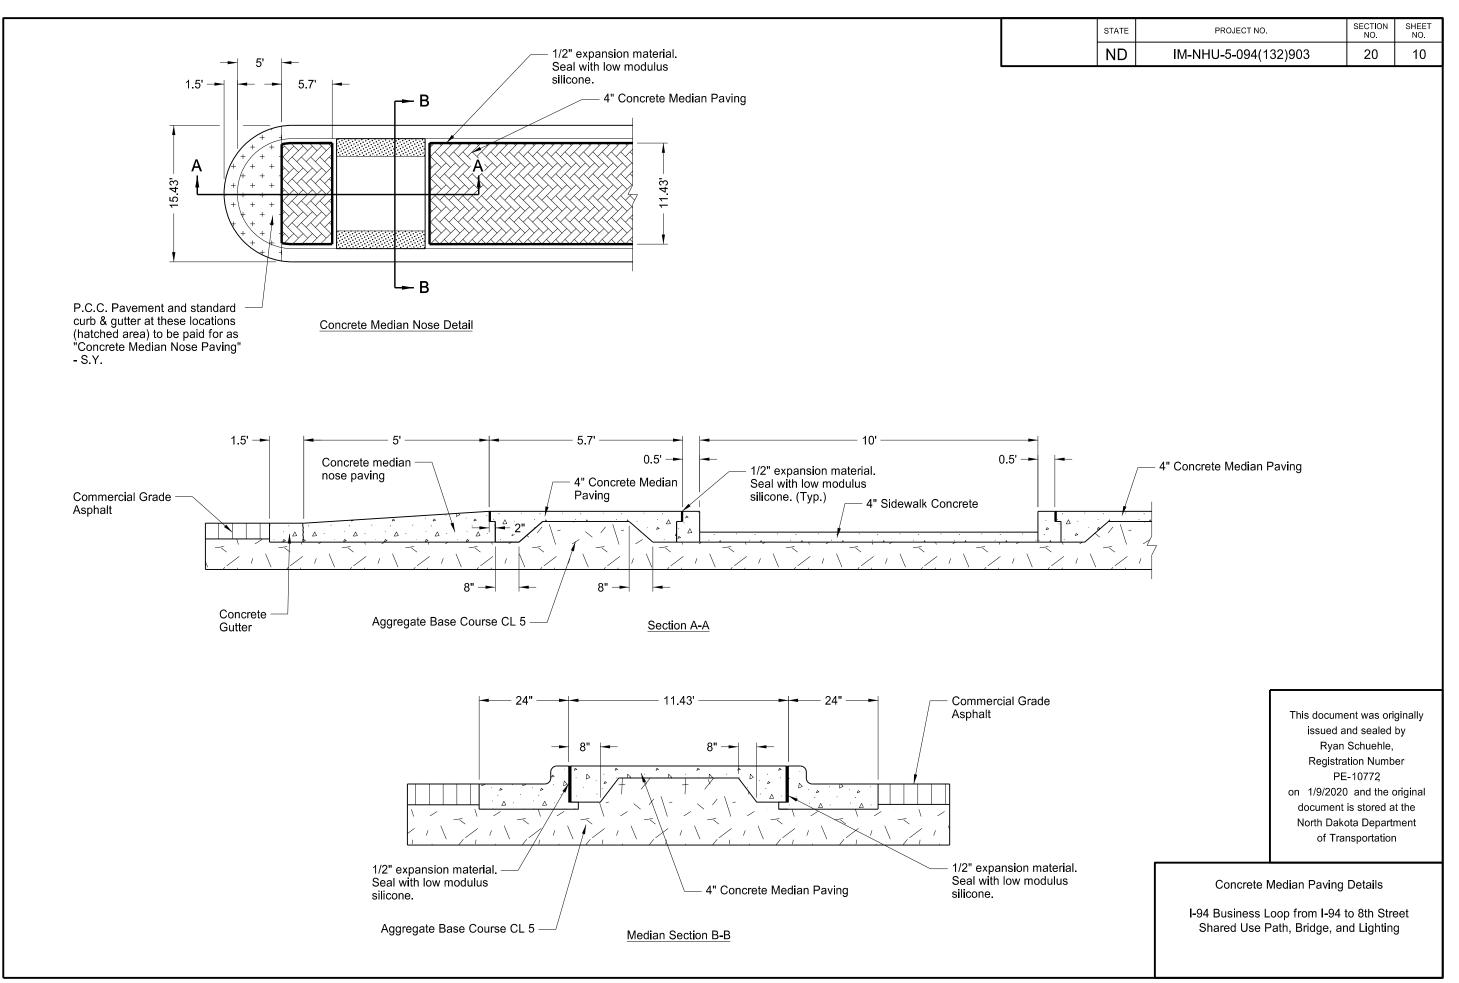



1:29:45 PM

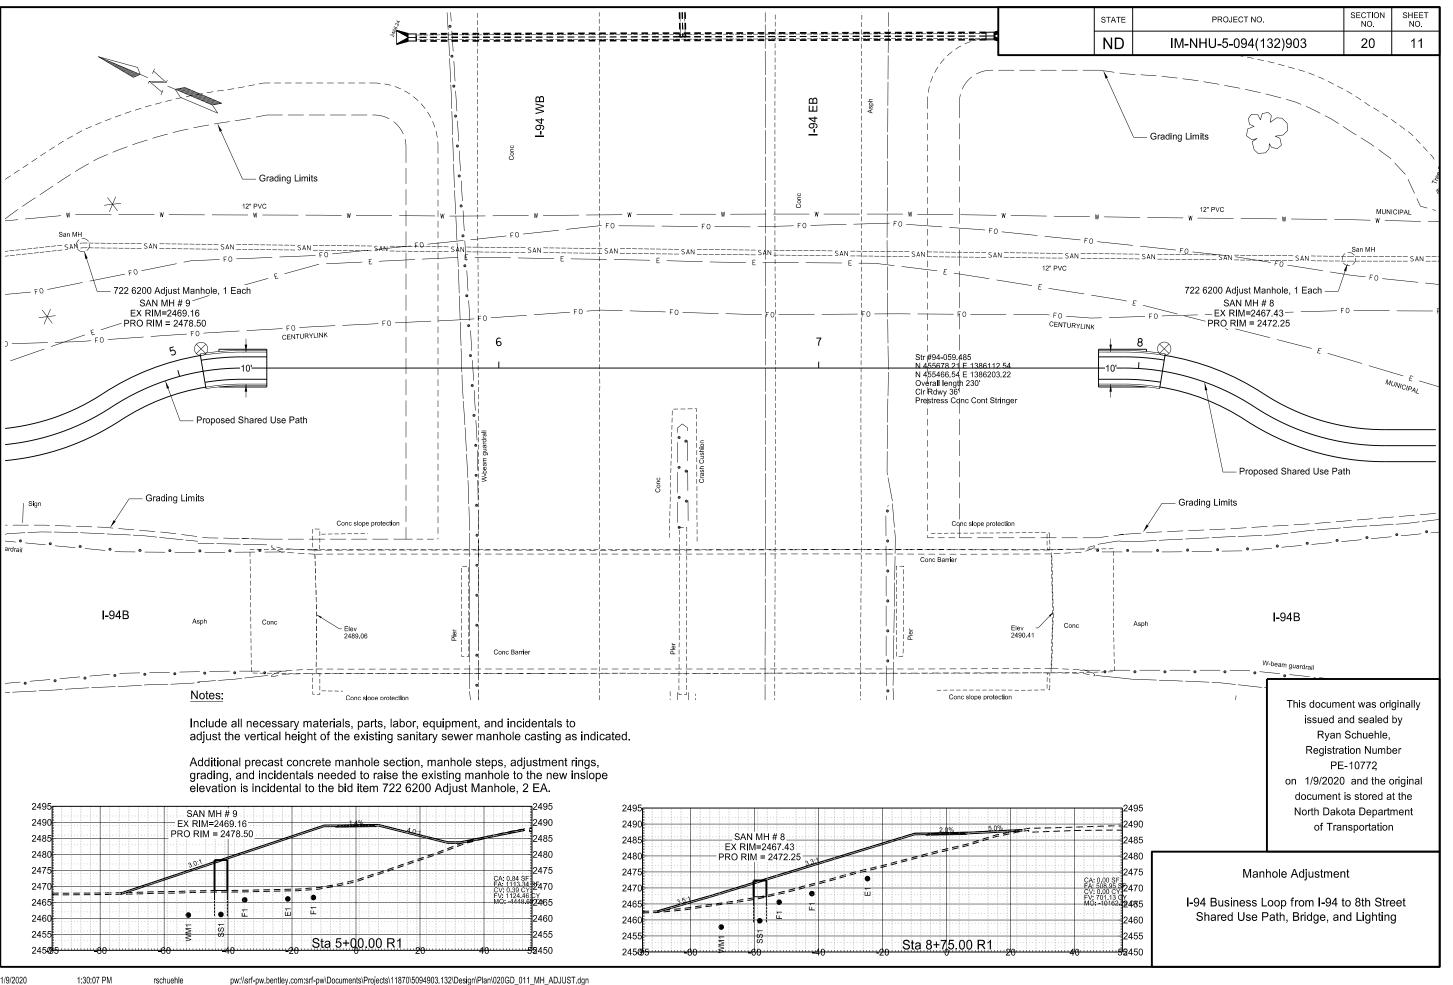

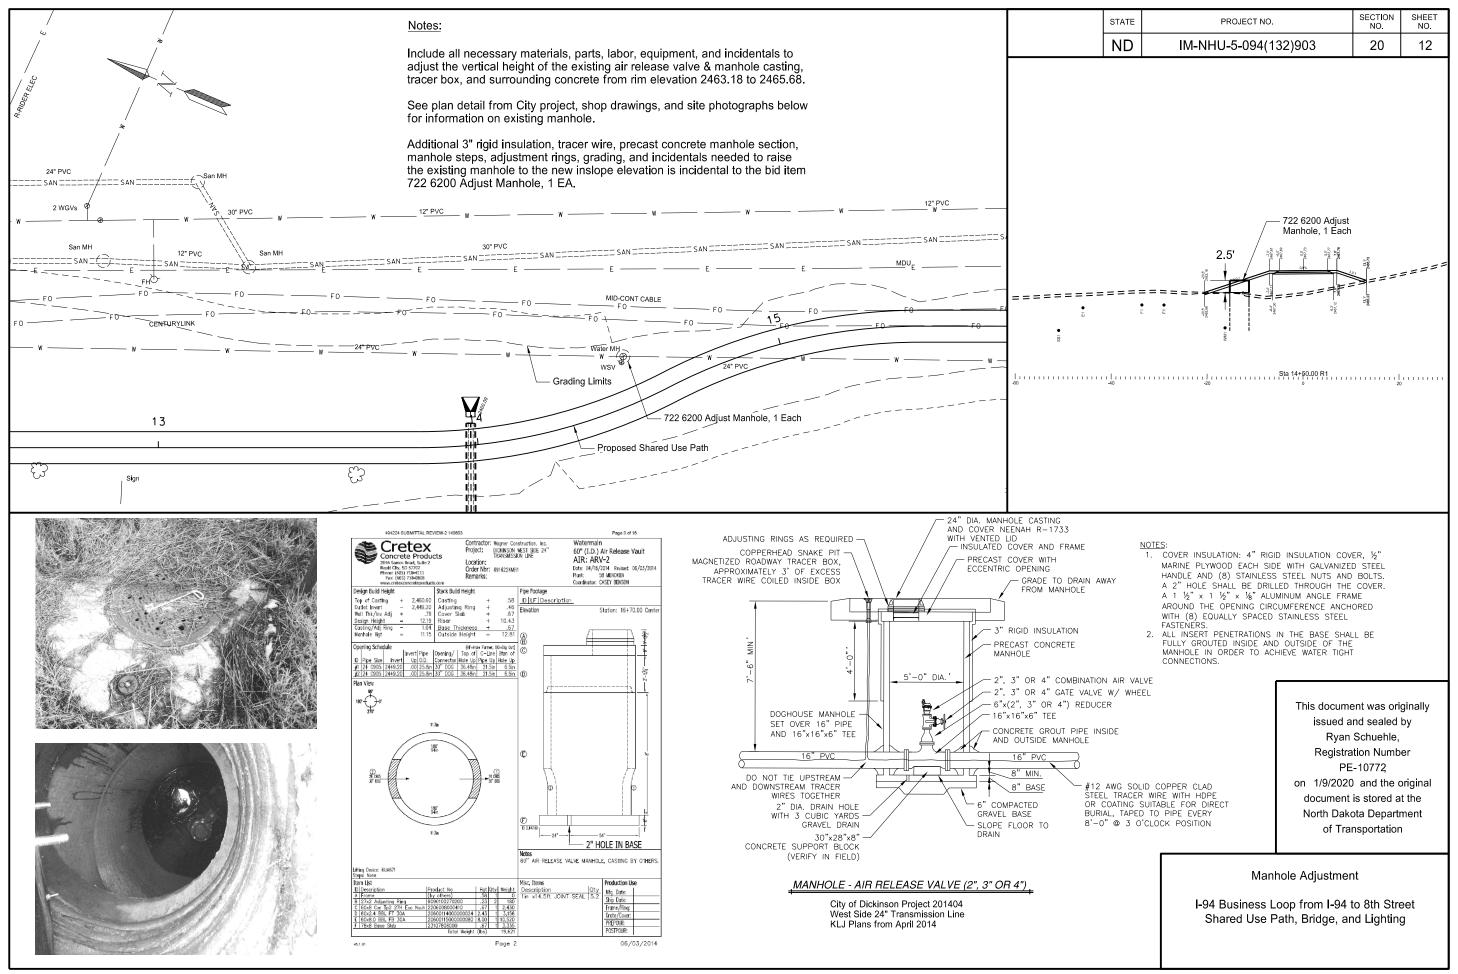

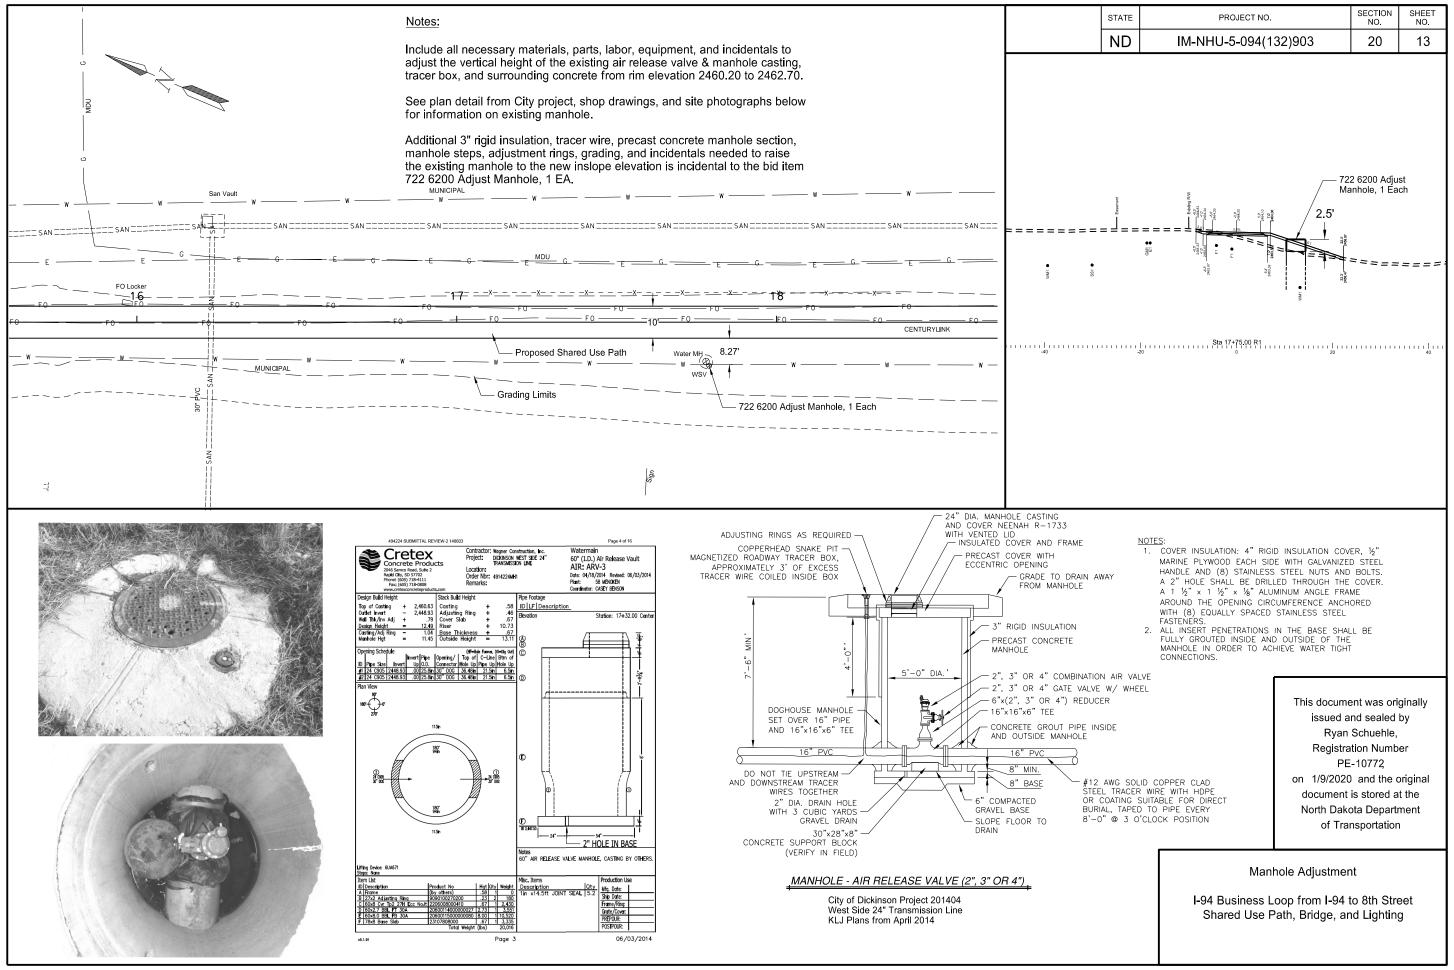

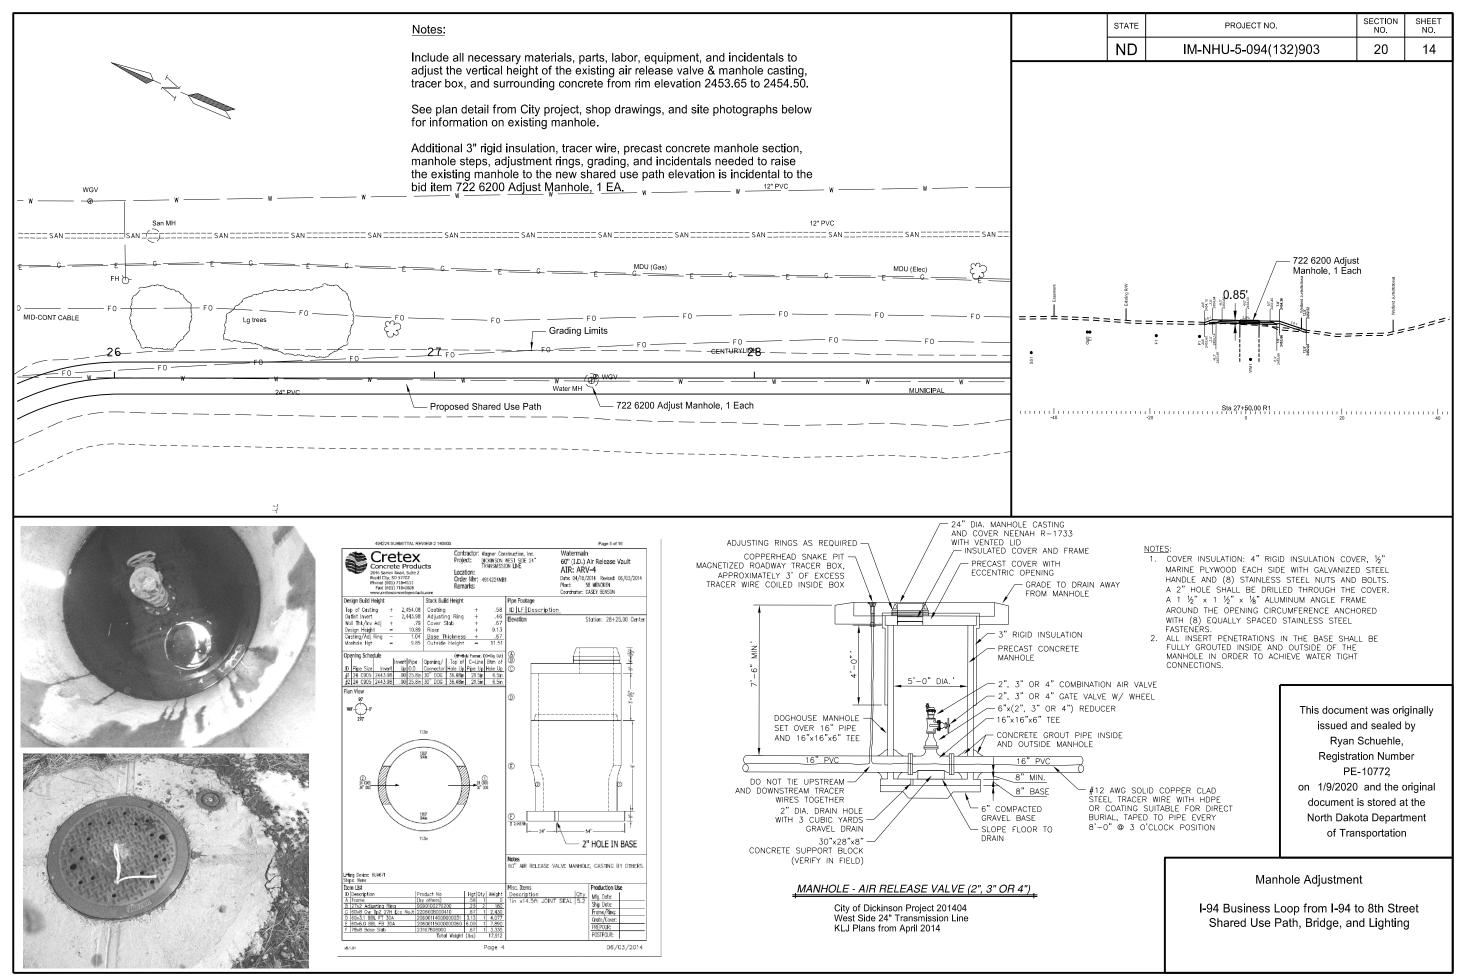

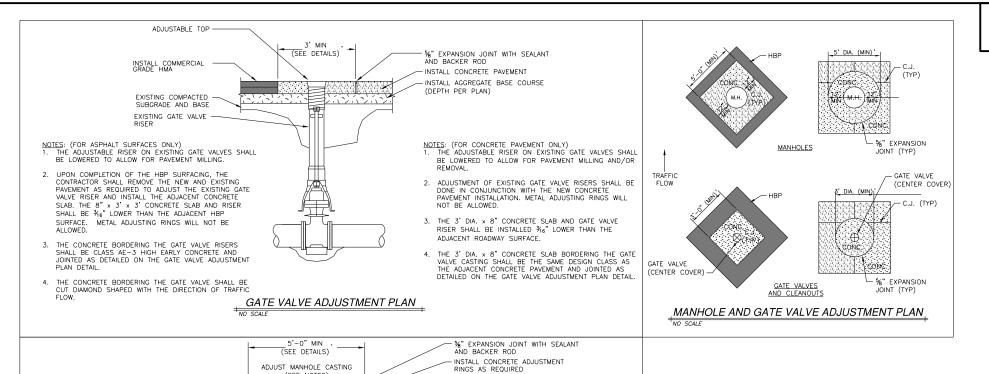

- INSTALL CONCRETE PAVEMENT - INSTALL AGGREGATE BASE COURSE

	- Ctation		· anamg					Elevation	Elevation		
	Station	Offset	Funding		Featu	ıre		Existing	Proposed		
				NO SCALE				<u> </u>			
			ON OF TRAFFIC FLOW	٧.	HOLE ADJI	JSTMENT PL	AN				
			MENT PLAN DETAIL. NHOLE SHALL BE CU	т.				ADJACENT CONCR	ETE PAVEMENT AN		
BE	CLASS AE-3 HIG	GH EARLY CONCR	NHOLE CASTING SHALE ETE AND JOINTED AS				5.		DNCRETE SLAB BOR	RDERING THE MANHOL	-E
	ALL BE INSTALLET P SURFACE.	J ≯ ₁₆ LOWER IH.	AN THE ADJACENT					WITH COVER SHA ADJACENT ROADW		36" LOWER THAN THE	<u> </u>
			CASTING WITH COVE	R			4.			MANHOLE CASTING	
OF ALL	3 RINGS). META	IG RINGS AND/OF L ADJUSTING RINI SHIMS ARE ALL						(MAXIMUM OF 3 DONE IN CONJUN	RINGS). THIS ADJU ICTION WITH THE N LATION. METAL ADJ	ISTMENT SHALL BE	
		SHALL BE ADJUS		Т	AND COV		3.		G AND COVER SHA ADJUSTING RINGS	LL BE ADJUSTED BY	
COL	NTRACTOR SHALL /EMENT AS REQU	REMOVE THE NE IRED TO REINSTA	W AND EXISTING	т	EXISTING MA	NHOLE	2.	INSTALL NEW MAI		ID COVER SPECIFIED	
REM MIL	MOVED AND SALV LING.	OLE CASTING ANI AGED TO ALLOW OF THE HBP SUI	FOR PAVEMENT					THE EXISTING MA	ALVAGED TO ALLOW	ND COVER SHALL BE	
	(FOR ASPHALT	SURFACES ONLY)	D COVER SHALL BE		\				`	,	
		DE AND BASE				\ _			CHIMNEY SEAL FO T AREAS (SEE DET		
	EVICTING	COMPACTED -	_						0	. 5	

(SEE NOTES)

Station	Offset	Funding	Feature	Existing	Proposed	Nature of Work
				Elevation	Elevation	
4+89	49' LT	IM	Sanitary Sewer Manhole	2469.16	2478.50	See detail sheet 20-11. Pay item 722 6200 Adjust Manhole, 1 EA.
8+38	55' LT	IM	Sanitary Sewer Manhole	2467.43	2472.25	See detail sheet 20-11. Pay item 722 6200 Adjust Manhole, 1 EA.
11+78	37' LT	IM	Watermain Cata Valva	2467.23	2469,50	Raise gate valve height by screwing up riser box stem. Valve is in grading area, no concrete pavement
11+76	37 L1	IIVI	Watermain Gate Valve	2407.23	2469.50	surrounding box. Pay item 722 6140 Adjust Gate Valve Box, 1 EA.
14+53	15' LT	NHU	Watermain Air Release Manhole	2463.18	2465.68	See detail sheet 20-12. Pay item 722 6200 Adjust Manhole, 1 EA.
17+78	12' RT	NHU	Watermain Air Release Manhole	2460.20	2462.70	See detail sheet 20-13. Pay item 722 6200 Adjust Manhole, 1 EA.
27+49	0' RT	NHU	Watermain Air Release Manhole	2453.65	2454.50	See detail sheet 20-14. Pay item 722 6200 Adjust Manhole, 1 EA.
29+67	20' LT	NHU	Watermain Gate Valve	2453.30	2454.50	Raise gate valve height by screwing up riser box stem. Valve is in grading area, no concrete pavement
29+07	20 L1	NHO	waternain Gate valve	2455.50	2434.30	surrounding box. Pay item 722 6140 Adjust Gate Valve Box, 1 EA.
30+28	35' LT	NHU	Watermain Gate Valve	2456.37	2456.72	Raise gate valve height by screwing up riser box stem, pour new concrete collar and surrounding pavement per
30+20	35 L1	NHU	watermain Gate valve	2456.57	2430.72	detail above. Pay item 722 6140 Adjust Gate Valve Box, 1 EA.
30+56	45' LT	NHU	Storm Sewer Manhole	2456.60	2456.80	Raise manhole casting elevation by adding an adjustment ring. Pour new concrete collar and surrounding
30+36	45 L1	NHU	Storm Sewer Mannole	2456.60	2456.60	pavement per detail above. Pay item 722 6200 Adjust Manhole, 1 EA.
30+56	0' LT	NHU	Storm Sewer Manhole	N/A	2456,50	New manhole, see section 60 Pay item 722 0107 Manhole 54IN, 1 EA. Adjustment is incidental to pay item.
55150		14110	Storm Cower Marinole	14/74	2400,00	The manner, see seemen see a green 122 of the manner of the first the first to pay tent.

This document was originally issued and sealed by Ryan Schuehle, Registration Number PE-10772 on 1/9/2020 and the original document is stored at the North Dakota Department of Transportation

SECTION NO.

20

STATE

ND

PROJECT NO.

IM-NHU-5-094(132)903

SHEET NO.

15


Manhole and Gate Valve Adjustment

I-94 Business Loop from I-94 to 8th Street Shared Use Path, Bridge, and Lighting

INSTALL COMMERCIAL GRADE HMA

	STATE	PROJECT NO.	SECTION NO.	SHEET NO.
	ND	IM-NHU-5-094(132)903	20	16

A quantity of 40 LF of IM funded and 80 LF of NHU funded Fiber Roll 12IN amd Remove Fiber Roll 12IN has been included in the quantities for use at weirs. The Engineer will measure the actual quantity required in the field.

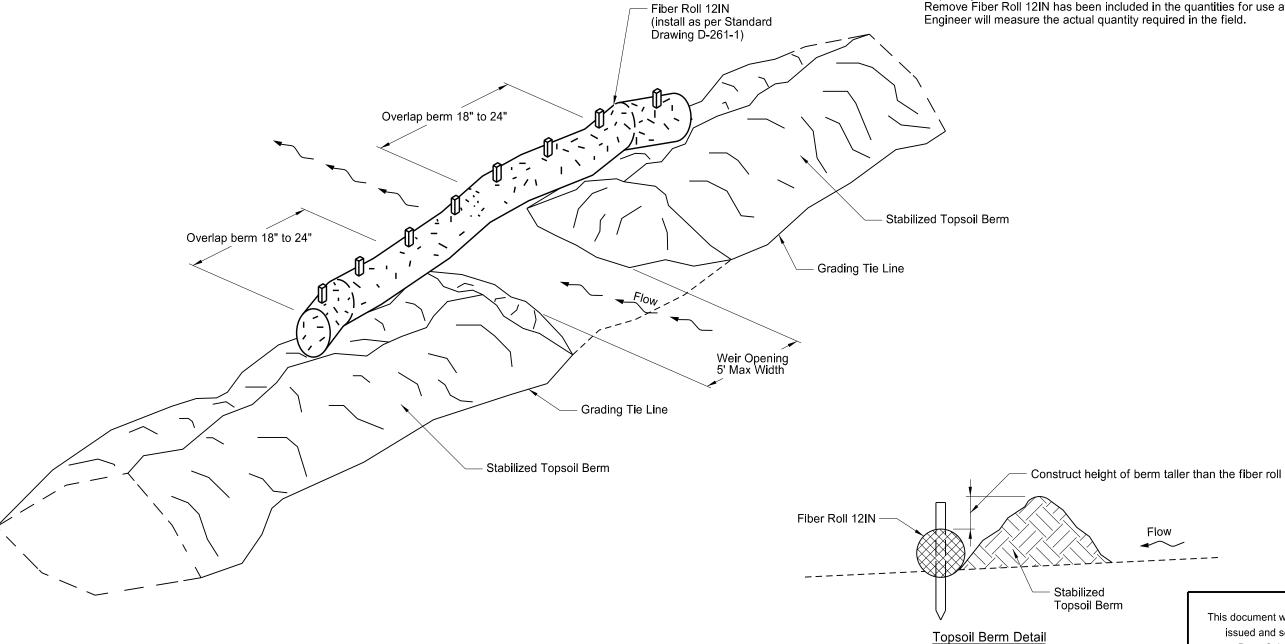

Notes:

- Windrow the existing topsoil from the foreslope to create a berm at the grading tie line. Stabilize berms in accordance with the Construction General Permit.

 Place weirs intermittently throughout the length of the berm to allow stormwater to drain through the berm. Avoid placing weirs adjacent to waterbodies.
- 5.
- Install fiber rolls as the weirs are created in the topsoil berm.


 Include costs to create, stabilize, maintain, and dismantle the berm in the unit price bid for "Topsoil". 6.
- Include costs for fiber rolls in the unit price bid for "Fiber Rolls 12IN".

This document was originally issued and sealed by Ryan Schuehle, Registration Number PE-10772 on 1/9/2020 and the original document is stored at the North Dakota Department of Transportation


Temporary Topsoil Berm and Weir Detail

STATE	PROJECT NO.	SECTION NO.	SHEET NO.
ND	IM-NHU-5-094(132)903	20	17

Settlement Plate Plan View

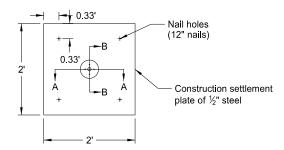

Section A-A

 


with a minimum of three 1/4" x 11/2" bolts


Section B-B (Not to scale)

Threaded to take Min. of three a 1" Pipe Standard black 3/4" floor flange

Settlement Plate Installation

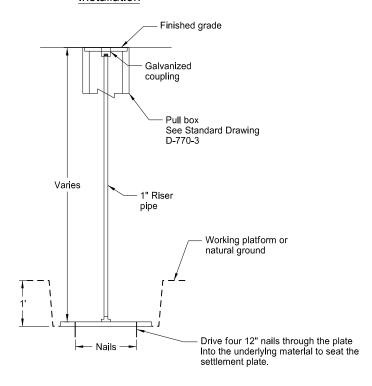

Riser Pipe & Coupling

 


Notes:

- Notify the Engineer prior to settlement plate installation.
- Install the settlement plate at Sta 5+08, 7' Lt and Sta 8+07, 7' Lt
- Install settlement plate on a smooth and level surface and prior to the addition of any fill material.
- Install settlement plate in position and extend pipes in sections as the embankment is placed. Notify the Engineer when the pipe is to be extended. Submit a date and exact length of pipe added each time the pipe is extended.
- Install pull box flush with proposed ground.
- Maintain settlement plate and pull box until project completion. Any damage to the plate will be repaired/replaced at Contractor's expense.
- Include all costs associated with installing/maintaining settlement plate and pull box in the price bid for "Settlement Plate".

This document was originally issued and sealed by Jared J. Loegering, Registration Number PE- 10931, on 01/07/2020 and the original document is stored at the North Dakota Department of Transportation

Settlement Plate Detail

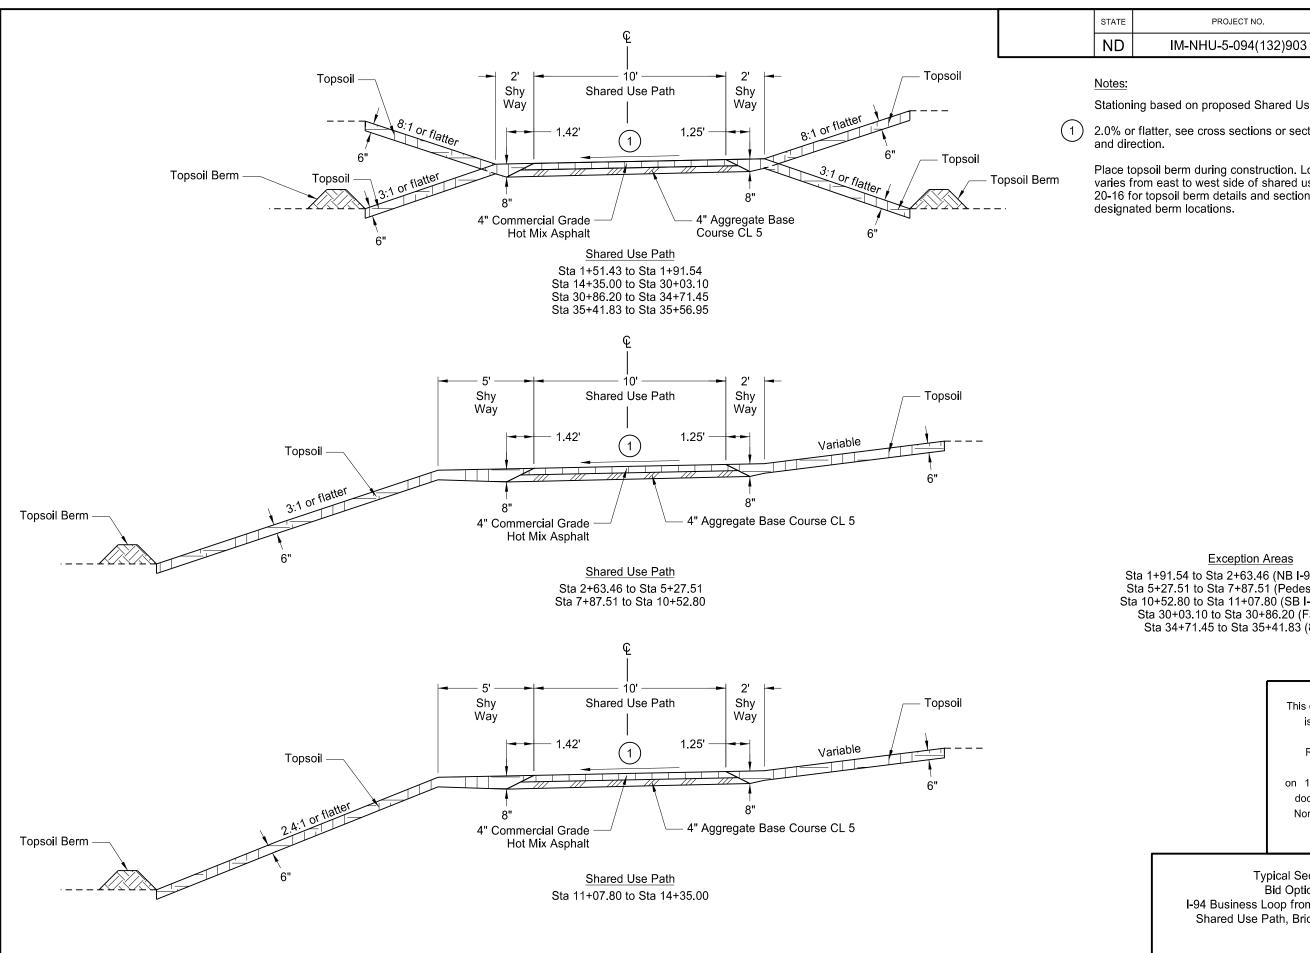

Stationing based on proposed Shared Use Path alignment.

SHEET NO.

1

SECTION NO.

30

2.0% or flatter, see cross sections or section 80 for cross slope


Place topsoil berm during construction. Location of topsoil berm varies from east to west side of shared use path. See sheet 20-16 for topsoil berm details and sections 75, 76, and 77 for designated berm locations.

Exception Areas

Sta 1+91.54 to Sta 2+63.46 (NB I-94 Off-Ramp) Sta 5+27.51 to Sta 7+87.51 (Pedestrian Bridge) Sta 10+52.80 to Sta 11+07.80 (SB I-94 On-Ramp) Sta 30+03.10 to Sta 30+86.20 (Fairview St) Sta 34+71.45 to Sta 35+41.83 (8th St W)

> This document was originally issued and sealed by Ryan Schuehle, Registration Number PE- 10772, on 1/9/2020 and the original document is stored at the North Dakota Department of Transportation

Typical Sections Bid Option 1 I-94 Business Loop from I-94 to 8th Street Shared Use Path, Bridge, and Lighting

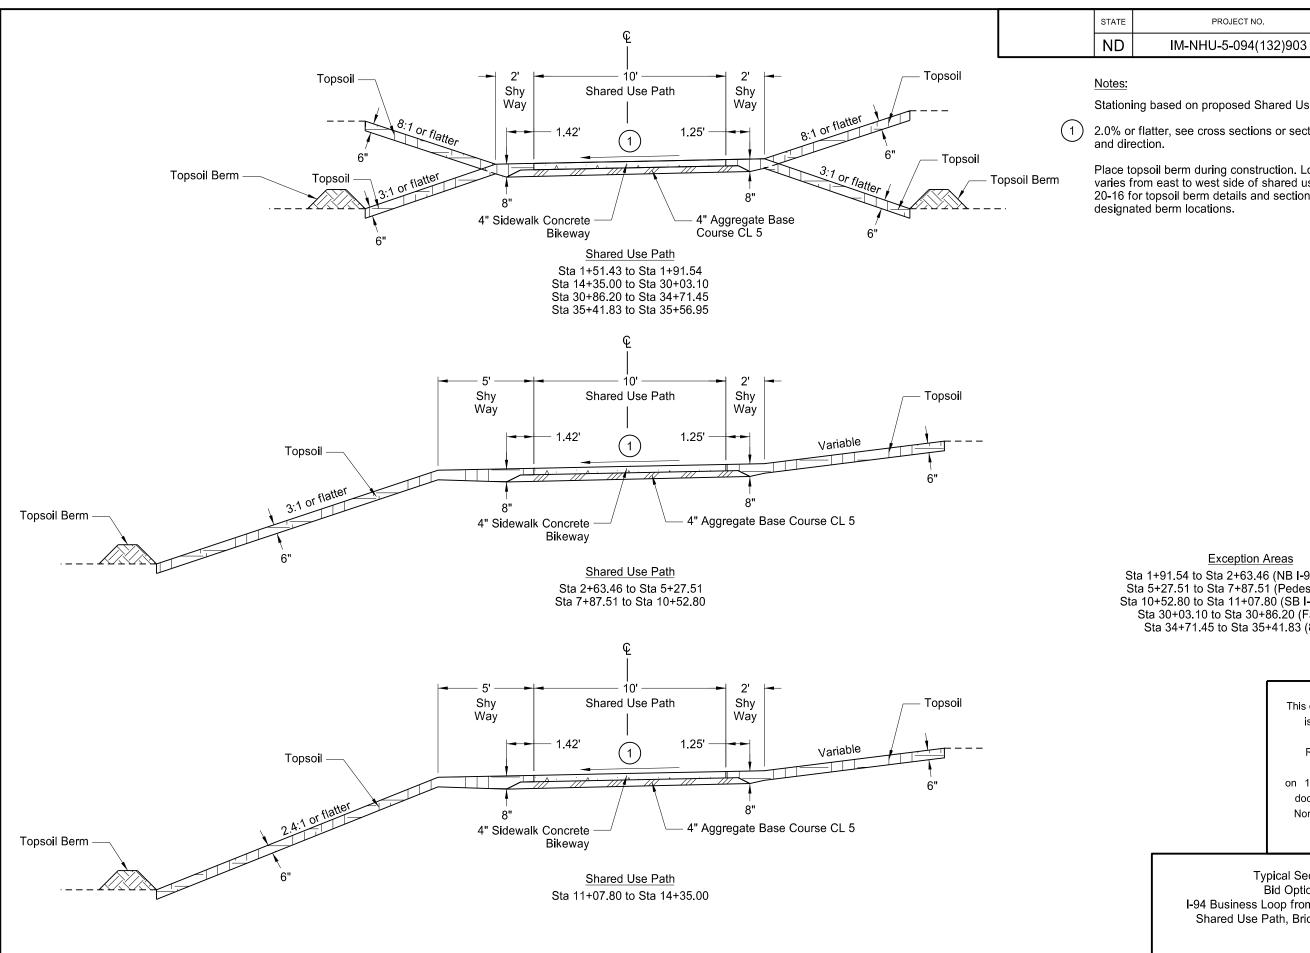

Stationing based on proposed Shared Use Path alignment.

SHEET NO.

2

SECTION NO.

30

2.0% or flatter, see cross sections or section 80 for cross slope

Place topsoil berm during construction. Location of topsoil berm varies from east to west side of shared use path. See sheet 20-16 for topsoil berm details and sections 75, 76, and 77 for designated berm locations.

Exception Areas

Sta 1+91.54 to Sta 2+63.46 (NB I-94 Off-Ramp) Sta 5+27.51 to Sta 7+87.51 (Pedestrian Bridge) Sta 10+52.80 to Sta 11+07.80 (SB I-94 On-Ramp) Sta 30+03.10 to Sta 30+86.20 (Fairview St) Sta 34+71.45 to Sta 35+41.83 (8th St W)

> This document was originally issued and sealed by Ryan Schuehle, Registration Number PE- 10772, on 1/9/2020 and the original document is stored at the North Dakota Department of Transportation


Typical Sections Bid Option 2 I-94 Business Loop from I-94 to 8th Street Shared Use Path, Bridge, and Lighting

STATE	PROJECT NO.	SECTION NO.	SHEET NO.	
ND	IM-NHU-5-094(132)903	30	3	


Notes:

Stationing based on proposed Fairway St alignment.

- 2.0% or flatter, see cross sections or section 80 for cross slope and direction.
- 8' sidewalk includes 2' of "concrete median paving" along the back of curb and 6' of sidewalk.

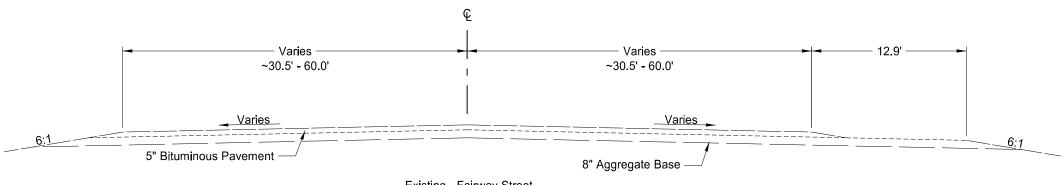

Existing - Fairway Street Sta 2+35.28 to Sta 3+07.24

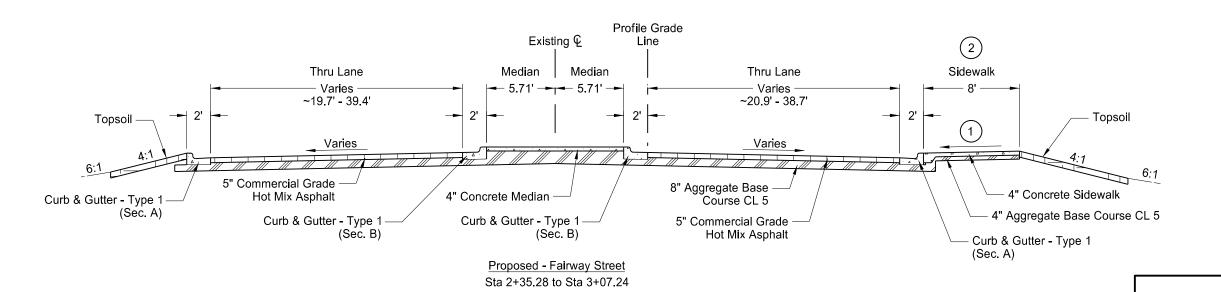



This document was originally issued and sealed by Ryan Schuehle, Registration Number PE- 10772, on 1/9/2020 and the original document is stored at the North Dakota Department of Transportation


Typical Sections

I-94 Business Loop from I-94 to 8th Street Shared Use Path, Bridge, and Lighting

1/9/2020

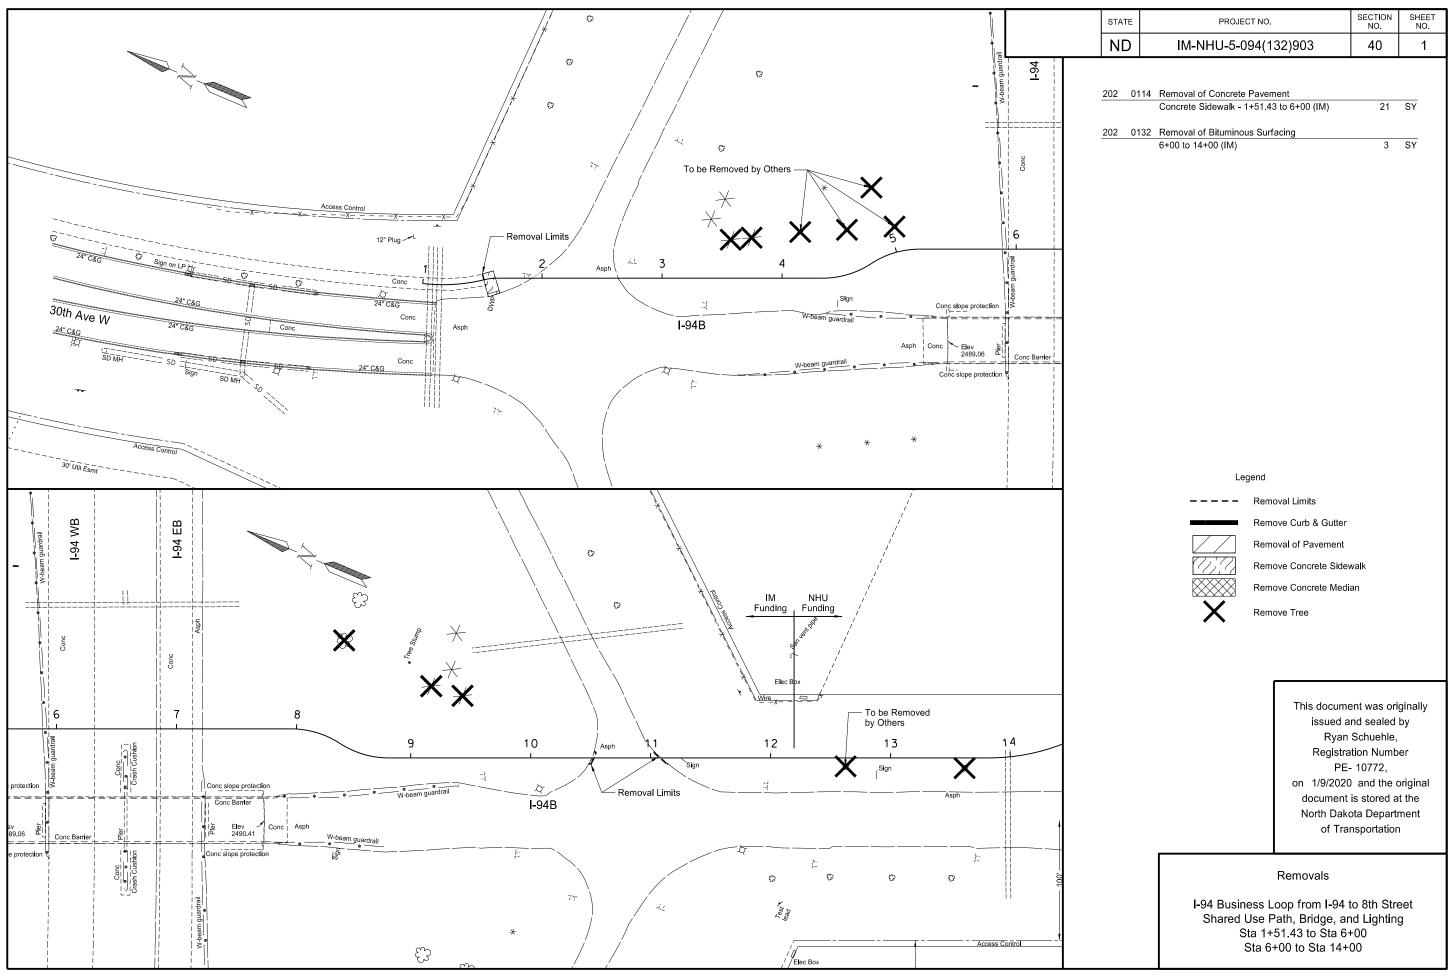

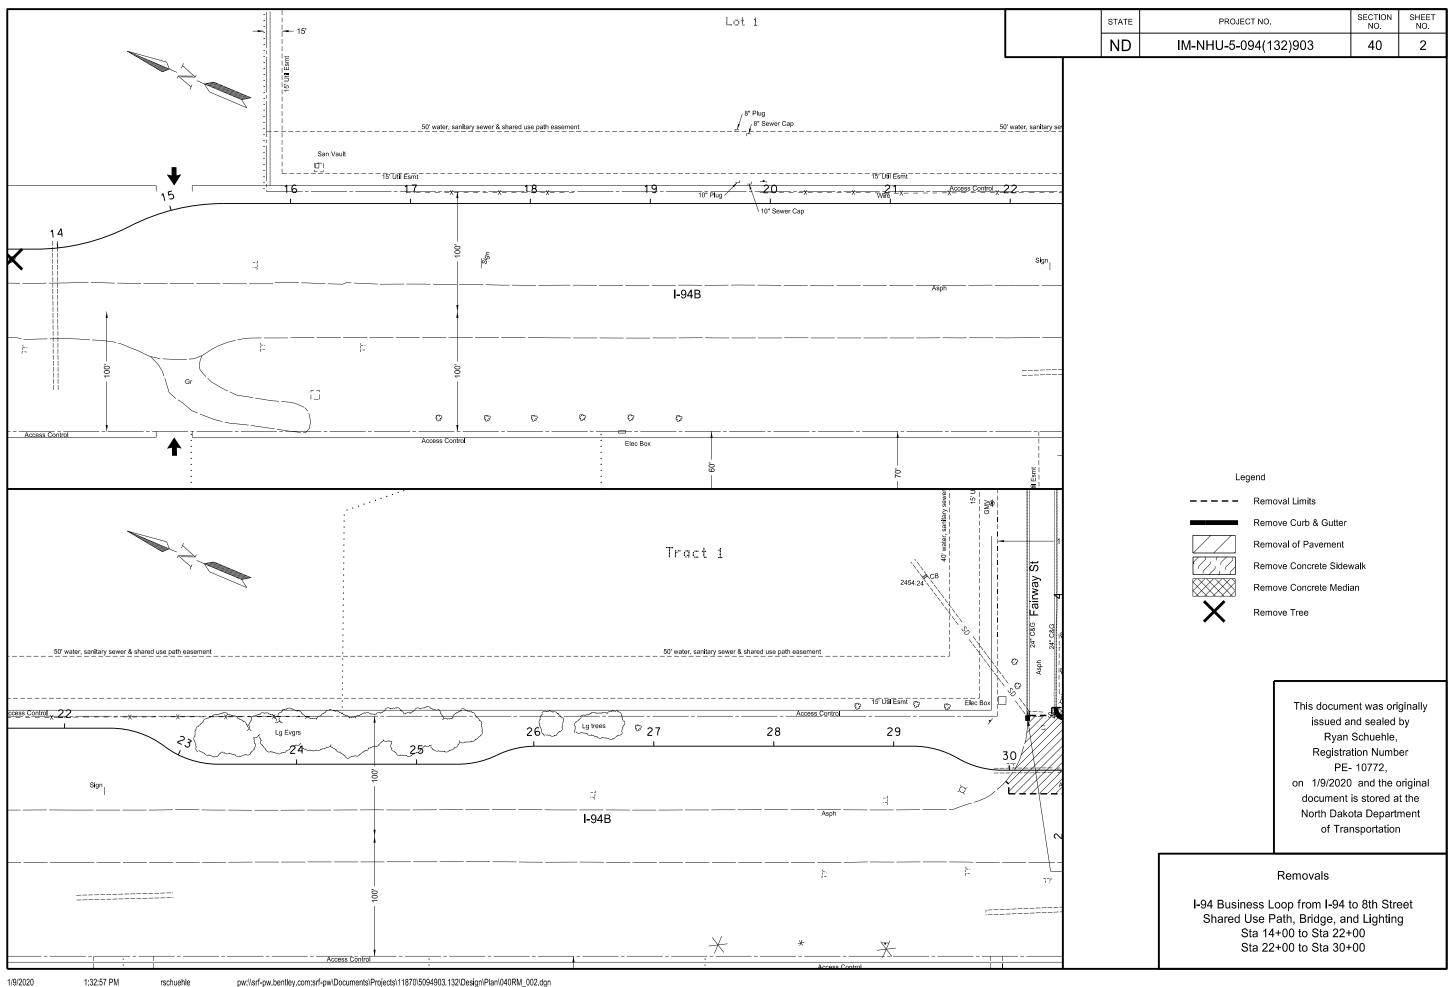

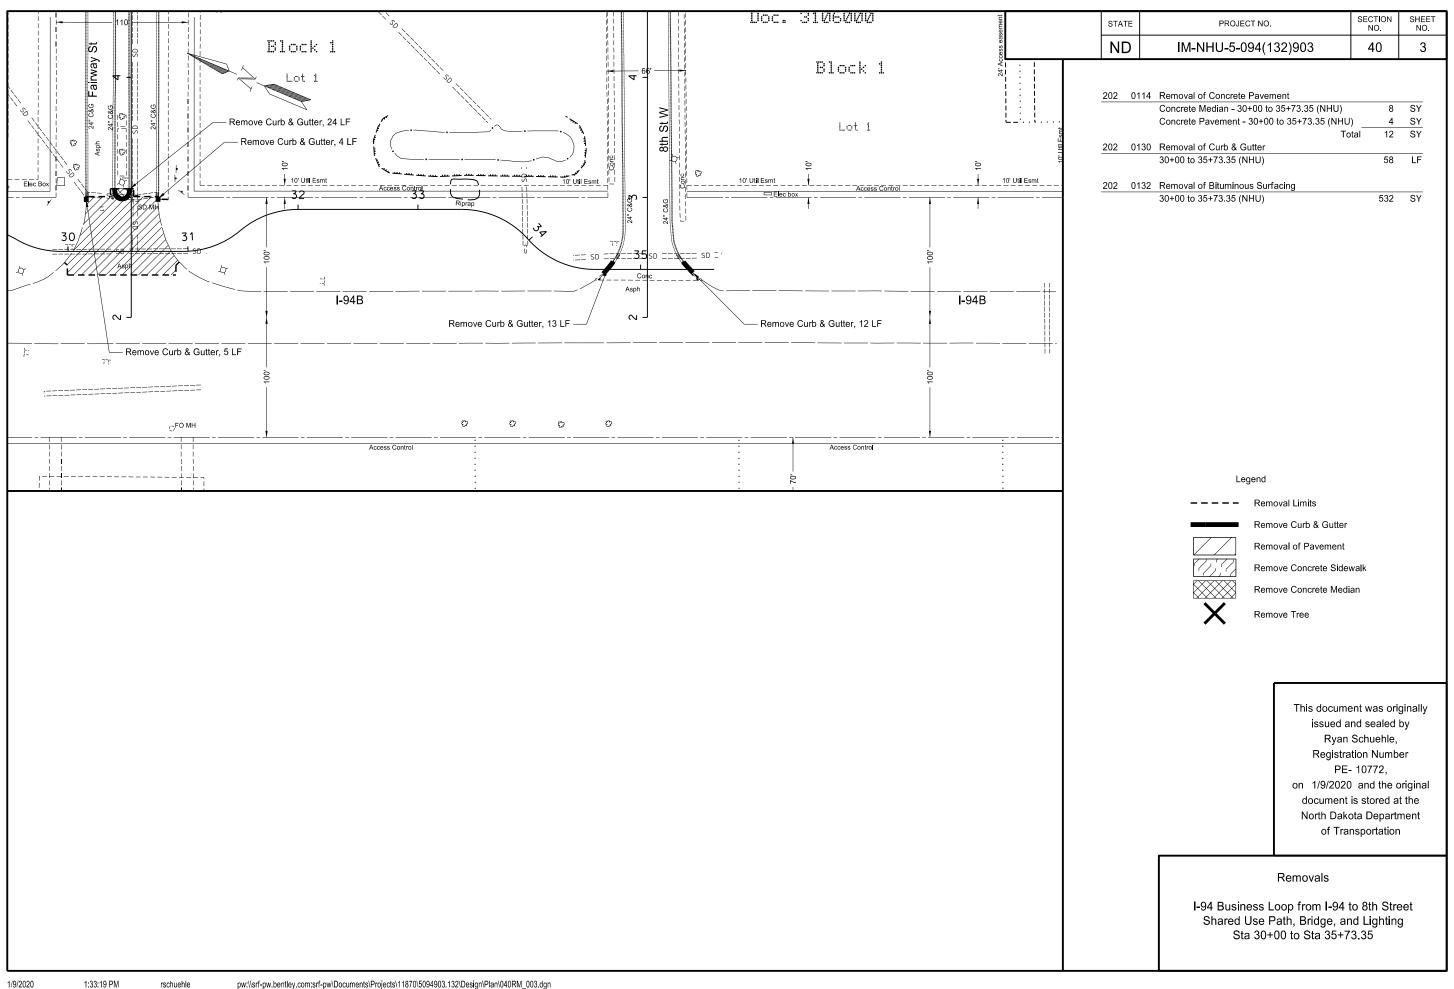

STATE	PROJECT NO.	SECTION NO.	SHEET NO.
ND	IM-NHU-5-094(132)903	50	1

Manhole No. 1 Manhole - 54IN <PRPATH> - 30+77.89 - 0.0' RT Casting Type: Solid Cover Top Elev = 2456.50 Base Elev = 2450.41 Invert Elev = 2451.37

H' Dist. = 4.8'

30 In. Conduit N = 2451.37 (Existing) 30 In. Conduit S = 2451.38 (Existing) 15 In. Conduit E = 2451.63

Inlet No. 1A Inlet - Type 2 <PRPATH> - 30+77.89 - 17.5' LT Grate Type: V Grate Elev = 2456.01 Base Elev = 2450.84 Invert Elev = 2451.70 H' Dist. = 4.2'

15 In. Conduit W = 2451.70

Manhole No. 2 Manhole - 48IN <PRPATH> - 34+02.00 - 5.9' RT Casting Type: Solid Cover Top Elev = 2456.26 Base Elev = 2450.25

Invert Elev = 2451.09 H' Dist. = 4.0'

8 In. Conduit E = 2451.19 (Existing) 15 In. Conduit N = 2451.09

This document was originally issued and sealed by Devin S Power, Registration Number PE- 28149, on 1/9/2020 and the original document is stored at the North Dakota Department of Transportation

Inlet and Manhole Summary

1-94 Business Loop from I-94 to 8th Street Shared Use Path, Bridge, and Lighting

STATE	PROJECT NO.	SECTION NO.	SHEET NO.
ND	IM-NHU-5-094(132)903	51	1

Begin Station/	Begin	End Station/	End		Pipe Installation		Allowable Material	Required	Steel Pipe	Steel Pipe Corrugations	Steel Pipe Minimum		*) eatments	Applicable
Location	Offset	Location	Offset		(Pay Item)			Diameter	Coatings	or Spiral Ribs	Thickness	Begin	End	Backfill
				IN	Bid Item	LF		IN	Туре	IN	IN	EA	EA	
6+57	120.2' LT	6+57	115.4' LT	18	Pipe Conc. Reinf. CL III (Extension)	4	Reinforced Concrete Pipe - Class III (Barrel Length = 4 LF)	18				Remove & Relay		D-714-27
14+00	23.3' LT	13+98	5.7' LT	30	Pipe Conc. Reinf. CL III (Extension)	16	Reinforced Concrete Pipe - Class III (Barrel Length = 16 LF)	30				Remove & Relay		Section 20 Sheet 9
29+58	10.0' RT	29+87	0.6' RT	30	Pipe Conc. Reinf. CL III (Extension)	30	Reinforced Concrete Pipe - Class III (Barrel Length = 30 LF)	30				Remove & Relay		D-714-27
4.0		,		4.5	Pipe Conduit -		Reinforced Concrete Pipe - Class III (Barrel Length = 14 LF)	1.5						5 744 67
1A		1		15	Storm Drain	14	Spiral Rib Steel Pipe	15	Р	3/4, 1	0.064	1		D-714-27
31+15	2.3' RT	31+37	12.4' RT	30	Pipe Conc. Reinf. CL III (Extension)	24	Reinforced Concrete Pipe - Class III (Barrel Length = 24 LF)	30					Remove & Relay	D-714-27
		00.07	40 OLDT	45	Pipe Conduit -	40	Reinforced Concrete Pipe - Class III (Barrel Length = 8 LF)	15					FF0	D 744.07
2		33+97	18.2' RT	15	Storm Drain	12	Spiral Rib Steel Pipe		Р	3/4, 1	0.064]	FES	D-714-27
34+06	17.3' RT	34+42	7.2' LT	36	Pipe Conc. Reinf. CL III (Extension)	42	Reinforced Concrete Pipe - Class III (Barrel Length = 42 LF)					Remove &		D-714-27

Z = Zinc

3/4 = 3/4"x3/4"@7-1/2"

A = Aluminum

1 = 3/4"x1"@11-1/2" P = Polymeric (over Zinc or Aluminum)

<u>Corrugations</u>: 2 = 2-2/3"x1/2"

3 = 3"x1"

5 = 5"x1"


TES = Traversable End Section


(*) The price bid for "Pipe Conduit" bid items includes end treatments. $\mbox{FES} = \mbox{Flared End Section}$


This document was originally issued and sealed by Devin S Power, Registration Number PE- 28149, on 1/9/2020 and the original document is stored at the North Dakota Department of Transportation


Allowable Pipe List


1-94 Business Loop from I-94 to 8th Street Shared Use Path, Bridge, and Lighting

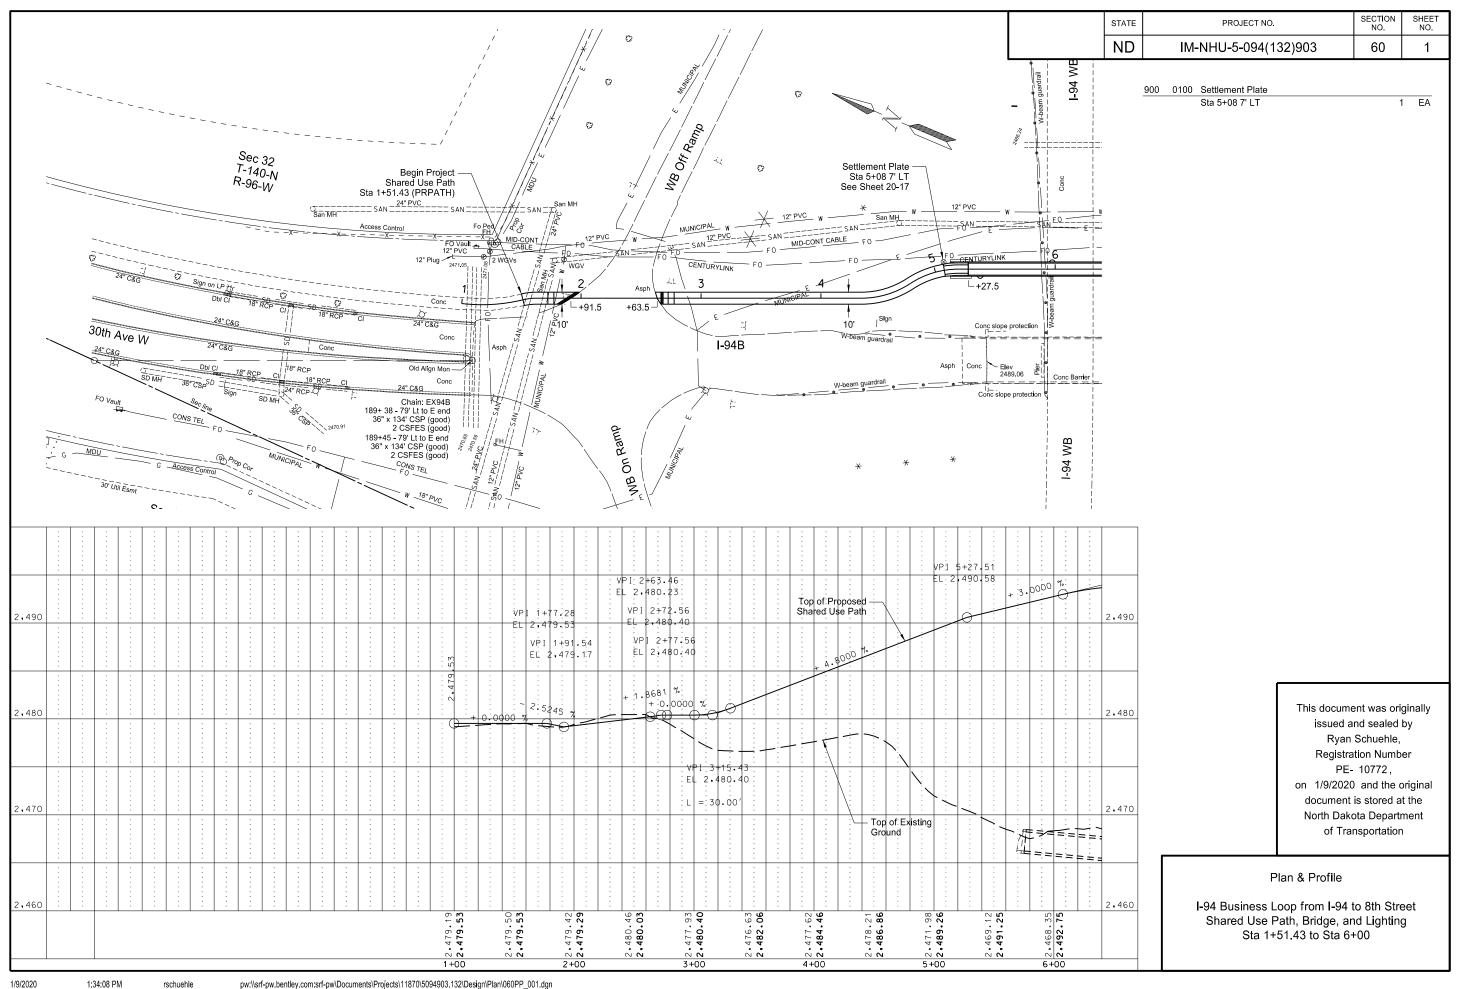


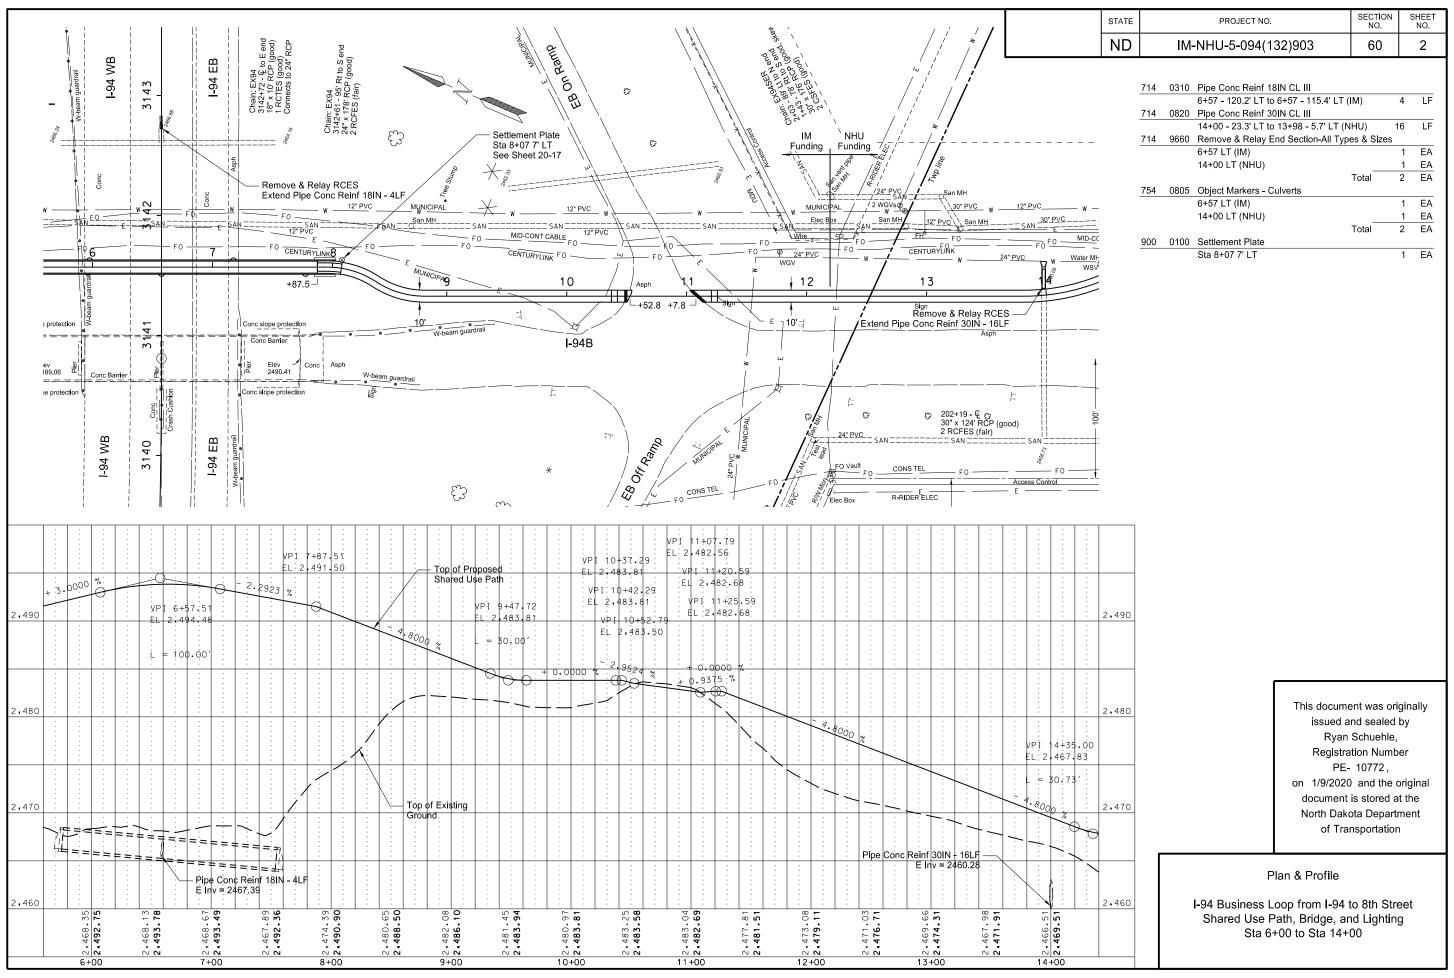

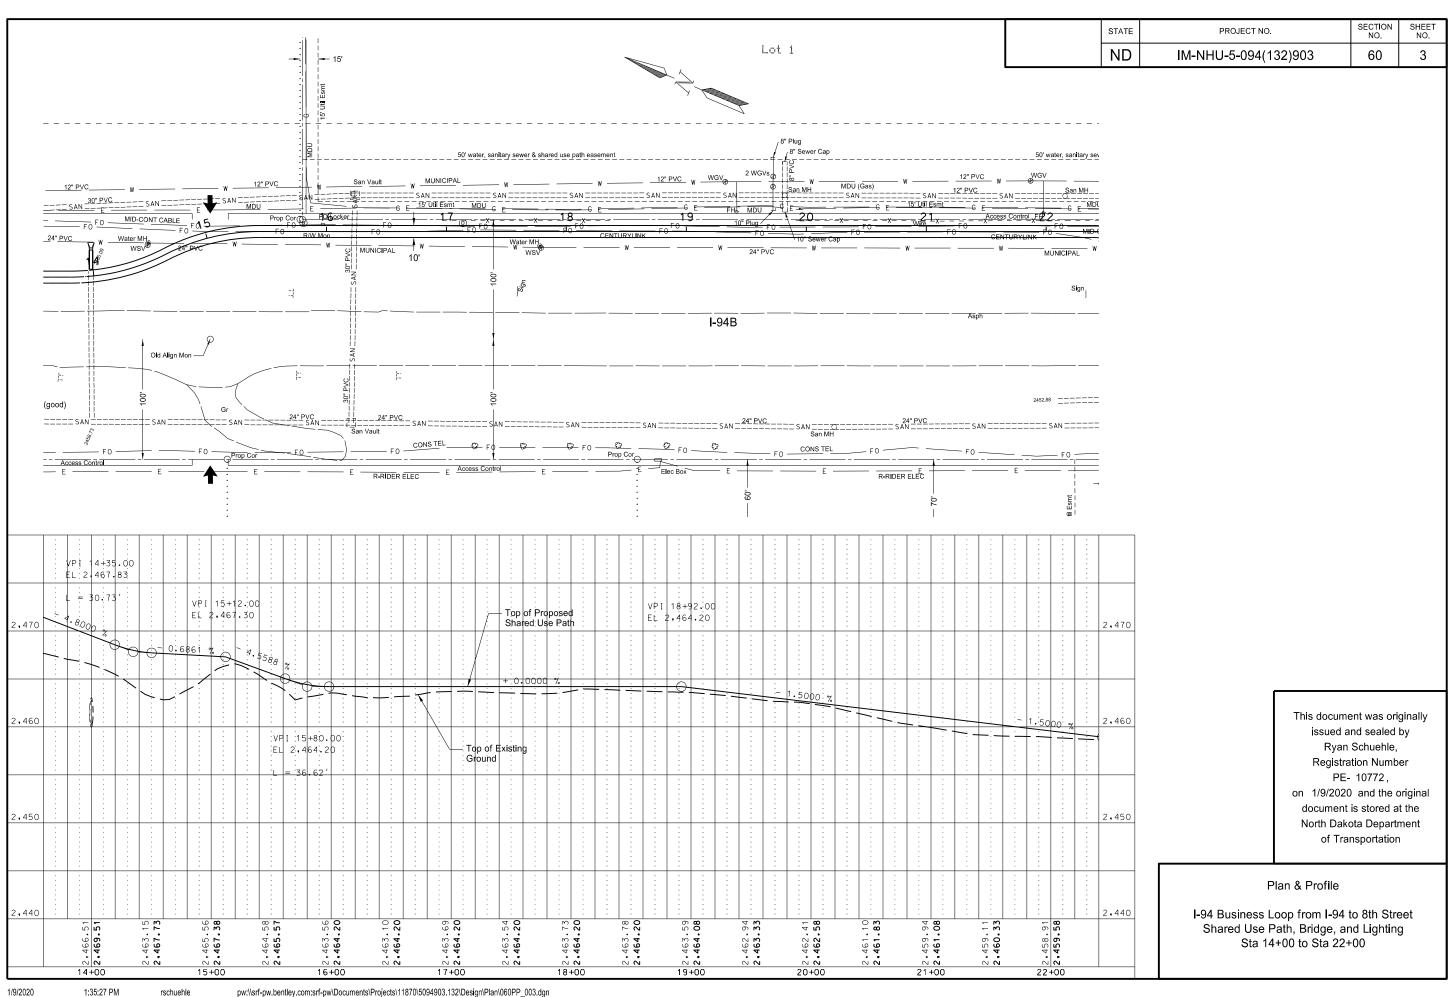

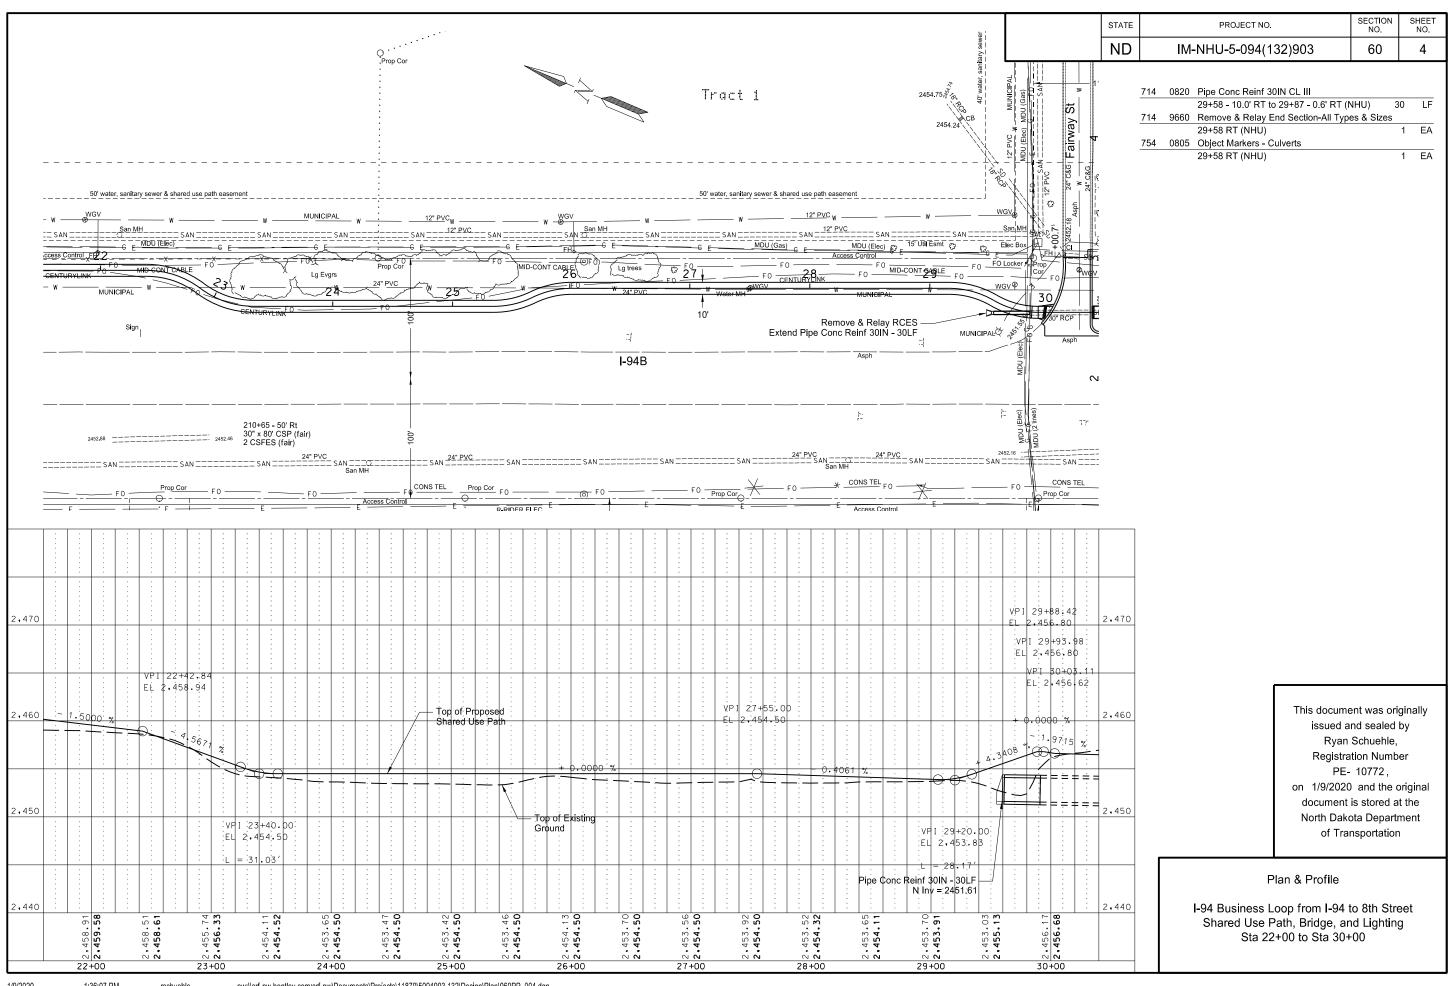

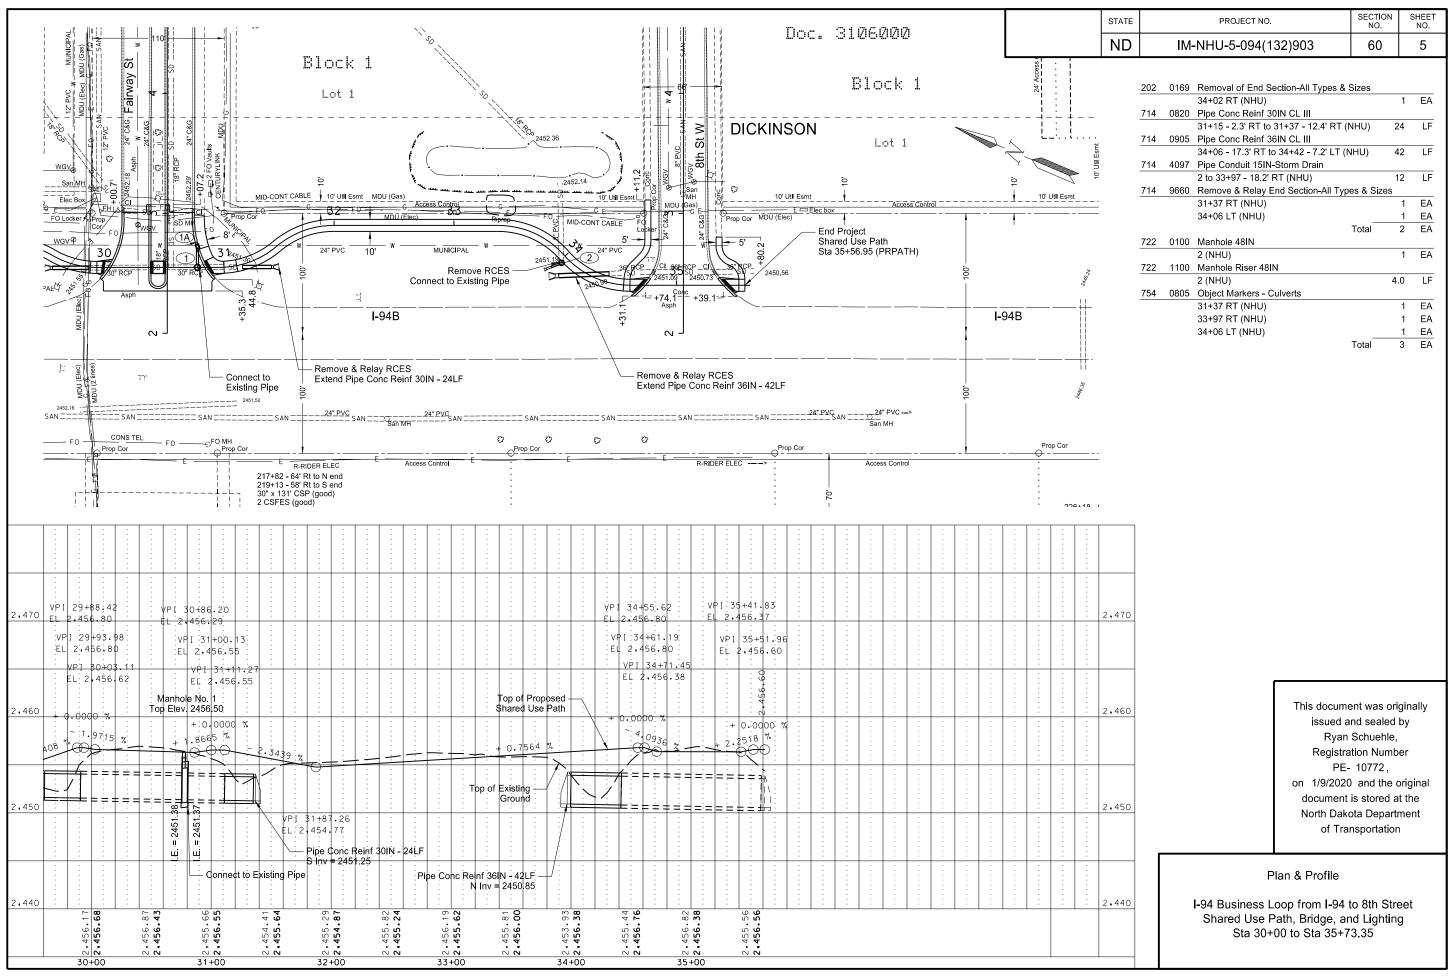

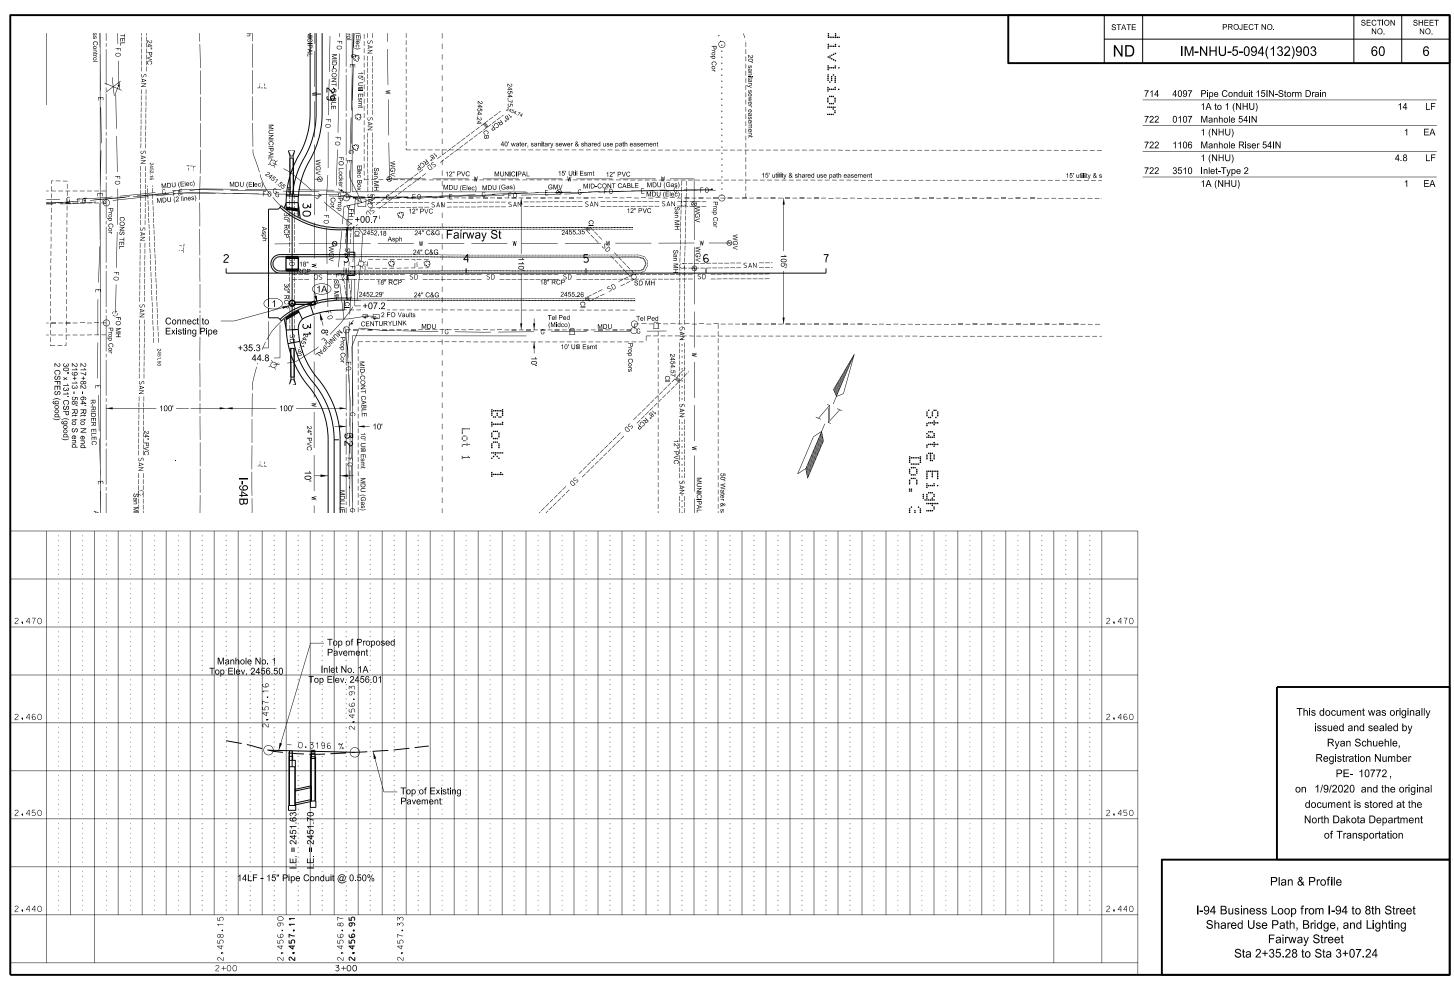

STATE	PROJECT NO.	SECTION NO.	SHEET NO.
ND	IM-NHU-5-094(132)903	75	1

Wetland Impact Table														
				USACE	Wetland	Impacts	Wetland Mitigation							
Wetland Number	Location	Туре	Wetland Feature	Jurisdictional Wetlands ¹	Acre(s)		Mitig	gation Requir	11990 Bank					
					Temp.	Perm.	EO 11990	USACE	USFWS	Location	Acre(s)			
1a	Sec. 5, T139N, R96W	Ditch		Yes	0.01	0.01								
1b	Sec. 5, T139N, R96W	Ditch		Yes	0.08	0.02								
					0.09	0.03					0			


¹ A wetland Jurisdictional Determination was issued by the USACE on 2/19/2019; NWO-2010-00282-BIS.


lmı	pact Sun	nmary Table	e				
Permano Impact Sun	ent	Temporary Impacts and additional information					
Wetland Type	Total (Acres)	Wetland Type	Total (Acres/Lf)				
Natural/JD	N/A	Temporary JD	0.09				
Natural/Non- JD	N/A	Non-JD Temporary	N/A				
Artificial/JD	0.03	Permanent JD > 0.10	N/A				
Artificial /Non-JD	N/A	Permanent OW	N/A				
Total	0.03	Temporary OW	N/A				


This document was originally issued and sealed by Ryan Schuehle, Registration Number PE-10772, on 01/09/2020 and the original document is stored at the North Dakota Department of Transportation.


Wetlands Mitigation and Environmental


I-94 Business Loop from I-94 to 8th Street Shared Use Path, Bridge, and Lighting

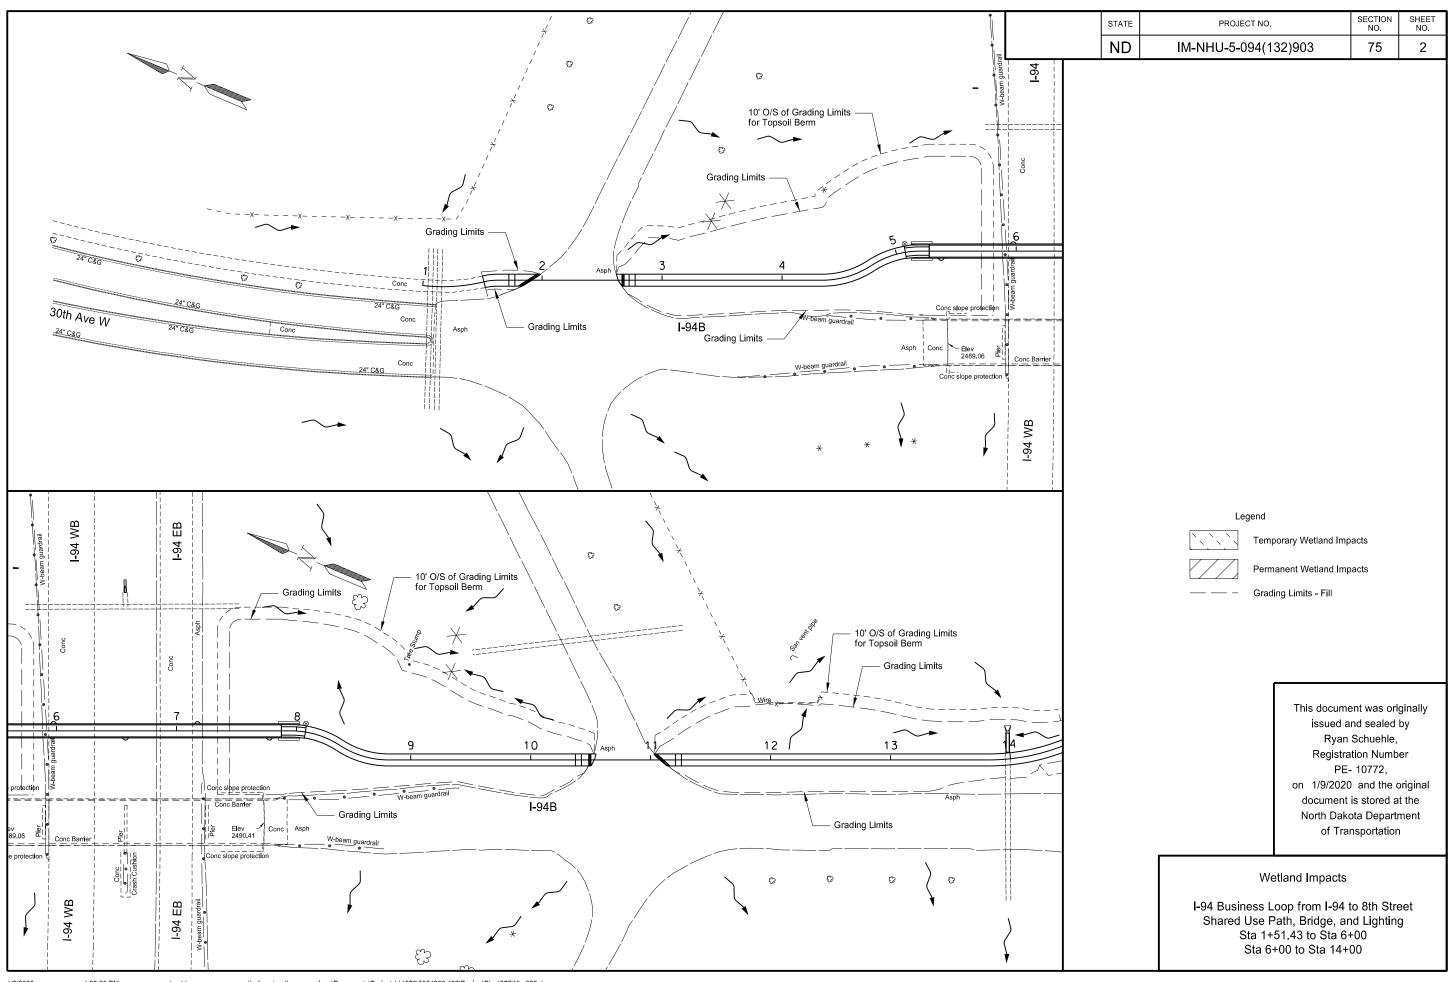


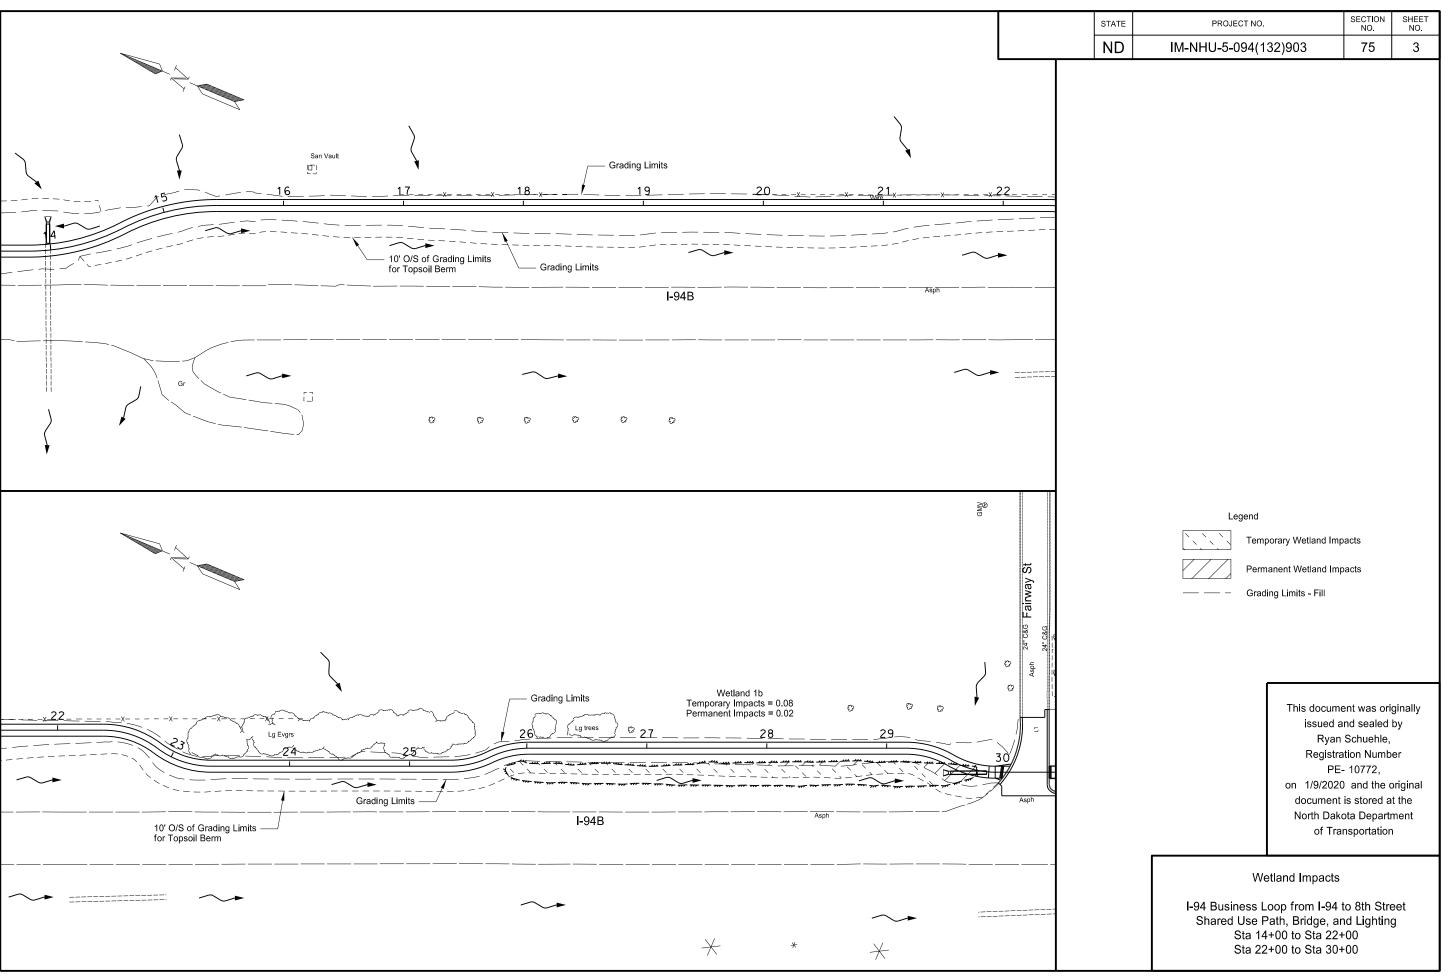


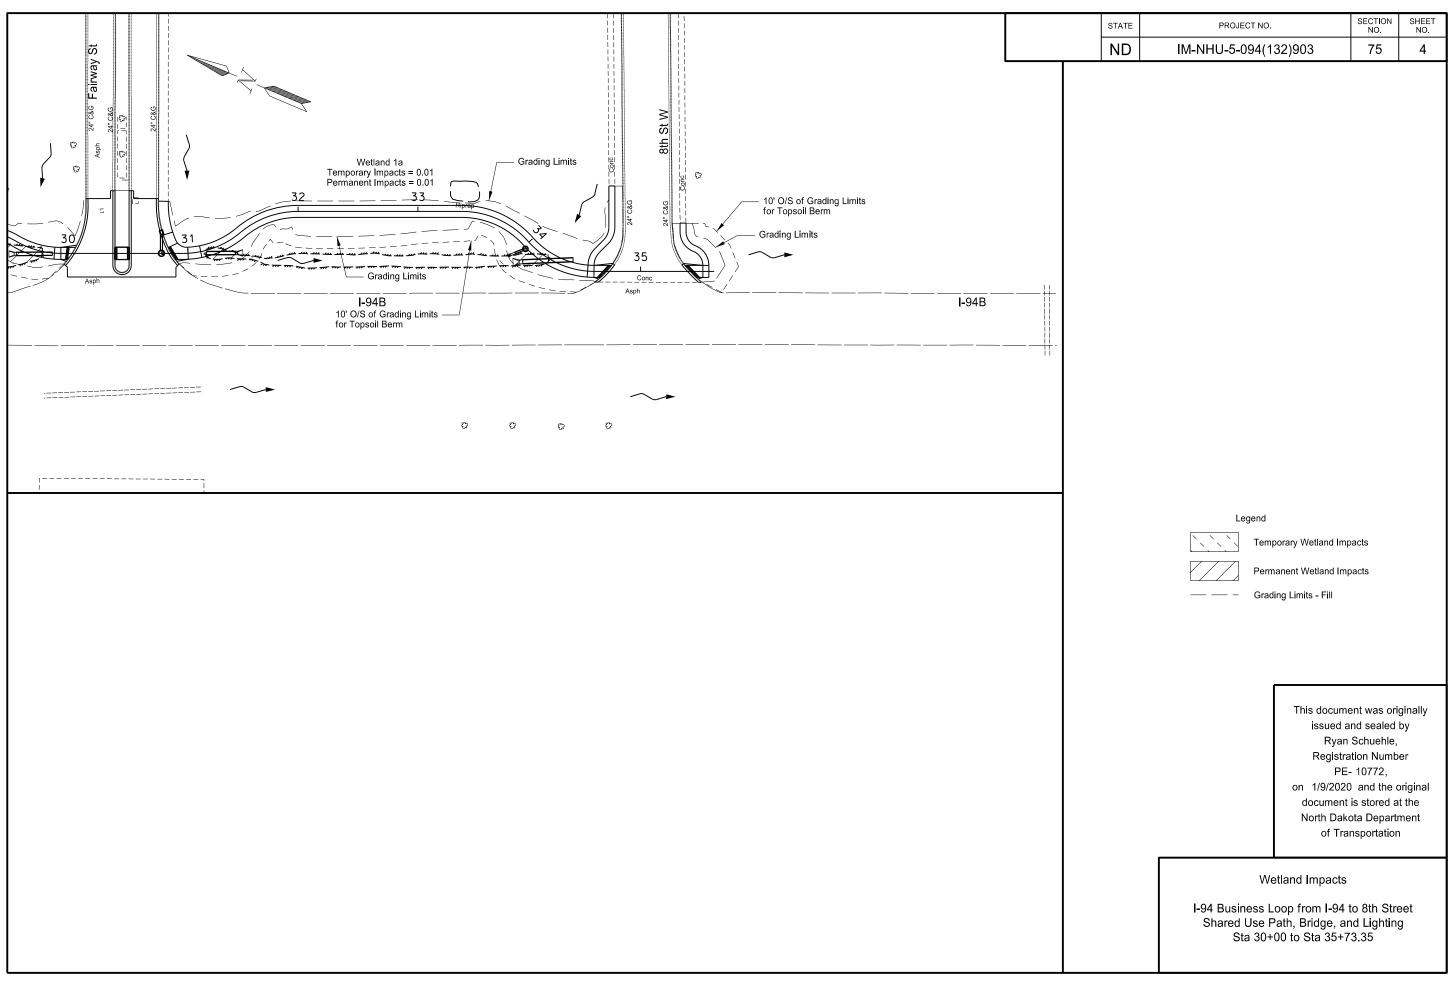


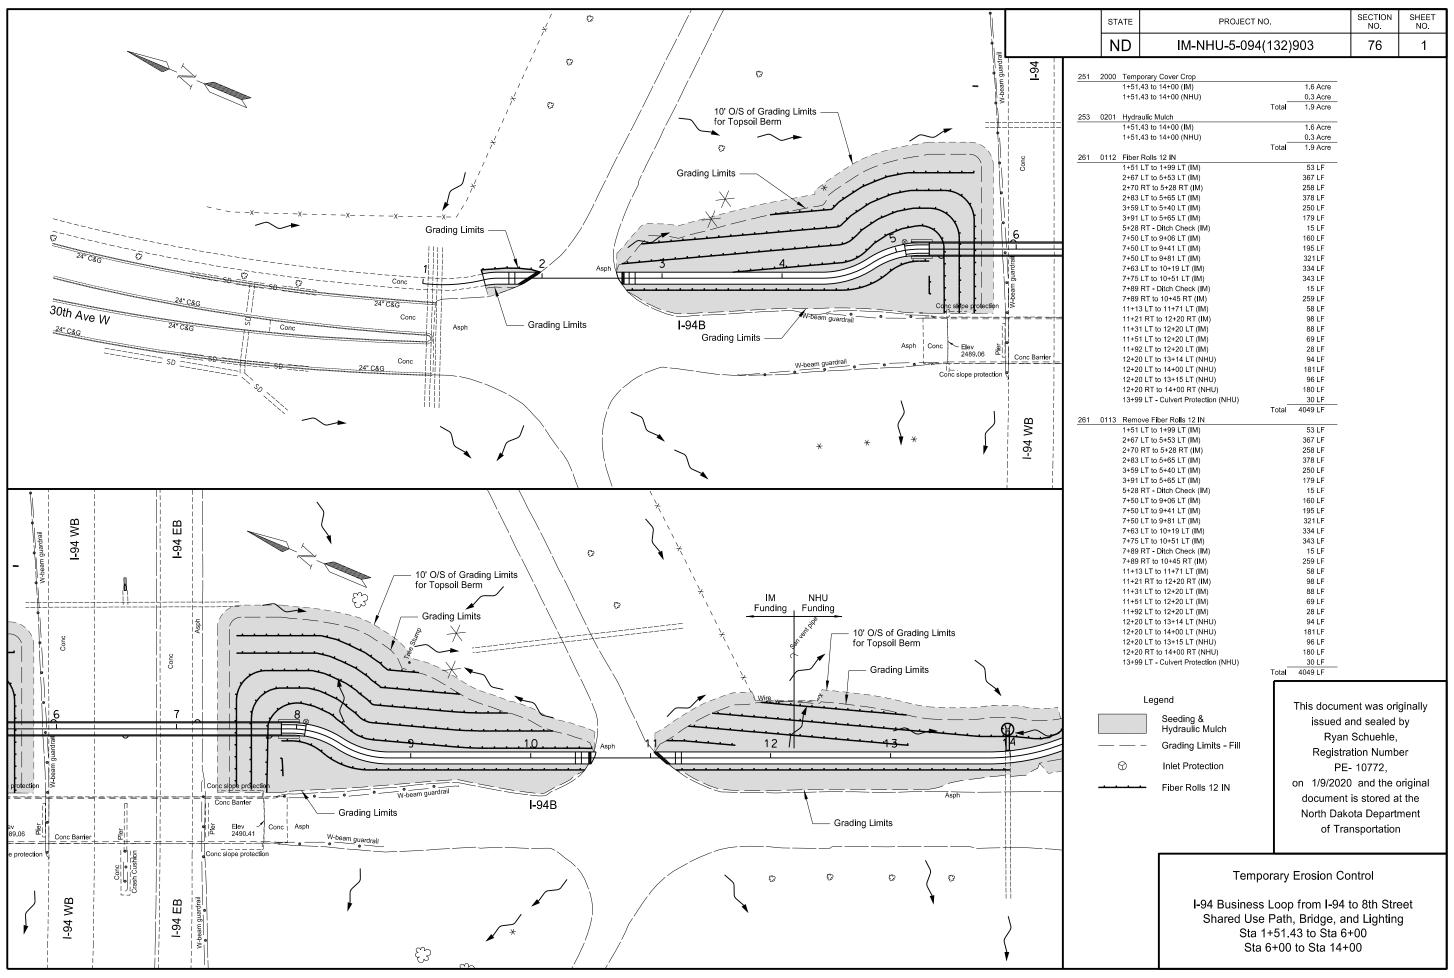


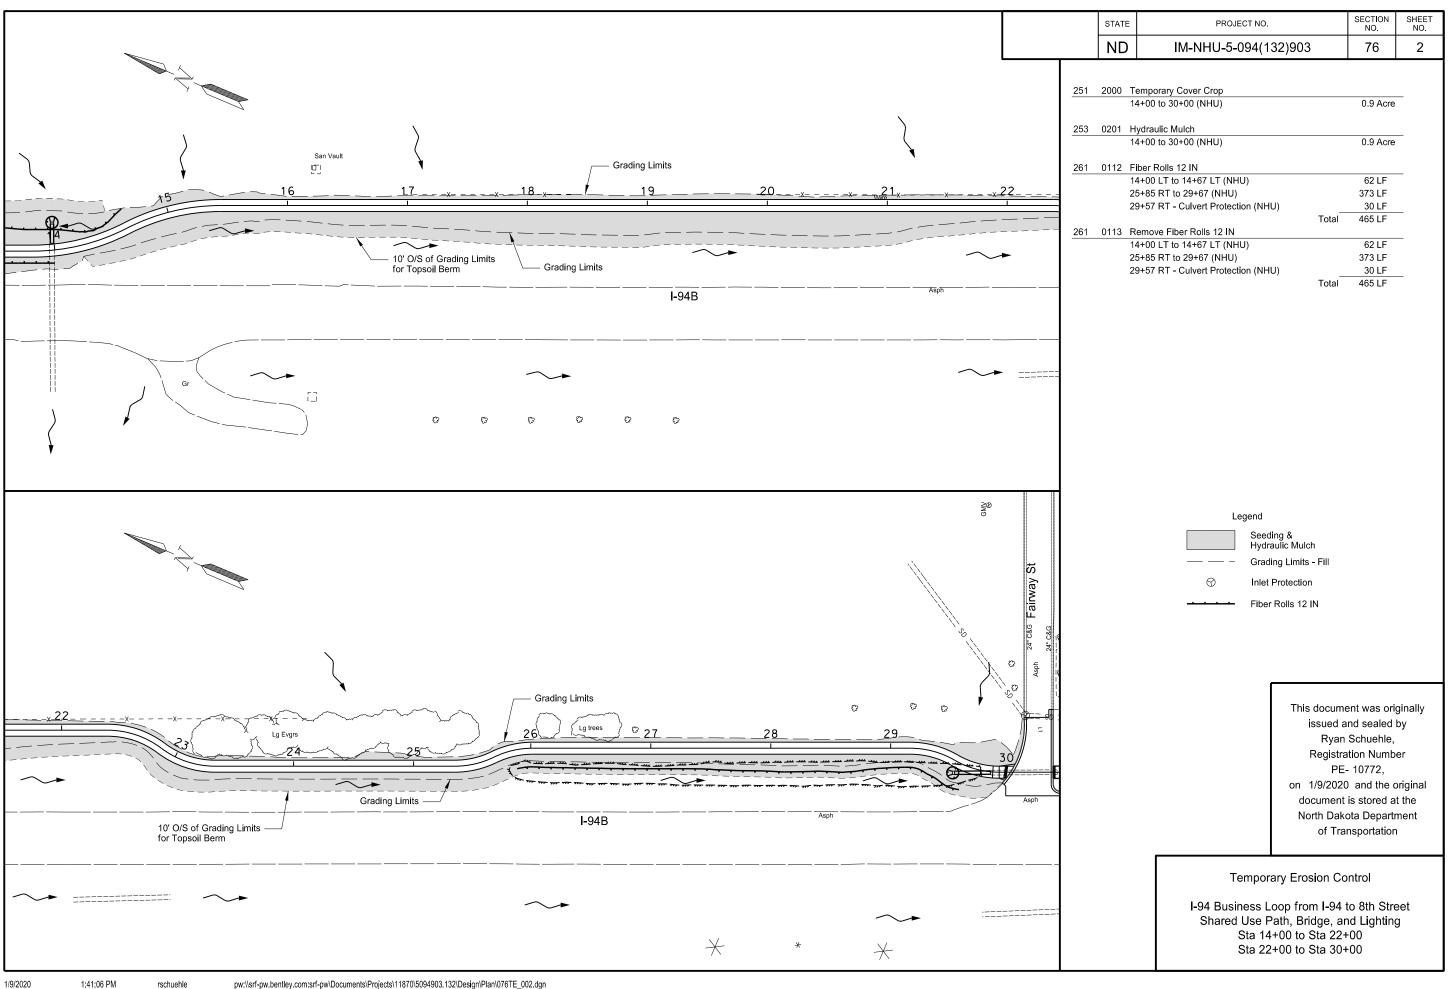


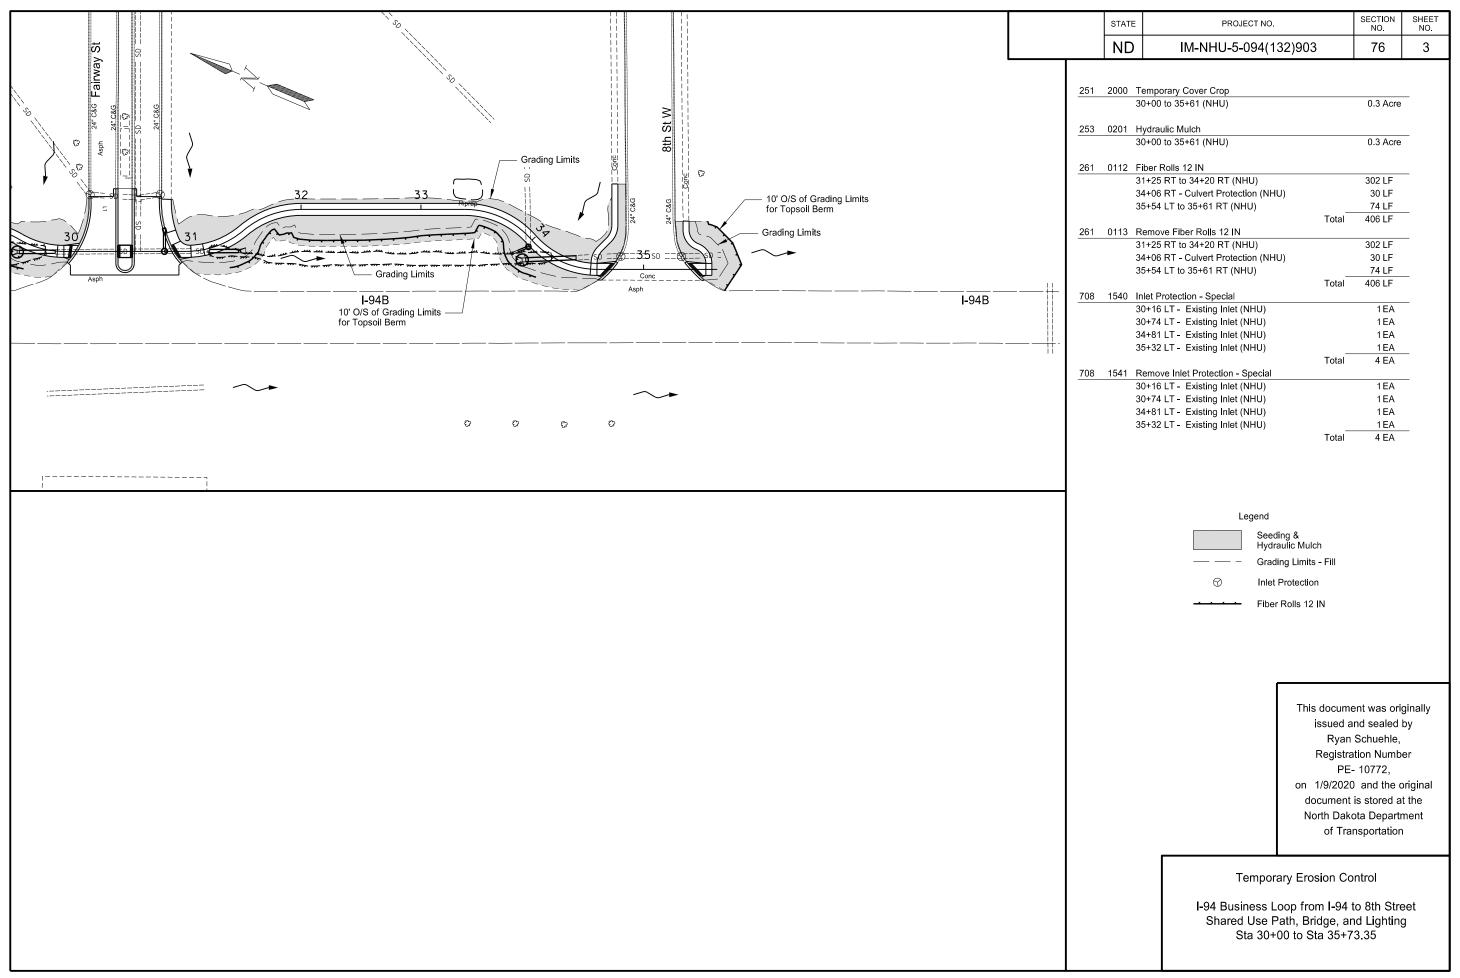


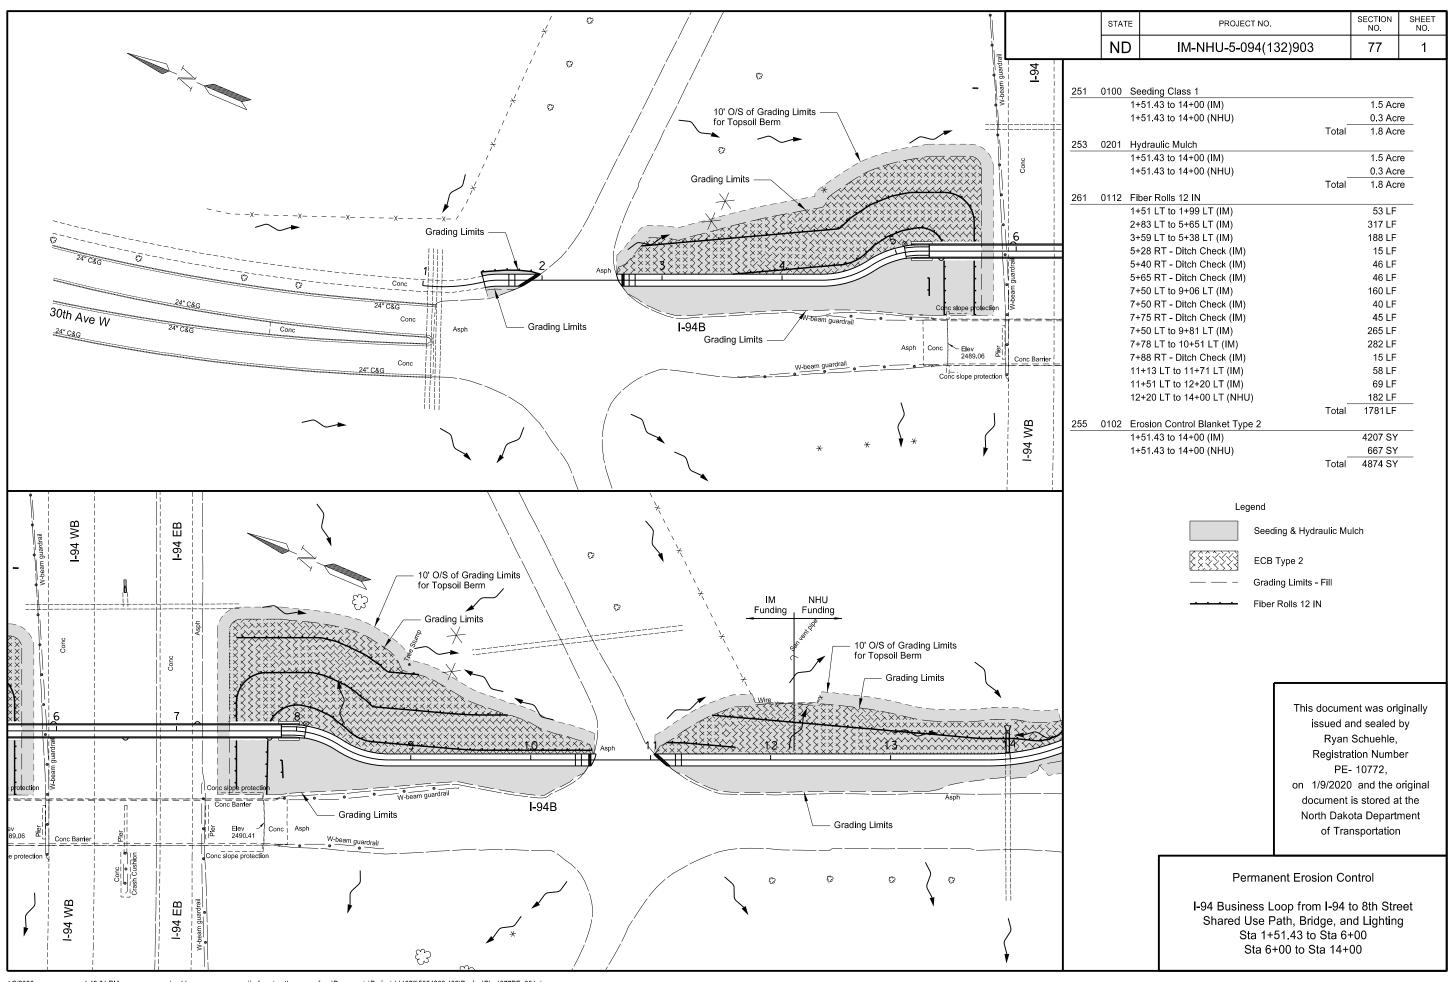


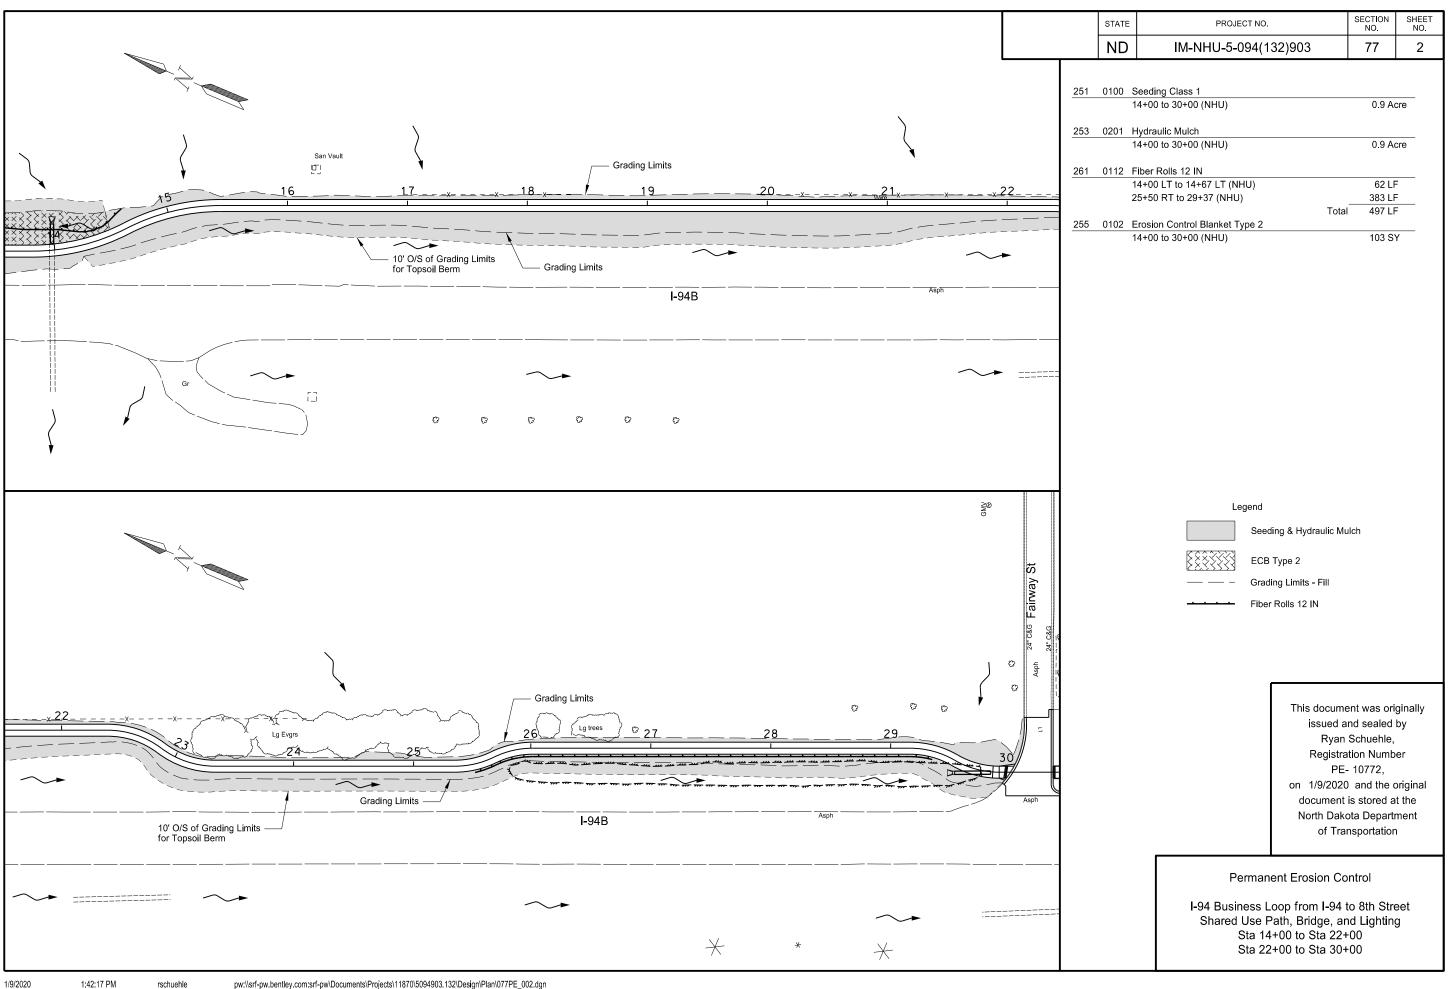

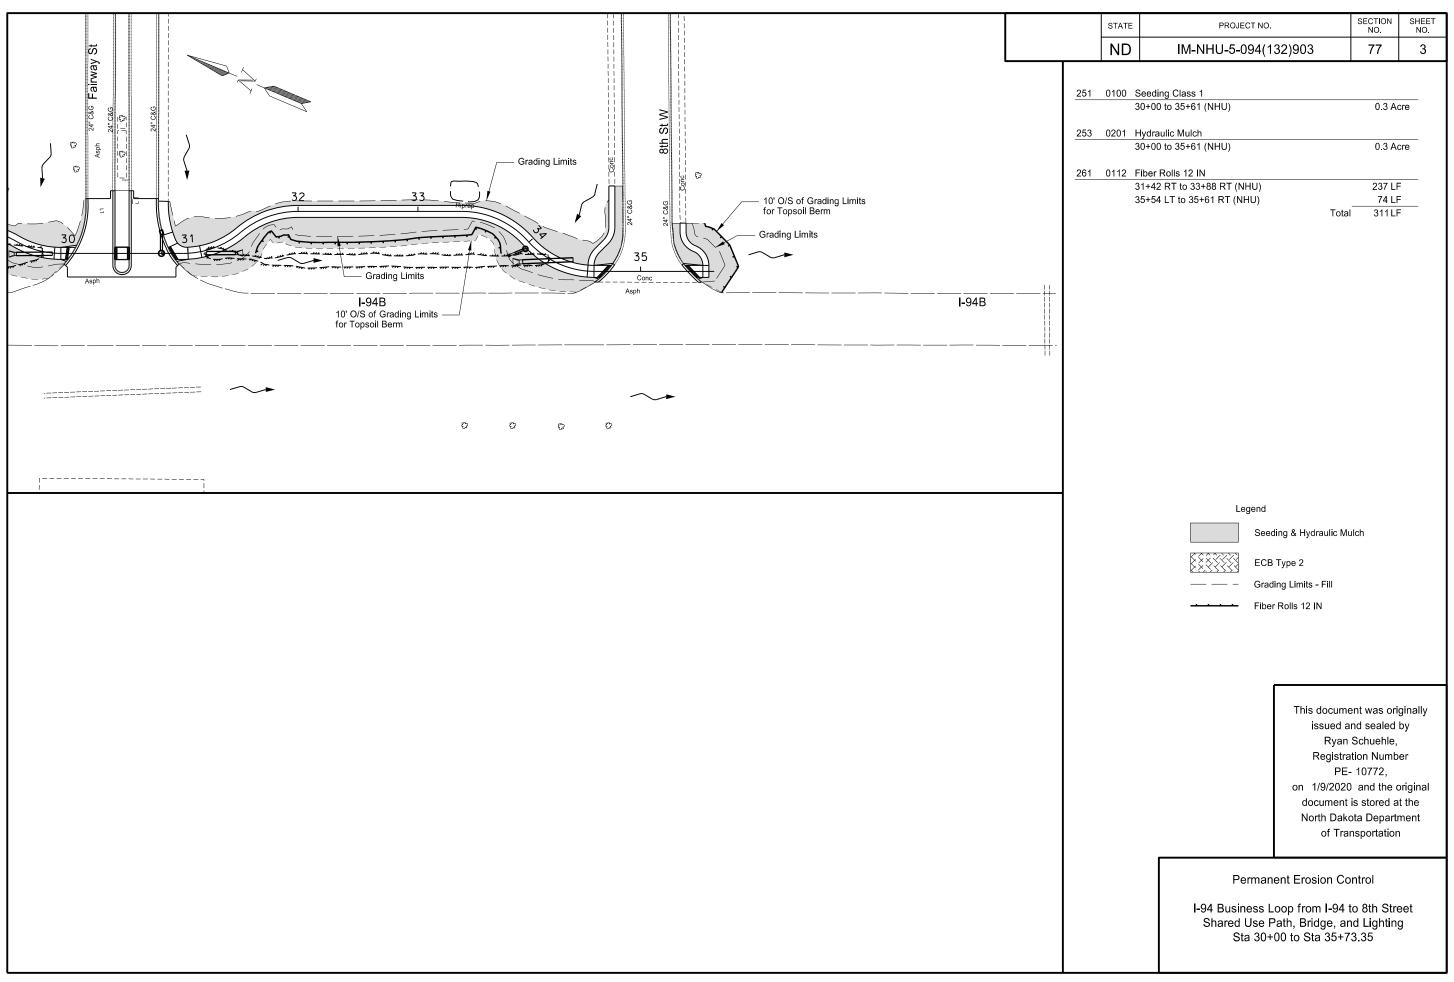

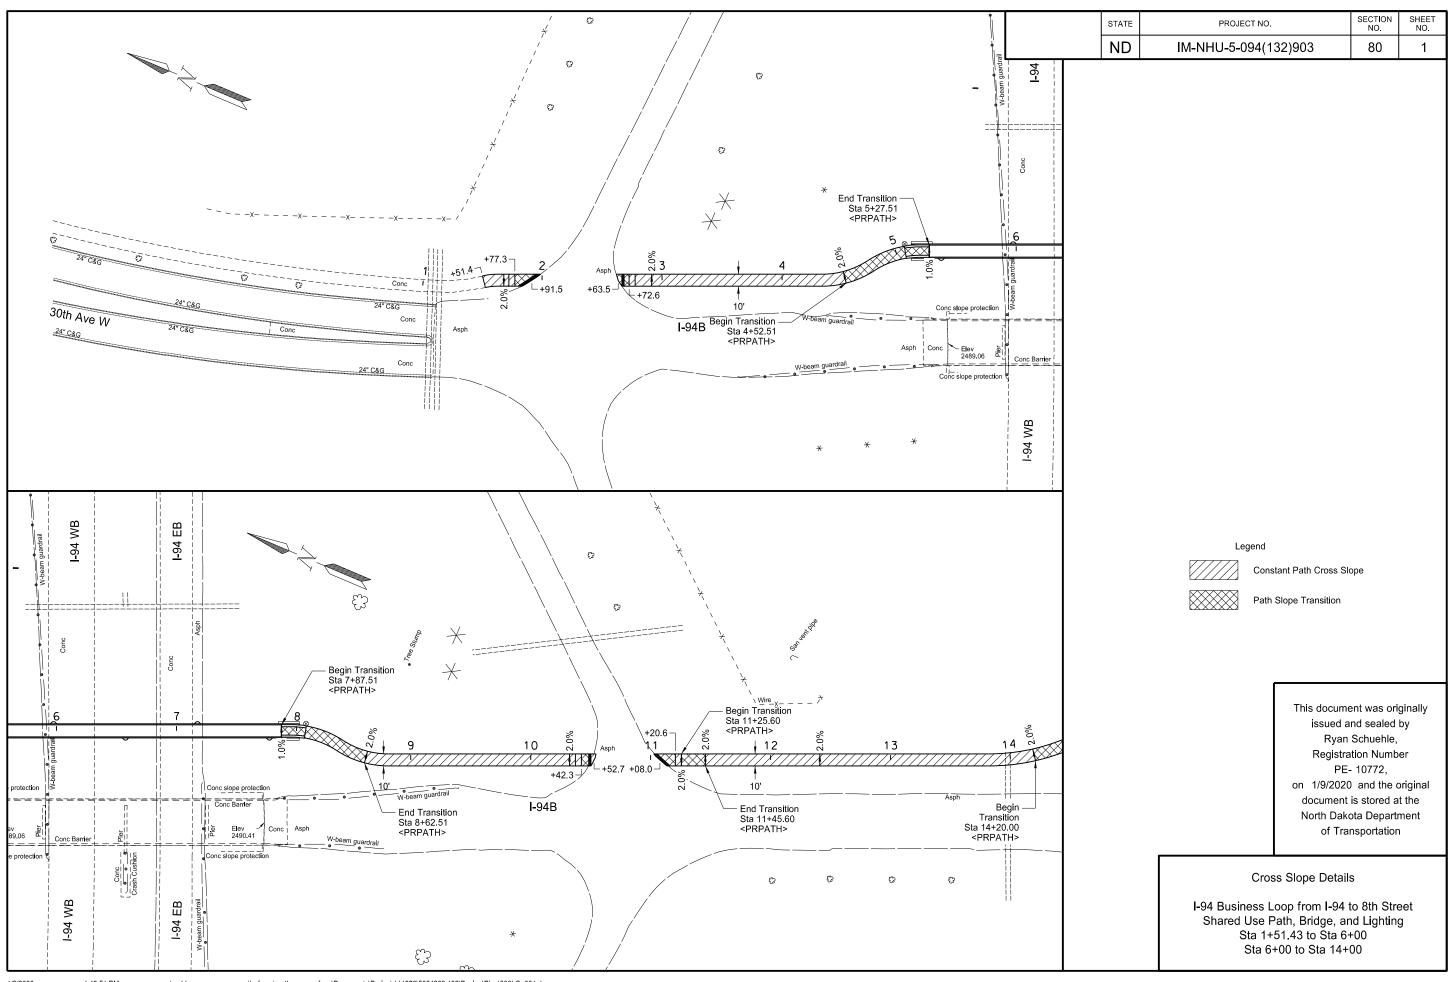

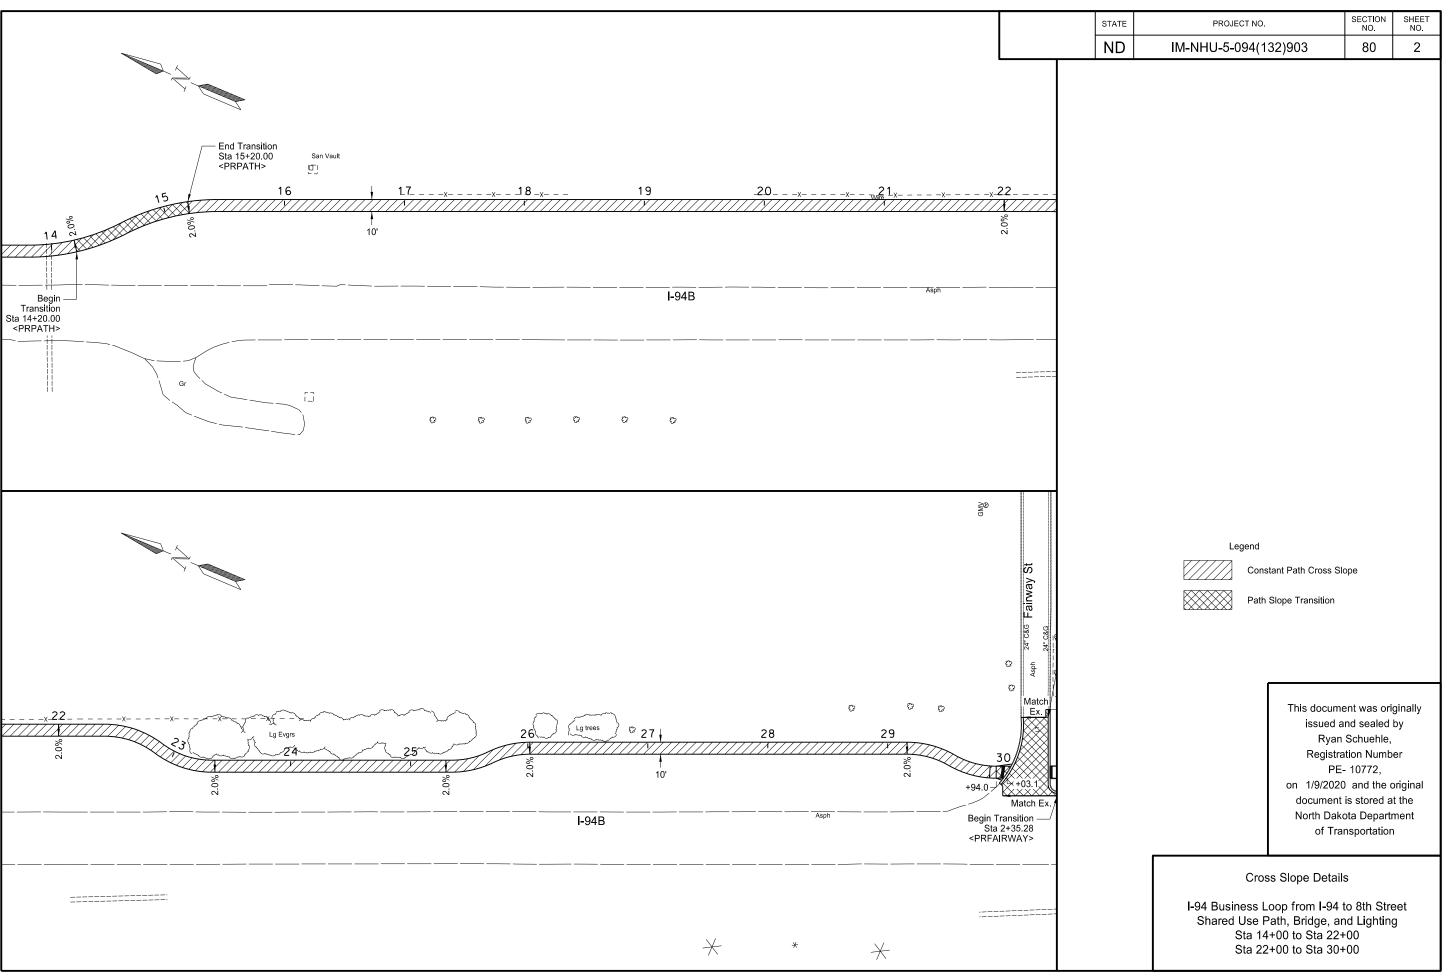

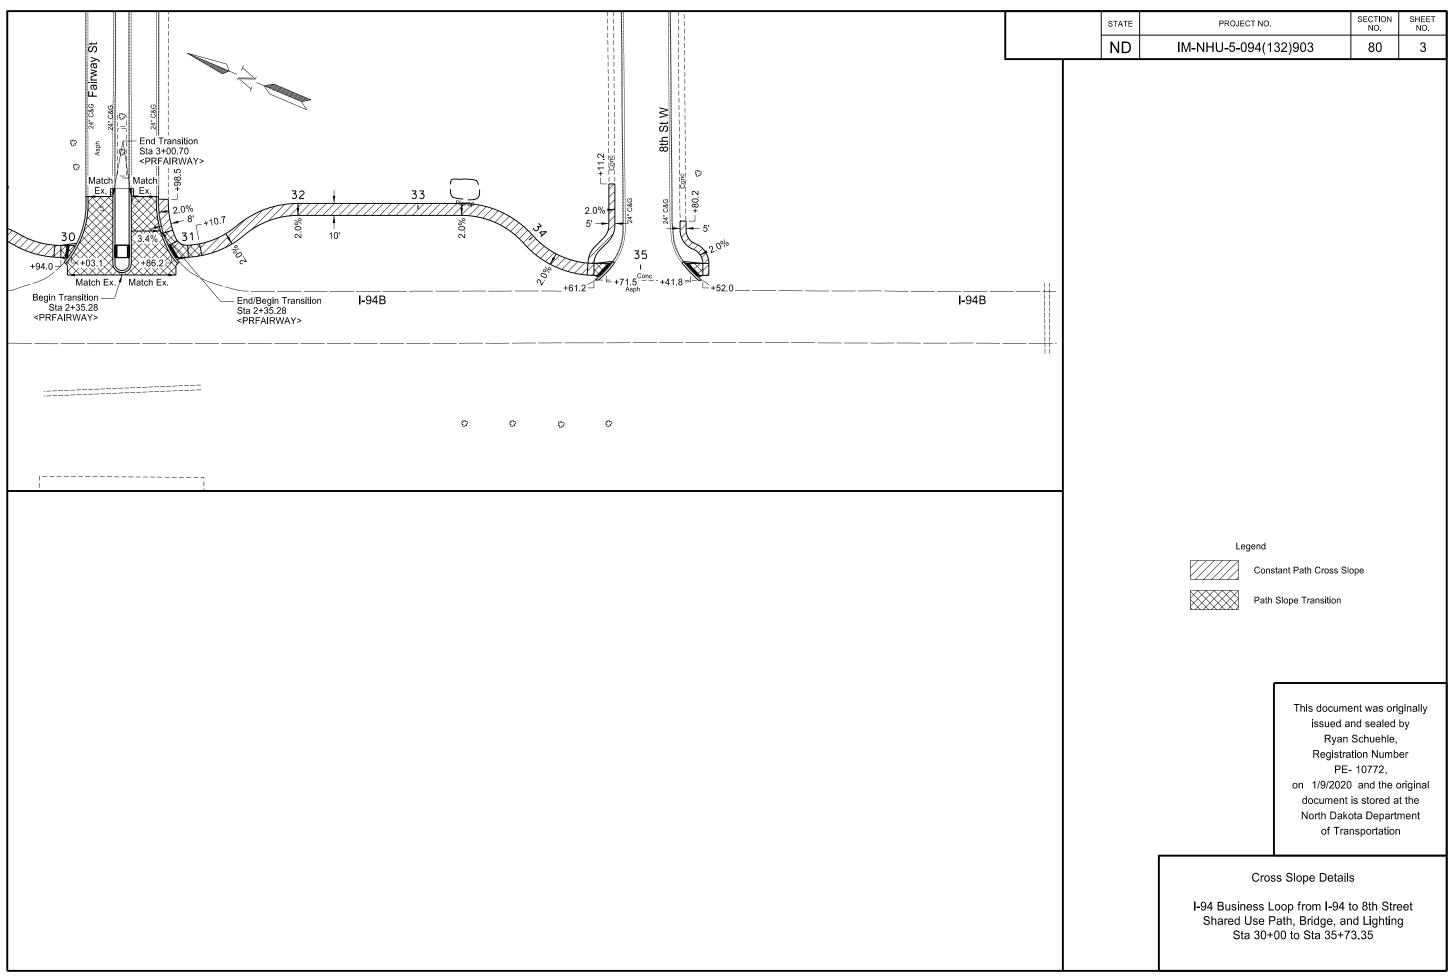

PRELIMINARY SURVEY COORDINATE AND CURVE DATA - 8TH ST W TO I-94 EXIT 59 N RAMP

STATE	PROJECT NO.	SECTION NO.	SHEET NO.
ND	IM-NHU-5-094(132)903	81	1

HORIZONTAL ALIGNMENT				CURVE DATA			US PUBLIC LAND SURVEY DATA				SURVEY CONTROL POINTS						
							DEOC					DNT					OFFOFT
	ATION	NORTHING	EASTING		ARC DE	FINITION	DESC.					PNT	NORTHING C	EASTING ONTROL POINT		STATION N	OFFSE1
I-94 Business Loop (Chain: EX94B)			CUR3			NW Cor	6-139N-96W	1-A	455215.30	1380822.48						
Beg/Rec ¼ Cor	172+90.18	457706.88	1385865.52		= 186+34.10		NE Cor	6-139N-96W	3-A	455068.58	1385781.56	GPS 1	454378.19	1413783.68	2504.29	_	_
PC	183+19.07	456678.51	1385832.79	Delta	= 24° 48' 25" LT		E ¼ Cor		3-B	452386.25	1385697.20			um Cap Stampe		S-1"	
PI CUR3	186+34.10	456363.65	1385822.77	Da	= 4° 00' 00"		N ¼ Cor	5-139N-96W	4-A	454992.66	1388423.59	GPS 3	446346.59	1392350.11	2411.85	_	_
PT	189+39.25	456073.63	1385945.77	R	= 1432.40'								1.5" A	um Cap Stampe	d "NDDOT GP:	S-3"	
Station equation a	at I-94 WB Exit Rai	mp and Entrance Ramp		Т	= 315.03'		NE Cor	31-140N-96W	3-L	460345.49	1385942.86						
I-94 Business Loo	p 190+23.84	455995.76	1385978.80	L	= 620.18'		E ¼ Cor	31-140N-96W	3-M	457706.88	1385865.52						
I-94 WB Exit Ram	p 0+00.00	455995.76	1385978.80										RE	FERENC	E MARKI	ERS	
I-94 WB Ent Ram	p 22+05.25	455995.76	1385978.80									R Mkr#	NORTHING	EASTING	STATION	O/S	ALIGNMEI
Station equation a	at I-94(EX94)											59	455052.36	1383644.52	3115+08	72' Rt	EX94
I-94 Business Loo	p 194+82.80	455573.23	1386158.01														
I - 94	3140+80.80	455573.23	1386158.01														
Station equation a	at I-94 EB Exit Ran	np and Entrance Ramp															
I-94 Business Loo	p 199+41.71	455150.75	1386337.21														
I-94 EB Exit Ramp	p 19+26.86	455150.75	1386337.21														
I-94 EB Ent Ramp	0+00.00	455150.75	1386337.21														
Twp Xing	200+49.63	455051.40	1386379.35														
PI	203+17.58	454804.72	1386483.98														
End	231+75.08	452174.07	1387599.75														
												on th	pordinates and m is document deri nternational Foot	ved from	issı	ued and se	
												I N	IITIALIZING BEN	CH MADK		Thomas D. gistration N	-
								umed Coordinates				1	NDGPS Stations			LS-1087	'1,
NOTES: Sheet 1 of 3						Date Survey Completed 12/7/18	Cou The refe	coordinates on this shee inty ground coordinates. y are derived from the N rence frame; North Dak- nbination Factor (cf) = 0	IAD83(2011 ota South Zo) one		GE	SVD-29 EOID 12A		docur North	7/19 and nent is sto Dakota De f Transpor	epartment
							Con	momation Factor (cr) = 0	.0000110			⊠ GE	OID 12B			'	

PRELIMINARY SURVEY COORDINATE AND CURVE DATA - 8TH ST W TO I-94 EXIT 59 N RAMP


STATE	PROJECT NO.	SECTION NO.	SHEET NO.
ND	IM-NHU-5-094(132)903	81	2

	HORIZONTAI	_ ALIGNME	NT		CUR	RVE DATA		US	S PUBLIC LANI	SURVEY [DATA		SURVEY CON	TROL POINTS	
PNT :	STATION	NORTHING	EASTING		ARC	DEFINITION		DESC. SEC	-TWP-RGE INDEX	NORTHING	EASTING	PNT	NORTHING EASTING CONTROL POINT	ELEV STATION	OFFSE
-94 (Chain: EX94				CUR1		NWR_	2						CONTROL FOINT	DESCRIPTION	
Beg/Rec Sec Cor	3086+82.63	455215.30	1380822.48	PI STA	= 3128+59.91	PI STA	= 12+55.89								
PC	3115+99.49	455121.65	1383737.82	Delta	= 24° 49' 05" LT	Delta	= 31° 38' 15" LT								
PI CUR1	3128+59.91	455081.19	1384997.60	Da	= 1° 00' 01"	Da	= 3° 59' 57"								
Twp Xing	25.34' (Ahd Tan)	455091.08	1385020.93	R	= 5728.45'	R	= 1432.69'								
Sec Xing	863.61 (Ahd Tan)	455418.33	1385792.69	Т	= 1260.43'	Т	= 405.92'								
PT	3140+80.80	455573.23	1386158.01	L	= 2481.31'	L	= 791.10'								
Station equation	n at I-94 Business Loop	(EX94B)													
PT I-94	3140+80.80	455573.23	1386158.01	CUR2											
I-94 Business I	oop 194+82.80	455573.23	1386158.01	PI STA	= 3177+43.66										
PC	3164+77.42	456508.83	1388364.47	Delta	= 24° 55' 27" RT										
PI CUR2	3177+43.66	457003.15	1389530.24	Da	= 1° 00' 00"										
PT end	3189+69.85	456960.15	1390795.76	R	= 5729.58'										
				Т	= 1266.25'										
I-94 WB Exit Ram	(Chain: EX94NER)			L	= 2492.43'										
Beg	0+00.00	455995.76	1385978.80												
Station equation	n at I-94 Business Loop	(EX94B)		NER_1											
Beg I-94 WB E	kit Ramp 0+00.00	455995.76	1385978.80	PI STA	= 8+52.08										
I-94 Business l	oop 190+23.84	455995.76	1385978.80	Delta	= 25° 07' 37" LT										
PC	5+32.79	455962.48	1386510.56	Da	= 3° 59' 57"										
PI NER_1	8+52.08	455942.54	1386829.22	R	= 1432.69'										
PT	11+61.09	456059.80	1387126.19	Т	= 319.28'										
End	18+01.29	456294.91	1387721.65	L	= 628.30'										
I-94 WB Entrance	Ramp (Chain: EX94NW	R)		NWR_	1										
PC Beg	0+00.00	455173.52	1384018.25	PI STA	= 4+25.77										
PI NWR_1	4+25.77	455189.46	1384443.73	Delta	= 8° 29' 59" LT										
PCC	8+49.98	455268.11	1384862.17	Da	= 1° 00' 00"										
PI NWR_2	12+55.89	455343.10	1385261.10	R	= 5729.65'										
PT	16+41.08	455616.19	1385561.41	Т	= 425.77'							A 111	· · · · · · · · · · · · · · · · · · ·		
End	22+05.25	455995.76	1385978.80	L	= 849.98'							on t	coordinates and measurements his document derived from	This document was	
Station equation	at I-94 Business Loop (EX94B)										the	International Foot definition.	issued and sea Thomas D. '	-
End I-94 WB En	rance Ramp 22+05.25	455995.76	1385978.80					Assumed C	Coordinates				NITIALIZING BENCH MARK	Registration N	
I-94 Business Lo	op 190+23.8	4 455995.76	1385978.80						tes on this sheet are Stark				NDGPS Stations (OPUS) AVD-88	LS-1087 on 5/7/19 and	•
NOTES: Sheet 2 of 3						Date Sur	vey Completed 12/7/18	County grou They are de reference fr	ind coordinates. rived from the NAD83(201 ame; North Dakota South a Factor (cf) = 0.9998175	1)		N	GVD-29 EOID 12A EOID 12B	document is stor North Dakota De of Transport	ed at the partment

PRELIMINARY SURVEY COORDINATE AND CURVE DATA - 8TH ST W TO I-94 EXIT 59 N RAMP

STATE	PROJECT NO.	SECTION NO.	SHEET NO.
ND	IM-NHU-5-094(132)903	81	3

	HORIZONTA	L ALIGNME	NT		CURV	E DATA		US PUBLIC LAN	D SURVEY I	DATA		SURVEY CONT	ROL POINTS	
PNT	STATION	NORTHING	EASTING		ARC DE	EFINITION	DESC. S	EC-TWP-RGE INDE	X NORTHING	EASTING	PNT	NORTHING EASTING CONTROL POINT I	ELEV STATION	OFFSET
I-94 EB Exit Ra	amp (Chain: EX94SWR)			SWR_1								JOINTHOLT OINT	JEGOMI HON	
PC Beg	0+00.00	455086.49	1384423.25	PI STA	= 3+30.37									
PI SWR_1	3+30.37	455106.92	1384752.98	Delta	= 6° 36' 00" LT									
PT	6+60.01	455165.10	1385078.19	Da	= 1° 00' 00"									
PC	8+60.01	455200.33	1385275.06	R	= 5729.65'									
PI SWR_2	10+57.50	455235.11	1385469.47	Т	= 330.37'									
PT	12+52.52	455216.00	1385666.03	L	= 660.01'									
End	19+26.86	455150.75	1386337.21											
Station equati	ion at I-94 Business loop (EX94B)		SWR_2	!									
End I-94 EB E	Exit Ramp 19+26.86	455150.75	1386337.21	PI STA	= 10+57.50									
I-94 Business	Loop 199+41.71	455150.75	1386337.21	Delta	= 15° 41' 50" RT						1_			
				Da	= 3° 59' 57"									
I-94 EB Entran	ce Ramp (Chain: EX94SE	R)		R	= 1432.69'									
Beg	0+00.00	455150.75	1386337.21	Т	= 197.49'									
Station equati	ion at I-94 Business loop (EX94B)		L	= 392.51'									
Beg I-94 EB E	Entrance Ramp 0+00.00	455150.75	1386337.21											
I-94 Business	s loop 199+41.7	1 455150.75	1386337.21	SER_1										
PC	5+23.31	455548.91	1386676.80	PI STA	= 8+46.38									
PI SER_1	8+46.38	455794.72	1386886.45	Delta	= 25° 24' 53" RT									
PT	11+58.81	455926.76	1387181.30	Da	= 3° 59' 57"									
End	21+59.01	456335.55	1388094.15	R	= 1432.69'									
				Т	= 323.06'									
				L	= 635.50'									
											on	coordinates and measurements this document derived from	This document was	
											the	International Foot definition.	issued and sea Thomas D. V	Weigel
							Assume	ed Coordinates				INITIALIZING BENCH MARK NDGPS Stations (OPUS)	Registration N LS-1087	
							X All coord	linates on this sheet are Star	k			IAVD-88	on 5/7/19 and	the original
NOTES: Sheet 3	3 of 3					Date Survey Completed 12/7/18	County : They are reference	ground coordinates. e derived from the NAD83(20 e frame; North Dakota South	11) Zone			IGVD-29 GEOID 12A	document is store North Dakota De	partment
								ation Factor (cf) = 0.999817 5				GEOID 12B	of Transporta	auon

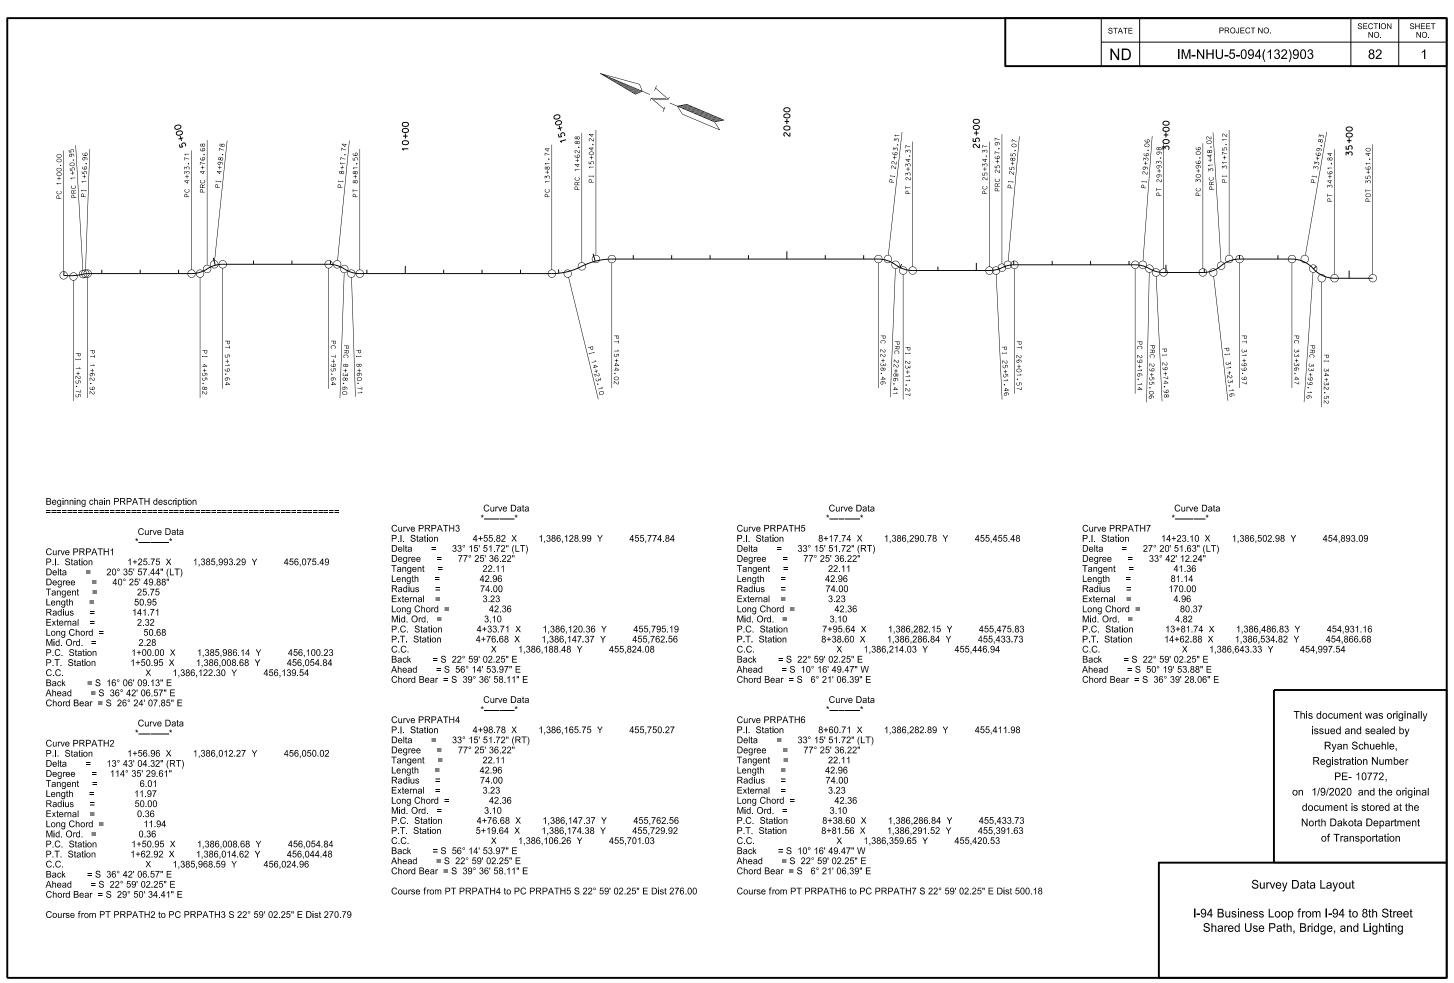

STATE	PROJECT NO.	SECTION NO.	SHEET NO.
ND	IM-NHU-5-094(132)903	82	2


Curve Data	Curve Data	Curve Data
** Curve PRPATH8	** Curve PRPATH12	** Curve PRPATH16
P.I. Station 15+04.24 X 1,386,566.65 Y 454,840.28 Delta = 27° 20' 51.63" (RT)	P.I. Station 25+85.07 X 1,386,971.80 Y 453,846.65 Delta = 26° 01' 08.39" (RT)	P.I. Station 31+75.12 X 1,387,210.73 Y 453,321.75 Delta = 40° 13' 30.26" (RT)
Degree = 33° 42' 12.24 ["]	Degree = 77° 25' 36.23"	Degree = 77° 25' 36.22"
Tangent = 41.36 Length = 81.14	Tangent = 17.10 Length = 33.60	Tangent = 27.10 Length = 51.95
Radius = 170.00	Radius = 74.00	Radius = 74.00
External = 4.96 Long Chord = 80.37	External = 1.95 Long Chord = 33.32	External = 4.81 Long Chord = 50.89
Mid. Ord. = 4.82 P.C. Station 14+62.88 X 1,386,534.82 Y 454,866.68	Mid. Ord. = 1.90 P.C. Station 25+67.97 X 1,386,958.90 Y 453,857.86	Mid. Ord. = 4.51 P.C. Station 31+48.02 X 1,387,186.54 Y 453,333.96
P.T. Station 15+44.02 X 1,386,582.80 Y 454,802.21	P.T. Station 26+01.57 X 1,386,978.48 Y 453,830.91	P.T. Station 31+99.97 X 1,387,221.31 Y 453,296.80
C.C. X 1,386,426.30 Y 454,735.83 Back = S 50° 19' 53.88" E	C.C. X 1,386,910.35 Y 453,802.01 Back = S 49° 00' 10.64" E	C.C. X 1,387,153.19 Y 453,267.90 Back = S 63° 12' 32.51" E
Ahead = S 22° 59' 02.25" E	Ahead = S 22° 59' 02.25" E	Ahead = S 22° 59' 02.25" E
Chord Bear = S 36° 39' 28.06" E	Chord Bear = S 35° 59' 36.44" E	Chord Bear = S 43° 05' 47.38" E
Course from PT PRPATH8 to PC PRPATH9 S 22° 59' 02.25" E Dist 694.44	Course from PT PRPATH12 to PC PRPATH13 S 22° 59' 02.25" E Dist 314.57	Course from PT PRPATH16 to PC PRPATH17 S 22° 59' 02.25" E Dist 136.50
Curve Data **	Curve Data *——*	Curve Data *—*
Curve PRPATH9 P.I. Station 22+63.31 X 1,386,863.67 Y 454,140.02	Curve PRPATH13 P.I. Station 29+36.06 X 1,387,109.09 Y 453,522.98	Curve PRPATH17 P.I. Station 33+69.83 X 1,387,287.64 Y 453,140.42
Delta = 37° 07' 37.98" (RT)	Delta = 30° 07' 57.80" (RT)	Delta = 48° 32' 06.07" (RT)
Degree = 77° 25' 36.22" Tangent = 24.85	Degree = 77° 25' 36.22" Tangent = 19.92	Degree = 77° 25' 36.22" Tangent = 33.36
Length = 47.95	Length = 38.92	Length = 62.69
Radius = 74.00 External = 4.06	Radius = 74.00 External = 2.63	Radius = 74.00 External = 7.17
Long Chord = 47.12 Mid. Ord. = 3.85	Long Chord = 38.47 Mid. Ord. = 2.54	Long Chord = 60.83 Mid. Ord. = 6.54
P.C. Station 22+38.46 X 1,386,853.96 Y 454,162.90	P.C. Station 29+16.14 X 1,387,101.31 Y 453,541.31	P.C. Station 33+36.47 X 1,387,274.61 Y 453,171.13
P.T. Station 22+86.41 X 1,386,857.59 Y 454,115.92 C.C. X 1,386,785.84 Y 454,134.00	P.T. Station 29+55.06 X 1,387,106.61 Y 453,503.21 C.C. X 1,387,033.18 Y 453,512.42	P.T. Station 33+99.16 X 1,387,273.25 Y 453,110.32 C.C. X 1,387,206.49 Y 453,142.24
Back = S 22° 59' 02.25" E	Back = S 22° 59' 02.25" E	Back = S 22° 59' 02.25" E
Ahead = S 14° 08' 35.73" W Chord Bear = S 4° 25' 13.26" E	Ahead = S 7° 08' 55.55" W Chord Bear = S 7° 55' 03.35" E	Ahead = S 25° 33' 03.82" W Chord Bear = S 1° 17' 00.79" W
Curve Data	Curve Data	Curve Data
Curve PRPATH10	Curve PRPATH14	Curve PRPATH18
P.I. Station 23+11.27 X 1,386,851.52 Y 454,091.82 Delta = 37° 07' 37.98" (LT)	P.I. Station 29+74.98 X 1,387,104.13 Y 453,483.45 Delta = 30° 07' 57.80" (LT)	P.I. Station 34+32.52 X 1,387,258.86 Y 453,080.22 Delta = 48° 32' 06.07" (LT)
Degree = 77° 25' 36.22"	Degree = 77° 25' 36.22"	Degree = 77° 25' 36.22"
Tangent = 24.85 Length = 47.95	Tangent = 19.92 Length = 38.92	Tangent = 33.36 Length = 62.69
Radius = 74.00 External = 4.06	Radius = 74.00 External = 2.63	Radius = 74.00 External = 7.17
Long Chord = 47.12	Long Chord = 38.47	Long Chord = 60.83
Mid. Ord. = 3.85 P.C. Station 22+86.41 X 1,386,857.59 Y 454,115.92	Mid. Ord. = 2.54 P.C. Station 29+55.06 X 1,387,106.61 Y 453,503.21	Mid. Ord. = 6.54 P.C. Station 33+99.16 X 1,387,273.25 Y 453,110.32
P.T. Station 23+34.37 X 1,386,861.22 Y 454,068.94	P.T. Station 29+93.98 X 1,387,111.91 Y 453,465.11	P.T. Station 34+61.84 X 1,387,271.89 Y 453,049.51
C.C. X 1,386,929.35 Y 454,097.84 Back = S 14° 08' 35.73" W	C.C. X 1,387,180.03 Y 453,494.00 Back = S 7° 08' 55.55" W	C.C. X 1,387,340.01 Y 453,078.40 Back = S 25° 33' 03.82" W
Ahead = S 22° 59' 02.25" E Chord Bear = S 4° 25' 13.26" E	Ahead = S 22° 59' 02.25" E Chord Bear = S 7° 55' 03.35" E	Ahead = S 22° 59' 02.25" E Chord Bear = S 1° 17' 00.79" W
Course from PT PRPATH10 to PC PRPATH11 S 22° 59' 02.25" E Dist 200.00	Course from PT PRPATH14 to PC PRPATH15 S 22° 59' 02.25" E Dist 102.09	Course from PT PRPATH18 to 8001 S 22° 59' 02.25" E Dist 99.56
Curve Data	Curve Data	Point 8001 X 1,387,310.76 Y 452,957.86 Sta 35+61.40
Curve PRPATH11	Curve PRPATH15	
P.I. Station 25+51.46 X 1,386,946.00 Y 453,869.08 Delta = 26° 01' 08.39" (LT)	P.I. Station 31+23.16 X 1,387,162.35 Y 453,346.17 Delta = 40° 13' 30.26" (LT)	Ending chain PRPATH description
Degree = 77° 25' 36.22"	Degree = 77° 25' 36.22"	
Tangent = 17.10 Length = 33.60	Tangent = 27.10 Length = 51.95	
Radius = 74.00 External = 1.95	Radius = 74.00 External = 4.81	
Long Chord = 33.32	Long Chord = 50.89	
Mid. Ord. = 1.90 P.C. Station 25+34.37 X 1,386,939.32 Y 453,884.82	Mid. Ord. = 4.51 P.C. Station 30+96.06 X 1,387,151.77 Y 453,371.12	
P.T. Station 25+67.97 X 1,386,958.90 Y 453,857.86	P.T. Station 31+48.02 X 1,387,186.54 Y 453,333.96	
Back = S 22° 59' 02.25" E	Back = S 22° 59' 02.25" E	
Ahead = S 49° 00' 10.64" E Chord Bear = S 35° 59' 36.44" E	Ahead = S 63° 12' 32.51" E Chord Bear = S 43° 05' 47.38" E	

This document was originally issued and sealed by Ryan Schuehle, Registration Number PE- 10772, on 1/9/2020 and the original document is stored at the North Dakota Department of Transportation

Survey Data Layout

I-94 Business Loop from I-94 to 8th Street Shared Use Path, Bridge, and Lighting

STATE	PROJECT NO.	SECTION NO.	SHEET NO.
ND	IM-NHU-5-094(132)903	82	3

 

00.00+7 109 00+⊊ POT 2+00.00

00.00+7 T09 00+⊊ 00.00+S T09

Beginning chain PRFAIRWAY description

Point 8010 X 1,387,084.21 Y 453,389.55 Sta 2+00.00 Course from 8010 to 8011 N 67° 00' 59.15" E Dist 500.00 X 1,387,544.52 Y 453,584.78 Sta 7+00.00 _____ Ending chain PRFAIRWAY description


Beginning chain PR8THST description


X 1,387,252.21 Y 452,993.45 Sta 2+00.00 Course from 8020 to 8021 N 67° 00' 57.75" E Dist 500.00 Point 8021 X 1,387,712.52 Y 453,188.69 Sta 7+00.00 _____ Ending chain PR8THST description


> This document was originally issued and sealed by Ryan Schuehle, Registration Number PE- 10772, on 1/9/2020 and the original document is stored at the North Dakota Department of Transportation

Survey Data Layout

I-94 Business Loop from I-94 to 8th Street Shared Use Path, Bridge, and Lighting

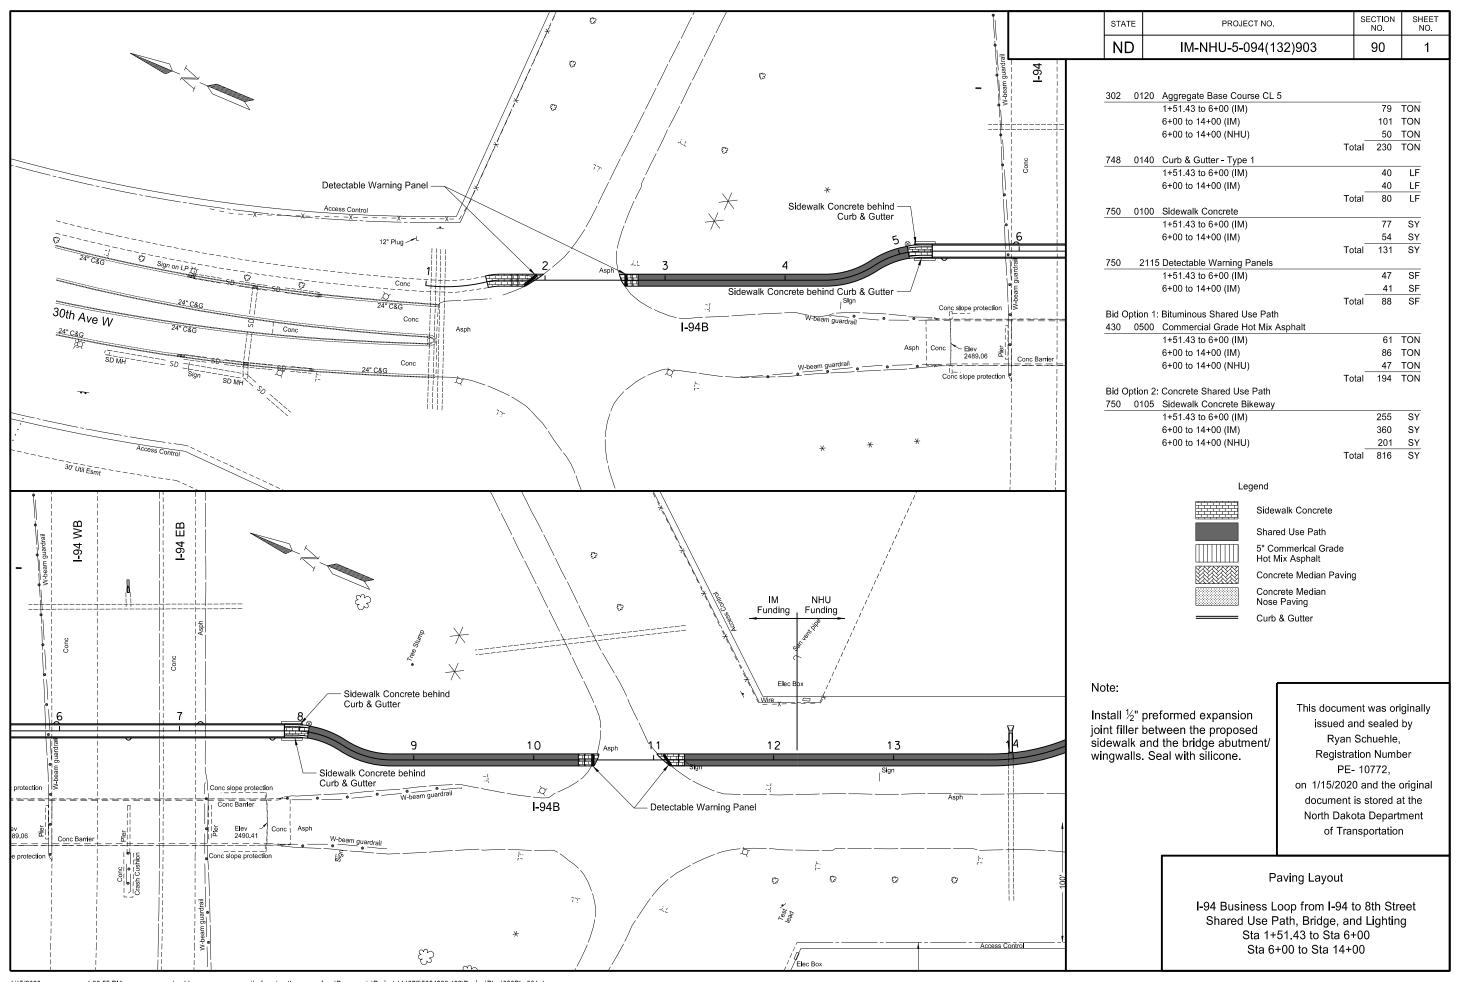

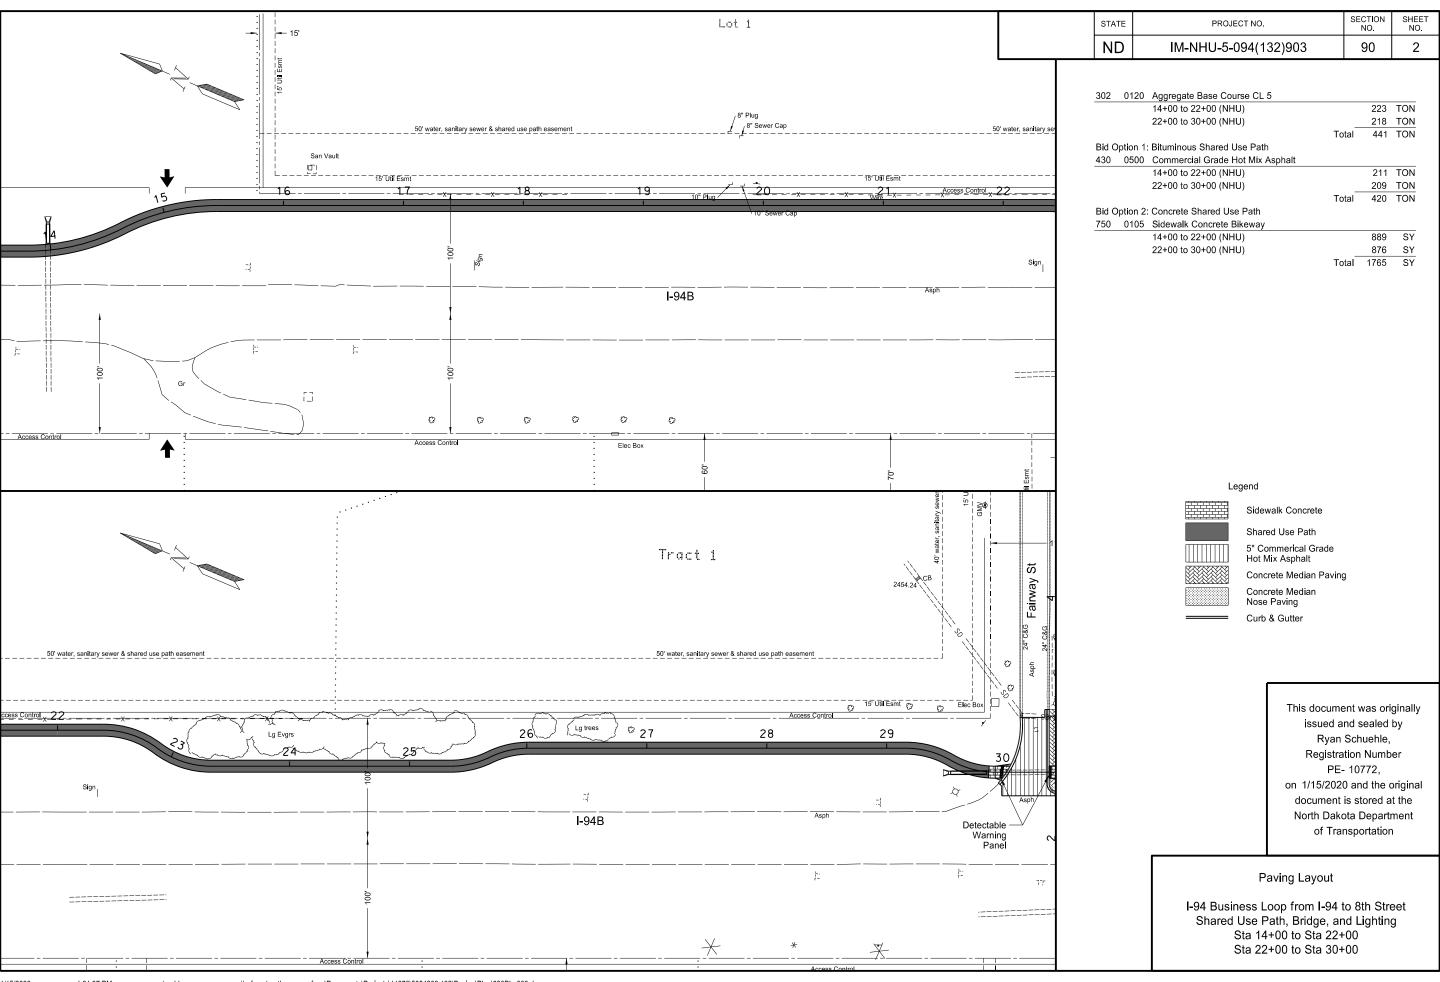

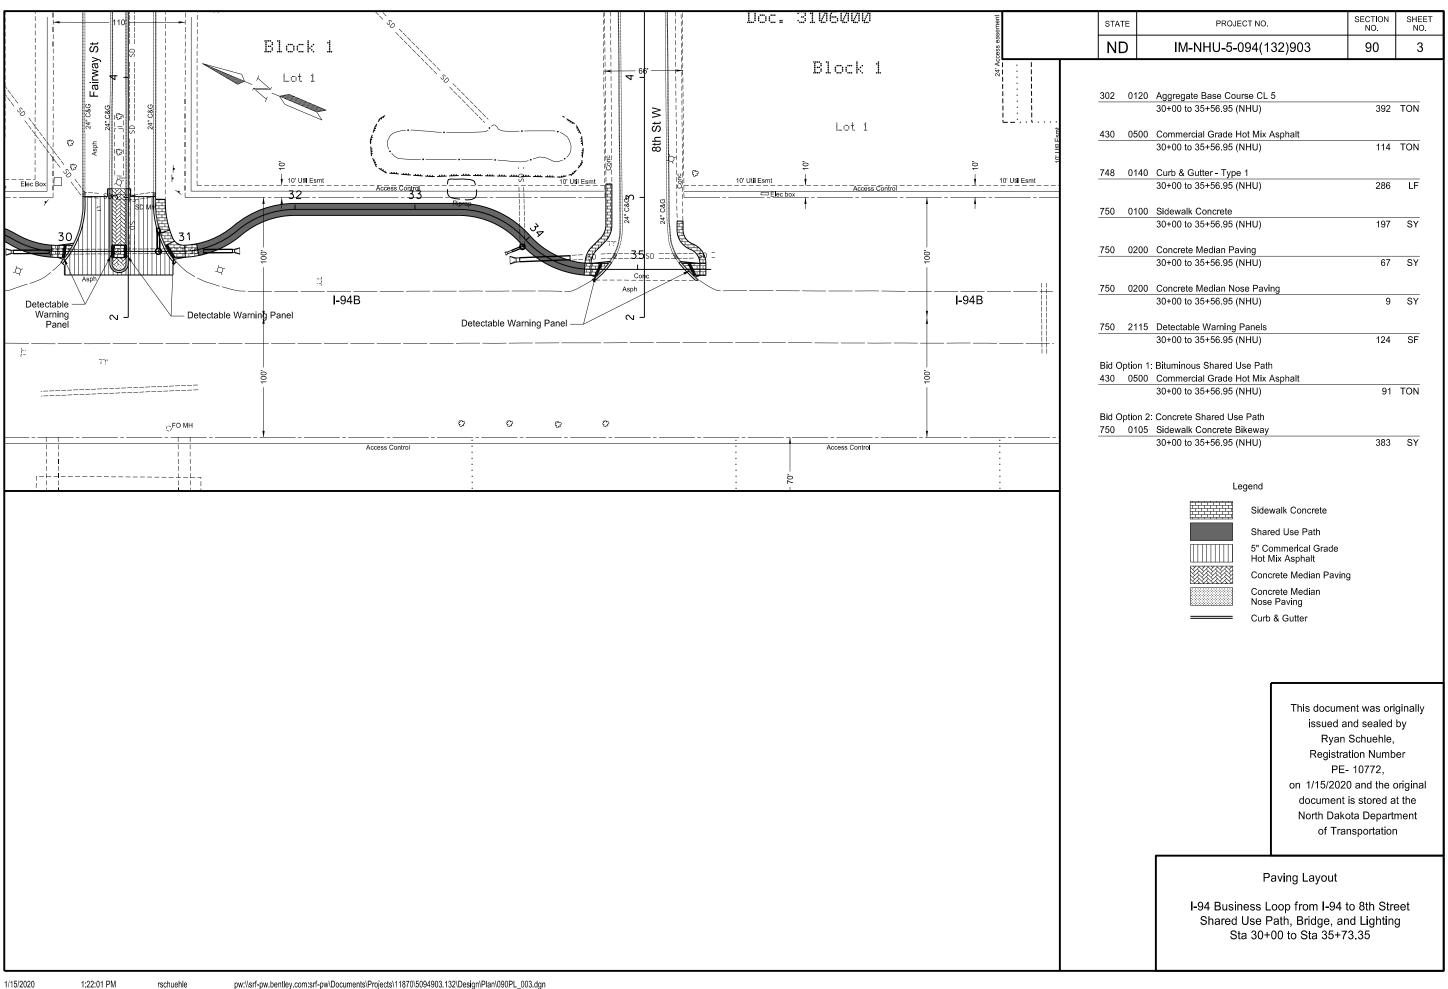

STATE	PROJECT NO.	SECTION NO.	SHEET NO.
ND	IM-NHU-5-094(132)903	100	1

SIGN NUMBER	SIGN SIZE	DESCRIPTION	AMOUNT REQUIRED	UNITS PER AMOUNT	UNITS SUB TOTA
E5-1-48	48"x48"	EXIT GORE	1	35	
G20-1-60	60"x24"	ROAD WORK NEXT MILES	1	28	
G20-1b-60 G20-2-48	60"x24" 48"x24"	NO WORK IN PROGRESS (Sign and installation only) END ROAD WORK	6	18 26	1
G20-2-46 G20-4-36	36"x18"	PILOT CAR FOLLOW ME (Mounted to back of pilot car)	- 6	18	1
G20-10-108	108"x48"	CONTRACTOR SIGN		70	
G20-50a-72	72"x36"	ROAD WORK NEXT MILES RT & LT ARROWS		43	
G20-52a-72	72"x24"	ROAD WORK NEXT MILES RT or LT ARROW		36	
G20-55-96	96"x48"	SPEED LIMIT ENFORCED - MINIMUM FEE \$80 WHEN WORKERS PRESENT	1	59	
M1-1-24	24"x24"	INTERSTATE ROUTE MARKER (Post and installation only)	2	10	
M1-1-36	36"x36"	INTERSTATE ROUTE MARKER (Post and installation only)		10	
M1-2-24	24"x24"	OFF-INTERSTATE BUSINESS ROUTE SIGN	6	14	
M1-4-24	24"x24"	U.S. ROUTE MARKER (Post and installation only)		10	
M1-5-24	24"x24"	STATE ROUTE MARKER (Post and installation only)		10	
M3-1-24 M3-2-24	24"x12"	NORTH (Mounted on route marker post)		7	
M3-2(I)-24	24"x12" 24"x12"	EAST (Mounted on route marker post) EAST (Mounted on route marker post)	2	7	
M3-3-24	24 X12 24"x12"	SOUTH (Mounted on route marker post)		7	
M3-4-24	24 X12 24"x12"	WEST (Mounted on route marker post)		7	
M3-4(I)-24	24"x12"	WEST (Mounted on route marker post)	2	7	
M4-5-24	24 X12 24"x12"		14	12	1
M4-8-24	24"x12"	DETOUR (Mounted on route marker post)	2	7	<u> </u>
VI4-8a-24	24"x18"	END DETOUR	2	13	
M4-9-30	30"x24"	DETOUR ARROW RIGHT or LEFT/AHD AND RT or LT		15	
//4-10-48	48"x18"	DETOUR (INSIDE ARROW) RIGHT or LEFT (Mounted on barricade)	1	7	
W5-1-21	21"x15"	ADVANCE TURN ARROW RT or LT(Mounted on route marker post)	6	7	
И5-1-30	30"x21"	ADVANCE TURN ARROW RT or LT(Mounted on route marker post)		9	
VI5-2(I)-21	21"x15"	ADVANCE TURN ARROW DIAGONAL RT or LT (Mounted on route marker post)	1	7	
/I6-1-21	21"x15"	DIRECTIONAL ARROW RT or LT (Mounted on route marker post)	5	7	
∕I6-1-30	30"x21"	DIRECTIONAL ARROW RT or LT (Mounted on route marker post)		9	
M6-2(I)-21	21"x15"	DIRECTIONAL ARROW DIAGONAL RT or LT (Mounted on route marker post)	1	7	
M6-3-21	21"x15"	DIRECTIONAL ARROW UP (Mounted on route marker post)	1	7	
R1-1-48	48"x48"	STOP	2	32	
R1-2-60	60"x60"	YIELD	1	29	
R2-1-36	36"x48"	SPEED LIMIT (Portable only)	16	30	
R2-1-48	48"x60"	SPEED LIMIT	10	39	:
R2-1aP-24	24"x18"	MINIMUM FEE \$80 (Mounted on Speed Limit post)	2	10	
R3-2-48	48"x48"	NO LEFT TURN		35	
R4-1-48	48"x60"	DO NOT PASS		39	
R4-7-48	48"x60"	KEEP RIGHT		39	
R5-1-48 R6-1-54	48"x48" 54"x18"	DO NOT ENTER		35 14	
R7-1-12	12"x18"	ONE WAY RIGHT or LEFT (Mounted on STOP or DO NOT ENTER post) NO PARKING ANY TIME		11	
R10-6-24	24"x36"	STOP HERE ON RED		16	
R11-2-48	48"x30"	ROAD CLOSED (Mounted on barricade)	1	12	
R11-2a-48	48"x30"	STREET CLOSED (Mounted on barricade)	2	12	
R11-3a-60	60"x30"	ROAD CLOSED MILES AHEAD LOCAL TRAFFIC ONLY (Mtd on barricade)		15	
R11-3c-60	60"x30"	STREET CLOSED MILES AHEAD LOCAL TRAFFIC ONLY (Mtd on barricade)		15	
R11-4a-60	60"x30"	STREET CLOSED TO THRU TRAFFIC (Mounted on barricade)	2	15	
W1-3-48	48"x48"	REVERSE TURN RIGHT or LEFT		35	
W1-4-48	48"x48"	REVERSE CURVE RIGHT or LEFT		35	
W1-4b-48	48"x48"	TWO LANE REVERSE CURVE RIGHT or LEFT		35	
W1-6-48	48"x24"	ONE DIRECTION LARGE ARROW		26	
N3-1-48	48"x48"	STOP AHEAD		35	
N3-3-48	48"x48"	SIGNAL AHEAD		35	
N3-4-48	48"x48"	BE PREPARED TO STOP		35	
N3-5-48	48"x48"	SPEED REDUCTION AHEAD	9	35	
N4-2-48	48"x48"	LANE ENDS RIGHT or LEFT	4	35	
N5-1-48	48"x48"	ROAD NARROWS		35	
N5-8-48	48"x48"	THRU TRAFFIC RIGHT LANE		35	
V5-9-48	48"x48"	ROAD WORK TRAFFIC ONLY DOWN & LT or RT ARROW		35	
N6-3-48	48"x48"	TWO WAY TRAFFIC		35	
N8-1-48	48"x48"	BUMP DAVEMENT ENDS		35	
N 8-3-48 N 8-7-48	48"x48"	PAVEMENT ENDS		35	
ıv ö- <i>ı</i> -48	48"x48" 48"x48"	LOOSE GRAVEL UNEVEN LANES		35 35	
N/8-11-40	48"x48" 48"x48"	NO CENTER LINE		35	
		SHOULDER DROP-OFF SYMBOL		35	
N8-12-48	48"v19"	TRUCKS ENTERING HIGHWAY		35	
V8-12-48 V8-17-48	48"x48"	TINGONG ENTERING HIGHWAT	2	35 35	
N8-12-48 N8-17-48 N8-53-48	48"x48"	TRUCKS ENTERING AHEAD or FT or MILE	-	35	
N8-12-48 N8-17-48 N8-53-48 N8-54-48	48"x48" 48"x48"	TRUCKS ENTERING AHEAD or FT or _ MILE TRUCKS CROSSING AHEAD or FT or _ MILE	2		
N8-12-48 N8-17-48 N8-53-48 N8-54-48 N8-55-48	48"x48" 48"x48" 48"x48"	TRUCKS CROSSING AHEAD or FT or _ MILE	2		
N 8-12-48 N 8-17-48 N 8-53-48 N 8-54-48 N 8-55-48 N 8-56-48	48"x48" 48"x48" 48"x48" 48"x48"	TRUCKS CROSSING AHEAD or FT or _ MILE TRUCKS EXITING HIGHWAY	2	35	
W8-12-48 W8-17-48 W8-53-48 W8-54-48 W8-55-48 W8-56-48 W9-3a-48	48"x48" 48"x48" 48"x48" 48"x48" 48"x48"	TRUCKS CROSSING AHEAD or FT or _ MILE TRUCKS EXITING HIGHWAY CENTER LANE CLOSED SYMBOL	2	35 35	
N8-12-48 N8-17-48 N8-53-48 N8-54-48 N8-56-48 N9-3a-48 N12-2-48	48"x48" 48"x48" 48"x48" 48"x48" 48"x48" 48"x48"	TRUCKS CROSSING AHEAD orFT orMILE TRUCKS EXITING HIGHWAY CENTER LANE CLOSED SYMBOL LOW CLEARANCE	2	35 35 35	
W8-12-48 W8-17-48 W8-53-48 W8-54-48 W8-55-48 W8-56-48 W9-3a-48 W12-2-48 W13-1P-30	48"x48" 48"x48" 48"x48" 48"x48" 48"x48" 48"x48" 30"x30"	TRUCKS CROSSING AHEAD or FT or _ MILE TRUCKS EXITING HIGHWAY CENTER LANE CLOSED SYMBOL LOW CLEARANCE MPH ADVISORY SPEED PLAQUE (Mounted on warning sign post)	2	35 35 35 14	
N8-12-48 N8-17-48 N8-53-48 N8-54-48 N8-55-48 N8-56-48 N9-3a-48 N12-2-48 N13-1P-30 N14-3-64	48"x48" 48"x48" 48"x48" 48"x48" 48"x48" 48"x48" 30"x30" 64"x48"	TRUCKS CROSSING AHEAD or FT or _ MILE TRUCKS EXITING HIGHWAY CENTER LANE CLOSED SYMBOL LOW CLEARANCE MPH ADVISORY SPEED PLAQUE (Mounted on warning sign post) NO PASSING ZONE	2	35 35 35 14 28	
N8-12-48 N8-17-48 N8-53-48 N8-54-48 N8-56-48 N8-56-48 N12-2-48 N13-1P-30 N14-3-64 N16-2P-30	48"x48" 48"x48" 48"x48" 48"x48" 48"x48" 48"x48" 30"x30" 64"x48" 30"x24"	TRUCKS CROSSING AHEAD or FT or _ MILE TRUCKS EXITING HIGHWAY CENTER LANE CLOSED SYMBOL LOW CLEARANCE MPH ADVISORY SPEED PLAQUE (Mounted on warning sign post) NO PASSING ZONE FEET PLAQUE (Mounted on warning sign post)		35 35 35 14 28 10	
W8-12-48 W8-17-48 W8-53-48 W8-54-48 W8-55-48 W8-56-48 W9-3a-48 W12-2-48 W13-1P-30 W14-3-64 W16-2P-30 W20-1-48	48"x48" 48"x48" 48"x48" 48"x48" 48"x48" 48"x48" 30"x30" 64"x48" 30"x24" 48"x48"	TRUCKS CROSSING AHEAD orFT or _ MILE TRUCKS EXITING HIGHWAY CENTER LANE CLOSED SYMBOL LOW CLEARANCEMPH ADVISORY SPEED PLAQUE (Mounted on warning sign post) NO PASSING ZONEFEET PLAQUE (Mounted on warning sign post) ROAD WORK AHEAD or _FT or _ MILE	7	35 35 35 14 28 10 35	
W8-12-48 W8-17-48 W8-53-48 W8-55-48 W8-56-48 W9-3a-48 W12-2-48 W13-1P-30 W14-3-64 W16-2P-30 W20-1-48 W20-2-48	48"x48" 48"x48" 48"x48" 48"x48" 48"x48" 48"x48" 30"x30" 64"x48" 30"x24" 48"x48" 48"x48"	TRUCKS CROSSING AHEAD or FT or MILE TRUCKS EXITING HIGHWAY CENTER LANE CLOSED SYMBOL LOW CLEARANCE MPH ADVISORY SPEED PLAQUE (Mounted on warning sign post) NO PASSING ZONE FEET PLAQUE (Mounted on warning sign post) ROAD WORK AHEAD or FT or MILE DETOUR AHEAD or FT or MILE	7 9	35 35 35 14 28 10 35 35	
W8-11-48 W8-12-48 W8-17-48 W8-53-48 W8-55-48 W8-56-48 W9-3a-48 W12-2-48 W13-1P-30 W14-3-64 W16-2P-30 W20-1-48 W20-3-48	48"x48" 48"x48" 48"x48" 48"x48" 48"x48" 48"x48" 30"x30" 64"x48" 30"x24" 48"x48"	TRUCKS CROSSING AHEAD orFT or _ MILE TRUCKS EXITING HIGHWAY CENTER LANE CLOSED SYMBOL LOW CLEARANCEMPH ADVISORY SPEED PLAQUE (Mounted on warning sign post) NO PASSING ZONEFEET PLAQUE (Mounted on warning sign post) ROAD WORK AHEAD or _FT or _ MILE	7	35 35 35 14 28 10 35	

SIGN NUMBER	SIGN SIZE	DESCRIPTION	AMOUNT REQUIRED	UNITS PER AMOUNT	UNITS SUB TOTAL
W20-7-48	48"x48"	FLAGGER	5	35	175
		STOP - SLOW PADDLE Back to Back	5	5	25
W20-52P-54	54"x12"	NEXT MILES (Mounted on warning sign post)		12	
W21-1-48	48"x48"	WORKERS	3	35	105
	48"x48"	FRESH OIL		35	
	48"x48"	ROAD MACHINERY AHEAD or FT or _ MILE		35	
W21-5-48	48"x48"	SHOULDER WORK	1	35	35
	48"x48"	RIGHT or LEFT SHOULDER CLOSED		35	
	48"x48"	RIGHT or LEFT SHOULDER CLOSED AHEAD or FT or _ MILE	4	35	140
W21-6-48	48"x48"	SURVEY CREW		35	
W21-50-48	48"x48"	BRIDGE PAINTING AHEAD or FT		35	
W21-51-48	48"x48"	MATERIAL ON ROADWAY		35	
	48"x48"	PAVEMENT BREAKS		35	
W21-53-48	48"x48"	RUMBLE STRIPS AHEAD		35	
W22-8-48	48"x48"	FRESH OIL LOOSE ROCK		35	

SPECIAL SI Consign 1	72"x24"	FAIRWAY ST	8	30	240

SPEC & CODE 704-1000 TRAFFIC CONTROL SIGNS TOTAL UNITS

If additional signs are required, units will be calculated using the formula from Section III-18.06 of the Design Manual. http://www.dot.nd.gov/ UNIT QUANTITY DESCRIPTION MHR EACH EACH

This document was originally issued and sealed by Ryan Schuehle, Registration Number PE-10772, on 1/17/20 and the original document

is stored at the North Dakota

Department of Transportation.

Traffic Control Devices List


I-94 Business Loop from I-94 to 8th St Shared Use Path, Bridge, and Lighting

CODE 704-0100 FLAGGING
704-1045 ATTENUATION DEVICE-TYPE B-75
704-1048 PORTABLE RUMBLE STRIPS
704-1050 TYPE I BARRICADES EACH 704-1052 TYPE III BARRICADES EACH 704-1060 DELINEATOR DRUMS EACH 704-1065 TRAFFIC CONES 704-1067 TUBULAR MARKERS EACH EACH 704-1070 DELINEATOR 704-1072 FLEXIBLE DELINEATORS EACH EACH 704-1080 STACKABLE VERTICAL PANELS EACH 704-1081 VERTICAL PANELS - BACK TO BACK EACH 704-1085 SEQUENCING ARROW PANEL - TYPE A EACH 704-1086 SEQUENCING ARROW PANEL - TYPE B EACH 704-1087 SEQUENCING ARROW PANEL - TYPE C EACH 704-1500 OBLITERATION OF PVMT MK
704-3501 PORTABLE PRECAST CONCRETE MED BARRIER 704-3510 PRECAST CONCRETE MED BARRIER - STATE FURNISHED EACH 112
 762-0200
 RAISED PAVEMENT MARKERS


 762-0420
 SHORT TERM 4IN LINE - TYPE R

 762-0430
 SHORT TERM 4IN LINE - TYPE NR
 EACH

SPEC &

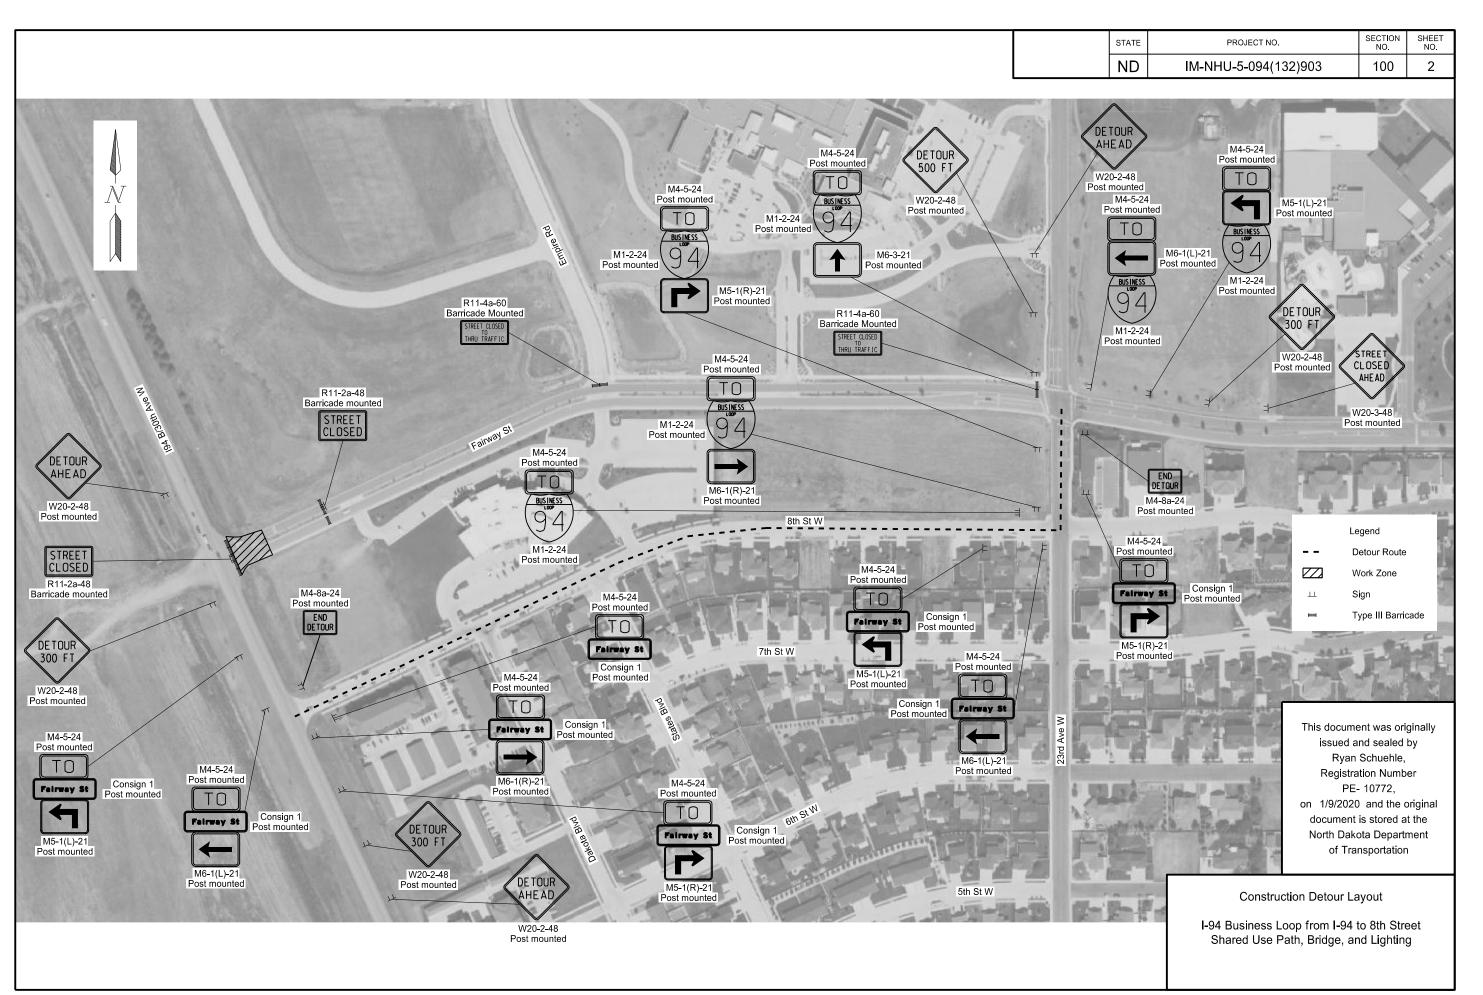

S ⁻	STATE	PROJECT NO.	SECTION NO.	SHEET NO.
1	ND	IM-NHU-5-094(132)903	100	3

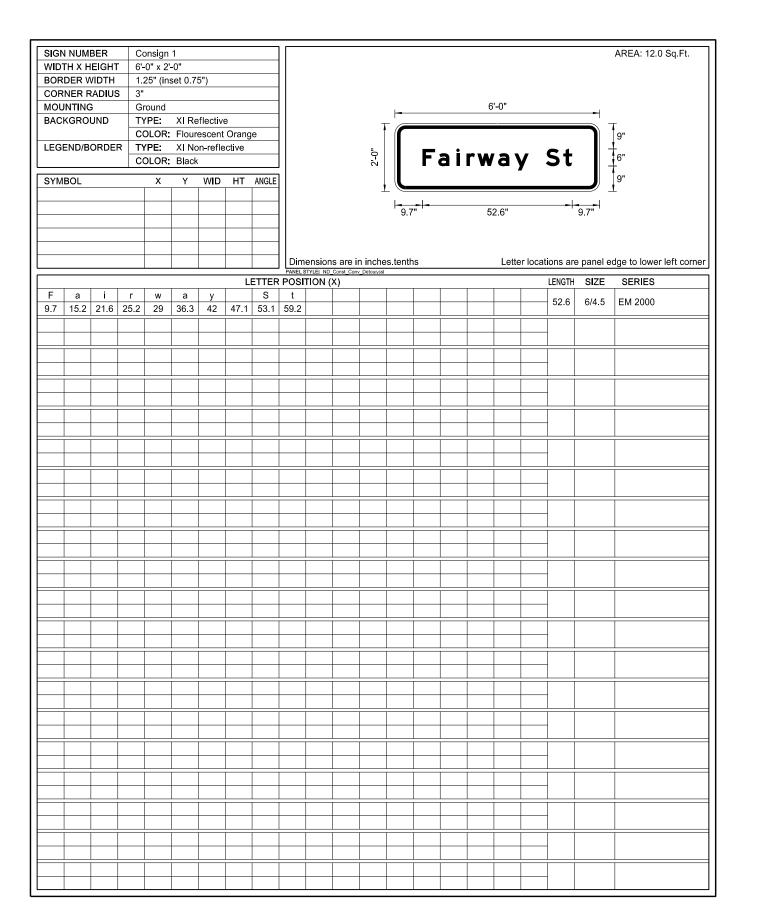

This document was originally issued and sealed by Ryan Schuehle, Registration Number PE- 10772, on 1/9/2020 and the original document is stored at the North Dakota Department of Transportation

Construction Sign Details

I-94 Business Loop from I-94 to 8th Street Shared Use Path, Bridge, and Lighting

N.D.	IM-NHU-5-094(132)903	110	1
STATE	PROJECT NO.	SECTION NO.	SHEET NO.

Station / RP	Sign No.	Assembly No.	Flat S For S IV SF		Sign S 1st LF	Support I 2nd LF	Length 3rd LF	4th LF	Vert Clear- ance FT	Support Size	Max Post Len LF	Sleeve 1st LF	Length 2nd LF	3rd LF	4th LF	Sleeve Size	Anchor . EA	Anchor LF	Anchor Size	Reset Sign Panel EA	Reset Sign Support EA	Break-Away EA	Comments
1+72 Rt		100		1.9	6.6				4.5	2 x 2 12 ga	21.4						1	4	2.25 x 2.25 12 ga				
2+73 Lt		100		1.9	6.6				4.5	2 x 2 12 ga	21.4						1	4	2.25 x 2.25 12 ga				
4+44 Rt										2 x 2 12 ga										1	2		
9+62 Rt	S.A. A									2 x 2 12 ga										1	1		
10+42 Rt		100		1.9	6.6				4.5	2 x 2 12 ga	21.4						1	4	2.25 x 2.25 12 ga				
10+44 Rt	S.A. C			14.0	10.6	10.6			5.0	2.25 x 2.25 12 ga	12.1						2	4	2.5 x 2.5 12 ga				
11+21 Rt	S.A. C			14.0	10.6	10.6			5.0	2.25 x 2.25 12 ga	12.1						2	4	2.5 x 2.5 12 ga				
11+21 Lt				1.9	6.6				4.5	2 x 2 12 ga	21.4						1	4	2.25 x 2.25 12 ga				
11+37 Rt	S.A. B									2 x 2 12 ga										1	3		
30+04 Lt	S.A. 4E									2 x 2 12 ga										1	1		
34+78 Lt	S.A. 4E			5.2	12.2				5.0	2.5 x 2.5 12 ga	13.3						1	4	3 x 3 7 ga	1			
Sub Total			0.0	40.8		Total	81.0										Total	36.0		5	7	0	
Grand Total			0.0	40.8		Total	81.0										Total	36	0	5	7	0	

This document was originally issued and sealed by Ryan Schuehle, Registration Number 10772, on 1/9/20 and is stored at the North Dakota Department of Transportation.

Sign Summary Perforated Tube

I-94 Business Loop from I-94 to 8th Street

1/9/20 2:33:12PM

Page 1 of 1

Γ	N.D.	IM-NHU-5-094(132)903	110	2
	STATE	PROJECT NO.	SECTION NO.	SHEET NO.


	Sign /	Flat She For Sigr		Pane For Sig		Overla Pane		Vert (el Sheet rd Pipe			v Steel Pos Shape Post		Max Post	Post	Revise Fuse	Sto	d Pipe F	dn	W-Shape	Conc		Sign	Sign	Stub	
Station / RP	Assembly No.		XI SF	IV SF	XI SF	IV SF	XI SF	ance FT	1st LF	2nd LF	Size	1st LF	2nd LF	3rd LF	Len LF	Space FT	Joint EA	Dia FT	Dep FT	Vol CY	Pile LF	Fdn EA	Pile EA	Panel EA	Support EA		
1+93 Lt								5.0	14.6		4.0				15.6			1.3	7.5	0.4		1		1			
3+37 Rt	17							5.0	10.8		3.5				15.6							1		1			
11+97 Rt	17							5.0	9.8		3.5				15.6			1.3	5.0	0.3		1		1			
12+88 Rt								5.0			W4x13	14.6	14.9		16.9	3.8					28		2	1			
Sub Total								Tot	al 35	.2		Total	29.5							0.7	28	3	2	4	0	0	0
Grand Total								Tot	al 35	.2		Total	29.5	,						0.7	28	3	2	4	0	0	0


This document was originally issued and sealed by Ryan Schuehle, Registration Number 10772, on 1/9/20 and is stored at the North Dakota Department of Transportation.


Sign Summary Round Steel Pipe & W-Shape


I-94 Business Loop from I-94 to 8th Street

1/9/20 2:32:01PM Page 1 of 1

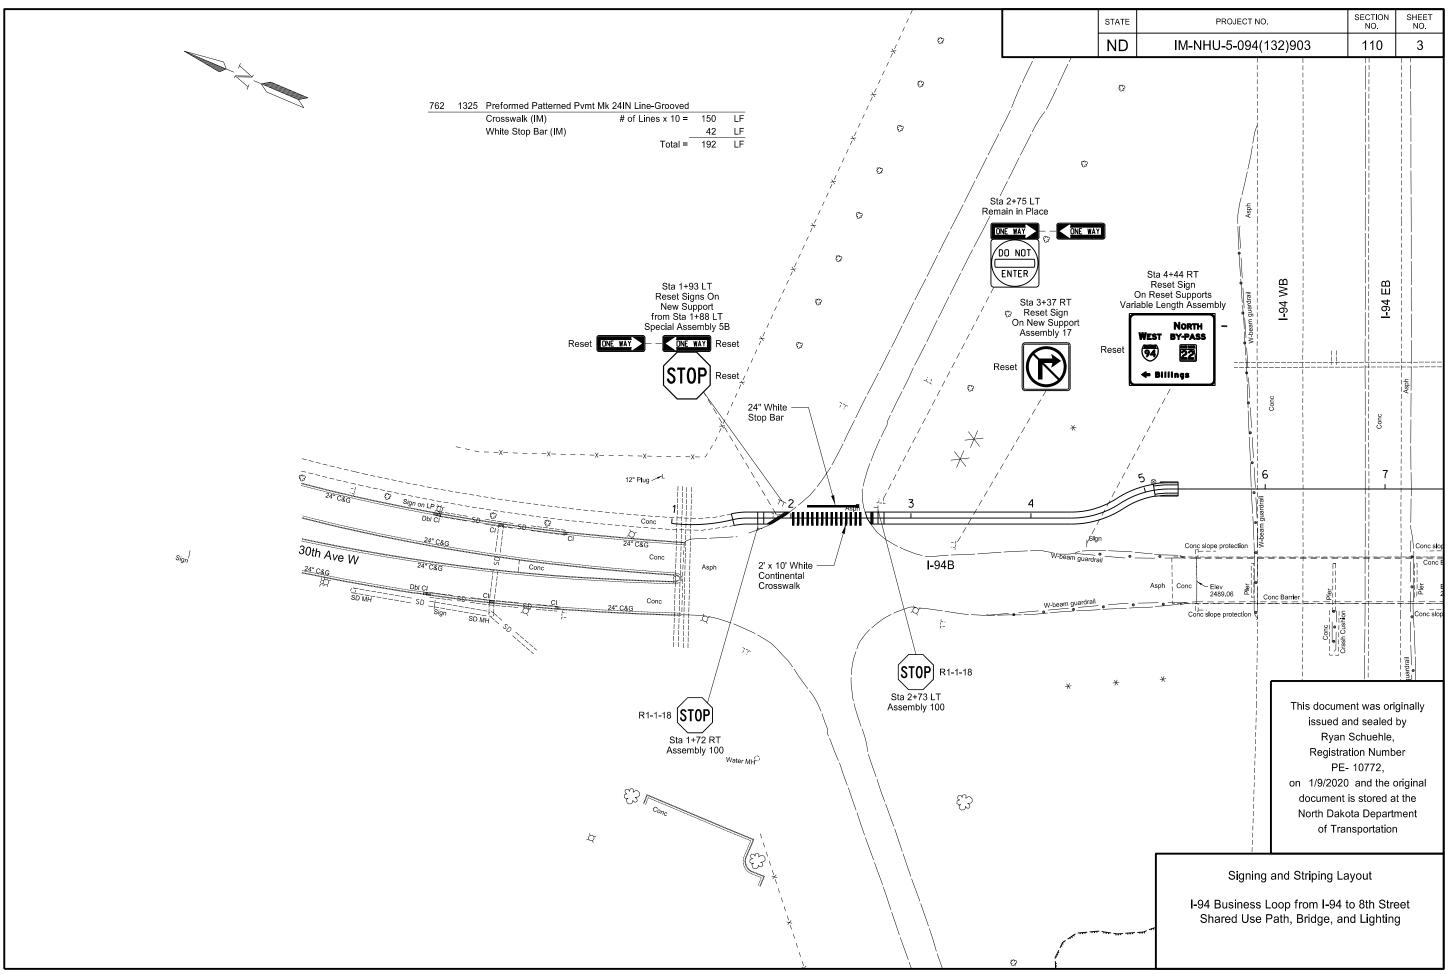


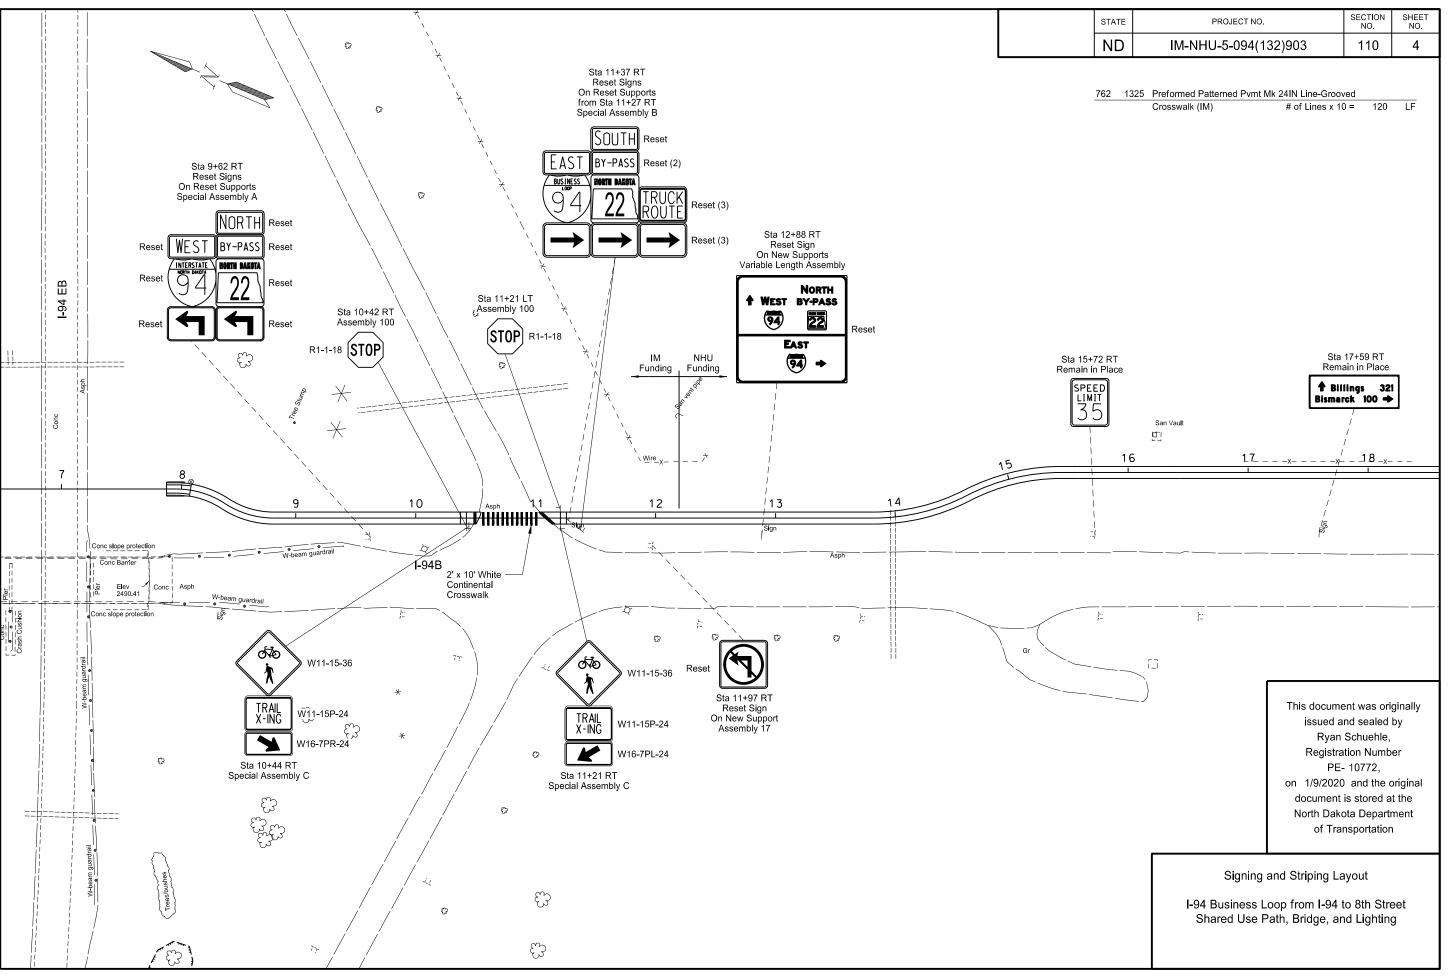

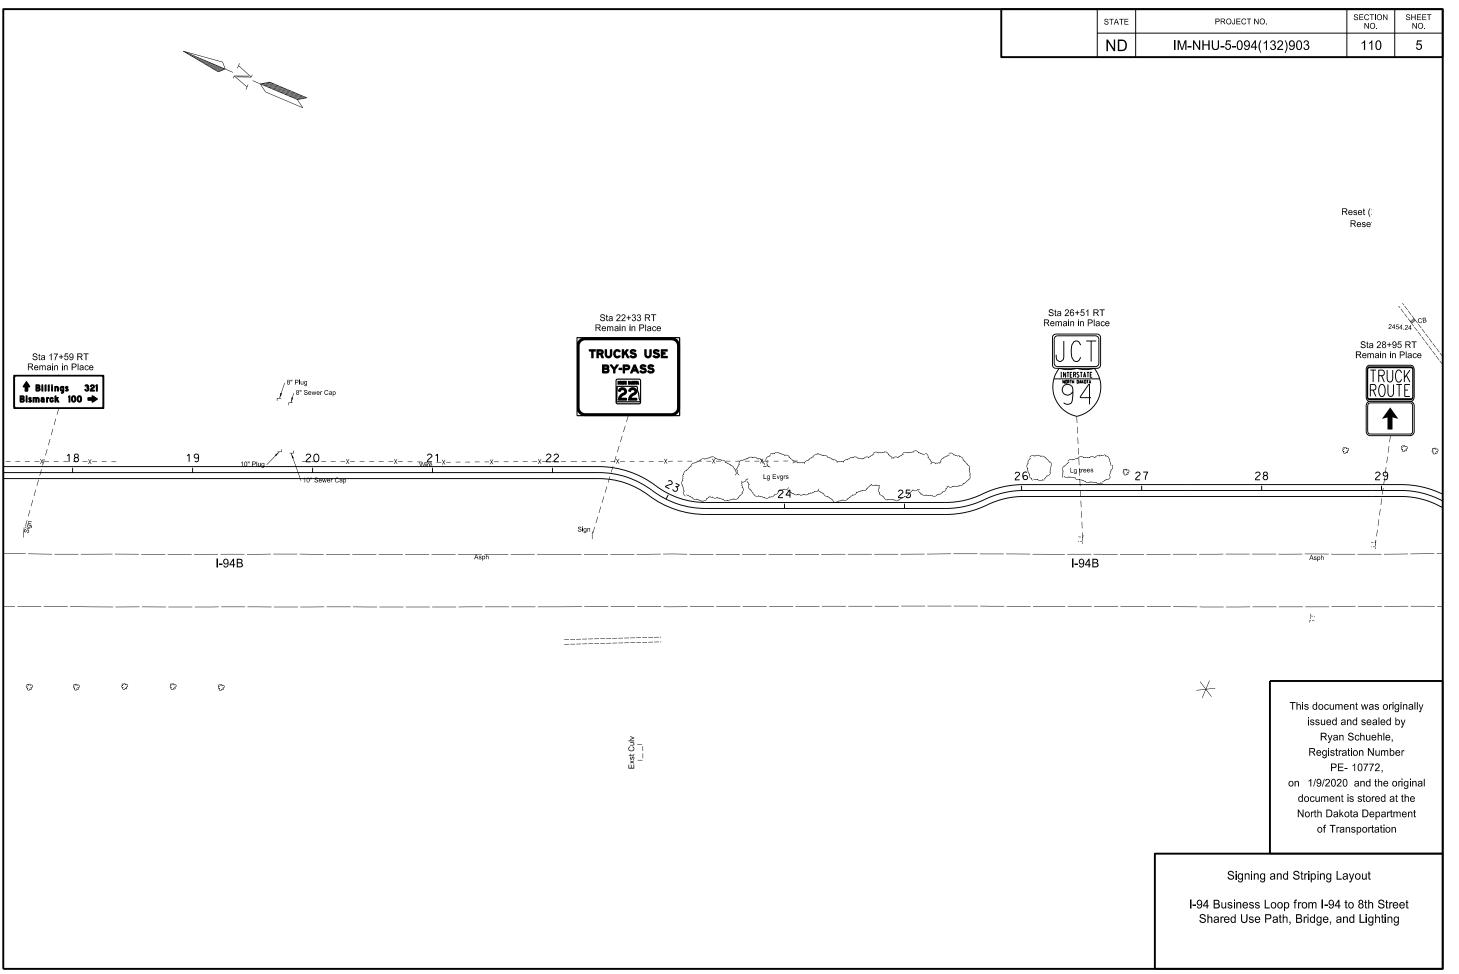

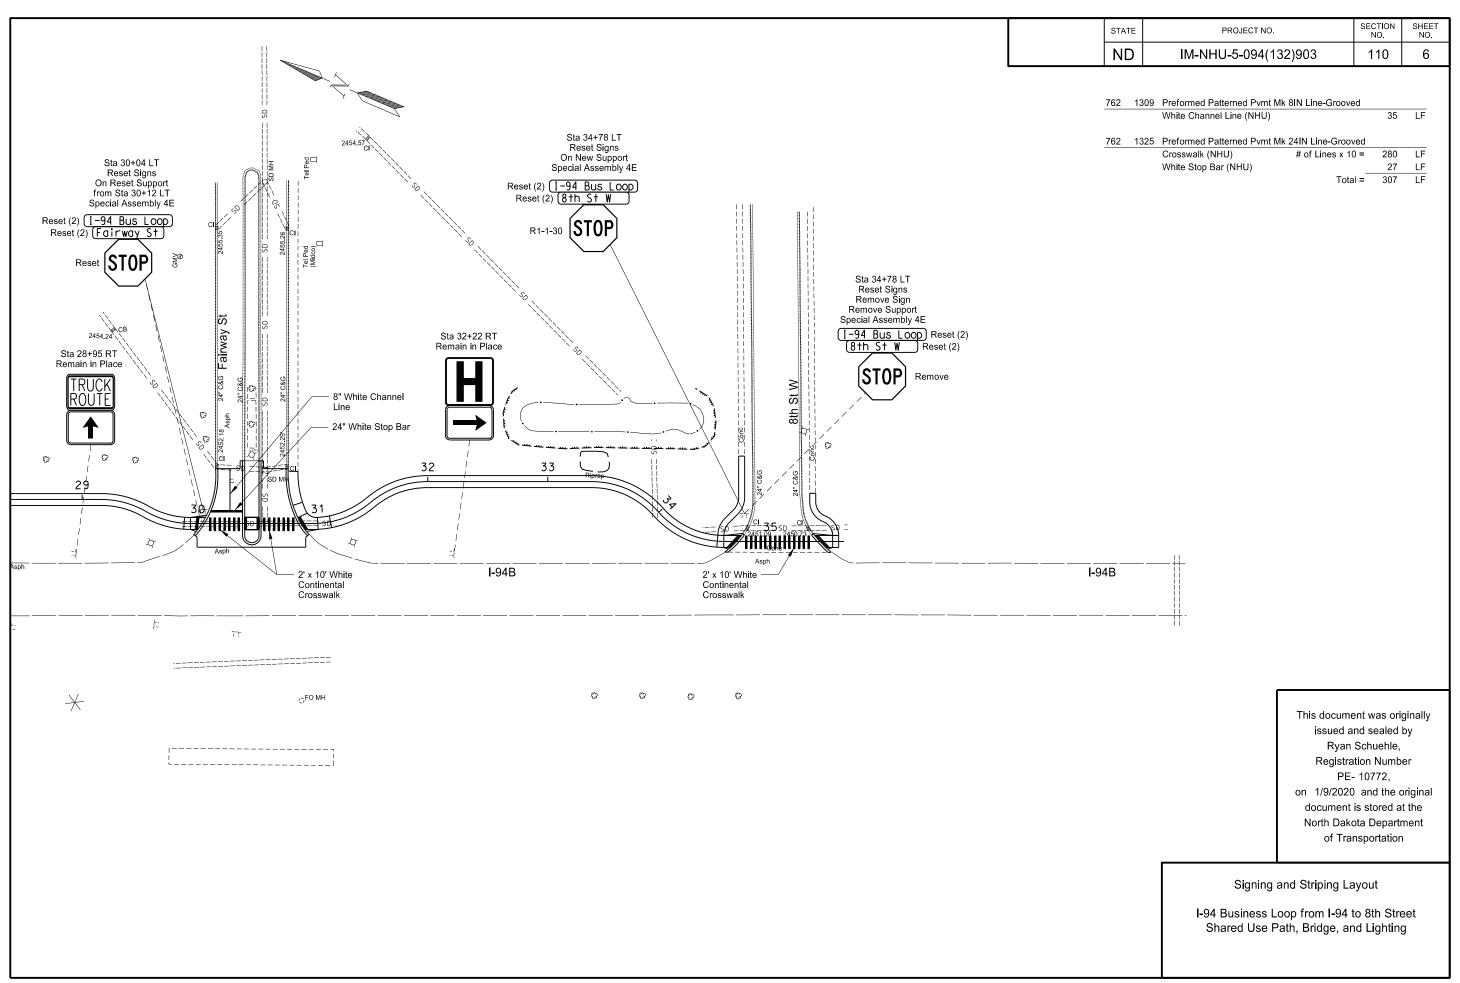


STATE	PROJECT NO.	SECTION NO.	SHEET NO.
ND	IM-NHU-5-094(132)903	110	7

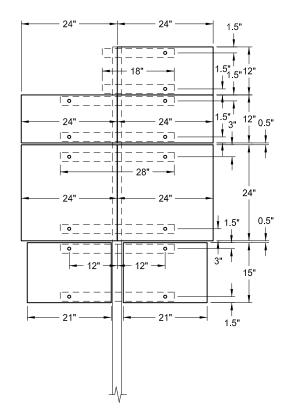


Special Assembly A Sta 9+62 RT (PRPATH)

Pay Area: 16.2 SF

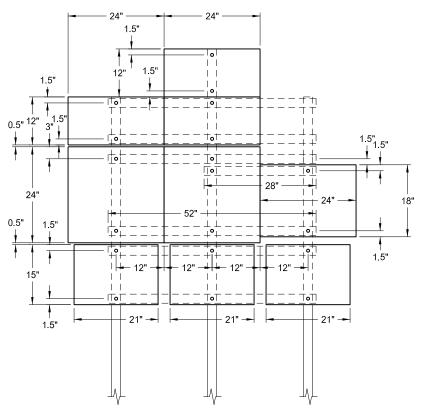

Special Assembly B Sta 11+37 RT (PRPATH)

Pay Area: 23.6 SF

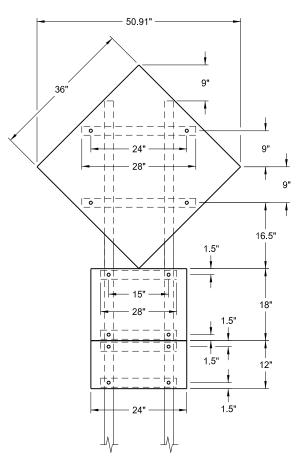

Special Assembly C Sta 10+44 RT Sta 11+21 RT (PRPATH)


Pay Area: 14.0 SF


This document was originally issued and sealed by Ryan Schuehle, Registration Number PE- 10772, on 1/9/2020 and the original document is stored at the North Dakota Department of Transportation


Signing Details

 
I-94 Business Loop from I-94 to 8th Street Shared Use Path, Bridge, and Lighting

Special Assemblies

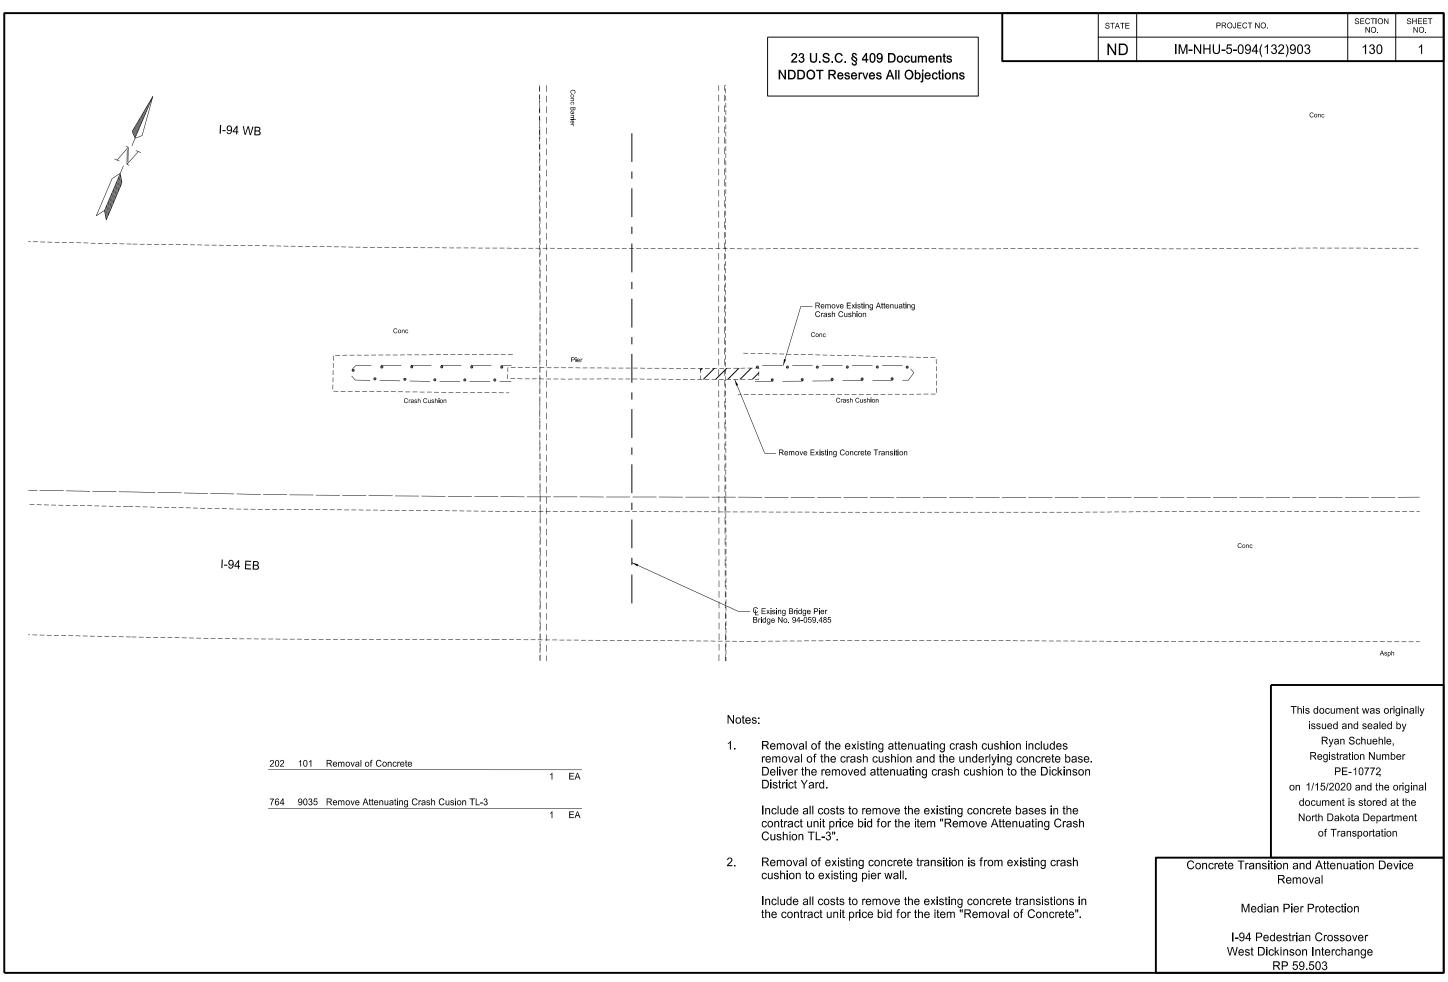


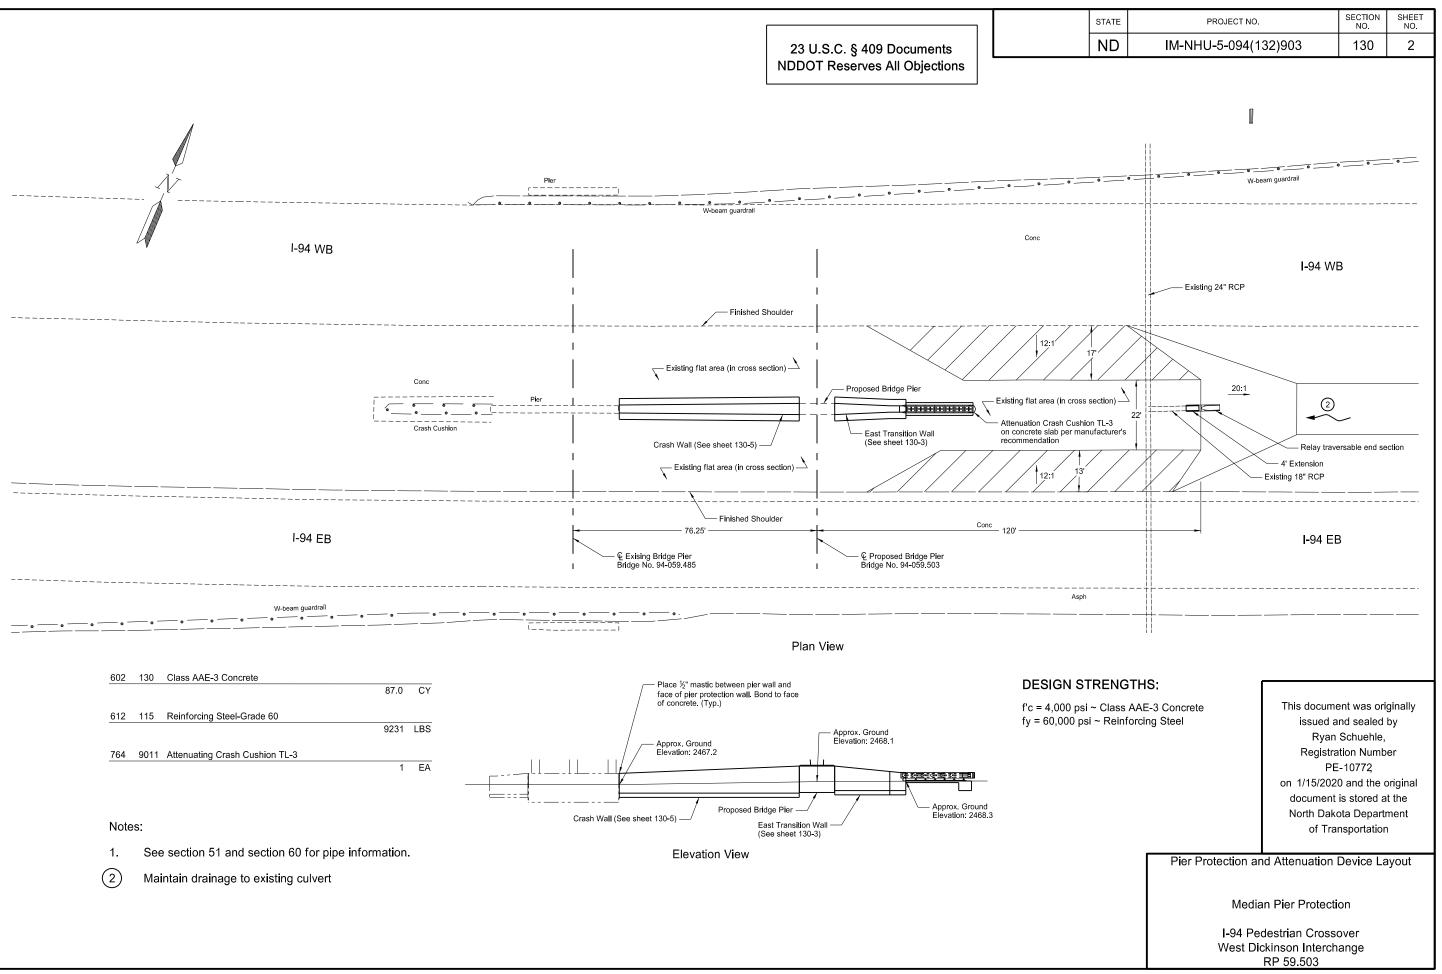


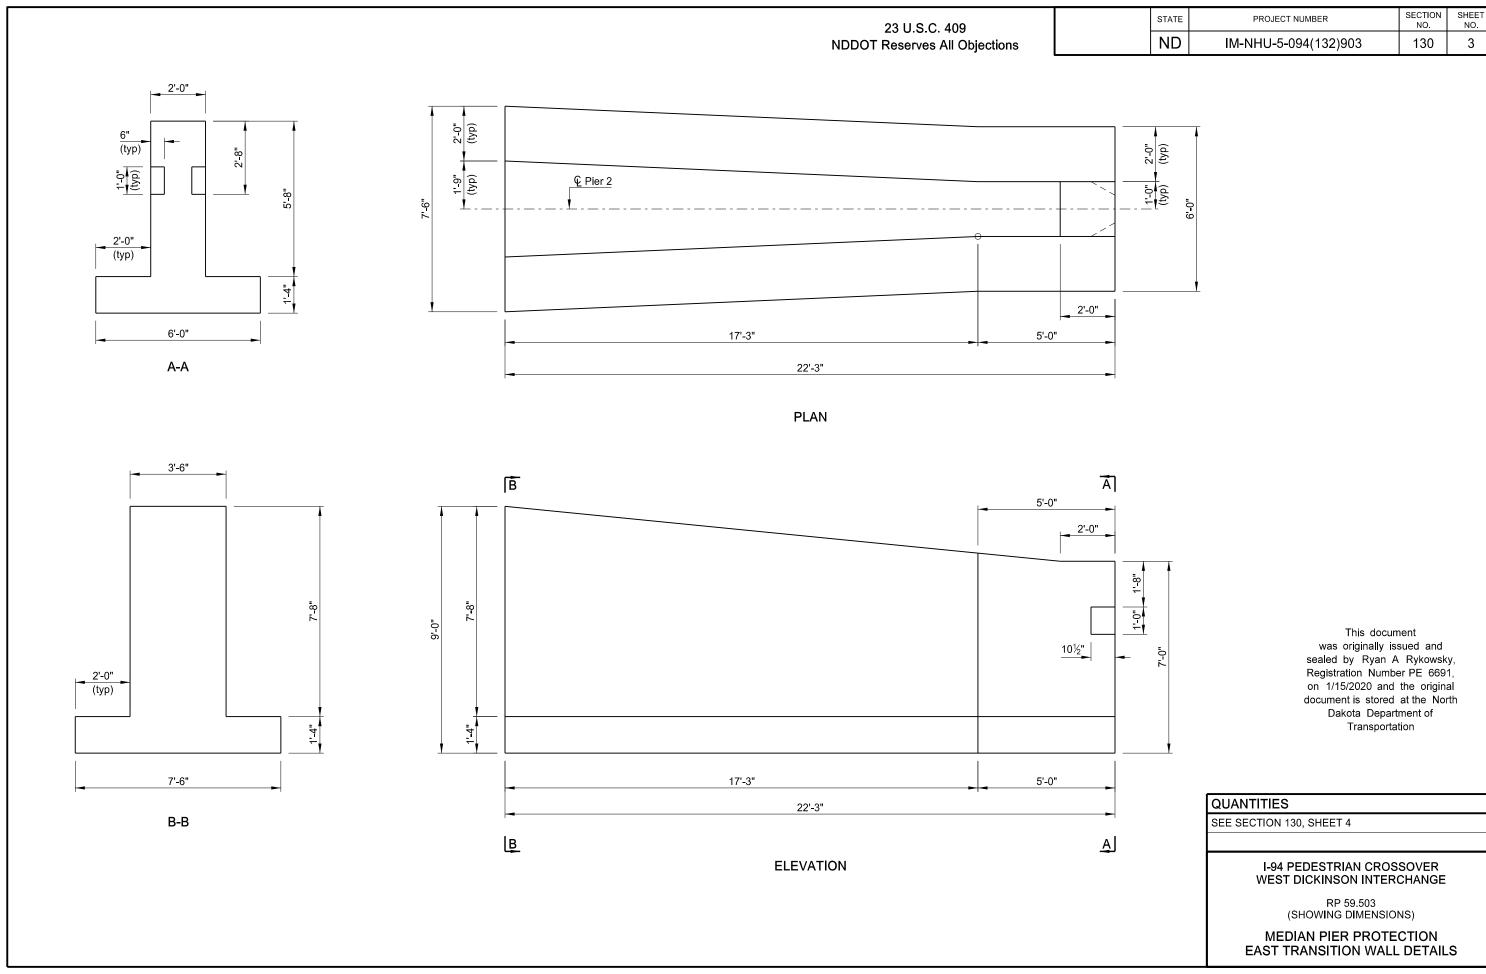




STATE	PROJECT NUMBER	SECTION NO.	SHEET NO.
ND	IM-NHU-5-094(132)903	130	4

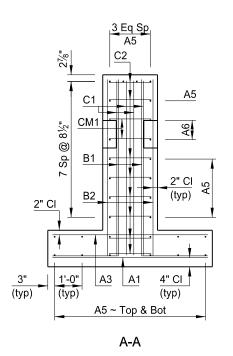

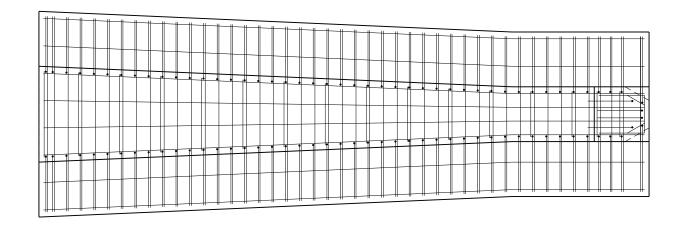


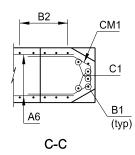


PLAN

NOTE:

Field bend A5-A9 bars to fit.

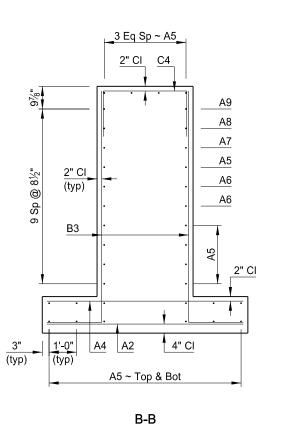

rschuehle

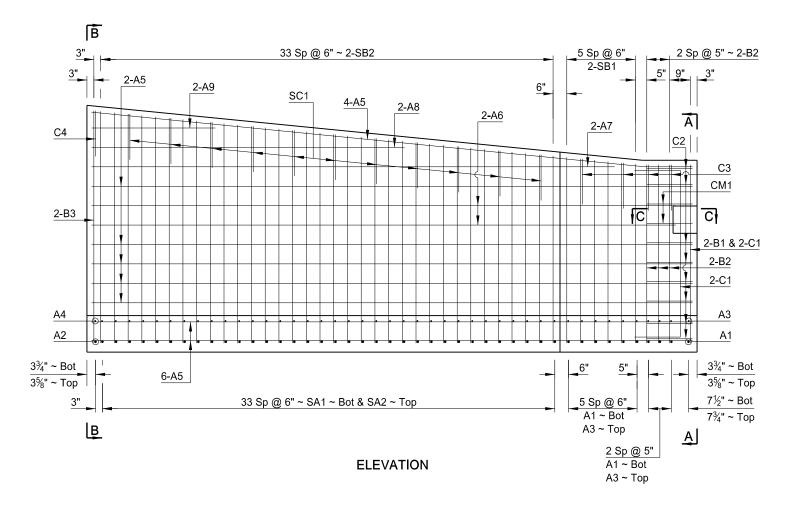


This document
was originally issued and
sealed by Ryan A Rykowsky,
Registration Number PE 6691,
on 1/15/2020 and the original
document is stored at the North
Dakota Department of
Transportation

QUANTITIES	
CLASS AAE-3 CONRETE	21.5 CY
REINFORCING STEEL	2,570 LBS


I-94 PEDESTRIAN CROSSOVER WEST DICKINSON INTERCHANGE

RP 59.503 (SHOWING REINFORCING)


MEDIAN PIER PROTECTION EAST TRANSITION WALL DETAILS

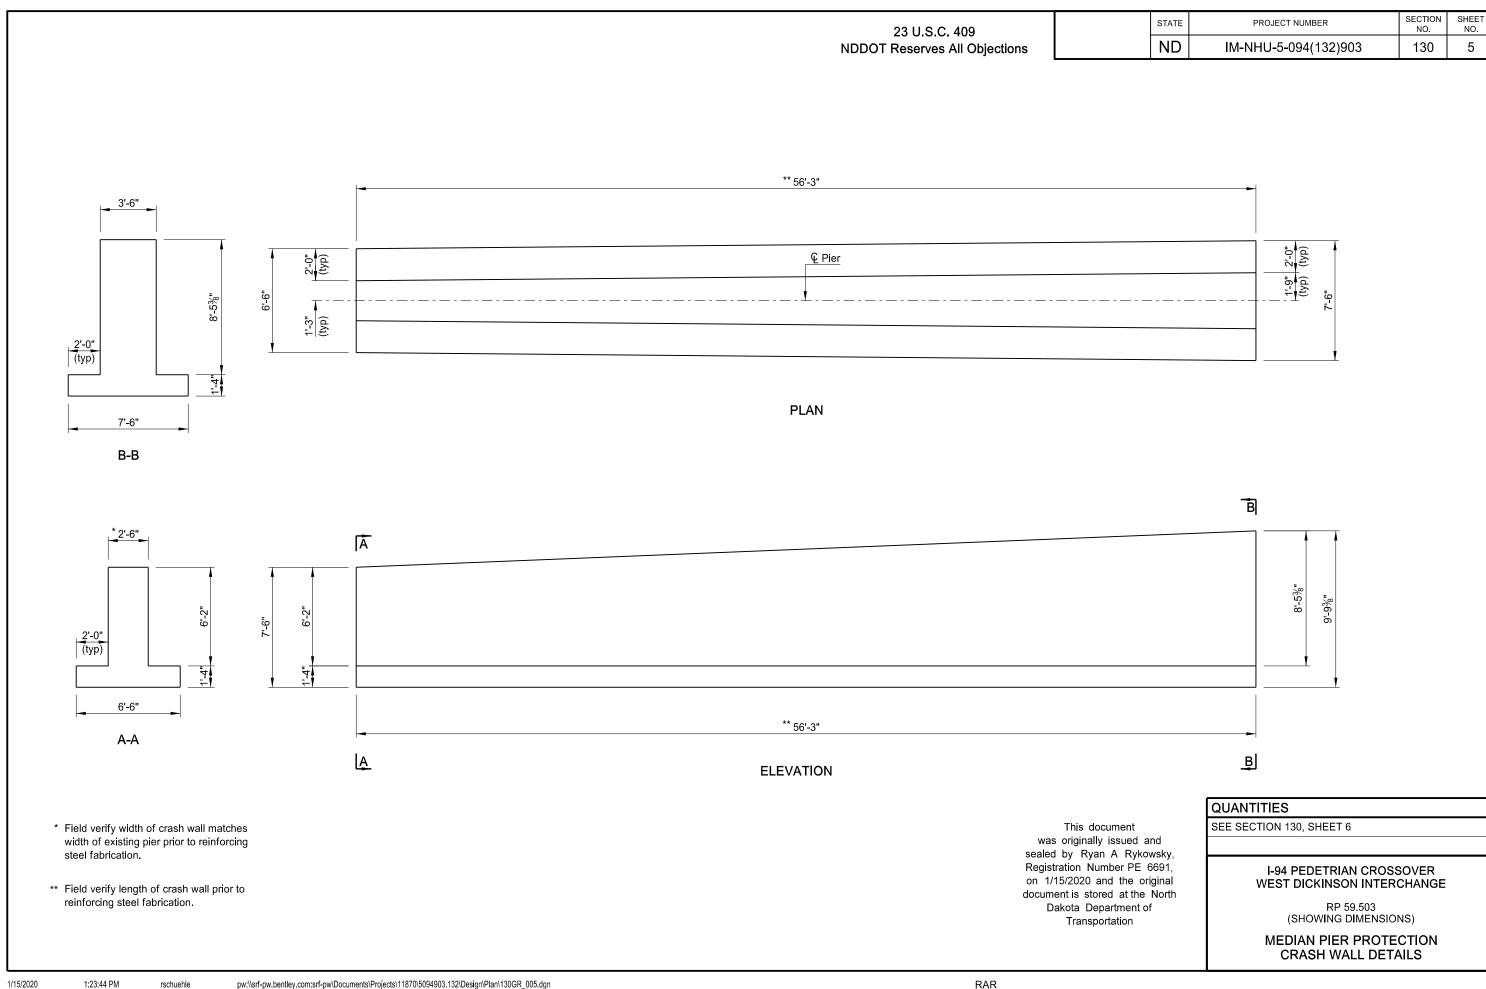

STATE	PROJECT NUMBER	SECTION NO.	SHEET NO.
ND	IM-NHU-5-094(132)903	130	6

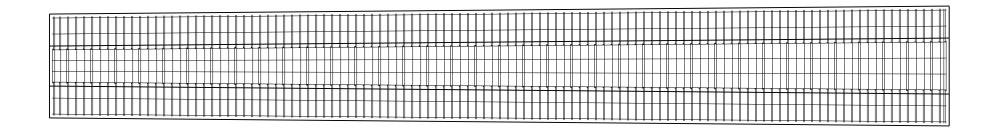



PLAN

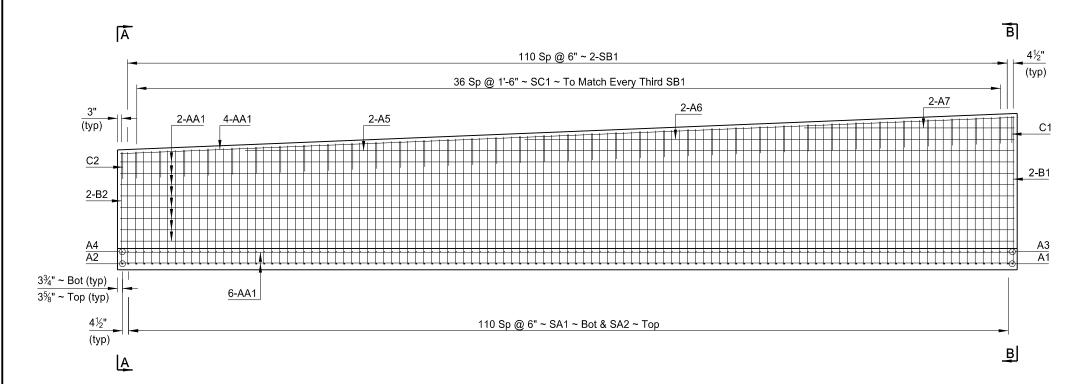

ELEVATION

This document
was originally issued and
sealed by Ryan A Rykowksy,
Registration Number PE 6691,
on 1/15/2020 and the original
document is stored at the North
Dakota Department of
Transportation

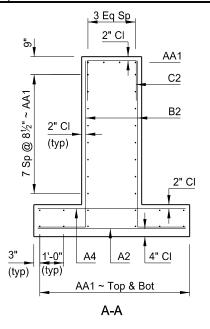

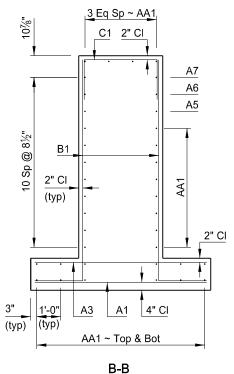

ь


QUANTITIES	
CLASS AAE-3 CONCRETE	65.5 CY
REINFORCING STEEL	6661 LBS

I-94 PEDESTRIAN CROSSOVER WEST DICKINSON INTERCHANGE

RP 59.503 (SHOWING REINFORCING)


MEDIAN PIER PROTECTION CRASH WALL DETAILS

 BILL OF REINFORCING STEEL, GRADE 60 LETTER PREFIX OF BAR MARK DENOTES SHAPE ~ SEE BAR DETAILS NO. EACH /SET **DETAILING DIMENSIONS** NOMINAL LOCA-SIZE MARK TION LENGTH b d e f h **A**1 10 5'-8" 5'-8" 6 A2 1 7'-1" 7'-1" 4 А3 10 5'-8" 5'-8" 4 A4 7'-1" 7'-1" 4 A5 26 21'-11" 21'-11" 4 A6 4 21'-4" 21'-4" 4 19'-1" Α7 2 19'-1" 4 A8 11'-5" 11'-5" 2 4 Α9 4'-6" 4'-6" 2 EAST TRANSITION WALL 6 В1 2 8'-11" 6'-6" 2'-5" 6 B2 6 8'-6" 6'-6" 2'-0" 6 В3 2 10'-5" 8'-5" 2'-0" 6 C1 4 9'-8" 1'-8" 6'-4" 1'-8" 5 C2 8 4'-10½" 1'-8" 1'-6½" 1'-8" 5 C3 4 5'-0" 1'-8" 1'-8" 1'-8" 5 3'-2" C4 6'-6" 1'-8" 1'-8" 5 CM1 2 5'-8" 1'-8" 10" 8" 10" 1'-8" 6 SA1 216'-9" 5'-8" 7'-1" 33 4 SA2 216'-9" 5'-8" 7'-1" 33 6 SB1 2 51'-9" 2'-0" 6'-6" 2'-0" 6'-9" 5 6 SB2 2 327'-3" 2'-0" 6'-10" 2'-0" 8'-5" 33 5 SC1 63'-0¼" 1'-9" 1'-8" 1'-8" 3'-0½" 10 7'-2" 6 Α1 7'-2" 6 A2 6'-2" 6'-2" 4 7'-2" A3 7'-2" 4 A4 6'-2" 6'-2" 4 A5 2 48'-1" 48'-1" 4 A6 2 30'-7" 30'-7" 4 Α7 2 13'-2" 13'-2" 6 В1 11'-3" 9'-3" 2'-0" 2 9'-0" 2'-0" 6 B2 7'-0" 2 CRASH WALL 5 5 C1 6'-6" 1'-8" 3'-2" 1'-8" C2 1 5'-6" 1'-8" 2'-2" 1'-8" 735'-4½" 7'-1" 110 6 SA1 6'-2" 4 SA2 735'-4½" 6'-2" 7'-1" 110 6 SB1 2 1123'-101/5" 2'-0" 7'-0" 2'-0" 9'-3" 110 5 2'-21/4" SC1 222'-0" 1'-8" 1'-8" 3'-1¾" 36 4 32 57'-8" 40"-0" 55'-11" AA1 1'-9" 17'-8"





STATE PROJECT NUMBER		SECTION NO.	SHEET NO.
ND	IM-NHU-5-094(132)903	130	7




 


* b = Vertical Leg

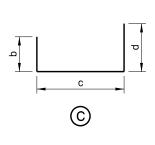

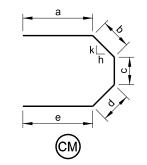


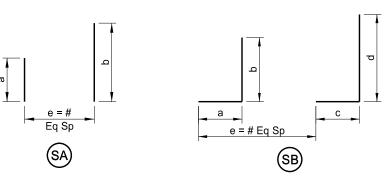

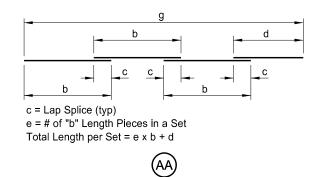

NOTES:

- Verify the quantity, size, and shape of the bar reinforcement against the structure drawings and immediately notify the Engineer of any discrepancies. Discrepancies in the bar list will not be cause for adjustment of the contract unit price.
- 2. All dimensions are out to out of bars.
- 3. Nominal length of each bent bar or cut bar is the sum total of the detailing dimensions for that bar, unless otherwise noted.
- 4. Turn adjacent "AA" bars end for end so that the splice locations are staggered.
- 5. Add a bar designation to differentiate between the wall units.

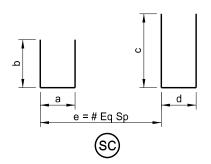


This document
was originally issued and
sealed by Ryan A Rykowsky,
Registration Number PE 6691,
on 1/15/2020 and the original
document is stored at the North
Dakota Department of
Transportation


I-94 PEDETRIAN CROSSOVER WEST DICKINSON INTERCHANGE


RP 59.503


REINFORCING BAR LIST & DETAILS

1/15/2020

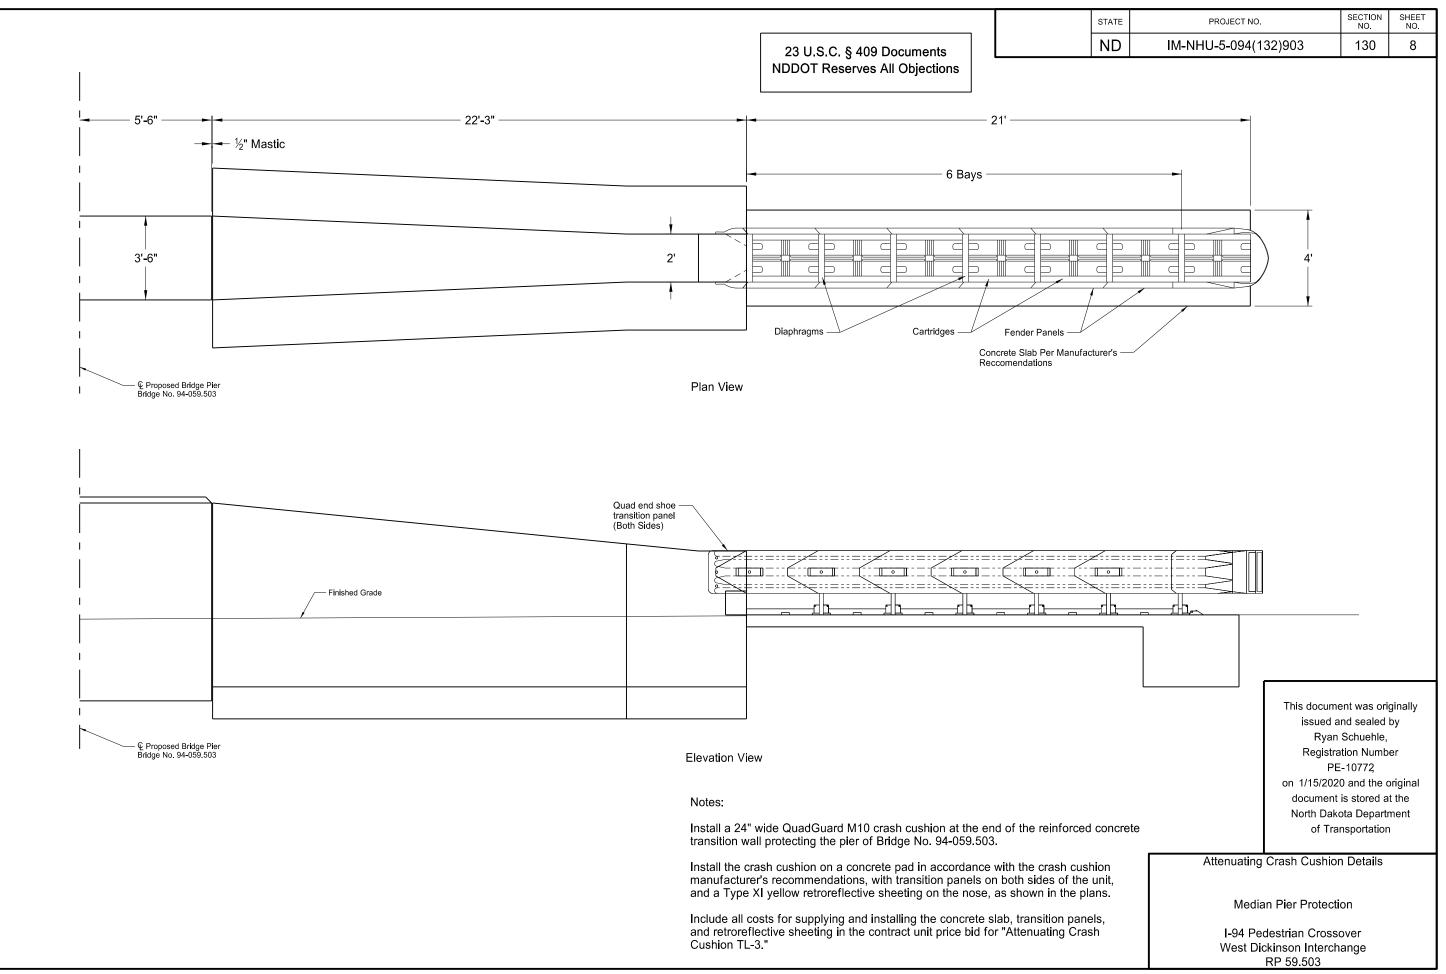

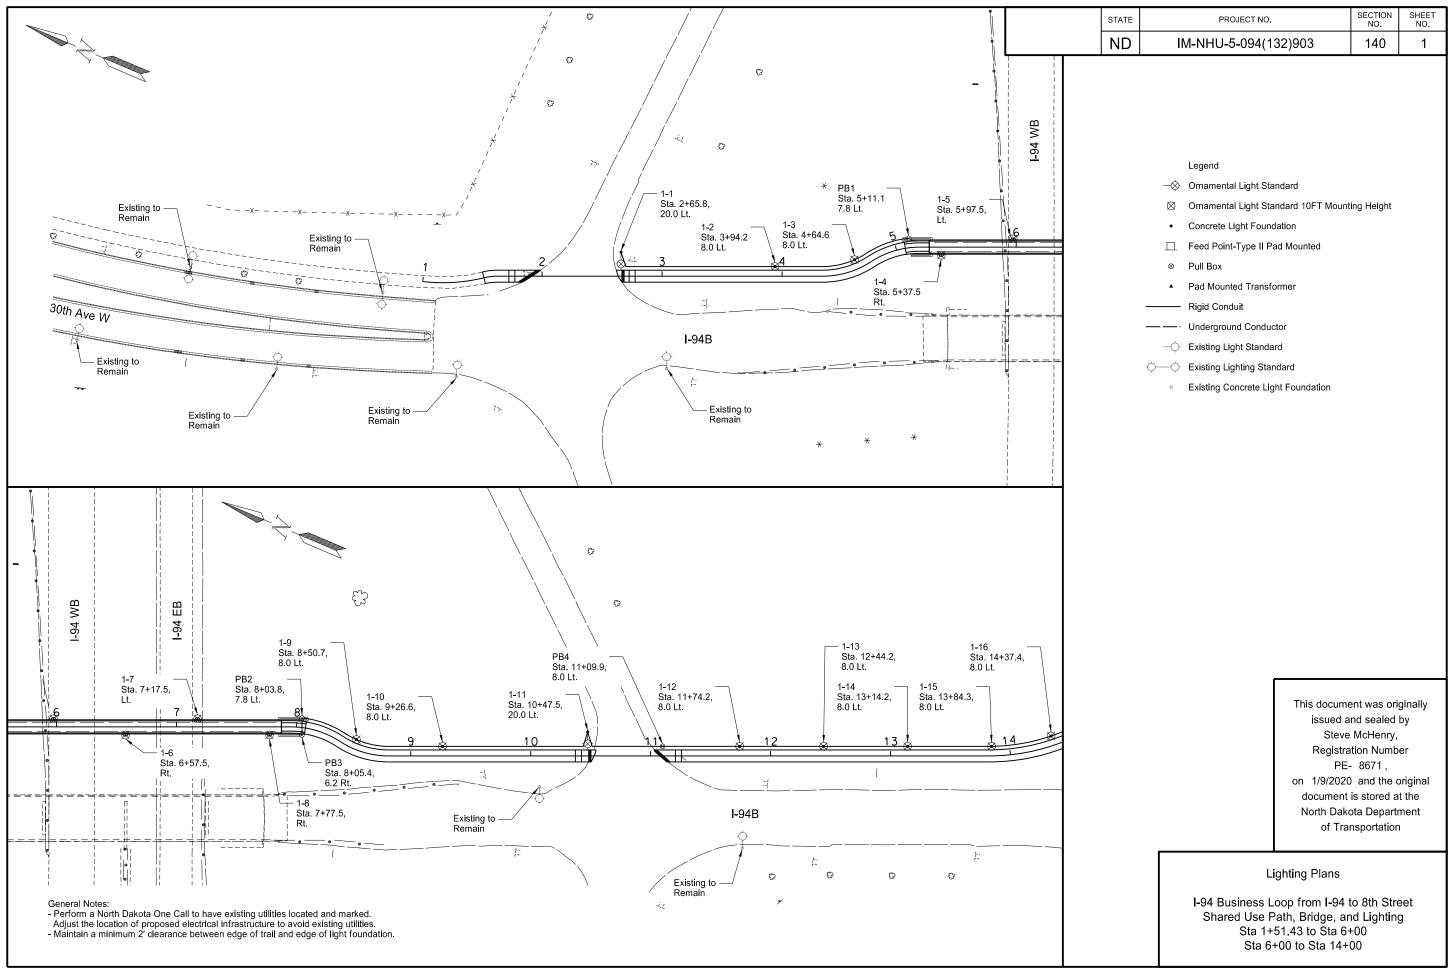

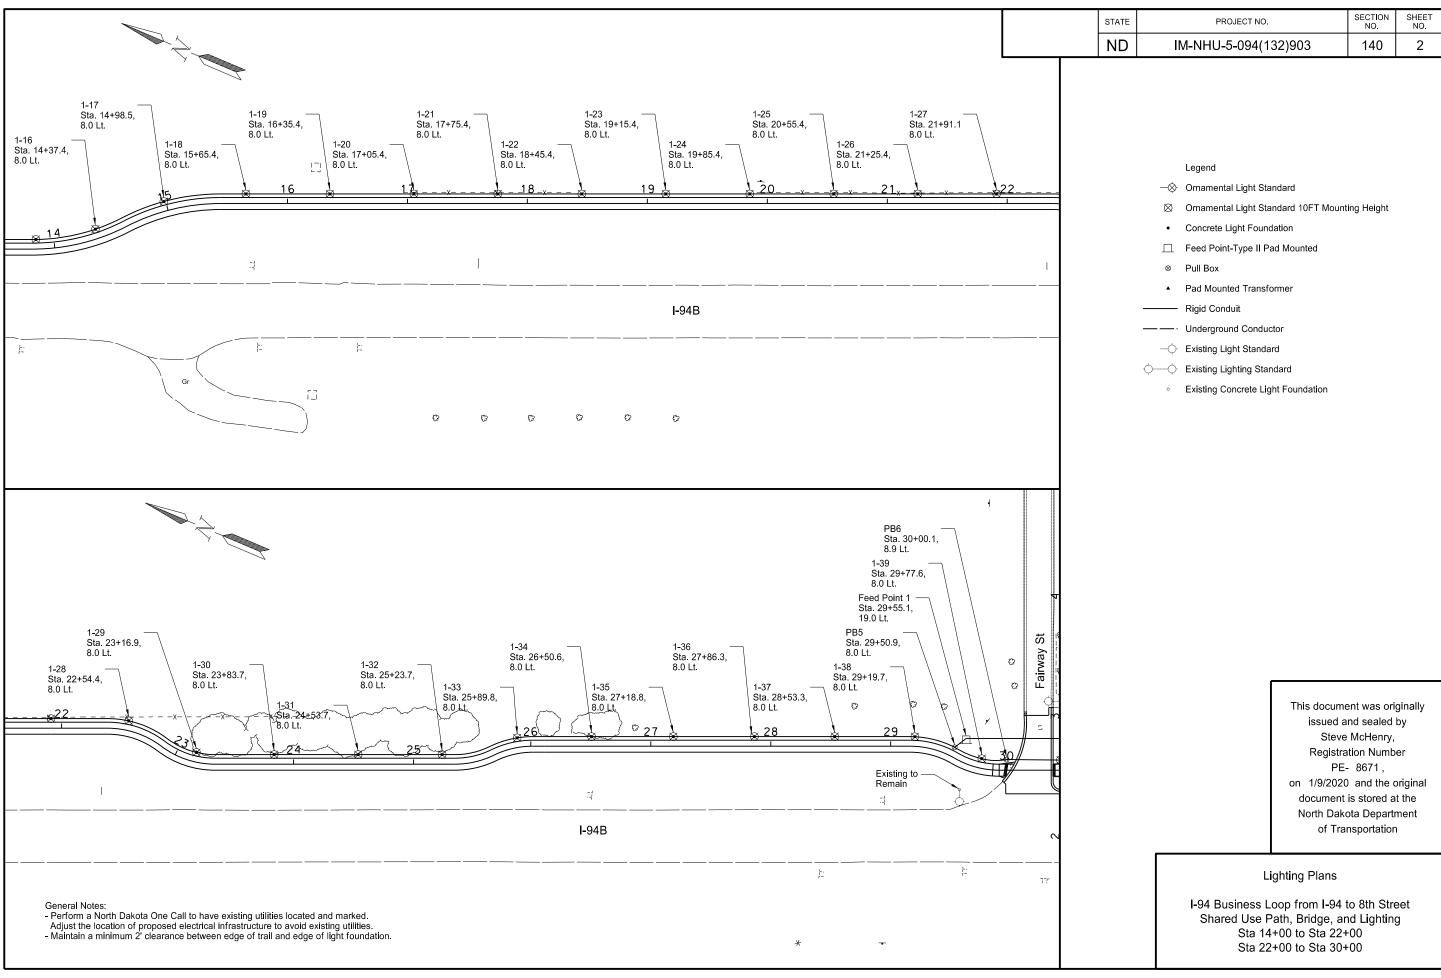

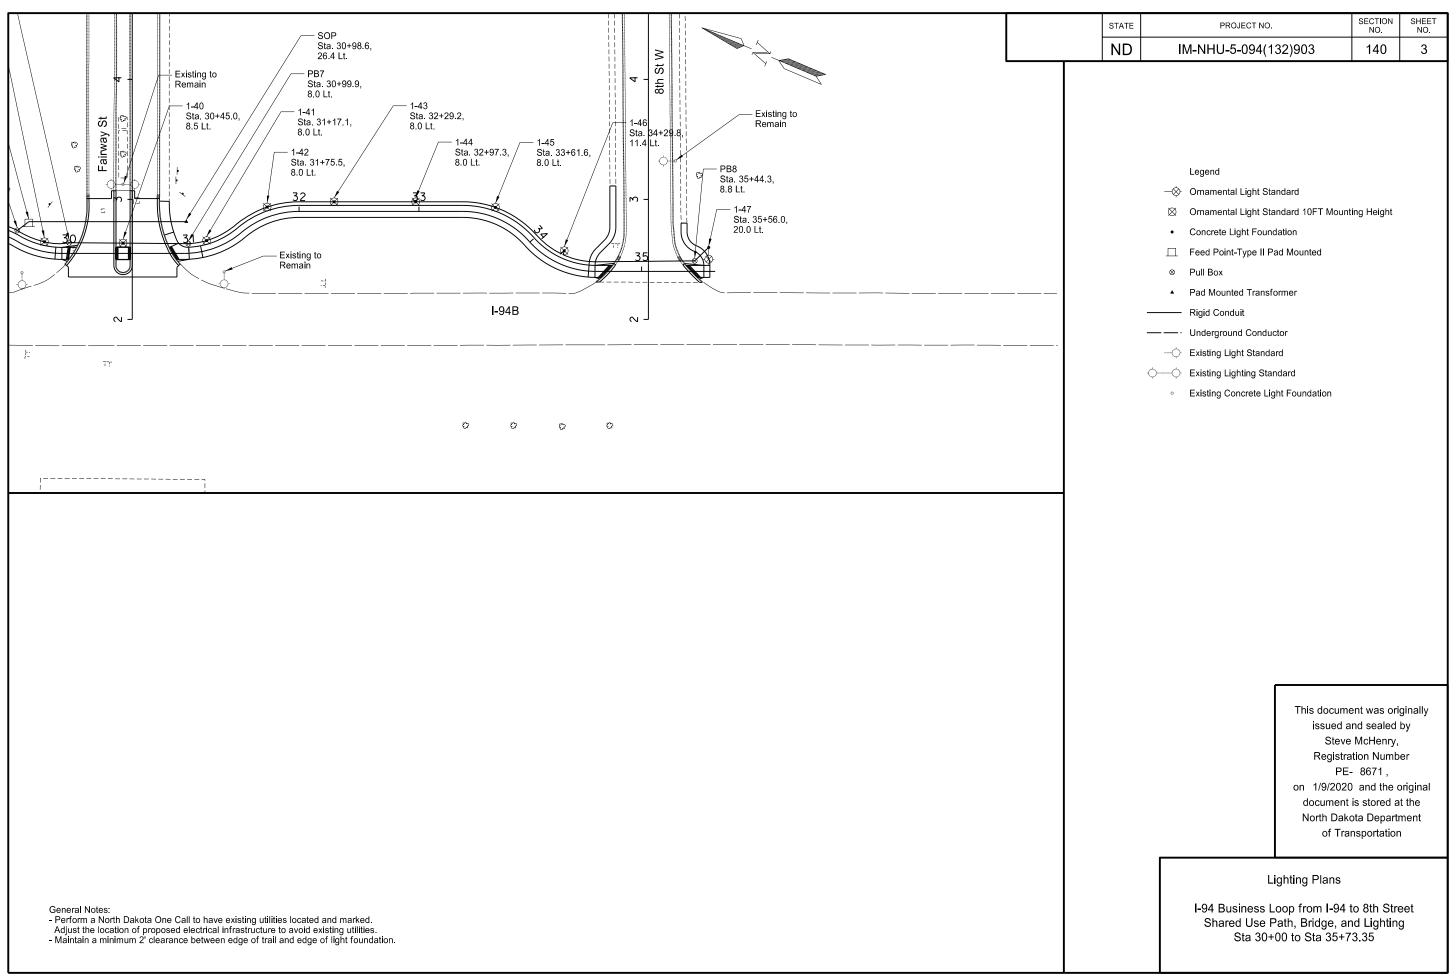

Point	Station	Conduit		Cable Trench		Cable Runs
		Length (ft)	Size	Length (ft)	Length (ft)	Туре
SOP	30+98.6, 26.4 Lt to	132	2"		304	2 - NO 2 TYPE RHW
FP1	29+55.1, 19.0 Lt				152	1 - NO 2 TYPE THW
FP1	29+55.1, 19.0 Lt to	13	1.5"		132	2 - NO 6 TYPE RHW
PB5	29+50.9, 8.0 Lt to	35	1.5"		66	1 - NO 6 TYPE THW
1-38	29+19.7, 8.0 Lt					
1-38	29+19.7, 8.0 Lt to	67	1.5"		150	2 - NO 6 TYPE RHW
1-37	28+53.3, 8.0 Lt				75	1 - NO 6 TYPE THW
1-37	28+53.3, 8.0 Lt to	67	1.5"		150	2 - NO 6 TYPE RHW
1-36	27+86.3, 8.0 Lt				75	1 - NO 6 TYPE THW
1-36	27+86.3, 8.0 Lt to	68	1.5"		152	2 - NO 6 TYPE RHW
1-35	27+18.8, 8.0 Lt				76	1 - NO 6 TYPE THW
	·					
1-35	27+18.8, 8.0 Lt to	69	1.5"		154	2 - NO 6 TYPE RHW
1-34	26+50.6, 8.0 Lt				77	1 - NO 6 TYPE THW
1-34	26+50.6, 8.0 Lt to	63	1,5"		142	2 - NO 6 TYPE RHW
1-33	25+89.8, 8.0 Lt				71	1 - NO 6 TYPE THW
	55.5, 5.0 Et				<u> </u>	
1-33	25+89.8, 8.0 Lt to	65	1.5"		146	2 - NO 6 TYPE RHW
1-32	25+23.7, 8.0 Lt				73	1 - NO 6 TYPE THW
1-32	25+23.7, 8.0 Lt to	70	1.5"		156	2 - NO 6 TYPE RHW
1-31	24+53.7, 8.0 Lt				78	1 - NO 6 TYPE THW
	·					
1-31	24+53.7, 8.0 Lt to	70	1.5"		156	2 - NO 6 TYPE RHW
1-30	23+83.7, 8.0 Lt				78	1 - NO 6 TYPE THW
1-30	23+83.7, 8.0 Lt to	65	1.5"		146	2 - NO 6 TYPE RHW
1-29	23+16.9, 8.0 Lt				73	1 - NO 6 TYPE THW
	·					
1-29	23+16.9, 8.0 Lt to	63	1.5"		142	2 - NO 6 TYPE RHW
1-28	22+54.4, 8.0 Lt				71	1 - NO 6 TYPE THW
	·					
1-28	22+54.4, 8.0 Lt to	66	1.5"		148	2 - NO 6 TYPE RHW
1-27	21+91.1, 8.0 Lt				74	1 - NO 6 TYPE THW
1-27	21+91.1, 8.0 Lt to	66	1.5"		148	2 - NO 6 TYPE RHW
1-26	21+25.4, 8.0 Lt				74	1 - NO 6 TYPE THW
1-26	21+25.4, 8.0 Lt to	70	1.5"		156	2 - NO 6 TYPE RHW
1-25	20+55.4, 8.0 Lt				78	1 - NO 6 TYPE THW
1-25	20+55.4, 8.0 Lt to	70	1.5"		156	2 - NO 6 TYPE RHW
1-24	19+85.4, 8.0 Lt				78	1 - NO 6 TYPE THW
1-24	19+85.4, 8.0 Lt to	70	1.5"		156	2 - NO 6 TYPE RHW
1-23	19+15.4, 8.0 Lt				78	1 - NO 6 TYPE THW
1-23	19+15.4, 8.0 Lt to	70	1.5"		156	2 - NO 6 TYPE RHW
1-22	18+45.4, 8.0 Lt				78	1 - NO 6 TYPE THW
1-22	18+45.4, 8.0 Lt to	70	1.5"		156	2 - NO 6 TYPE RHW
1-21	17+75.4, 8.0 Lt				78	1 - NO 6 TYPE THW
1-21	17+75.4, 8.0 Lt to	70	1.5"		156	2 - NO 6 TYPE RHW
1-20	17+05.4, 8.0 Lt				78	1 - NO 6 TYPE THW
1-20	17+05.4, 8.0 Lt to	70	1.5"		156	2 - NO 6 TYPE RHW
1-19	16+35.4, 8.0 Lt				78	1 - NO 6 TYPE THW
1-19	16+35.4, 8.0 Lt to	70	1.5"		156	2 - NO 6 TYPE RHW
1-18	15+65.4, 8.0 Lt				78	1 - NO 6 TYPE THW
1-18	15+65.4, 8.0 Lt to	69	1.5"		154	2 - NO 6 TYPE RHW
1-17	14+98.5, 8.0 Lt		_		77	1 - NO 6 TYPE THW

STATE	PROJECT NO.	SECTION NO.	SHEET NO.
ИD	IM-NHU-5-094(132)903	140	4

Point	Doint Station		Conduit Runs		Cable Trench		Cable Runs
1-16	Point	Station	Length (ft)	Size	Length (ft)	Length (ft)	Туре
1-16		14+98.5, 8.0 Lt to	62	1.5"		140	2 - NO 6 TYPE RHW
1-15	1-16	14+37.4, 8.0 Lt				70	1 - NO 6 TYPE THW
1-15							
1-15			51	1.5"			
1-14 13+14.2, 8.0 Lt	1-15	13+84.3, 8.0 Lt				59	1 - NO 6 TYPE THW
1-14 13+14.2, 8.0 Lt							
1-14		13+84.3, 8.0 Lt to	70	1.5"		156	2 - NO 6 TYPE RHW
1-13	1-14	13+14.2, 8.0 Lt				78	1 - NO 6 TYPE THW
1-13							
1-13		· · · · · · · · · · · · · · · · · · ·	70	1.5"			
1-12	1-13	12+44.2, 8.0 Lt				78	1 - NO 6 TYPE THW
1-12							
1-12		·	71	1.5"			
PB4	1-12	11+74.2, 8.0 Lt				79	1 - NO 6 TYPE THW
PB4							
1-11 10+47.5, 20.0 Lt 1-11 10+47.5, 20.0 Lt 1-11 10+47.5, 20.0 Lt 1-10 9+26.6, 8.0		· · · · · · · · · · · · · · · · · · ·					
1-11 10+47.5, 20.0 Lt to 130 1.5" 276 2 - NO 6 TYPE RHW 1-10 9+26.6, 8.0 Lt 138 1 - NO 6 TYPE RHW 1-10 9+26.6, 8.0 Lt to 73 1.5" 162 2 - NO 6 TYPE RHW 1-9 8+50.7, 8.0 Lt 10 50 1.5" 312 2 - NO 6 TYPE RHW 1-9 8+50.7, 8.0 Lt to Note 2 2" 156 1 - NO 6 TYPE RHW 1-7 7+17.5, Lt 10 1-7 7+17.5, Lt 10 1-8 1-8 1-8 1-8 1-8 1-8 1-8 1-8 1-8 1-8			72	1.5"		149	1 - NO 6 TYPE THW
1-10 9+26.6, 8.0 Lt	1-11	10+47.5, 20.0 Lt					
1-10 9+26.6, 8.0 Lt							
1-10 9+26.6, 8.0 Lt to 73 1.5" 162 2 - NO 6 TYPE RHW 1-9 8+50.7, 8.0 Lt		'	130	1.5"			
1-9 8+50.7, 8.0 Lt to 50 1.5" 312 2 - NO 6 TYPE RHW PB2 8+03.8, 7.8 Lt to Note 2 2" 156 1 - NO 6 TYPE THW 1-7 7+17.5, Lt 15 1- NO 6 TYPE THW 1-7 7+17.5, Lt 15 1- NO 6 TYPE THW 1-7 7+17.5, Lt 15 1- NO 6 TYPE THW 1-5 5+97.5, Lt 15 136 1 - NO 6 TYPE THW 1-5 5+97.5, Lt 15 15 1- NO 6 TYPE THW PB1 5+11.1, 7.8 Lt to 49 1.5" 155 1 - NO 6 TYPE THW 1-3 4+64.6, 8.0 Lt 15 1.5" 152 2 - NO 6 TYPE RHW 1-2 3+94.2, 8.0 Lt 15 137 1.5" 290 2 - NO 6 TYPE THW 1-1 2+65.8, 20.0 Lt 15 1.5" 145 1 - NO 6 TYPE THW 1-9 8+50.7, 8.0 Lt to Note 3 1.5" 230 2 - NO 6 TYPE THW PB2 8+05.4, 6.2 Rt to Note 2 2" 230 2 - NO 6 TYPE THW 1-8 7+77.5, Rt 15 1.5" 115 1 - NO 6 TYPE THW 1-8 7+77.5, Rt 15 1.5" 115 1 - NO 6 TYPE THW 1-9 8+55.7, Rt 15 1.5" 115 1 - NO 6 TYPE THW 1-8 7+77.5, Rt 15 1.5" 115 1 - NO 6 TYPE THW 1-9 8+55.7, Rt 15 1.5" 115 1 - NO 6 TYPE THW	1-10	9+26.6, 8.0 Lt				138	1 - NO 6 TYPE THW
1-9 8+50.7, 8.0 Lt to 50 1.5" 312 2 - NO 6 TYPE RHW PB2 8+03.8, 7.8 Lt to Note 2 2" 156 1 - NO 6 TYPE THW 1-7 7+17.5, Lt 15 1- NO 6 TYPE THW 1-7 7+17.5, Lt 15 1- NO 6 TYPE THW 1-7 7+17.5, Lt 15 1- NO 6 TYPE THW 1-5 5+97.5, Lt 15 136 1 - NO 6 TYPE THW 1-5 5+97.5, Lt 15 15 1- NO 6 TYPE THW PB1 5+11.1, 7.8 Lt to 49 1.5" 155 1 - NO 6 TYPE THW 1-3 4+64.6, 8.0 Lt 15 1.5" 152 2 - NO 6 TYPE RHW 1-2 3+94.2, 8.0 Lt 15 137 1.5" 290 2 - NO 6 TYPE THW 1-1 2+65.8, 20.0 Lt 15 1.5" 145 1 - NO 6 TYPE THW 1-9 8+50.7, 8.0 Lt to Note 3 1.5" 230 2 - NO 6 TYPE THW PB2 8+05.4, 6.2 Rt to Note 2 2" 230 2 - NO 6 TYPE THW 1-8 7+77.5, Rt 15 1.5" 115 1 - NO 6 TYPE THW 1-8 7+77.5, Rt 15 1.5" 115 1 - NO 6 TYPE THW 1-9 8+55.7, Rt 15 1.5" 115 1 - NO 6 TYPE THW 1-8 7+77.5, Rt 15 1.5" 115 1 - NO 6 TYPE THW 1-9 8+55.7, Rt 15 1.5" 115 1 - NO 6 TYPE THW							
1-9 8+50.7, 8.0 Lt to 50 1.5" 312 2 - NO 6 TYPE RHW PB2 8+03.8, 7.8 Lt to Note 2 2" 156 1 - NO 6 TYPE THW 1-7 7+17.5, Lt 1-7 7+17.5, Lt to Note 2 2" 272 2 - NO 6 TYPE RHW 1-5 5+97.5, Lt 136 1 - NO 6 TYPE THW 1-5 5+97.5, Lt 10 Note 2 2" 310 2 - NO 6 TYPE RHW 1-5 5+97.5, Lt 10 Note 2 2" 310 2 - NO 6 TYPE RHW 1-1 1-3 4+64.6, 8.0 Lt 10 49 1.5" 155 1 - NO 6 TYPE THW 1-2 3+94.2, 8.0 Lt 10 68 1.5" 152 2 - NO 6 TYPE RHW 1-2 3+94.2, 8.0 Lt 10 137 1.5" 290 2 - NO 6 TYPE RHW 1-1 2+65.8, 20.0 Lt 115 1.5" 290 2 - NO 6 TYPE THW 1-9 8+50.7, 8.0 Lt to Note 3 1.5" 230 2 - NO 6 TYPE THW 1-9 8+50.7, 8.0 Lt to 15 1.5" 115 1 - NO 6 TYPE THW 1-9 8+50.7, 8.0 Lt to Note 2 2" 272 2 - NO 6 TYPE RHW 1-8 7+77.5, Rt 10 Note 2 2" 272 2 - NO 6 TYPE RHW 1-8 7+77.5, Rt 10 Note 2 2" 272 2 - NO 6 TYPE THW			73	1.5"			
PB2 8+03.8, 7.8 Lt to	1-9	8+50.7, 8.0 Lt				81	1 - NO 6 TYPE THW
PB2 8+03.8, 7.8 Lt to	1.0	0.507.00111	50	4.5"		0.10	0. 110.0 TVDE DUNA
1-7 7+17.5, Lt to Note 2 2" 272 2 - NO 6 TYPE RHW 1-5 5+97.5, Lt to Note 2 2" 310 2 - NO 6 TYPE RHW 1-5 5+97.5, Lt to Note 2 2" 310 2 - NO 6 TYPE RHW 1-5 5+97.5, Lt to 49 1.5" 155 1 - NO 6 TYPE THW 1-3 4+64.6, 8.0 Lt 1-3 4+64.6, 8.0 Lt to 68 1.5" 152 2 - NO 6 TYPE RHW 1-2 3+94.2, 8.0 Lt 76 1 - NO 6 TYPE THW 1-2 3+94.2, 8.0 Lt 76 1 - NO 6 TYPE RHW 1-1 2 2+65.8, 20.0 Lt 10 137 1.5" 290 2 - NO 6 TYPE RHW 1-1 2 2+65.8, 20.0 Lt 10 Note 3 1.5" 230 2 - NO 6 TYPE THW 1-9 8+50.7, 8.0 Lt to Note 3 1.5" 230 2 - NO 6 TYPE RHW 1-9 8+03.8, 7.8 Lt to 15 1.5" 115 1 - NO 6 TYPE THW 1-8 7+77.5, Rt 10 Note 2 2" 272 2 - NO 6 TYPE RHW 1-6 6+57.5, Rt to Note 2 2" 272 2 - NO 6 TYPE RHW							
1-7 7+17.5, Lt to Note 2 2" 272 2 - NO 6 TYPE RHW 1-5 5+97.5, Lt 136 1 - NO 6 TYPE THW 1-5 5+97.5, Lt to Note 2 2" 310 2 - NO 6 TYPE RHW PB1 5+11.1, 7.8 Lt to 49 1.5" 155 1 - NO 6 TYPE THW 1-3 4+64.6, 8.0 Lt 15 15" 152 2 - NO 6 TYPE RHW 1-2 3+94.2, 8.0 Lt 176 1 - NO 6 TYPE THW 1-2 3+94.2, 8.0 Lt 177 1.5" 290 2 - NO 6 TYPE RHW 1-1 2+65.8, 20.0 Lt 177 1.5" 290 2 - NO 6 TYPE RHW 1-1 2+65.8, 20.0 Lt 178 1.5" 290 2 - NO 6 TYPE THW 1-9 8+50.7, 8.0 Lt to Note 3 1.5" 230 2 - NO 6 TYPE RHW PB2 8+03.8, 7.8 Lt to 15 1.5" 115 1 - NO 6 TYPE THW PB3 8+05.4, 6.2 Rt to Note 2 2" 272 2 - NO 6 TYPE RHW 1-8 7+77.5, Rt 18 136 1 - NO 6 TYPE THW 1-9 6+57.5, Rt 136 1 - NO 6 TYPE THW		· · · · · · · · · · · · · · · · · · ·	Note 2	2"		156	1 - NO 6 TYPE THW
1-5 5+97.5, Lt to Note 2 2" 310 2 - NO 6 TYPE THW PB1 5+11.1, 7.8 Lt to 49 1.5" 155 1 - NO 6 TYPE THW 1-3 4+64.6, 8.0 Lt 10 68 1.5" 152 2 - NO 6 TYPE RHW 1-2 3+94.2, 8.0 Lt 76 1 - NO 6 TYPE THW 1-2 3+94.2, 8.0 Lt 10 137 1.5" 290 2 - NO 6 TYPE RHW 1-1 2+65.8, 20.0 Lt 145 1 - NO 6 TYPE THW 1-9 8+50.7, 8.0 Lt to Note 3 1.5" 230 2 - NO 6 TYPE RHW PB2 8+03.8, 7.8 Lt to 15 1.5" 115 1 - NO 6 TYPE THW PB3 8+05.4, 6.2 Rt to Note 2 2" 272 2 - NO 6 TYPE RHW 1-8 7+77.5, Rt 15 Note 2 2" 272 2 - NO 6 TYPE RHW 1-6 6+57.5, Rt to Note 2 2" 272 2 - NO 6 TYPE THW	1-7	/+1/.5, Lt					
1-5 5+97.5, Lt to Note 2 2" 310 2 - NO 6 TYPE THW PB1 5+11.1, 7.8 Lt to 49 1.5" 155 1 - NO 6 TYPE THW 1-3 4+64.6, 8.0 Lt 10 68 1.5" 152 2 - NO 6 TYPE RHW 1-2 3+94.2, 8.0 Lt 76 1 - NO 6 TYPE THW 1-2 3+94.2, 8.0 Lt 10 137 1.5" 290 2 - NO 6 TYPE RHW 1-1 2+65.8, 20.0 Lt 145 1 - NO 6 TYPE THW 1-9 8+50.7, 8.0 Lt to Note 3 1.5" 230 2 - NO 6 TYPE RHW PB2 8+03.8, 7.8 Lt to 15 1.5" 115 1 - NO 6 TYPE THW PB3 8+05.4, 6.2 Rt to Note 2 2" 272 2 - NO 6 TYPE RHW 1-8 7+77.5, Rt 15 Note 2 2" 272 2 - NO 6 TYPE RHW 1-6 6+57.5, Rt to Note 2 2" 272 2 - NO 6 TYPE THW	4.7	7.47.5.144-	Note 2	2"		272	2 NO C TYPE DUM
1-5		· · · · · · · · · · · · · · · · · · ·	Note 2				
PB1 5+11.1, 7.8 Lt to 49 1.5" 155 1 - NO 6 TYPE THW 1-3 4+64.6, 8.0 Lt to 68 1.5" 152 2 - NO 6 TYPE RHW 1-2 3+94.2, 8.0 Lt 76 1 - NO 6 TYPE THW 1-2 3+94.2, 8.0 Lt to 137 1.5" 290 2 - NO 6 TYPE RHW 1-1 2+65.8, 20.0 Lt 145 1 - NO 6 TYPE THW 1-9 8+50.7, 8.0 Lt to Note 3 1.5" 230 2 - NO 6 TYPE RHW PB2 8+03.8, 7.8 Lt to 15 1.5" 115 1 - NO 6 TYPE THW PB3 8+05.4, 6.2 Rt to Note 2 2" 272 2 - NO 6 TYPE RHW 1-8 7+77.5, Rt 136 1 - NO 6 TYPE THW 1-6 6+57.5, Rt to Note 2 2" 272 2 - NO 6 TYPE RHW 1-6 6+57.5, Rt to Note 2 2" 272 2 - NO 6 TYPE RHW	1-0	5+97.5, Lt				130	I-NO OTTPETHW
PB1 5+11.1, 7.8 Lt to 49 1.5" 155 1 - NO 6 TYPE THW 1-3 4+64.6, 8.0 Lt to 68 1.5" 152 2 - NO 6 TYPE RHW 1-2 3+94.2, 8.0 Lt 76 1 - NO 6 TYPE THW 1-2 3+94.2, 8.0 Lt to 137 1.5" 290 2 - NO 6 TYPE RHW 1-1 2+65.8, 20.0 Lt 145 1 - NO 6 TYPE THW 1-9 8+50.7, 8.0 Lt to Note 3 1.5" 230 2 - NO 6 TYPE RHW PB2 8+03.8, 7.8 Lt to 15 1.5" 115 1 - NO 6 TYPE THW PB3 8+05.4, 6.2 Rt to Note 2 2" 272 2 - NO 6 TYPE RHW 1-8 7+77.5, Rt 136 1 - NO 6 TYPE THW 1-6 6+57.5, Rt to Note 2 2" 272 2 - NO 6 TYPE RHW 1-6 6+57.5, Rt to Note 2 2" 272 2 - NO 6 TYPE RHW	1.5	5±07.5.1±±0	Note 2	2"		210	2 NO 6 TVDE DUM
1-3		· · · · · · · · · · · · · · · · · · ·					
1-3		<u>`</u>	49	1.5		133	I-NOUTTE THIV
1-2 3+94.2, 8.0 Lt 76 1 - NO 6 TYPE THW 1-2 3+94.2, 8.0 Lt to 137 1.5" 290 2 - NO 6 TYPE RHW 1-1 2+65.8, 20.0 Lt 145 1 - NO 6 TYPE THW 1-9 8+50.7, 8.0 Lt to Note 3 1.5" 230 2 - NO 6 TYPE RHW PB2 8+03.8, 7.8 Lt to 15 1.5" 115 1 - NO 6 TYPE THW PB3 8+05.4, 6.2 Rt to Note 2 2" 2" 1-8 7+77.5, Rt 272 2 - NO 6 TYPE RHW 1-6 6+57.5, Rt 136 1 - NO 6 TYPE THW 1-6 6+57.5, Rt to Note 2 2" 272 2 - NO 6 TYPE RHW	1-5	4+04.0, 0.0 Lt					
1-2 3+94.2, 8.0 Lt 76 1 - NO 6 TYPE THW 1-2 3+94.2, 8.0 Lt to 137 1.5" 290 2 - NO 6 TYPE RHW 1-1 2+65.8, 20.0 Lt 145 1 - NO 6 TYPE THW 1-9 8+50.7, 8.0 Lt to Note 3 1.5" 230 2 - NO 6 TYPE RHW PB2 8+03.8, 7.8 Lt to 15 1.5" 115 1 - NO 6 TYPE THW PB3 8+05.4, 6.2 Rt to Note 2 2" 2" 1-8 7+77.5, Rt 272 2 - NO 6 TYPE RHW 1-6 6+57.5, Rt 136 1 - NO 6 TYPE THW 1-6 6+57.5, Rt to Note 2 2" 272 2 - NO 6 TYPE RHW	1_3	4+64.6.8.0.1.t.to	68	1.5"		152	2 - NO 6 TYPE RHW
1-2 3+94.2, 8.0 Lt to 137 1.5" 290 2 - NO 6 TYPE RHW 1-1 2+65.8, 20.0 Lt 145 1 - NO 6 TYPE THW 1-9 8+50.7, 8.0 Lt to Note 3 1.5" 230 2 - NO 6 TYPE RHW PB2 8+03.8, 7.8 Lt to 15 1.5" 115 1 - NO 6 TYPE THW PB3 8+05.4, 6.2 Rt to Note 2 2" 272 2 - NO 6 TYPE RHW 1-8 7+77.5, Rt 136 1 - NO 6 TYPE RHW 1-6 6+57.5, Rt to Note 2 2" 272 2 - NO 6 TYPE RHW 1-6 6+57.5, Rt to Note 2 2" 272 2 - NO 6 TYPE RHW			- 55	1.0			
1-1 2+65.8, 20.0 Lt 145 1 - NO 6 TYPE THW 1-9 8+50.7, 8.0 Lt to Note 3 1.5" 230 2 - NO 6 TYPE RHW PB2 8+03.8, 7.8 Lt to 15 1.5" 115 1 - NO 6 TYPE THW PB3 8+05.4, 6.2 Rt to Note 2 2" 1-8 7+77.5, Rt 272 2 - NO 6 TYPE RHW 1-6 6+57.5, Rt 136 1 - NO 6 TYPE THW 1-6 6+57.5, Rt to Note 2 2" 272 2 - NO 6 TYPE RHW 1-6 6+57.5, Rt to Note 2 2" 272 2 - NO 6 TYPE RHW	12	0.01.2, 0.0 20					1 110 0 111 2 11111
1-1 2+65.8, 20.0 Lt 145 1 - NO 6 TYPE THW 1-9 8+50.7, 8.0 Lt to Note 3 1.5" 230 2 - NO 6 TYPE RHW PB2 8+03.8, 7.8 Lt to 15 1.5" 115 1 - NO 6 TYPE THW PB3 8+05.4, 6.2 Rt to Note 2 2" 1-8 7+77.5, Rt 272 2 - NO 6 TYPE RHW 1-6 6+57.5, Rt 136 1 - NO 6 TYPE THW 1-6 6+57.5, Rt to Note 2 2" 272 2 - NO 6 TYPE RHW 1-6 6+57.5, Rt to Note 2 2" 272 2 - NO 6 TYPE RHW	1-2	3+94.2. 8.0 Lt to	137	1.5"		290	2 - NO 6 TYPF RHW
1-9 8+50.7, 8.0 Lt to Note 3 1.5" 230 2 - NO 6 TYPE RHW PB2 8+03.8, 7.8 Lt to 15 1.5" 115 1 - NO 6 TYPE THW PB3 8+05.4, 6.2 Rt to Note 2 2" 1-8 7+77.5, Rt 1-8 7+77.5, Rt to Note 2 2" 272 2 - NO 6 TYPE RHW 1-6 6+57.5, Rt 136 1 - NO 6 TYPE THW		,					
PB2 8+03.8, 7.8 Lt to 15 1.5" 115 1 - NO 6 TYPE THW PB3 8+05.4, 6.2 Rt to Note 2 2" 2" 1-8 7+77.5, Rt 272 2 - NO 6 TYPE RHW 1-6 6+57.5, Rt 136 1 - NO 6 TYPE THW 1-6 6+57.5, Rt to Note 2 2" 272 2 - NO 6 TYPE RHW							
PB2 8+03.8, 7.8 Lt to 15 1.5" 115 1 - NO 6 TYPE THW PB3 8+05.4, 6.2 Rt to Note 2 2" 2" 1-8 7+77.5, Rt 272 2 - NO 6 TYPE RHW 1-6 6+57.5, Rt 136 1 - NO 6 TYPE THW 1-6 6+57.5, Rt to Note 2 2" 272 2 - NO 6 TYPE RHW	1-9	8+50.7. 8.0 Lt to	Note 3	1.5"		230	2 - NO 6 TYPE RHW
PB3 8+05.4, 6.2 Rt to Note 2 2" 1-8 7+77.5, Rt 2" 272 2 - NO 6 TYPE RHW 1-6 6+57.5, Rt to Note 2 2" 272 2 - NO 6 TYPE THW 1-6 6+57.5, Rt to Note 2 2" 272 2 - NO 6 TYPE RHW		· · · · · · · · · · · · · · · · · · ·					
1-8 7+77.5, Rt 1-8 7+77.5, Rt to Note 2 1-6 6+57.5, Rt 1-6 6+57.5, Rt to Note 2 2" 272 2 - NO 6 TYPE RHW 1-6 6+57.5, Rt to Note 2 2" 272 2 - NO 6 TYPE RHW	PB3	8+05.4, 6.2 Rt to					
1-8 7+77.5, Rt to Note 2 2" 272 2 - NO 6 TYPE RHW 1-6 6+57.5, Rt 136 1 - NO 6 TYPE THW 1-6 6+57.5, Rt to Note 2 2" 272 2 - NO 6 TYPE RHW							
1-6 6+57.5, Rt 136 1 - NO 6 TYPE THW 1-6 6+57.5, Rt to Note 2 2" 272 2 - NO 6 TYPE RHW		,					
1-6 6+57.5, Rt to Note 2 2" 272 2 - NO 6 TYPE RHW	1-8	7+77.5, Rt to	Note 2	2"		272	2 - NO 6 TYPE RHW
	1-6	6+57.5, Rt				136	1 - NO 6 TYPE THW
1-4 5+37.5, Rt 136 1 - NO 6 TYPE THW	1-6	6+57.5, Rt to	Note 2	2"		272	2 - NO 6 TYPE RHW
	1-4	5+37.5, Rt				136	1 - NO 6 TYPE THW

- Note: 1 Bridge mounted
- 2 Conduit furnished and installed by bridge contractor
- 3 Conduit included in a previous total

This document was originally issued and sealed by Steve McHenry, Registration Number PE- 8671, on 1/9/2020 and the original document is stored at the North Dakota Department of Transportation

Lighting Plans

Quantities

FP1	29+55.1, 19.0 Lt to	13	1.5"	112	2 - NO 6 TYPE RHW
PB5	29+50.9, 8.0 Lt to	25	1.5"	56	1 - NO 6 TYPE THW
1-39	29+77.6, 8.0 Lt				
1-39	29+77.6, 8.0 Lt to	21	1.5"	156	2 - NO 6 TYPE RHV
PB6	30+00.1, 8.9 Lt to	45	1.5"	78	1 - NO 6 TYPE THW
1-40	30+45.0, 8.5 Lt				
1-40	30+45.0, 8.5 Lt to	55	1.5"	166	2 - NO 6 TYPE RHV
PB7	30+99.9, 8.0 Lt to	16	1.5"	83	1 - NO 6 TYPE THV
1-41	31+17.1, 8.0 Lt				
1-41	31+17.1, 8.0 Lt to	59	1.5"	134	2 - NO 6 TYPE RHV
1-42	31+75.5, 8.0 Lt			67	1 - NO 6 TYPE THV
1-42	31+75.5, 8.0 Lt to	57	1.5"	130	2 - NO 6 TYPE RHV
1-43	32+29.2, 8.0 Lt			65	1 - NO 6 TYPE THV
1-43	32+29.2, 8.0 Lt to	69	1.5"	154	2 - NO 6 TYPE RHV
1-44	32+97.3, 8.0 Lt			77	1 - NO 6 TYPE THV
1-44	32+97.3, 8.0 Lt to	67	1.5"	150	2 - NO 6 TYPE RHV
1-45	33+61.6, 8.0 Lt			75	1 - NO 6 TYPE THV
1-45	33+61.6, 8.0 Lt to	71	1.5"	158	2 - NO 6 TYPE RHV
1-46	34+29.8, 11.4 Lt			79	1 - NO 6 TYPE THV
1-46	34+29.8, 11.4 Lt to	113	1.5"	284	2 - NO 6 TYPE RHV
PB8	35+44.3, 8.8 Lt to	17	1.5"	142	1 - NO 6 TYPE THV
1-47	35+56.0, 20.0 Lt				

N	lo	te:

- 1 Bridge mounted
- 2 Conduit furnished and installed by bridge contractor
- 3 Conduit included in a previous total

No.	Station	Offset	Wattage	Circuit	Pole Ht.	Mast Arm	Note
1-1	2+65.8	20.0 Lt	204	1	30	8'	
1-2	3+94.2	8.0 Lt	45	1	10'		
1-3	4+64.6	8.0 Lt	45	1	10'		
1-4	5+37.5	Rt	45	1	10'		1
1-5	5+97.5	Lt	45	1	10'		1
1-6	6+57.5	Rt	45	1	10'		1
1-7	7+17.5	Lt	45	1	10'		1
1-8	7+77.5	Rt	45	1	10'		1
1-9	8+50.7	8.0 Lt	45	1	10'		'
1-10	9+26.6	8.0 Lt	45	1	10'		
1-11	10+47.5	20.0 Lt	204	1	30	8'	
1-11				1	10'	0	
	11+74.2	8.0 Lt	45				
1-13	12+44.2	8.0 Lt	45	1	10'		
1-14	13+14.2	8.0 Lt	45	1	10'		
1-15	13+84.3	8.0 Lt	45	1	10'		
1-16	14+37.4	8.0 Lt	45	1	10'		
1-17	14+98.5	8.0 Lt	45	1	10'		
1-18	15+65.4	8.0 Lt	45	1	10'		
1-19	16+35.4	8.0 Lt	45	1	10'		
1-20	17+05.4	8.0 Lt	45	1	10'		
1-21	17+75.4	8.0 Lt	45	1	10'		
1-22	18+45.4	8.0 Lt	45	1	10'		
1-23	19+15.4	8.0 Lt	45	1	10'		
1-24	19+85.4	8.0 Lt	45	1	10'		
1-25	20+55.4	8.0 Lt	45	1	10'		
1-26	21+25.4	8.0 Lt	45	1	10'		
1-27	21+91.1	8.0 Lt	45	1	10'		
1-28	22+54.5	8.0 Lt	45	1	10'		
1-29	23+16.9	8.0 Lt	45	1	10'		
1-30	23+83.7	8.0 Lt	45	1	10'		
1-31	24+53.7	8.0 Lt	45	1	10'		
1-32	25+23.7	8.0 Lt	45	1	10'		
1-33	25+89.8	8.0 Lt	45	1	10'		
1-34	26+50.6	8.0 Lt	45	1	10'		
1-35	27+18.8	8.0 Lt	45	1	10'		
1-36	27+86.3	8.0 Lt	45	1	10'		
1-37	28+53.3	8.0 Lt	45	1	10'		
1-38	29+19.7	8.0 Lt	45	1	10'		
1-39	29+77.6	8.0 Lt	45	2	10'		
1-40	30+45.0	8.5 Lt	45	2	10'		
1-41	31+17.1	8.0 Lt	45		10' 10'		
1-42 1-43	31+75.5	8.0 Lt	45 45	2	10'		
1-43	32+29.2	8.0 Lt 8.0 Lt	45 45	2	10'		
1-44	32+97.3	8.0 Lt 8.0 Lt	45 45	2	10'		
1-45	33+61.6 34+29.8	11.4 Lt	45	2	10'		
1-46	34+29.8 35+56.0	20.0 Lt	204	2	30	8'	
1-41	33,30.0	20.0 Lt	204] 30	l o	

						Quanti	ities (A)							
CONCRETE FOUNDATION- HIGHWAY LIGHTING	CONCRETE FOUNDATON-FEED POINT -TYPE B	PULL BOX	1.5IN DIAMETER RIGID CONDUIT	2IN DIAMETER RIGID CONDUIT	UNDERGROUND CONDUCTOR NO2-	UNDERGROUND CONDUCTOR NO6-	UNDERGROUND CONDUCTOR NO2-	UNDERGROUND CONDUCTOR NO6-	FEED POINT-TYPE II-PAD MOUNTED	ORNAMENTAL LT STD 10FT MT HT	ORNAMENTAL LIGHT STD	LED LUMINAIRE - TYPE A	LED LUMINAIRE - TYPE B	LIGHTING SYSTEM
EA	EA	EA	LF	LF	LF	LF	LF	LF	EA	EA	EA	EA	EA	EA
42	1 1	8	3087	132	304	8342	152	4171	1 1	44	3	44	3	1 1

(A) - DO NOT BID SEPARATELY BUT INCLUDE IN THE ITEM "LIGHTING SYSTEM"

This document was originally issued and sealed by Steve McHenry, Registration Number PE- 8671, on 1/9/2020 and the original document is stored at the North Dakota Department of Transportation

SECTION NO.

140

STATE

ND

PROJECT NO.

IM-NHU-5-094(132)903


SHEET NO.

5

Lighting Plans

Quantities

STATE	PROJECT NO.	SECTION NO.	SHEET NO.
ND	IM-NHU-5-094(132)903	140	6

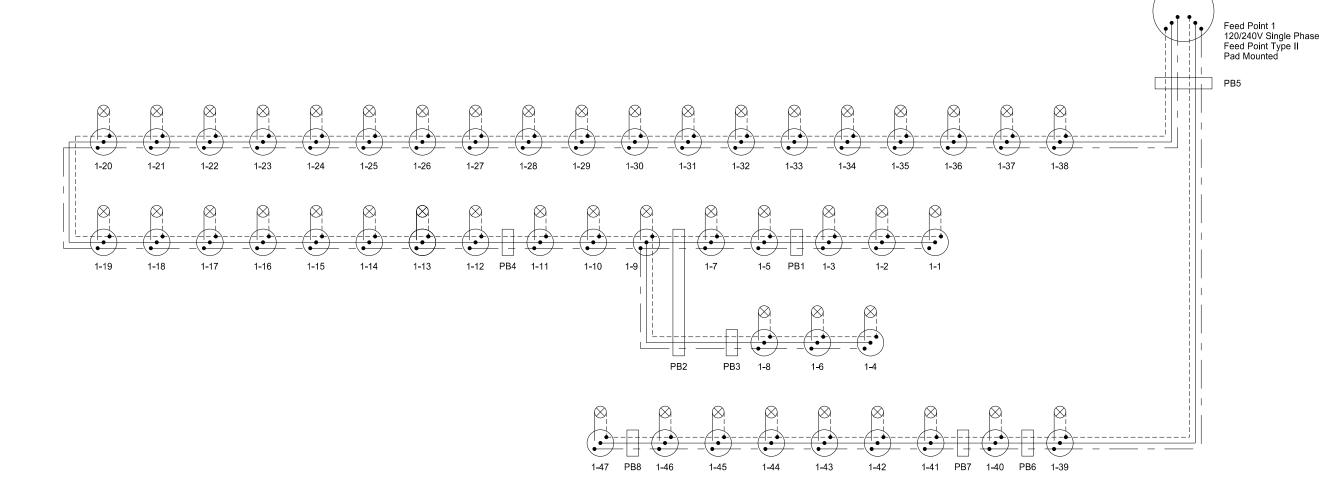


Luminaire LED Feed Point or Light Standard Pull Box Connection Conductor Phase 1 Conductor Ground Conductor Phase 2

This document was originally issued and sealed by Steve McHenry, Registration Number PE- 8671, on 1/9/2020 and the original document is stored at the North Dakota Department of Transportation

Lighting Plans

Wiring Diagram

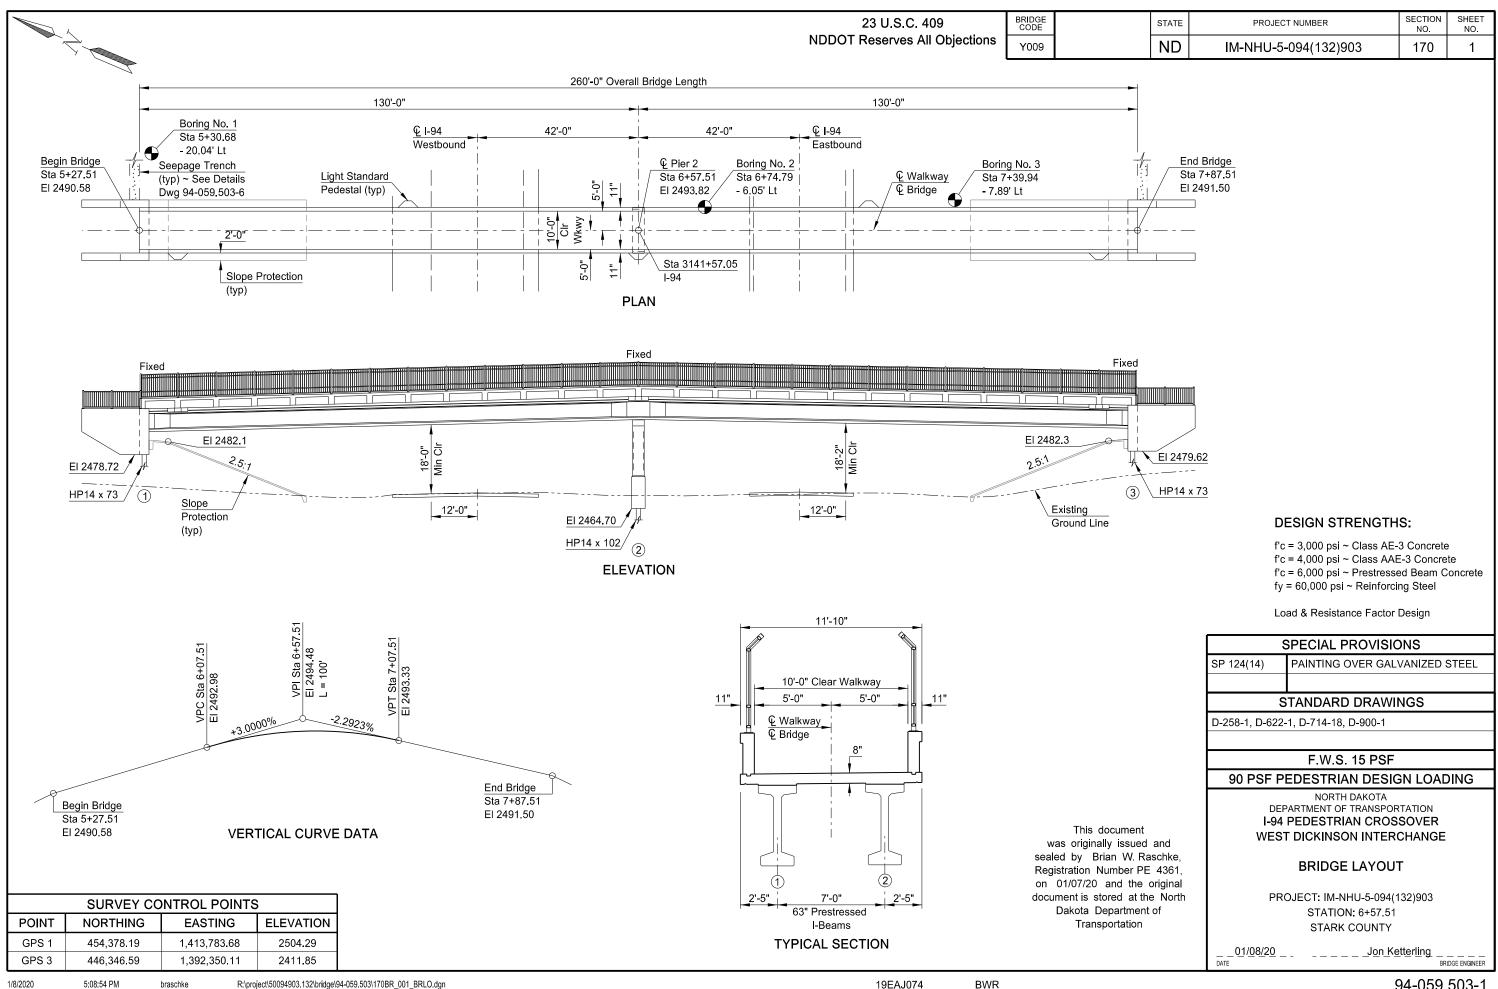

STATE	PROJECT NO.	SECTION NO.	SHEET NO.
ND	IM-NHU-5-094(132)903	170	2

<u>NOTES</u>

- SCOPE OF WORK: This project consists of building a new 2-span prestressed concrete I-beam pedestrian bridge with an overall bridge length of 260'-0" and a clear walkway width of 10'-0".
- 100 GENERAL: Include the cost of furnishing and placing concrete inserts, silicone sealant, waterproof membrane, conduit, and other miscellaneous items in the price bid for Class AE-3 and AAE-3 concrete.
- 210 EXCAVATION: Include the excavation costs at the abutments, as shown in the "Detail at Abutment", and the excavation costs at the pier in the lump sum bid item, "Class 1 Excavation."
- 602 CLASS AE-3 AND AAE-3 CONCRETE: The strength requirements of Section 802.01 A.2 "Class AE and AAE Mixes" are revised to develop a design compressive strength of 3,000 psi (AE-3) and 4,000 psi (AAE-3) at 28 days.
- FORM LINERS: Include the cost to provide and install the form liners in the price bid for the appropriate concrete items.
- DIAPHRAGMS AND ENDWALLS: Place the intermediate diaphragm concrete before the deck concrete and allow the diaphragms to cure at least 72 hours before deck placement. Place the pier diaphragm and endwall concrete at the same time as the deck concrete.
- 602 DECK BROOMING: Do not tine the bridge deck. Transversely broom the deck to slightly roughen the surface.
- BRIDGE DECK CURING: Do not cover the wet cure burlap with a waterproof material such as polyethylene during the curing period.
- SURFACE TOLERANCE: After the concrete has cured, the Engineer will test the bridge deck for surface irregularities with 10 foot and 8 foot straightedges. The Engineer will check the profile and cross slope by performing the following:

Check the profile using a 10 foot straightedge oriented in the longitudinal direction and starting at one end of the deck, move the straightedge transversely across the deck to the other edge with constant contact with the deck. Repeat this process in 5 foot intervals from one end of the deck to the other. Check the cross slope using the 8 foot straightedge oriented in the transverse direction and starting at one end of the deck, move the straightedge longitudinally from one end of the deck to the other end with constant contact with the deck.

- 602 PEDESTRIAN WALLS: Construct V-grooves that are ¾ inch wide and ¾ inch deep in all faces of the pedestrian walls at the pier and at 10 foot spacing between the pier and abutments.
- 602 SURFACE FINISH "D": Apply Surface Finish "D" on all exposed substructure surfaces, the fascia and bottom surface of the beams, the outside edges of the pier diaphragm, the

outside edges of the deck, the underside of the deck overhang, the exposed endwall areas outside of the beams, all surfaces of the light standard pedestals, and on all pedestrian wall surfaces. Use gray surface finish, color number 36176 meeting Aerospace Material Specification (AMS) Standard 595, for the fascia and bottom surface of the beams, the outside edges of the pier diaphragm and on the pier recessed form liner areas. Use gray surface finish, color number 36463 meeting AMS-STD-595, for all other surfaces.

Submit to the Engineer a 3" x 5" AMS-STD-595 color chip card for color numbers 36176 and 36463 with a declaration of conformity along with a 1' x 1' sample of the surface finish.

- PREBORING: Bore pilot holes through the constructed embankment for the abutment piling to an elevation of 2468 before driving piling. Bore pilot holes to a diameter of 24 inches. Prior to pile driving, backfill the pilot holes with polymer free sodium bentonite slurry. Mix the slurry at a ratio of 100 gallons of water per 120 pounds of bentonite. Use powdered bentonite to mix the slurry. Do not use bentonite chips. Place the slurry in the pilot hole from the bottom up using a tremie pipe. Check the hole after 24 hours for settlement of the slurry and top off the hole with slurry mixed at the previously specified ratio. Repeat this process until no observed settlement of the slurry occurs. Include all costs associated with boring pilot holes and backfilling with bentonite slurry in the price bid for HP14 x 73 piling.
- PILE DRIVING: Do not drive piling between the hours of 10:00 p.m. and 6:00 a.m.
- 622 PILING: Drive piling with a diesel hammer with a rated energy and ram weight (minimum of 6,000 pounds) of at least 109,340 foot-pound-tons computed by the formula:

W(E-30,800) + 0.710E

achieved.

W = Weight of the ram (tons)

E = Rated hammer energy

Run the hammer at an energy that produces a penetration at bearing between $\frac{1}{2}$ " and 3 inches in the last 10 blows.

Stop driving the pile if bearing is not yet obtained at a depth approximately 10 feet beyond the estimated depth. Wait 24 hours to allow pile setup to occur. After 24 hours warm the hammer with a minimum of 20 blows by striking the ground or timber mats. Restrike the pile with 10 blows to determine if bearing has been achieved. If bearing was not achieved during restrike, continue to drive the pile until bearing is

This document was originally issued and sealed by Brian W. Raschke, Registration Number PE-4361, on 01/07/20 and the original document is stored at the North Dakota Department of Transportation.

NOTES

STATE	PROJECT NO.	SECTION NO.	SHEET NO.
ND	IM-NHU-5-094(132)903	170	3

P30 ROADWAY CANOPY: A canopy is required to be constructed above the traveled roadway under the structure to protect traffic from falling material. The canopy is an added safeguard and does not relieve the Contractor from any responsibility for the safety of the public.


Submit the canopy details, including materials that will be used, to the Engineer for review. The canopy will provide a minimum vertical clearance of 15'-6" above the traveled roadway. The canopy will be extended a minimum distance of 5'-0" beyond the outside edge of deck of the structure and a minimum distance of 5'-0" beyond the edge of the driving lanes beneath the structure.

Construct the canopy before installing forming for the deck and keep in place until after the superstructure is complete. The canopy may be supported from the ground or suspended from the beams. Complete the installation of the canopy in a minimum amount of time and with the least inconvenience to the public.

Once the bridge superstructure is completed, remove the canopy. Roadway canopy will be paid for at the contract unit price for "Roadway Canopy." Payment for "Roadway Canopy" includes the construction, maintenance, and removal of the canopy system.

This document was originally issued and sealed by Brian W. Raschke, Registration Number PE-4361, on 01/07/20 and the original document is stored at the North Dakota Department of Transportation.

STATE	PROJECT NUMBER	SECTION NO.	SHEET NO.
ND	IM-NHU-5-094(132)903	170	4

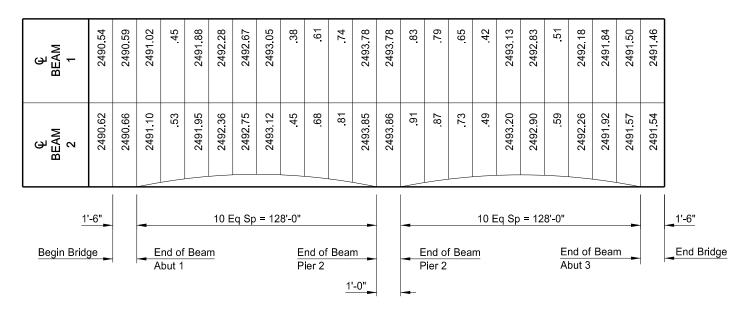

Beam 1 is the east beam. SCREED ELEVATIONS


BRIDGE BID ITEMS


SPEC	CODE	ITEM DESCRIPTION	UNIT	QUANTITY
OI LO	OODL	TEM BEGORII TION	OMIT	QUANTITI
210	0099	CLASS 1 EXCAVATION	L SUM	1
210	0201	FOUNDATION PREPARATION	EA	1
258	0100	CONCRETE SLOPE PROTECTION	SY	154
602	0130	CLASS AAE-3 CONCRETE	CY	144.8
602	1130	CLASS AE-3 CONCRETE	CY	89.6
602	1250	PENETRATING WATER REPELLENT TREATMENT	SY	496
604	9920	PRESTRESSED I-BEAM-63IN	LF	512.0
612	0115	REINFORCING STEEL-GRADE 60	LBS	10,716
612	0116	REINFORCING STEEL-GRADE 60-EPOXY COATED	LBS	28,916
622	0060	STEEL PILING HP 14 X 73	LF	150
622	0070	STEEL PILING HP 14 X 102	LF	90
624	0124	PEDESTRIAN FENCE	LF	578.7
930	3000	BRIDGE BENCH MARKS	SET	1
930	7012	ROADWAY CANOPY	L SUM	1
930	8600	ELASTOMERIC BEARING PAD	SF	16.0
930	9537	ABUTMENT UNDERDRAIN SYSTEM	EA	2

This document
was originally issued and
sealed by Brian W. Raschke,
Registration Number PE 4361,
on 01/07/20 and the original
document is stored at the North
Dakota Department of
Transportation

I-94 PEDESTRIAN CROSSOVER WEST DICKINSON INTERCHANGE

 SCREED ELEVATIONS & BID ITEM QUANTITIES



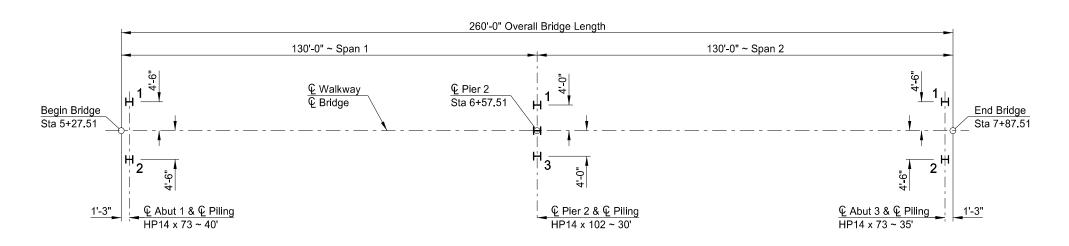

Drive the HP14 x 73 Pile to 180 tons.
Drive the HP14 x 102 Pile to 250 tons.
PILING LAYOUT

NOTE:

For double acting or single acting diesel hammers, calculate the safe bearing value of piles by the following formula:

$$P = \frac{4.5E}{S + 0.2} \times \frac{W + 0.2M}{W + M}$$

Where:

P = Safe bearing value, in pounds.

W = Weight of striking parts (ram), in pounds.

M = Weight of parts being driven, in pounds. Includes pile weight, anvil (if any), driving cap, etc.

E = Energy per blow, in foot-pounds.

S = Average penetration of pile in inches per blow for last ten blows.

For single acting hammers, calculate E by multiplying observed stroke (ft) and W (lbs).

PILE COORDINATES				
	PILE	NORTHING	EASTING	
ABUT 1	1	455,723.29	1,386,182.08	
ABL	2	455,719.77	1,386,173.80	
PIER 2	1	455,604.56	1,386,231.90	
ᇤ	3	455,601.44	1,386,224.53	
ABUT 3	1	455,486.23	1,386,282.63	
	2	455,482.71	1,386,274.35	

This document
was originally issued and
sealed by Brian W. Raschke,
Registration Number PE 4361,
on 01/07/20 and the original
document is stored at the North
Dakota Department of
Transportation

I-94 PEDESTRIAN CROSSOVER WEST DICKINSON INTERCHANGE

PILING LAYOUT & BEARING ELEVATIONS

| El 2484.54 | Q Bridge | Sta 6+57.51 | El 2487.70 | El 2485.44 | End Bridge | Sta 7+87.51 | El 2487.77 | El 2485.51 | El

 
Elevations shown are to top of finished concrete.


BEARING ELEVATIONS

19EAJ082

BWR

1/8/2020 5:08:58 PM braschke R:\project\50094903.132\bridge\94-059.503\170BR_005_PILELO.dgn



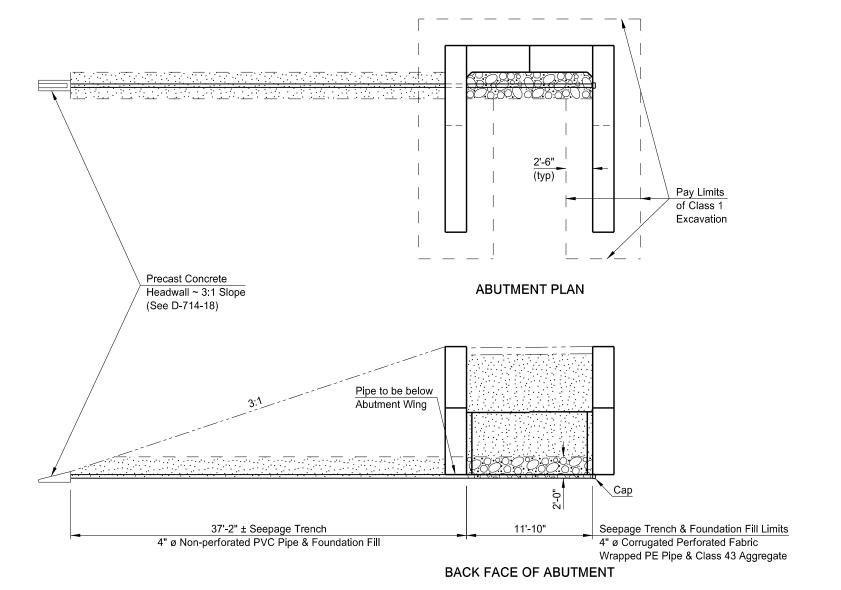

NOTES:

Use corrugated perforated fabric wrapped PE pipe that meets the requirements of Section 830.03 A.4. Provide fabric wrapping for the pipe that meets the requirements of Section 858.01 for D3 or D4 drainage fabric. Use non-perforated PVC pipe that meets the requirements of Section 830.03 A.3. Provide aggregate that meets the requirements of Section 816.03, Class 43. Provide foundation fill that meets the requirements of Section 210.

Include the cost to furnish and place the foundation fill, aggregate, corrugated perforated pipe, non-perforated pipe and headwalls in the pay item "Abutment Underdrain System."

This document
was originally issued and
sealed by Brian W. Raschke,
Registration Number PE 4361,
on 01/07/20 and the original
document is stored at the North
Dakota Department of
Transportation

I-94 PEDESTRIAN CROSSOVER WEST DICKINSON INTERCHANGE

 
ABUTMENT UNDERDRAIN & EXCAVATION DETAILS

Place embankment to this line prior to driving abutment piling. Foundation Fill 12:1] 2.5:1 Class 43 Aggregate Pay Limits 4" ø Corrugated Perforated of Class 1 Fabric Wrapped PE Pipe Excavation 2'-6" 2'-6" 7'-6" **DETAIL AT ABUTMENT**


1/8/2020

5:08:59 PM

braschke



STATE	PROJECT NUMBER	SECTION NO.	SHEET NO.
ND	IM-NHU-5-094(132)903	170	7

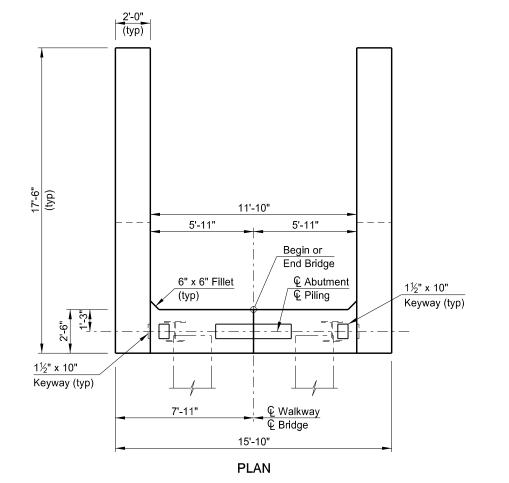

Ā

1½" x 10"

Keyway (typ)

A

9'-0" ~ HP14 x 73 Piling

15'-10"

ELEVATION

1½" x 10"

3'-5"

Keyway (typ)

Waterproof Membrane


(typ) ~ Back Face

2'-0" (typ)

> 3'-0" (typ)

> > 3'-5"

12'-0" (typ)

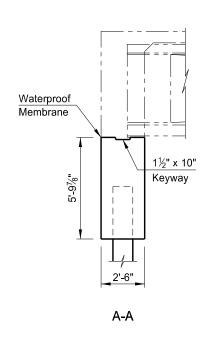


NOTE:

Use waterproof membrane that meets the requirements of Section 602.03 B. Center the waterproof membrane (1"-0" minimum width) on the joint.

NOTE:

Abutment 1 shown in elevation view, facing north.

This document
was originally issued and
sealed by Brian W. Raschke,
Registration Number PE 4361,
on 01/07/20 and the original
document is stored at the North
Dakota Department of
Transportation

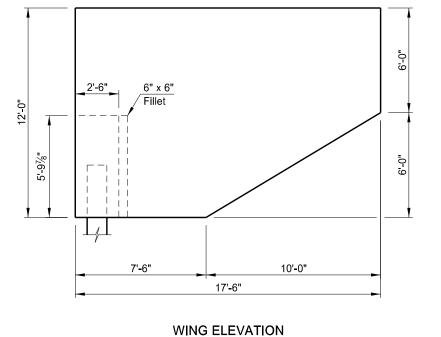


QUANTITIES


SEE DWG 94-059.503-8

I-94 PEDESTRIAN CROSSOVER WEST DICKINSON INTERCHANGE

(SHOWING DIMENSIONS)

ABUTMENT DETAILS

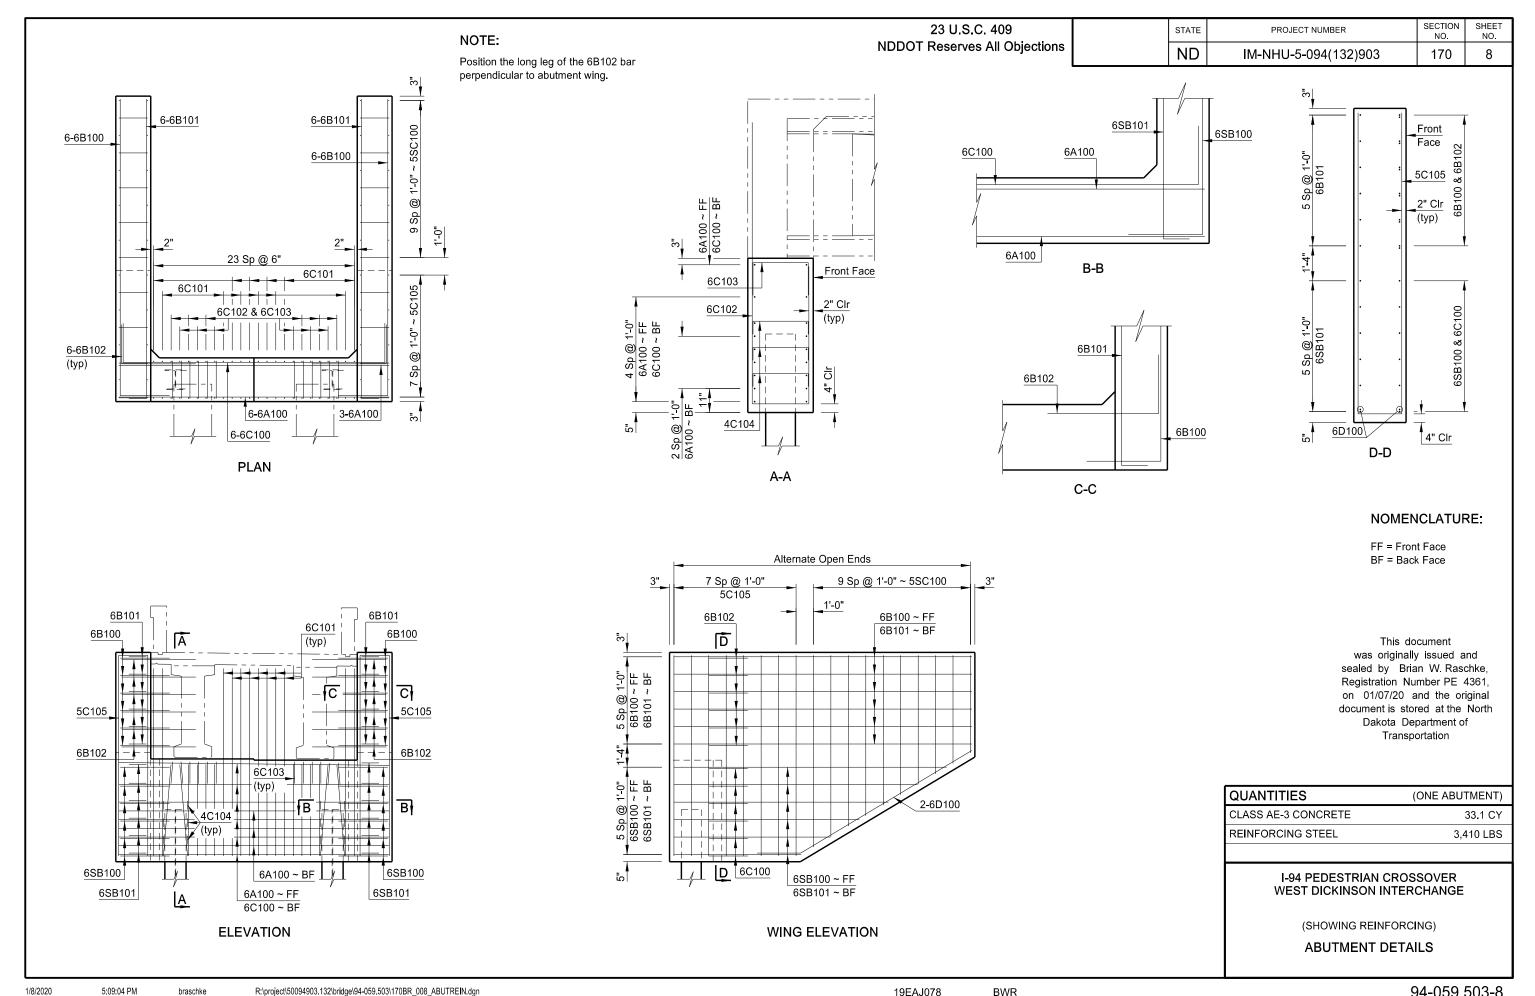

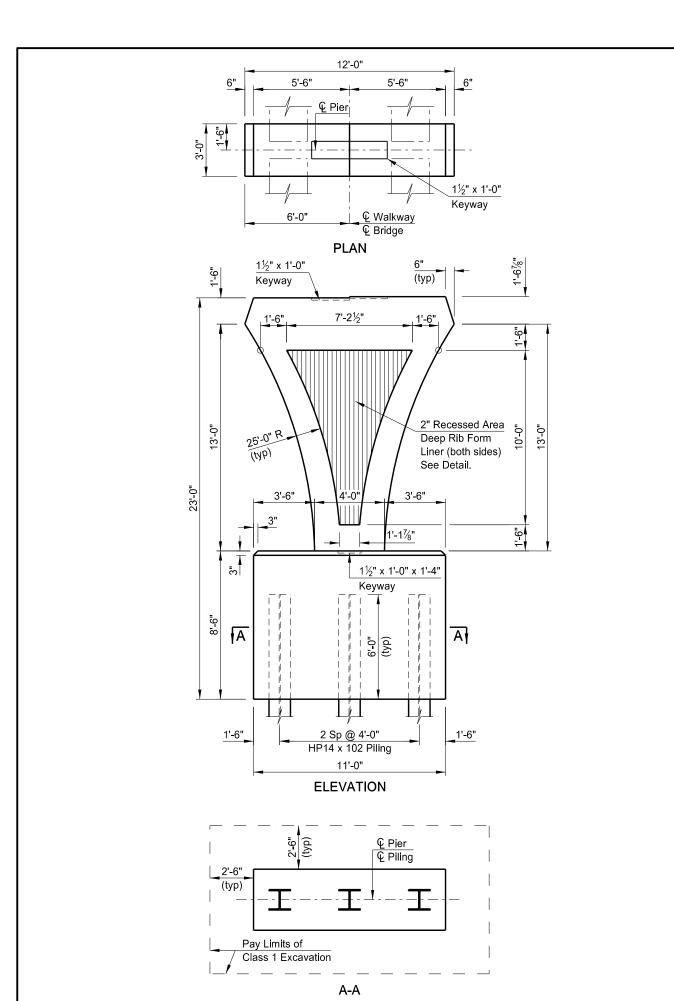

1/8/2020

5:09:06 PM

23 U.S.C. 409 NDDOT Reserves All Objections

3'-0"

3'-6"

2" (typ)


1½" x 1'-0" x 1'-4"

Keyway

1½" x 1'-0"

Keyway

STATE	PROJECT NUMBER	SECTION NO.	SHEET NO.
ND	IM-NHU-5-094(132)903	170	9

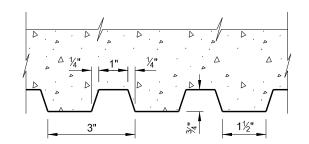

DEEP RIB FORM LINER DETAIL

This document
was originally issued and
sealed by Brian W. Raschke,
Registration Number PE 4361,
on 01/07/20 and the original
document is stored at the North
Dakota Department of
Transportation

QUANTITIES


SEE DWG 94-059.503-10


I-94 PEDESTRIAN CROSSOVER WEST DICKINSON INTERCHANGE

(SHOWING DIMENSIONS)

PIER DETAILS

braschke R:\project\50094903.132\bridge\94-059.503\170BR_009_PIERDIM.dgn 19EAJ087 BWR 94-059.503\170BR_009_PIERDIM.dgn

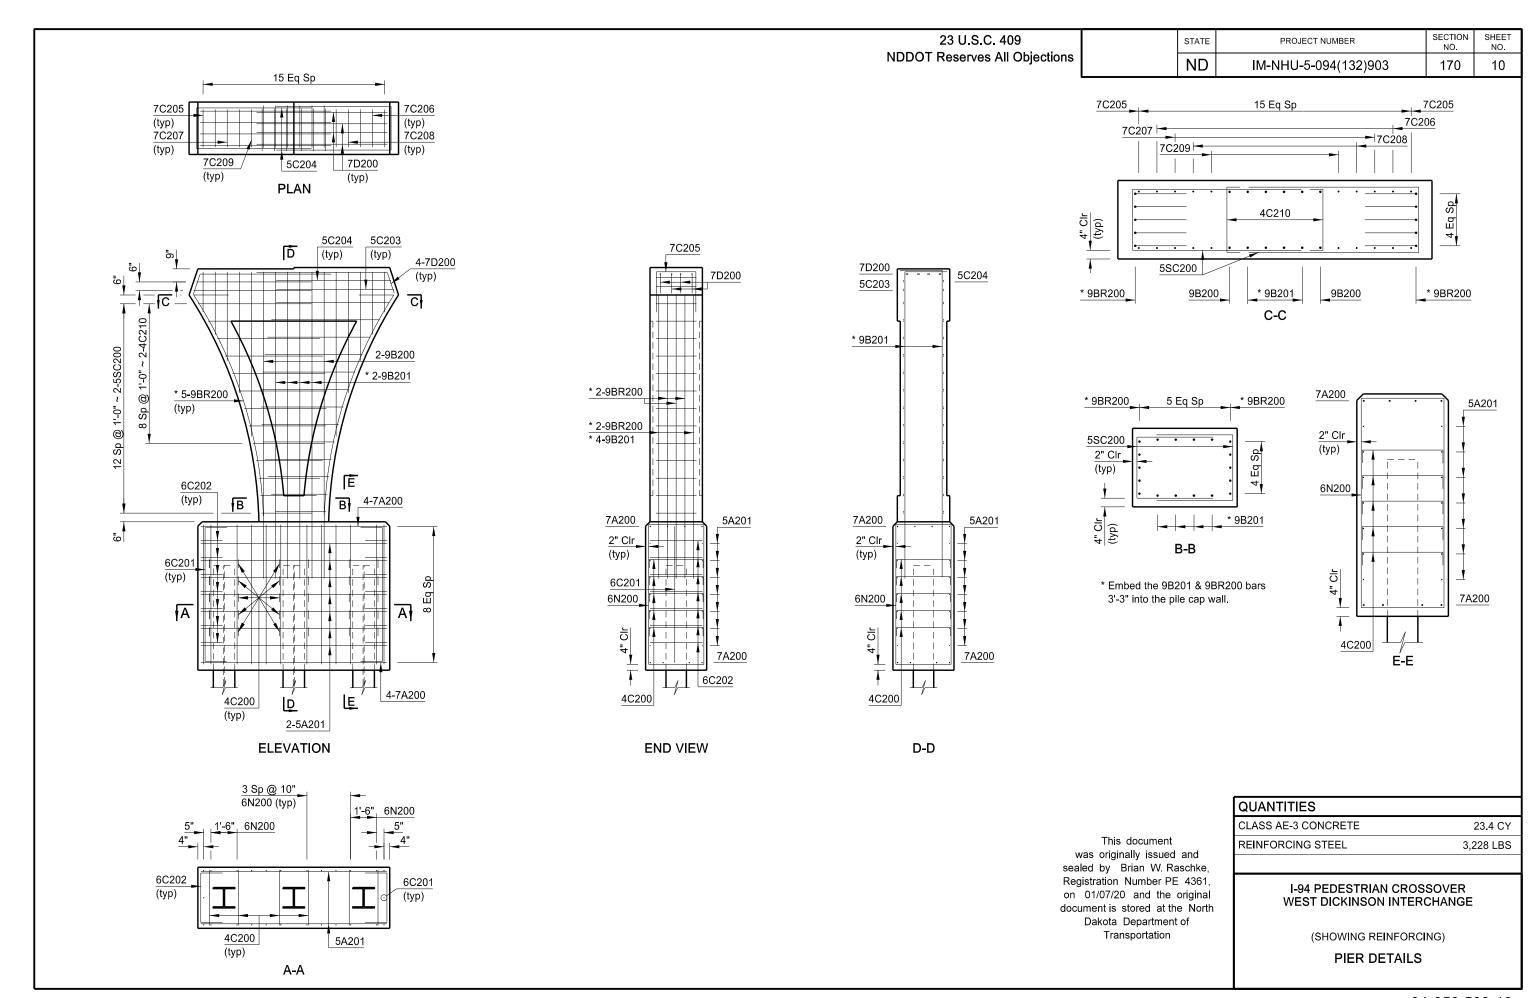

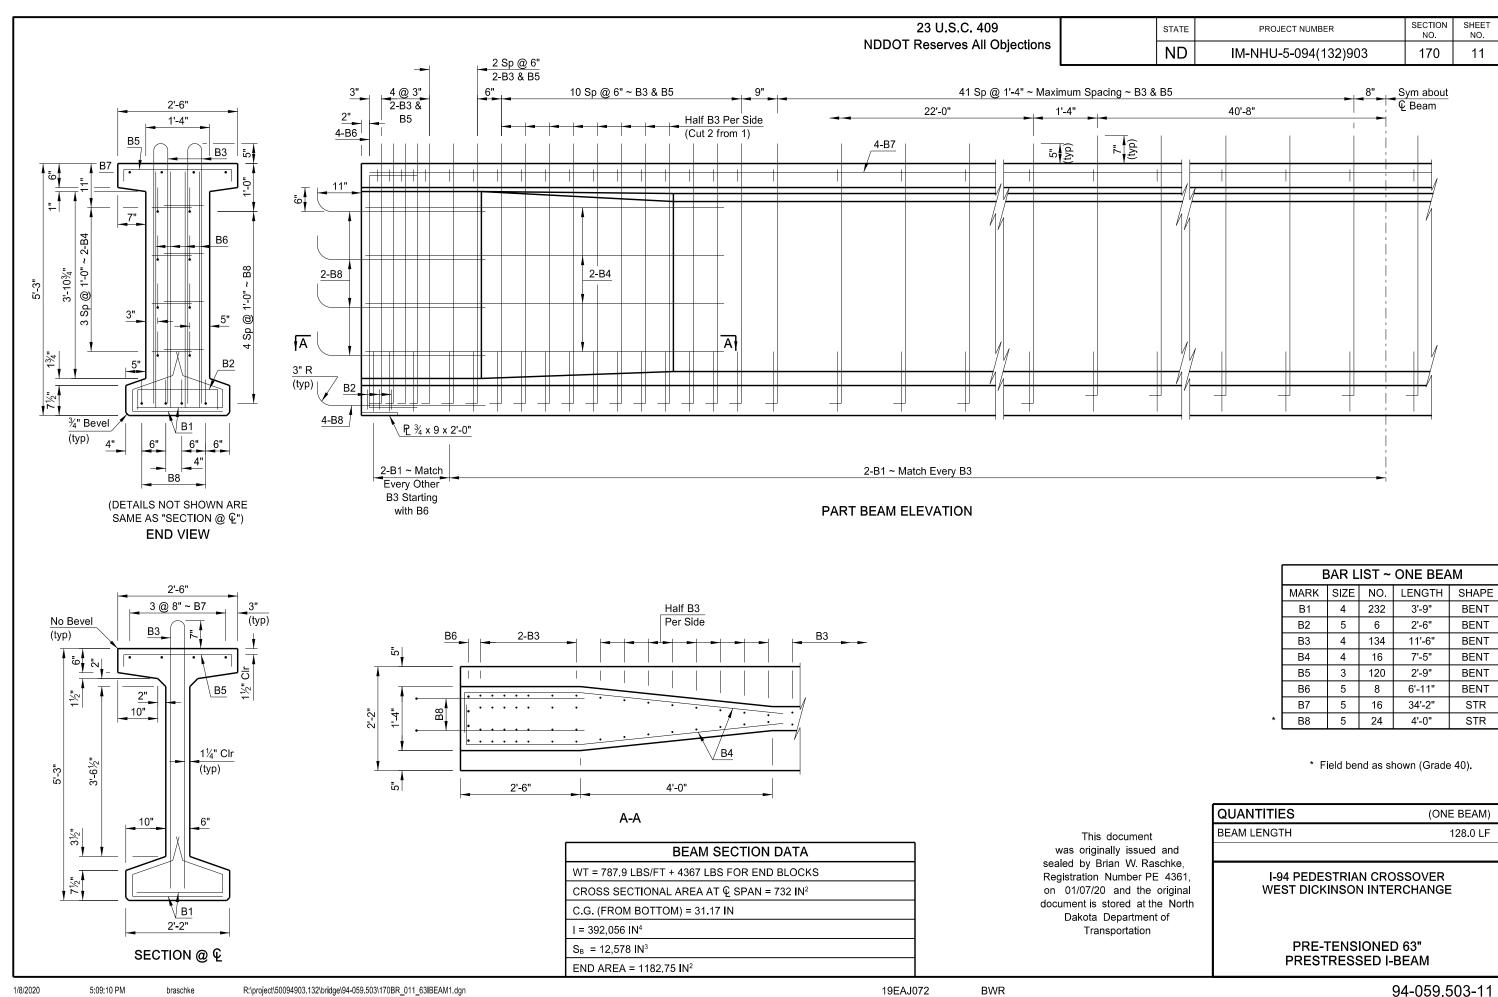

STATE	PROJECT NUMBER	SECTION NO.	SHEET NO.
ND	IM-NHU-5-094(132)903	170	12

ACCEPTANCE

STRENGTH

6000 psi

(Min)

WEIGHT

(TONS)

52.6

BEAM

LENGTH

128'-0"

PRESTRESSING DATA

DETENSION

STRENGTH

6000 psi

(Min)

FINAL

FORCE

1055.9 k

1061.9 k

1067.8 k

C.G.

3.50"

3.75"


4.00"

NOTES:

Select the final prestress force (remaining after all losses have been accounted for) and its corresponding center of gravity, from those on a curve determined by the three values shown in the "Prestressing Data" table.


Provide holes and inserts in the beams at locations shown to accommodate the diaphragm bars.

Minor changes to the shape of the beam and to reinforcing steel may be made to accommodate the forms of various contractors and their construction methods with the approval of the Engineer.

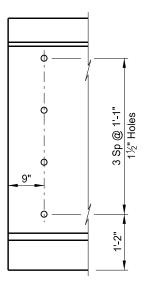


(Use holes for the beams at the Abutments. Use inserts for the beams at the Pier.)


> **ELEVATION BEAM END DETAIL**

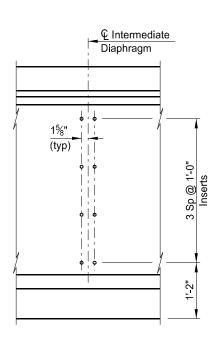


(See Dwg 94-059.503-13 for locations.)

INTERMEDIATE DIAPHRAGM DETAIL

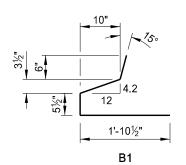

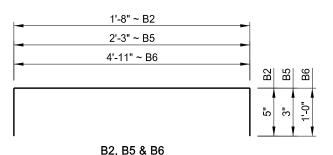

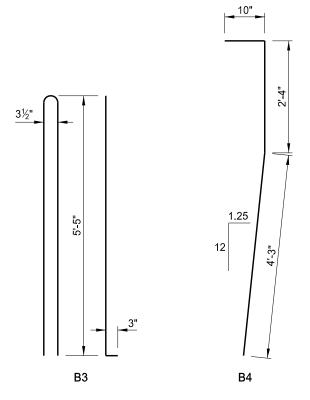

(DIMENSIONS SHOWN ARE OUT TO OUT) **BENT BAR DETAILS**


This document was originally issued and sealed by Brian W. Raschke, Registration Number PE 4361, on 01/07/20 and the original document is stored at the North Dakota Department of

Transportation

94-059.503-12

I-94 PEDESTRIAN CROSSOVER WEST DICKINSON INTERCHANGE

> PRE-TENSIONED 63" PRESTRESSED I-BEAM

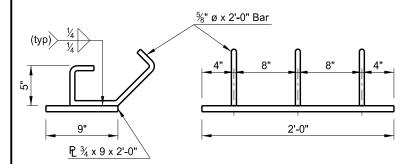


(Use ASTM A36 steel, hot dipped galvanized, for the bearing plate. Include the costs in the bid price for the beam.)


BEARING DETAIL

ELEVATION


1/8/2020 5:09:12 PM braschke R:\project\50094903.132\bridge\94-059.503\170BR_012_63IBEAM2.dgn 19EAJ073 BWR

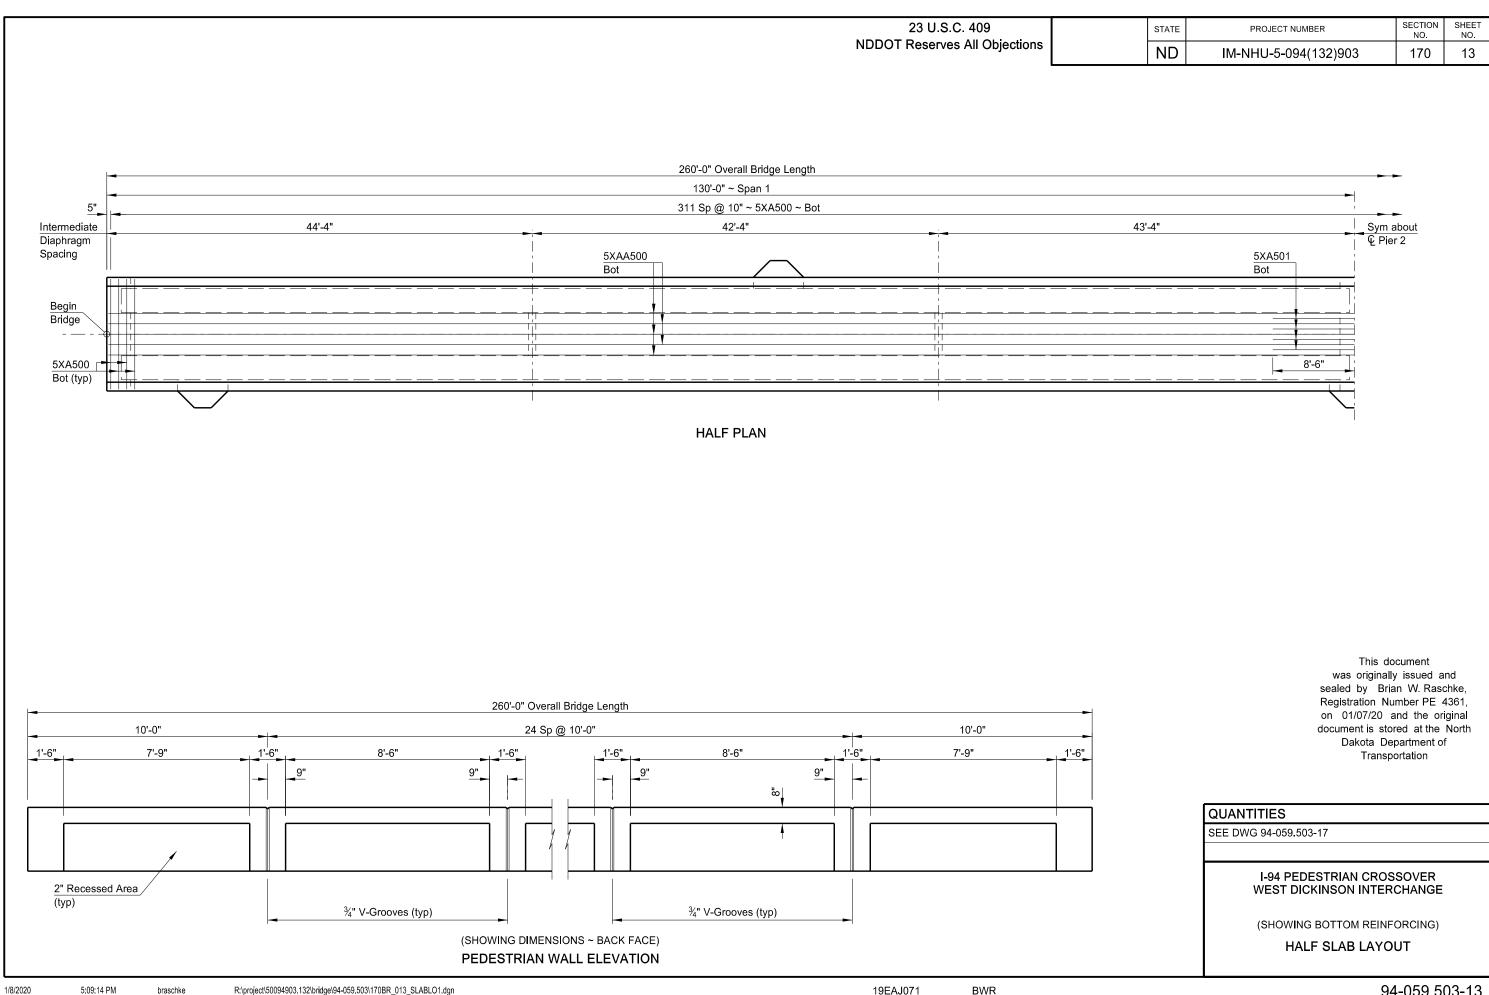

STATE	PROJECT NUMBER	SECTION NO.	SHEET NO.
ND	IM-NHU-5-094(132)903	170	14

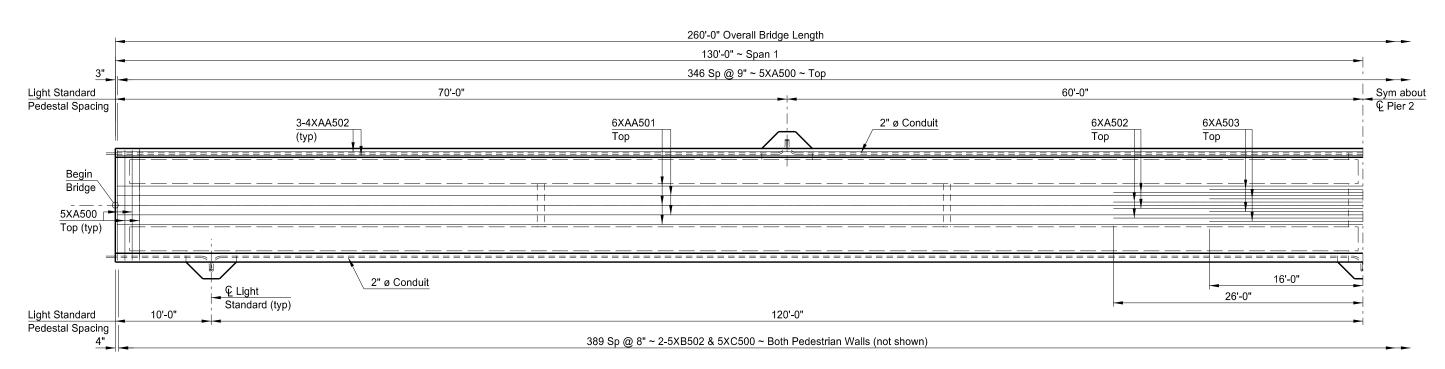

HALF PLAN

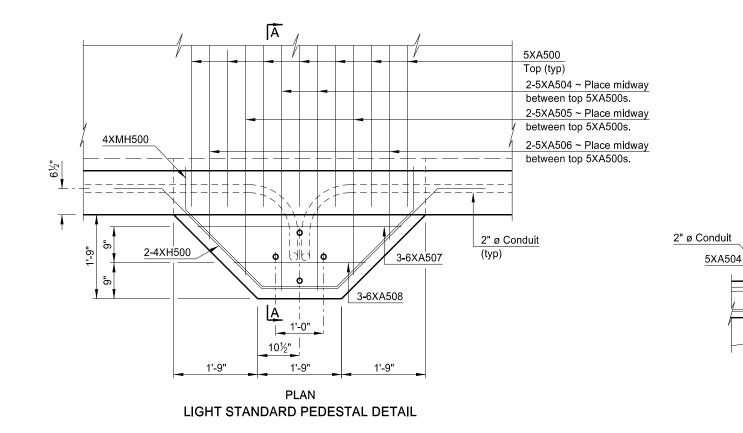

1/8/2020

5:09:17 PM

LIGHT STANDARD PEDESTAL LOCATIONS		
STATION	OFFSET	
5+37.51	6'-9½" Rt	
5+97.51	6'-9½" Lt	
6+57.51	6'-9½" Rt	
7+17.51	6'-9½" Lt	
7+77.51	6'-9½" Rt	

This document
was originally issued and
sealed by Brian W. Raschke,
Registration Number PE 4361,
on 01/07/20 and the original
document is stored at the North
Dakota Department of
Transportation

QUANTITIES
SEE DWG 94-059.503-17

I-94 PEDESTRIAN CROSSOVER WEST DICKINSON INTERCHANGE

(SHOWING TOP REINFORCING)

HALF SLAB LAYOUT

braschke R:\project\50094903.132\bridge\94-059.503\170BR_014_\$LABLO2.dgn 19EAJ101 BWR 19EAJ101 BWR

A-A

4XMH500

6XA507


1'-9"

9" 9"

6XA508


1¼" ø Holes

4XH500

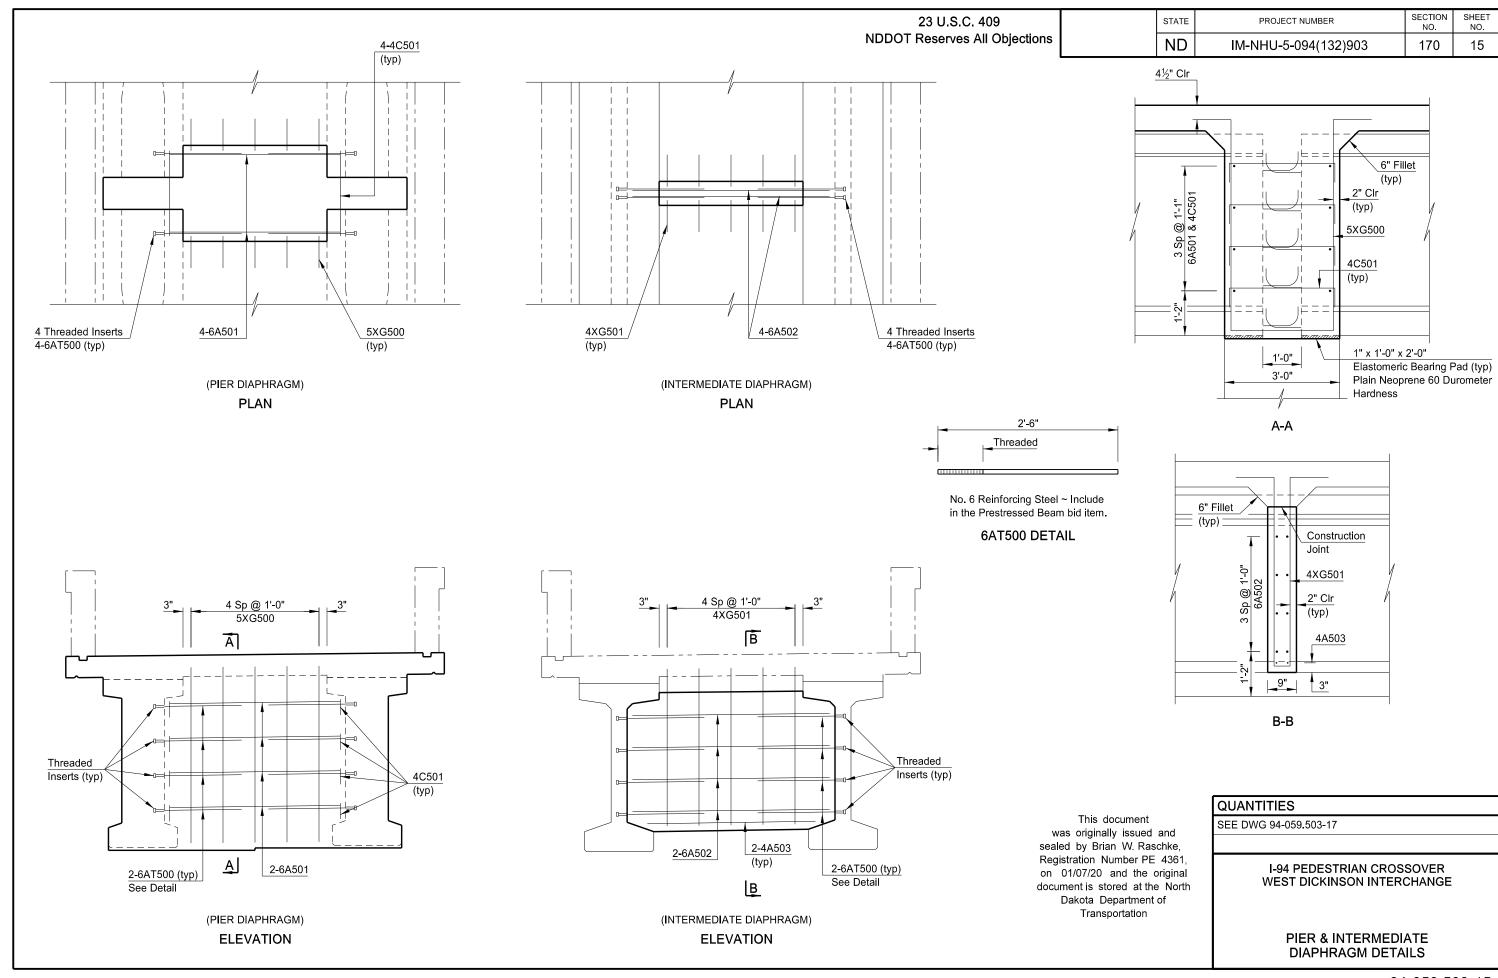


1/8/2020 5:09:19 PM braschke R:\project\50094903.132\bridge\94-059.503\170BR_015_DIAPHRAGM.dgn 19EAJ075 BWR 94-059.503\170BR_015_DIAPHRAGM.dgn


STATE	PROJECT NUMBER	SECTION NO.	SHEET NO.		
ND	IM-NHU-5-094(132)903	170	16		

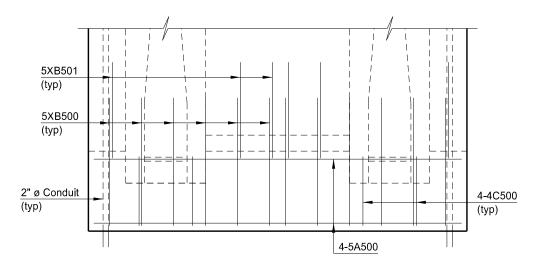

PLAN

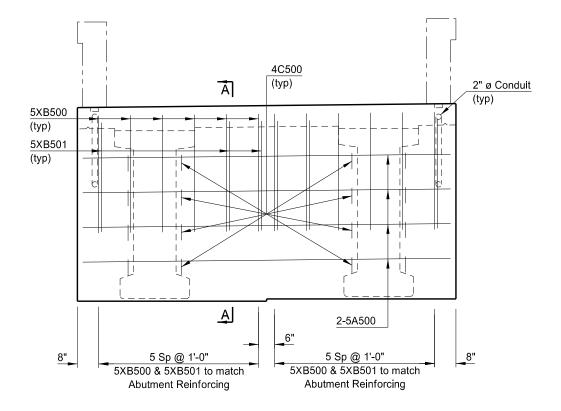

ELEVATION

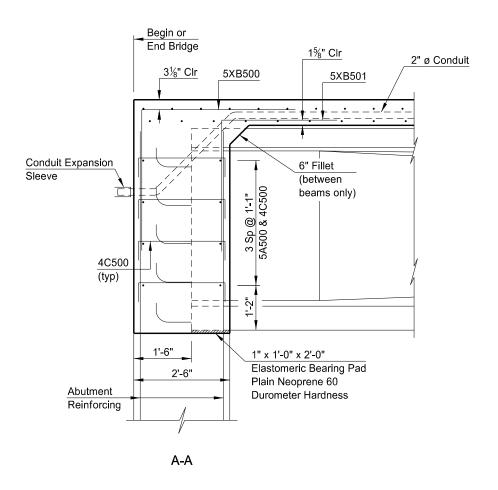

This document
was originally issued and
sealed by Brian W. Raschke,
Registration Number PE 4361,
on 01/07/20 and the original
document is stored at the North
Dakota Department of
Transportation

 
QUANTITIES

SEE DWG 94-059.503-17


I-94 PEDESTRIAN CROSSOVER WEST DICKINSON INTERCHANGE


ENDWALL DETAILS

1/8/2020 5:09:20 PM braschke R:\project\50094903.132\bridge\94-059.503\170BR_016_ENDWALL.dgn 19EAJ080 BWR 94-059.503\170BR_016_ENDWALL.dgn




STATE	PROJECT NUMBER	SECTION NO.	SHEET NO.		
ND	IM-NHU-5-094(132)903	170	17		

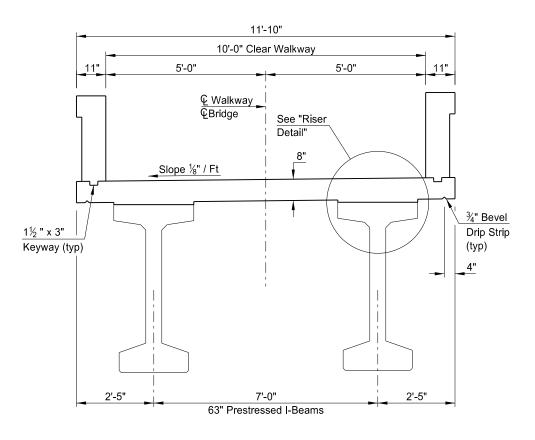


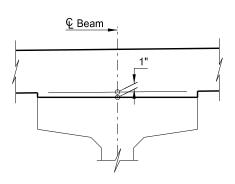

RISER DETAIL

The 1" dimension shown is located at the abutments and pier. The anticipated midspan riser is $3\frac{1}{2}$ ". Adjust the riser to maintain the 8" slab thickness.

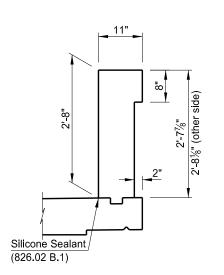

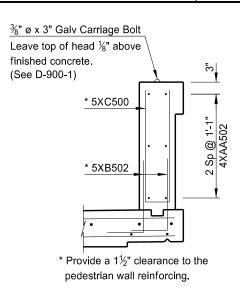

SHOWING DIMENSIONS

SHOWING REINFORCING

PEDESTRIAN WALL DETAIL

(SHOWING DIMENSIONS)
SLAB SECTION

8" 10 Sp @ 1'-0" ~ 6XAA501 ~ Top 8" 3" 5XC500 (typ) 5XB502 (typ) 2½" Clr 5XA500 2" Ø Conduit (typ) 5XAA500 ~ Bot 6x AA500 ~ Bo

5 Sp @ 1'-0" 5 Sp @ 1'-0" 6XA502 ~ Top 6XA502 ~ Top _1'-3"_ 4 Sp @ 1'-0" 1'-4" 4 Sp @ 1'-0" 6XA503 ~ Top 6XA503 ~ Top 5XC500 (typ) 5XB502 5XA500 2½" Clr (typ) 1" Clr 7½" 7½" 5XA501 3 Sp @ 1'-1" Bot (typ) 5XA501 ~ Bot

QUANTITIES
CLASS AAE-3 CONCRETE

CLASS AAE-3 CONCRETE 144.8 CY
REINFORCING STEEL 668 LBS
REINFORCING STEEL (EPOXY) 28,916 LBS

This document was originally issued and

sealed by Brian W. Raschke,

Registration Number PE 4361,

on 01/07/20 and the original

document is stored at the North Dakota Department of Transportation

I-94 PEDESTRIAN CROSSOVER WEST DICKINSON INTERCHANGE


SLAB SECTION


(SHOWING REINFORCING BETWEEN ABUTMENTS AND PIER)

SLAB SECTION


(SHOWING REINFORCING OVER PIER)
SLAB SECTION

1/8/2020 5:09:22 PM braschke R:\project\50094903.132\bridge\94-059.503\170BR_017_SLABSEC.dgn 19EAJ070 BWR 94-059.503\170BR_017_SLABSEC.dgn

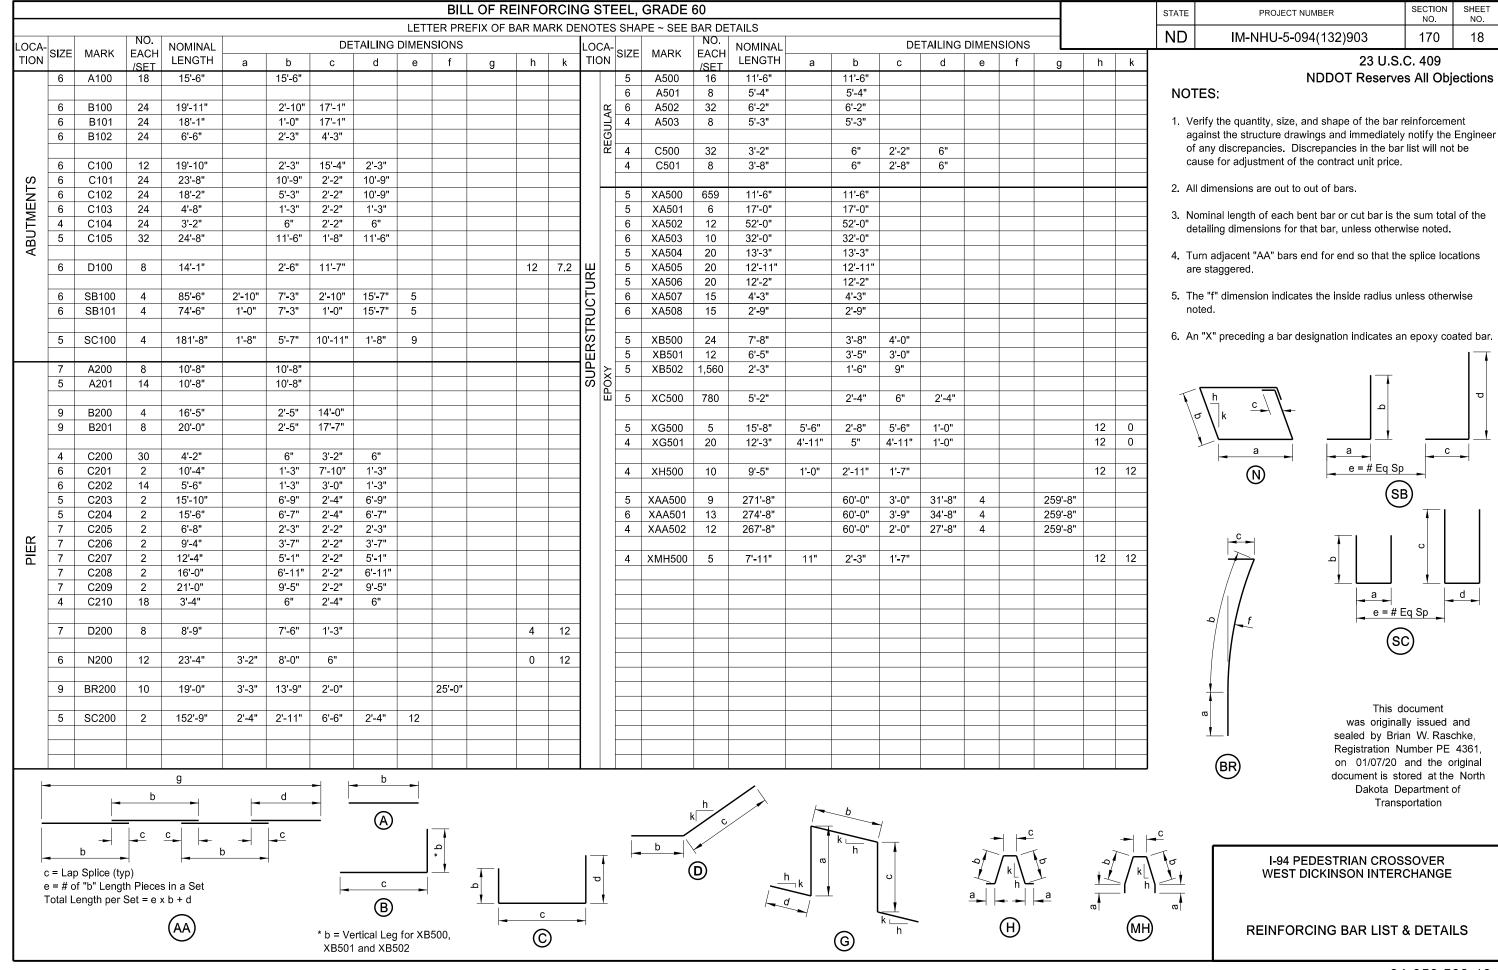

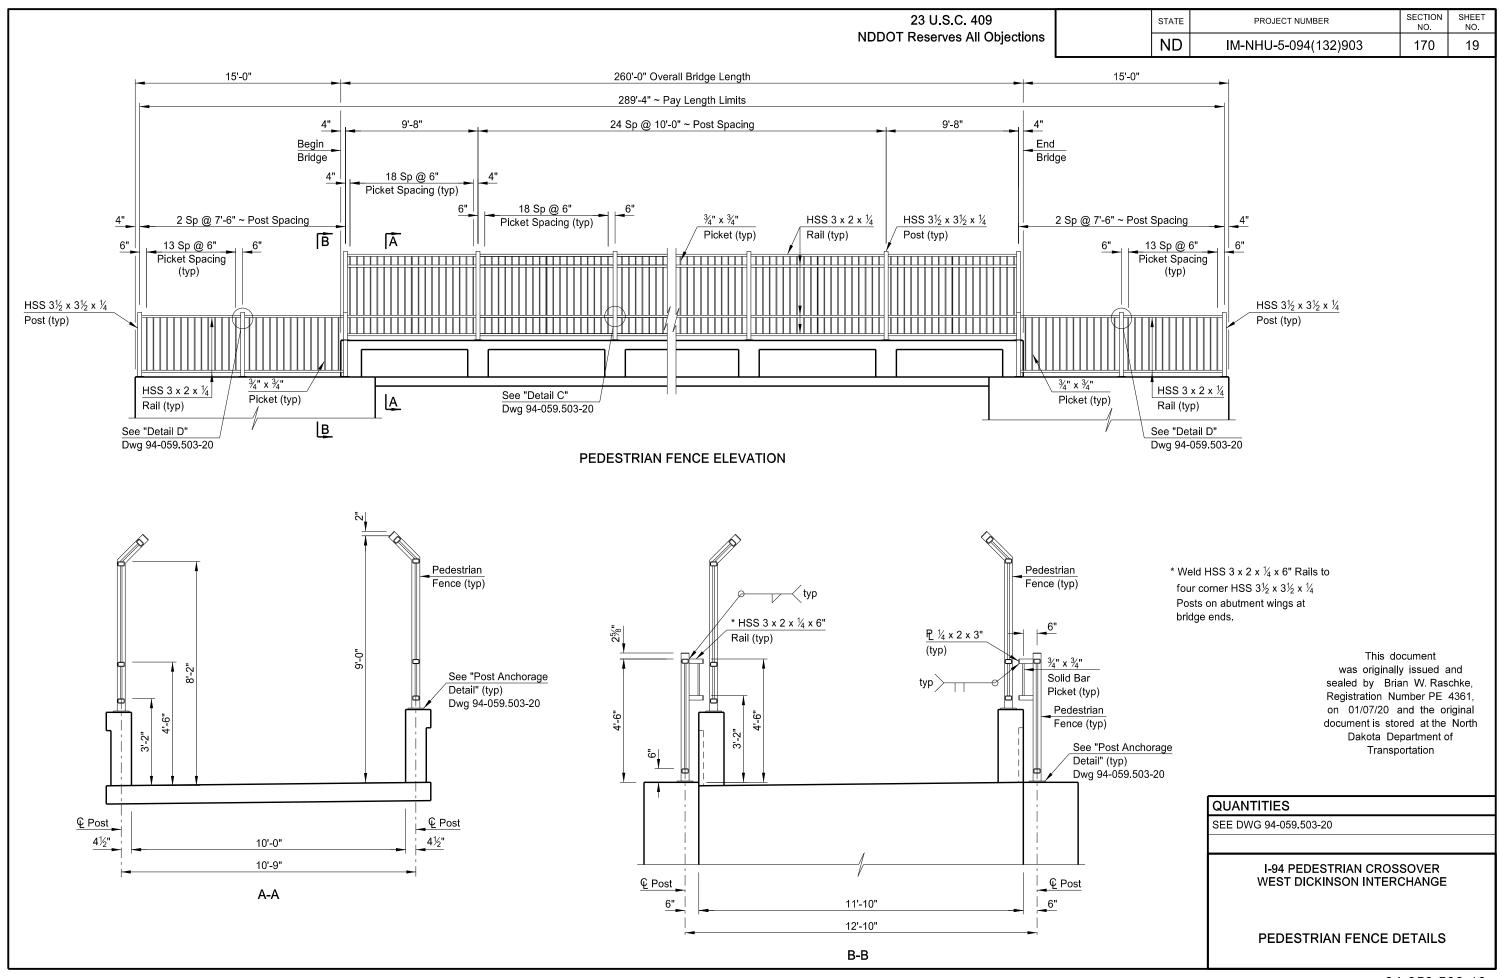

1/8/2020 5:09:26 PM braschke R:\project\50094903.132\bridge\94-059.503-19

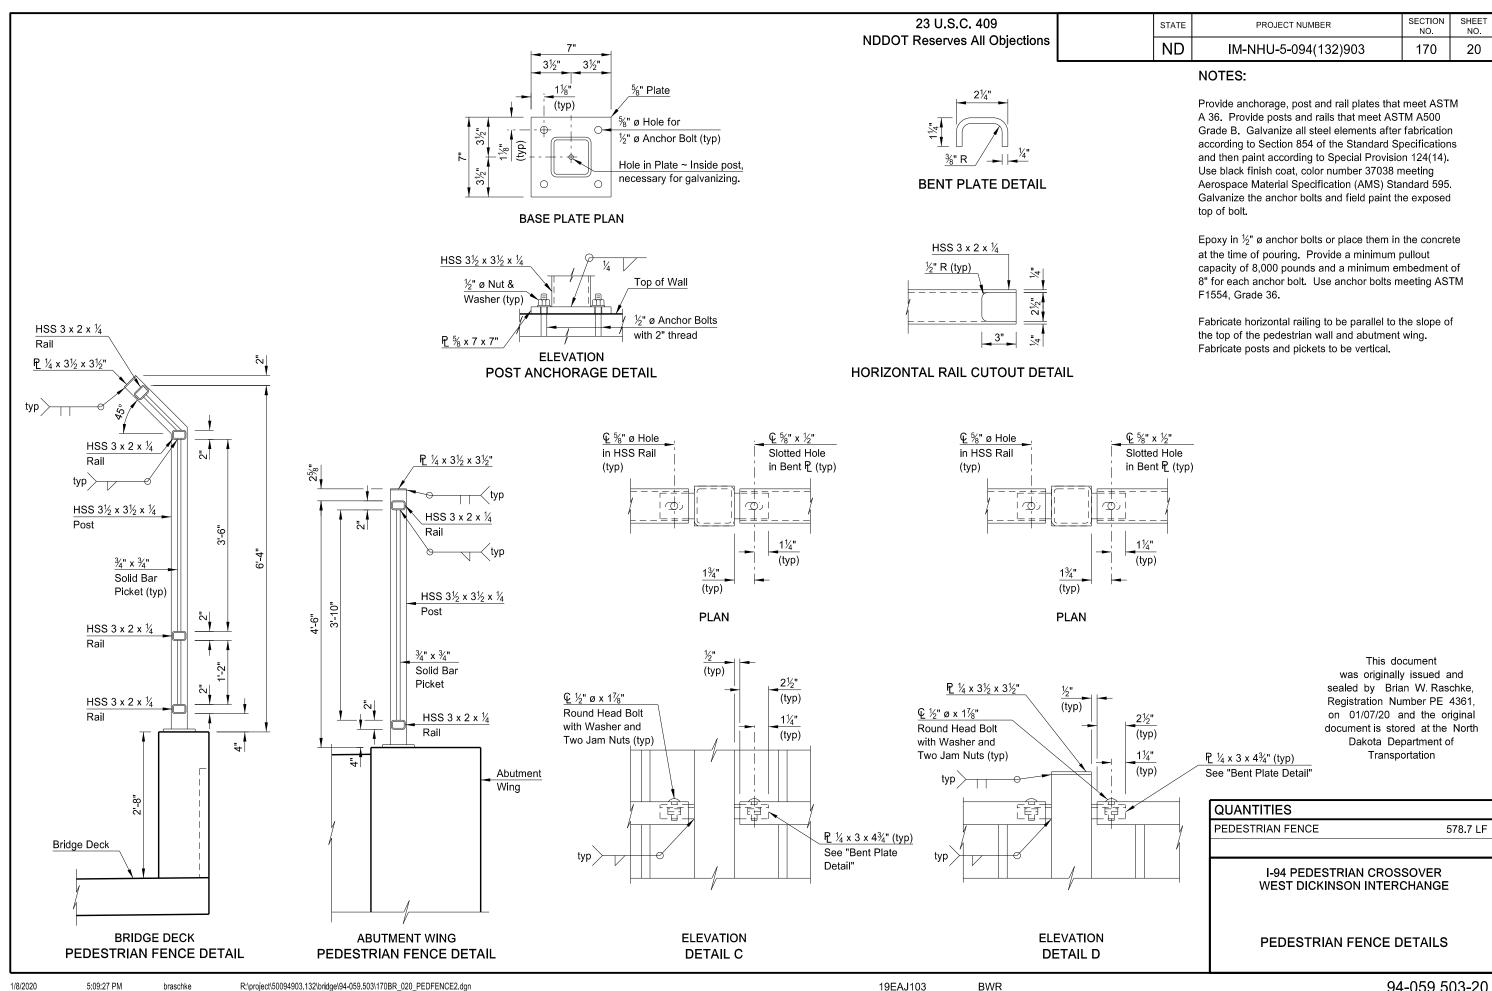

LOG OF BORING SB - 1 PAGE 1 OF 1

NORTH DAKOTA DEPARTMENT OF TR 300 AIRPORT ROAD Department of Transportation BISMARCK, ND 58504	MANSPORATION	PAGE 1 OF 1			
PROJECT NUMBER IM-NHU-5-094(132)903	DATE STARTED 7/16/19	COMPLETED 7/16/19			
PCN 22219	ELEVATION 2468.64 ft				
LOCATION Stark County	Northing 5200330.50 ft	Easting 208216.50 ft			
DRILLED BY Dallan LOGGED BY Jamie	DRILLING METHOD				
ENGINEER					
NOTES North Abutment Boring					

NOT					NOTES North Abutment Boring											
ELEVATION (ft)	DEPTH (ft)	MATERIAL DESCRIPTION		GRAPHIC LOG	AASHTO	nscs	SAMPLE TYPE & NUMBER	RECOVERY (%)		PT N VALUE		Pl F 20	40 AY FF (%	RACT)	80 ION	TESTS & REMARKS
-	0	Loose Silty/Clayey Sand			A-4	SC-SM	\	75	-11 . ⊚ ;	40 60 80	 	—22 ● :H	3 40 :	60 :	80	
-					A-2-4	SM	SS 614	75	10 ···· ⊚		0 0)· · · · <u>·</u> · ·				
-	1				A-2-4 A-2-4	SM SM	3TW 615	90	_			21·				CU=20.3°, c'=249 psf Con-30-19
-		2460.6 ft	8.0 ft		A-2-4	SM	SS 616	85	5 · · · · · · · · · · · ·			• :125 • :H				
2460	10-	Loose Silty Sand			A-2-4	SM	3TW 617	85			0)				
-					A-2-4	SM	617 SS 618	85	10 ·⊚· ···		0					
-											 				į	
_] -	2451.6 ft	17.0 ft		A-2-4	SM	3TW 619 V SS	85		49	0	• … <u>:</u> …،				
2450 ⁻		Dense Silty Sand			A-2-4	SM	SS 620	85		© :	 0					
-	20-			H	A-2-4 A-2-4	SM SM	3TW 621 SS	100 90		59 @	0					
-	-				7.2-4	OW	∆ SS 622	90								
-					A-2-4	SM	SS 623	85		····58 ····	 	… <u>:</u> •				
-	-				A-2-4	SM	SS 624	80		60 ⊚	···0	i •				
2440										58 •	ا… 0	·····i···)				
-	30-				A-2-4	SM	SS 625 SS	100		60 ©	0)				
-					A-2-4	SIVI	SS 626	80								
-					A-2-4	SM	SS 627	85	3	9: : : 58	ا ا	,				
-					A-2-4	SP-SM	SS 628	90		9 9	Ĭ	•				
2430 ⁻	40-				A-2-4	SM	SS 629	100		65 ••••••	0	· · · · •				
] -				A-2-4	SM	SS 629 SS 630	100			10 ••••)0 : }···∳··				
_																
_																
2420 ⁻											 910					
-	50-				A-2-4	SM	SS 631	100			⊚ [.				
-																
-									·····			••••	••••••			
-									!			••••		. !		
2410 ⁻					A-2-4	SM	SS 632	100			···∣ 7 0 •··∣)				
-	60-				~~2-4	JIVI	/∖ 632	100	ļ							
-							1 00		ļ <u>.</u>		 10 ·	.0				
	1	2402.6 ft	66.0 ft		A-2-4	SM	SS 633	100		<u> </u>	· 10	•	<u>:</u>	<u>:</u>	:	

STATE	PROJECT NO.	SECTION NO.	SHEET NO.	
ND	IM-NHU-5-094(132)903	175	1	

This document was originally issued and sealed by Jared J. Loegering, Registration Number PE-10931, on 12/31/2019 and the original document is stored at the North Dakota Department of Transportation

Boring Log 1

I-94 Business Loop from I-94 to 8th Street Shared Use Path, Bridge, and Lighting

LOG OF BORING SB - 2

PAGE 1 OF 1

 PROJECT NUMBER
 IM-NHU-5-094(132)903
 DATE STARTED
 7/16/19
 COMPLETED
 7/16/19

 PCN
 22219
 ELEVATION
 2468.12 ft
 Easting
 208228.92 ft

 LOCATION
 Stark County
 Northing
 5200288.12 ft
 Easting
 208228.92 ft

 DRILLED BY
 Dallan
 LOGGED BY
 Jamie
 DRILLING METHOD

 ENGINEER
 The county of the county of

NORTH DAKOTA DEPARTMENT OF TRANSPORATION 300 AIRPORT ROAD
BISMARCK, ND 58504

NOTE	NOTES Pier Boring										
ELEVATION (ft)	DEPTH (ft)	MATERIAL DESCRIPTION	GRAPHIC LOG	AASHTO	nscs	SAMPLE TYPE & NUMBER	RECOVERY (%)	© SPT N VALUE O SPT N VALUE			
	0	Stiff Silty/Sandy Clay		A-7-6	ML	SS 634	75	T11 · · · · · 2942 · · · · · · · · · · · · · · · · · · ·			
-	-			A-4	SM	SS 635	75				
-	-			A-6 A-6	CL CL	3TW 636	80				
-	-			A-7-6	СН	SS 637	60	7.9.:			
2460-	-			A-7-6	СН	•					
-	10-	2456.1 ft 12.0	ft H	A-7-6	CL	3TW 638	85	UU=1603 psf			
-		Dense Silty Sand		A-2-4	SM	SS 639	90				
-	1			A-2-4	SM	3TW 640	75				
-	-			A-2-4	SM	SS 641	100				
2450-				A-2-4	SM	3TW	160	0			
-	20-			A-2-4		642 SS	100	-1 : :32: : U : : : :			
-	-					643					
-	-			A-2-4	SM	SS 644	100	39 0 0 0 0 0 0 0 0 0 0 0 0 0 0 0 0 0 0 0			
-	-			A-2-4	SM	SS 645	100	9			
2440-								- 55 0 · · · · · · · · · · · · · · · · ·			
-	30-			A-2-4	SM	SS 646	100	- : : :66 : 0 : : : :			
-	-			A-2-4	SM	SS 647	100) -			
-	1					SS 648	100				
-	1			A-2-4	SM	SS 649	100	···································			
2430-	-							- 62 0			
-	40-			A-2-4	SM	SS 650 SS	100	- : : : 100 : : : : : : : : : : : : : : :			
-	-			A-2-4	SM	651	100				
-	1										
-											
2420-						1/1 00		100			
-	50-			A-2-4	SM	SS 652	130) 			
2440- 											
-				A-2-4	SM	SS 653	100				
-						, y 555					
2410-						\		100			
	60-	2407.1 ft 61.0 ft	ft	A-2-4	SM	SS 654	100	•			
Щ		Bottom of borehole at 61.0 ft									

STATE	PROJECT NO.	SECTION NO.	SHEET NO.	
ND	IM-NHU-5-094(132)903	175	2	

This document was originally issued and sealed by Jared J. Loegering, Registration Number PE-10931, on 12/31/2019 and the original document is stored at the North Dakota Department of Transportation

Boring Log 2

I-94 Business Loop from I-94 to 8th Street Shared Use Path, Bridge, and Lighting

LOG OF BORING SB - 3

PAGE 1 OF 1

 PROJECT NUMBER
 IM-NHU-5-094(132)903
 DATE STARTED
 7/16/19
 COMPLETED
 7/16/19

 PCN
 22219
 ELEVATION
 2467.86 ft
 Easting
 208236.85 ft

 DRILLED BY
 Dallan
 LOGGED BY
 Jamie
 DRILLING METHOD

 ENGINEER
 Engineer
 PRILLING METHOD

NORTH DAKOTA DEPARTMENT OF TRANSPORATION
300 AIRPORT ROAD
Department of Transportation
BISMARCK, ND 58504

NOTES South Abutment Boring SAMPLE TYPE & NUMBER MC **ELEVATION (ft)** RECOVERY (%) GRAPHIC LOG ŢLL DEPTH (ft) AASHTO 20 40 60 80 TESTS & @ SPT N VALUE MATERIAL DESCRIPTION REMARKS ☐ CLAY FRACTION (%) SS 655 SS 656 3TW 657 SS 658 Stiff Silty/Sandy Clay 75 © 70 Ø CU=31.8°, c'=253 psf Con-29-19 50 100 © ·21·····51 2460-3TW 659 × SS 660 SS 661 3TW 50 10-UU=2573 psf 19,36 100 © 14.0 ft 2453.9 ft Dense Silty Sand 85 50 © 100 : 2450-663 3TW 664 SS 665 20-.46 .:⊚.. 100 A-2-4 SM SS 666 SS 667 100 100 2440-36 SS 668 SS A-2-4 SM SS 668
A-2-4 SM SS 669 100 30-74 100 A-2-4 SM SS 670 SS 671 100 78 © 2430-A-2-4 SM SS 672 A-2-4 SM SS 673 100 100 · : A-2-4 SM SS 674 100 2420-100 A-2-4 SM SS 100 50-A-2-4 SM SS 100 A-2-4 SM SS 677 90 60-100 66.0 ft A-2-4 SM SS 678 100 • 2401.9 ft

STATE	PROJECT NO.	SECTION NO.	SHEET NO.	
ND	IM-NHU-5-094(132)903	175	3	

This document was originally issued and sealed by Jared J. Loegering, Registration Number PE-10931, on 12/31/2019 and the original document is stored at the North Dakota Department of Transportation

Boring Log 3

I-94 Business Loop from I-94 to 8th Street Shared Use Path, Bridge, and Lighting